



TIP-TOP TREE FARM EFFLUENT LAND APPLICATION PROJECT CONTRACTS 1, 2, 3, AND 4

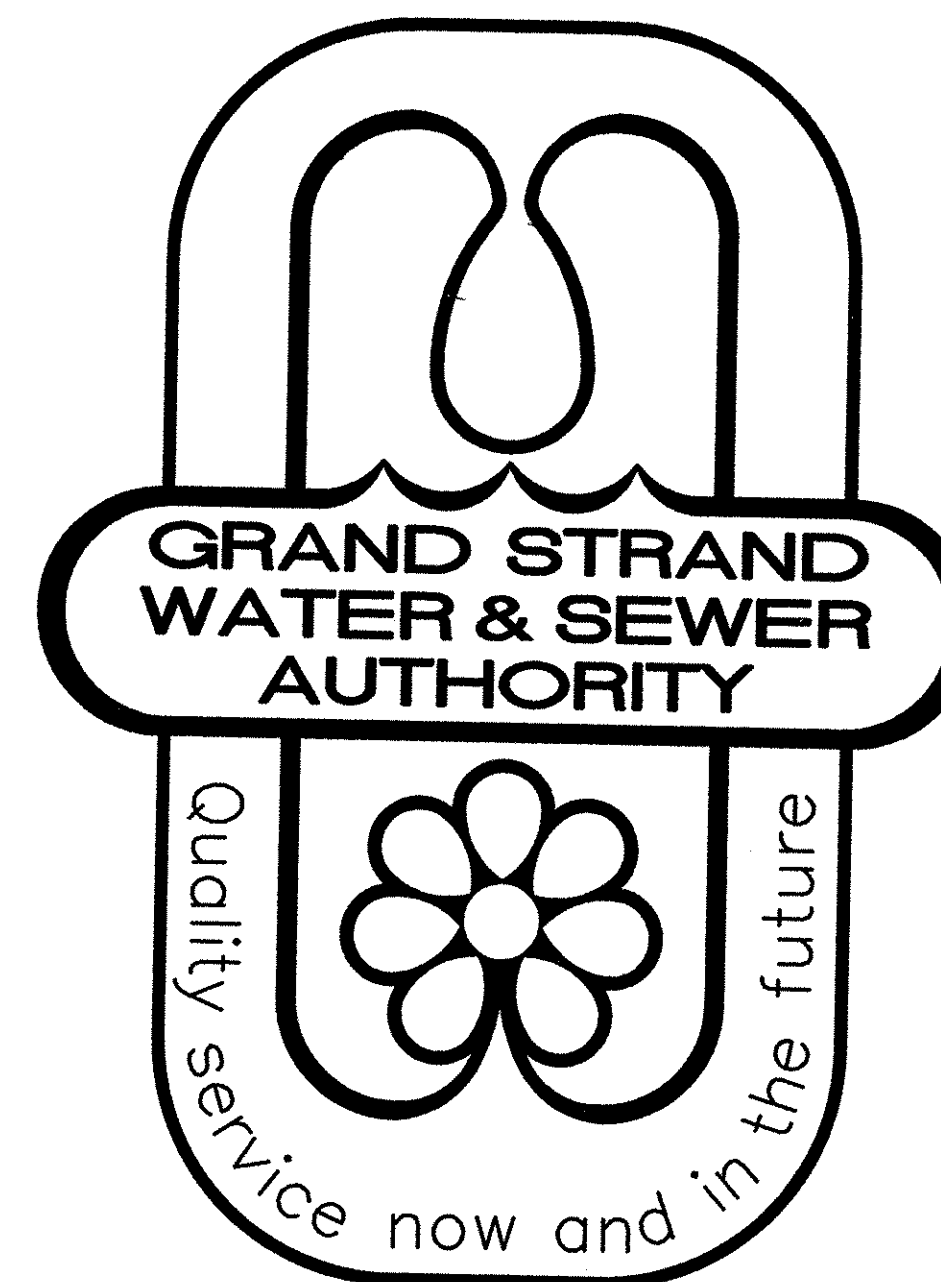

GRAND STRAND WATER AND SEWER AUTHORITY

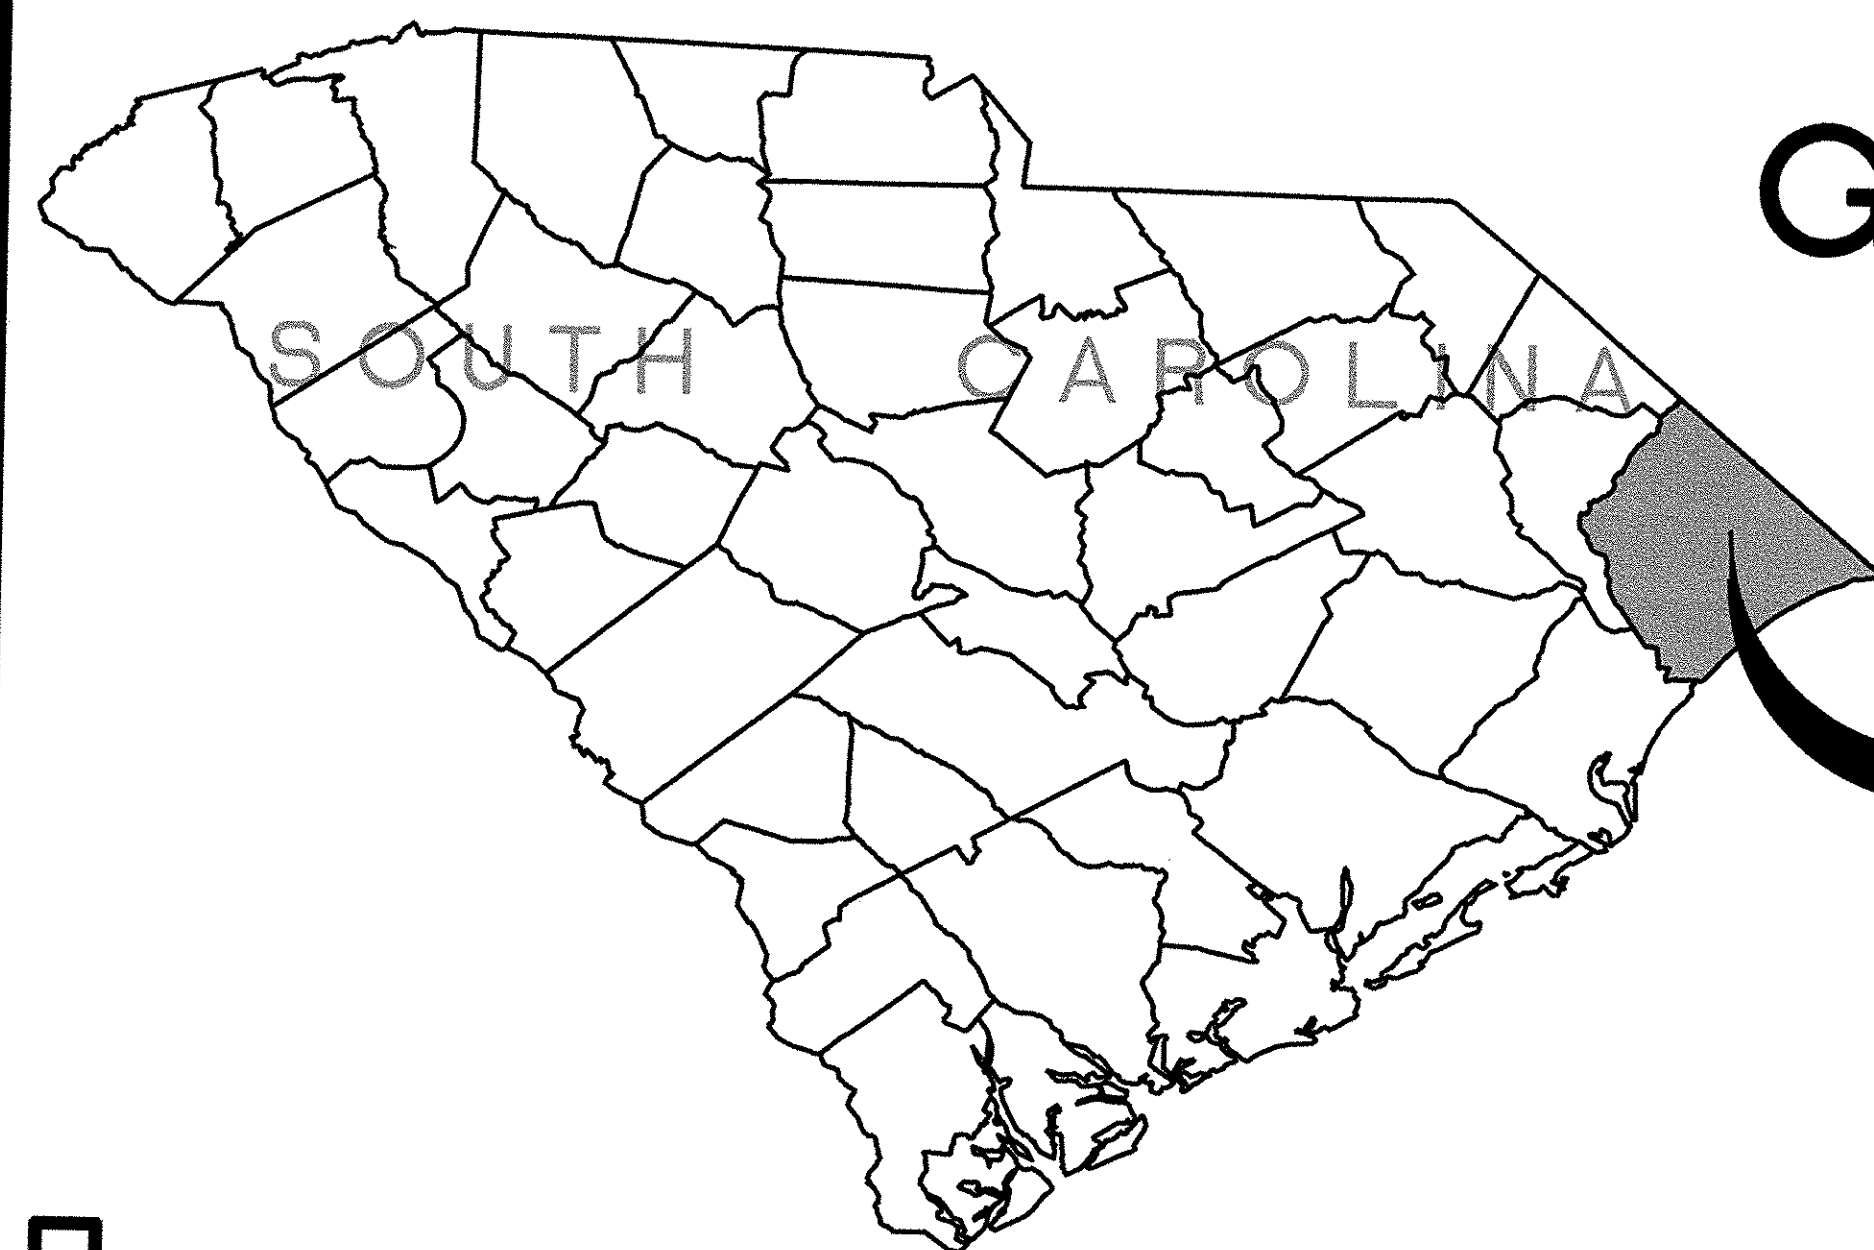



HORRY COUNTY

THESE DRAWINGS REFLECT
AS-BUILT
CONDITIONS

REVIEWED BY: *Fred R. [Signature]* 8-28-2001
(INSPECTIONS) DATE

REVIEWED BY: *Robert E. [Signature]* 8-30-2001
ENGINEERING DATE

GRAND STRAND WATER AND SEWER AUTHORITY

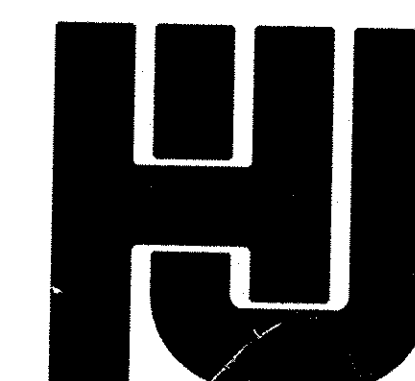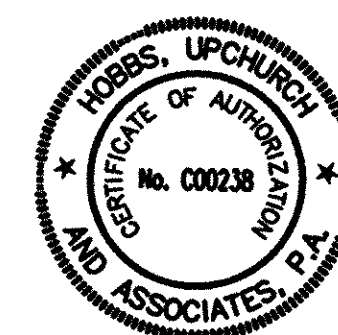

HOBBS, UPCHURCH & ASSOCIATES, P.A.

CONSULTING ENGINEERS

MYRTLE BEACH, SOUTH CAROLINA 29577

THESE DRAWINGS REFLECT
AS-BUILT
CONDITIONS


REVIEWED BY: _____ DATE _____
INSPECTIONS

REVIEWED BY: _____ DATE _____
ENGINEERING



GRAND STRAND WATER AND SEWER AUTHORITY

SECTION/DETAIL LEGEND

DETAIL CALL-OUT
AND DETAIL TITLE
IDENTIFICATION
SYMBOL

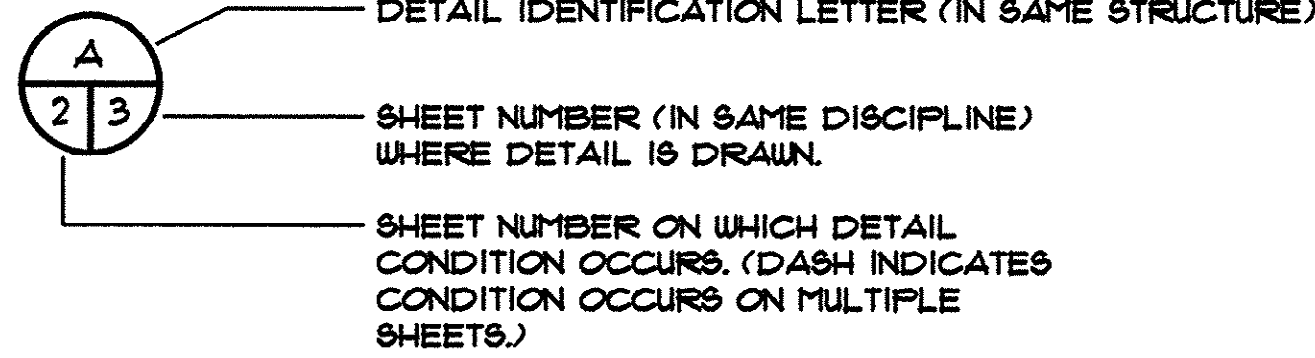

SECTION CUT SYMBOL
(w/ARROW) OR TITLE
IDENTIFICATION SYMBOL
(w/o ARROW)

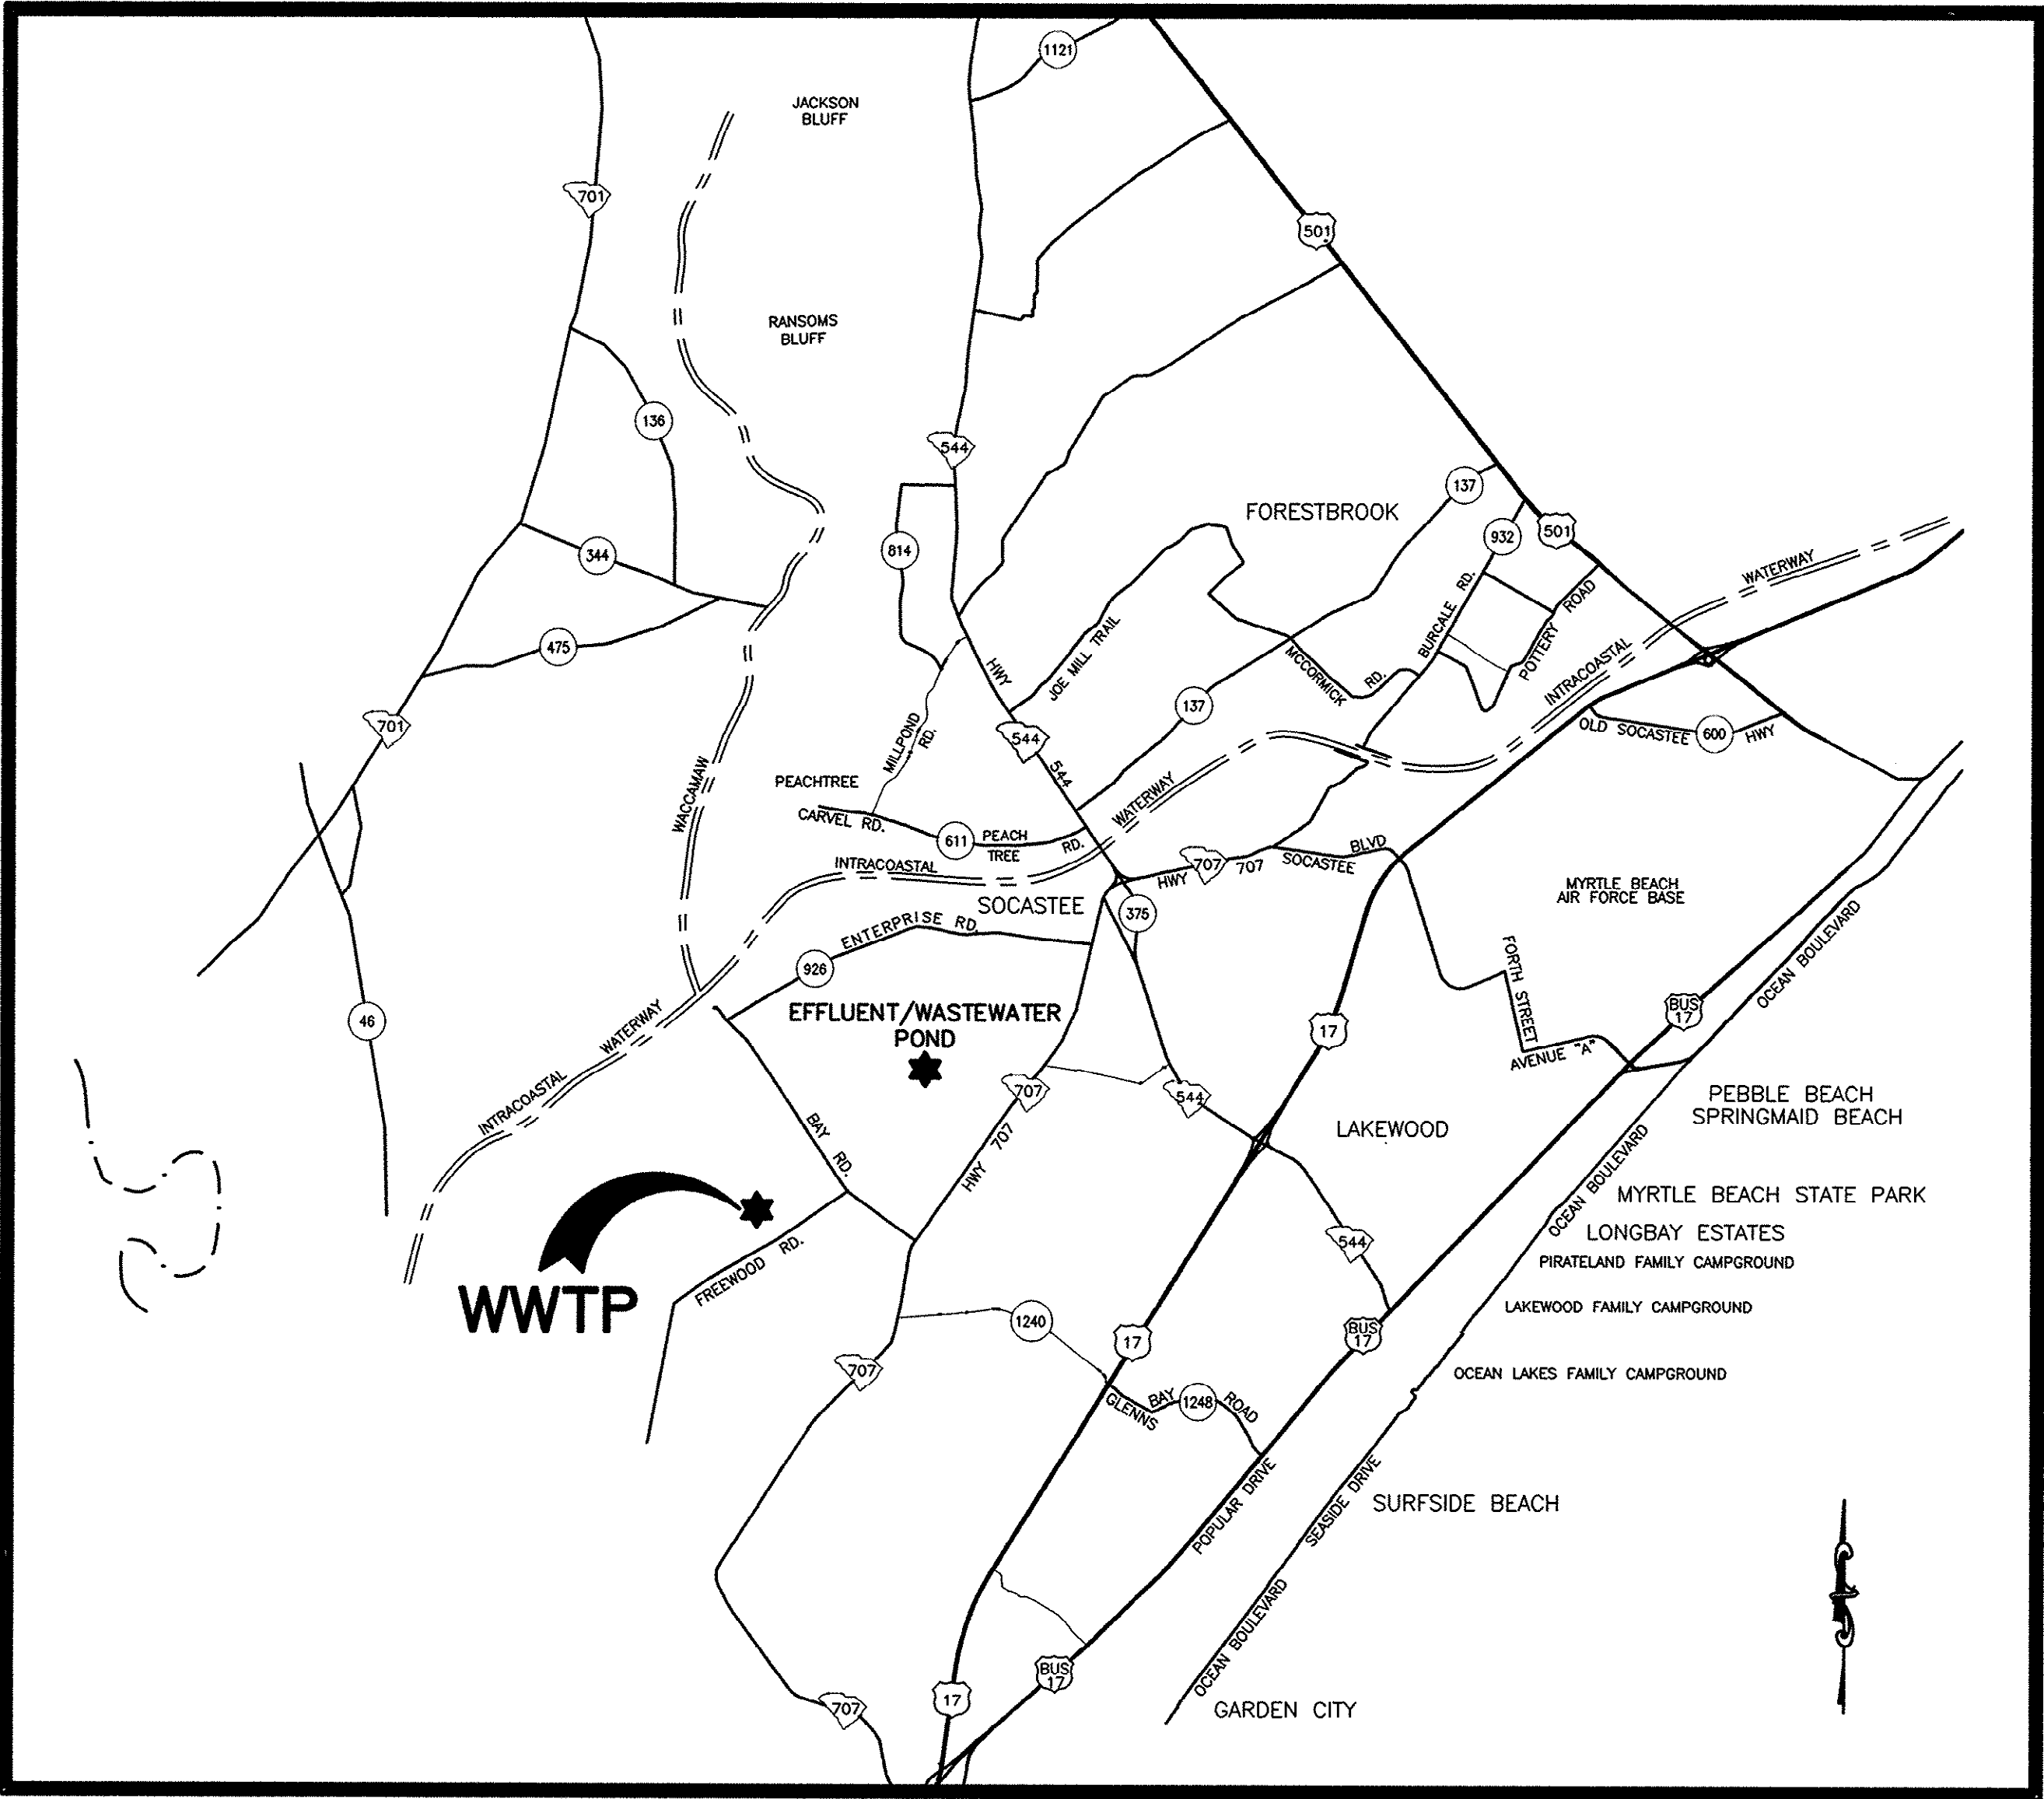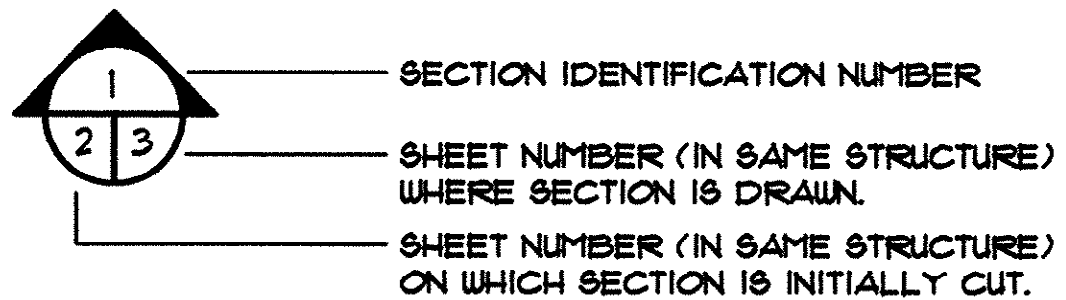

VICINITY MAP
N.T.S.

GENERAL CONSTRUCTION ABBREVIATIONS

•	NUMBER OR POUND	D	DIAMETER	INFL	INFLUENT	R.C.P.	REINFORCED CONCRETE PIPE
◊	DIAMETER	DIA	DIAMETER	INS.	INSIDE	RAD.	RADIUS
+	AND	D.I.P.	DUCTILE IRON PIPE	INV.	INVERT	RAS	RETURN ACTIVATED SLUDGE
<	LESS THAN	DISCH.	DISCHARGE	JT.	JOINT	RED	REDUCER
>=	LESS THAN OR EQUAL TO	DP	DEEP	JTS	JOINTS	REF	REFERENCE
≧	GREATER THAN	DWLS.	DOWELS	L.L.O.	LONG LEG OUT	REINF	REINFORCING OR REINFORCED
•	AT	EF.	EACH FACE	LB	FOUND	REQ'D	REQUIRED
A.B.	ANCHOR BOLT	E.J.	EXPANSION JOINT	LG	LONG	SS.	STAINLESS STEEL
AFF.	ABOVE FINISHED FLOOR	EA	EACH	L.P.	LOW POINT	SCH.	SCHEDULE
ADDL	ADDITIONAL	EFF.	EFFLUENT	M.J.	MECHANICAL JOINT	SHT	SHEET
ALUM	ALUMINUM OR ALUM	EL	ELEVATION	MATL.	MATERIAL	SIM	SIMILAR
APPROX	APPROXIMATE(LY)	ELEV	ELEVATION	MAS	MASONRY	SO2	SULFUR DIOXIDE
ARCH	ARCHITECTURAL	EQ	EQUAL	MAX	MAXIMUM	SFA	SPACES
BM	BENCH MARK OR BEAM	EQUIP	EQUIPMENT	MECH	MECHANICAL	SQ.	SQUARE
BOTT.	BOTTOM	EXIST.	EXISTING	MFR	MANUFACTURER	STD.	STANDARD
B.W.	BLOCK WALL	EXP.	EXPANSION	MH	MANHOLE	STL	STEEL
C.I.	CAST IRON	F.E.S.	FLARED END SECTION	MIN	MINIMUM	STN	STAINLESS
C/C	CENTER TO CENTER	F.R.P.	FIBERGLASS REINFORCED PLASTIC	MNTG	MOUNTING	S.W.	SLAB WIDTH
CAP	CAPACITY	FIG	FIGURE	N.P.W.	NONPOTABLE WATER	S.W.D.	SIDE WALL DEPTH
CIRCUM	CIRCUMFERENCE	FIN	FINISHED	N.T.S.	NOT TO SCALE	T/	TOP OF
CL	CLAY	FL	FLANGE	NO.	NUMBER	TCJ/CJ	TYP. CONTROL JOINT, CONSTRUCTION JOINT
CLR	CLEARANCE	FLR	FLOOR	O.C.	ON CENTER	THRD	THREAD(S)XED)
C.	CENTERLINE	FTG	FOOTING	O/O	OUTSIDE TO OUTSIDE	TRICK	TRICKLING
CL2	CHLORINE	GALV	GALVANIZED	OFNG	OPENING	TYP	TYPICAL
CLARIF	CLARIFIER	HDWE	HARDWARE	OX	OXIDATION	U.O.N.	UNLESS OTHERWISE NOTED
CHEM.	CHEMICAL	HK	HOOK	P.E.	PLAIN END	VERT	VERTICAL
COL	COLUMN	HORIZ.	HORIZONTAL	FED	FEDESTAL	W.W.F.	WELDED WIRE FABRIC
CONC.	CONCRETE	H.P.	HIGH POINT	FL	FLATE	W/	WITH
CONST	CONSTRUCTION	HYD	HYDRANT	FLCS.	PLACES	W/O	WITHOUT
CONT	CONTINUOUS	I.D.	INSIDE DIAMETER	PROJ	PROJECTION	WAS	WASTE ACTIVATED SLUDGE
CONTR	CONTRACTOR	O.D.	OUTSIDE DIAMETER	P.S.	PUMP STATION	W/L	WATER LEVEL
CU	COPPER			P.V.C.	POLYVINYLCHLORIDE		
C.W.	CONCRETE WALL						

INDEX OF SHEETS

- G-1 - COVER SHEET

G-2 - VICINITY MAP AND INDEX

G-3 - HYDRAULIC PROFILE

G-4 - SITE DEMOLITION PLAN

G-5 - SITE MODIFICATION PLAN

G-6 - DEEP BED SAND FILTERS PLAN VIEWS

G-7 - DEEP BED SAND FILTERS SECTIONS AND DETAILS

G-8 - DEEP BED SAND FILTERS AIR LINE SCHEMATIC AND CONTROL PANEL DETAILS

G-9 - EXIST. EFFLUENT CONTROL STRUCTURE PUMP AND PIPING ADDITION AND DETAILS

G-10 - IRRIGATION BOOSTER PUMP STATION PLAN/ EXTERIOR ELEVATIONS AND DETAILS

G-11 - DISTRIBUTION HEADER AND BUILDING LAYOUT

G-12 - IRRIGATION BOOSTER PUMP STATION PUMP ELEVATION AND BUILDING DETAILS

G-13 - IRRIGATION BOOSTER PUMP STATION FOUNDATION PLAN AND DETAILS

G-14 - SITE PLANS AND FILTER DRAIN PUMP STATION PLAN AND SECTION

G-15 - STRUCTURAL DETAILS/GENERAL NOTES

G-16 - MISCELLANEOUS DETAILS

AER-1 - EXISTING EFFLUENT WASTE WATER POND AND AERATOR DETAILS

EFF-1 - LAYOUT MAP

EFF-2 TO EFF-21 - EFFLUENT MAIN PLAN AND PROFILE
- DT-1 - MISCELLANEOUS DETAILS

DT-2 - MISCELLANEOUS DETAILS

DT-3 - MISCELLANEOUS DETAILS

DT-4 - MISCELLANEOUS DETAILS

DT-5 - EROSION CONTROL DETAILS

E-1 - SYMBOL SCHEDULE, EQUIPMENT SCHEDULE AND DETAILS

E-2 - IRRIGATION BOOSTER PUMP STATION ONE-LINE-POWER DIAGRAM

E-3 - IRRIGATION BOOSTER PUMP STATION ELECTRICAL PLAN AND DIAGRAMS

E-4 - PUMP STATION ELECTRICAL LIGHTING PLAN

E-5 - SCHWARTZ W.W.T.P. ELECTRICAL SITE PLAN

E-6 - SCHWARTZ W.W.T.P. POWER RISER DIAGRAM

E-7 - SCHWARTZ W.W.T.P. EFFLUENT CONTROL STRUCTURE ELECTRICAL WORK

E-8 - SCHWARTZ W.W.T.P. DEEP BED SAND FILTERS ELECTRICAL WORK

E-9 - HEADER BUILDING ELECTRICAL PLANS AND DETAILS

E-10 - MISCELLANEOUS DETAILS

VICINITY MAP
AND INDEX

TIP-TOP TREE FARM
EFFLUENT LAND
APPLICATION PROJECT
GRAND STRAND WATER
AND SEWER AUTHORITY

DATE: MAR. 1999

DESIGNED: JWM

DRAWN: DC

CHECKED: JWM

SCALE: AS SHOWN


SHEET NO.

G-2

16

45-003-002/53

HOBBS, UPCHURCH & ASSOC. MB J:\SS9801\800\820 G-DWG\AB-G-03.dwg EDITED BY: ARADON DATE: 08/28/01 TIME: 14:30 Layout: Model

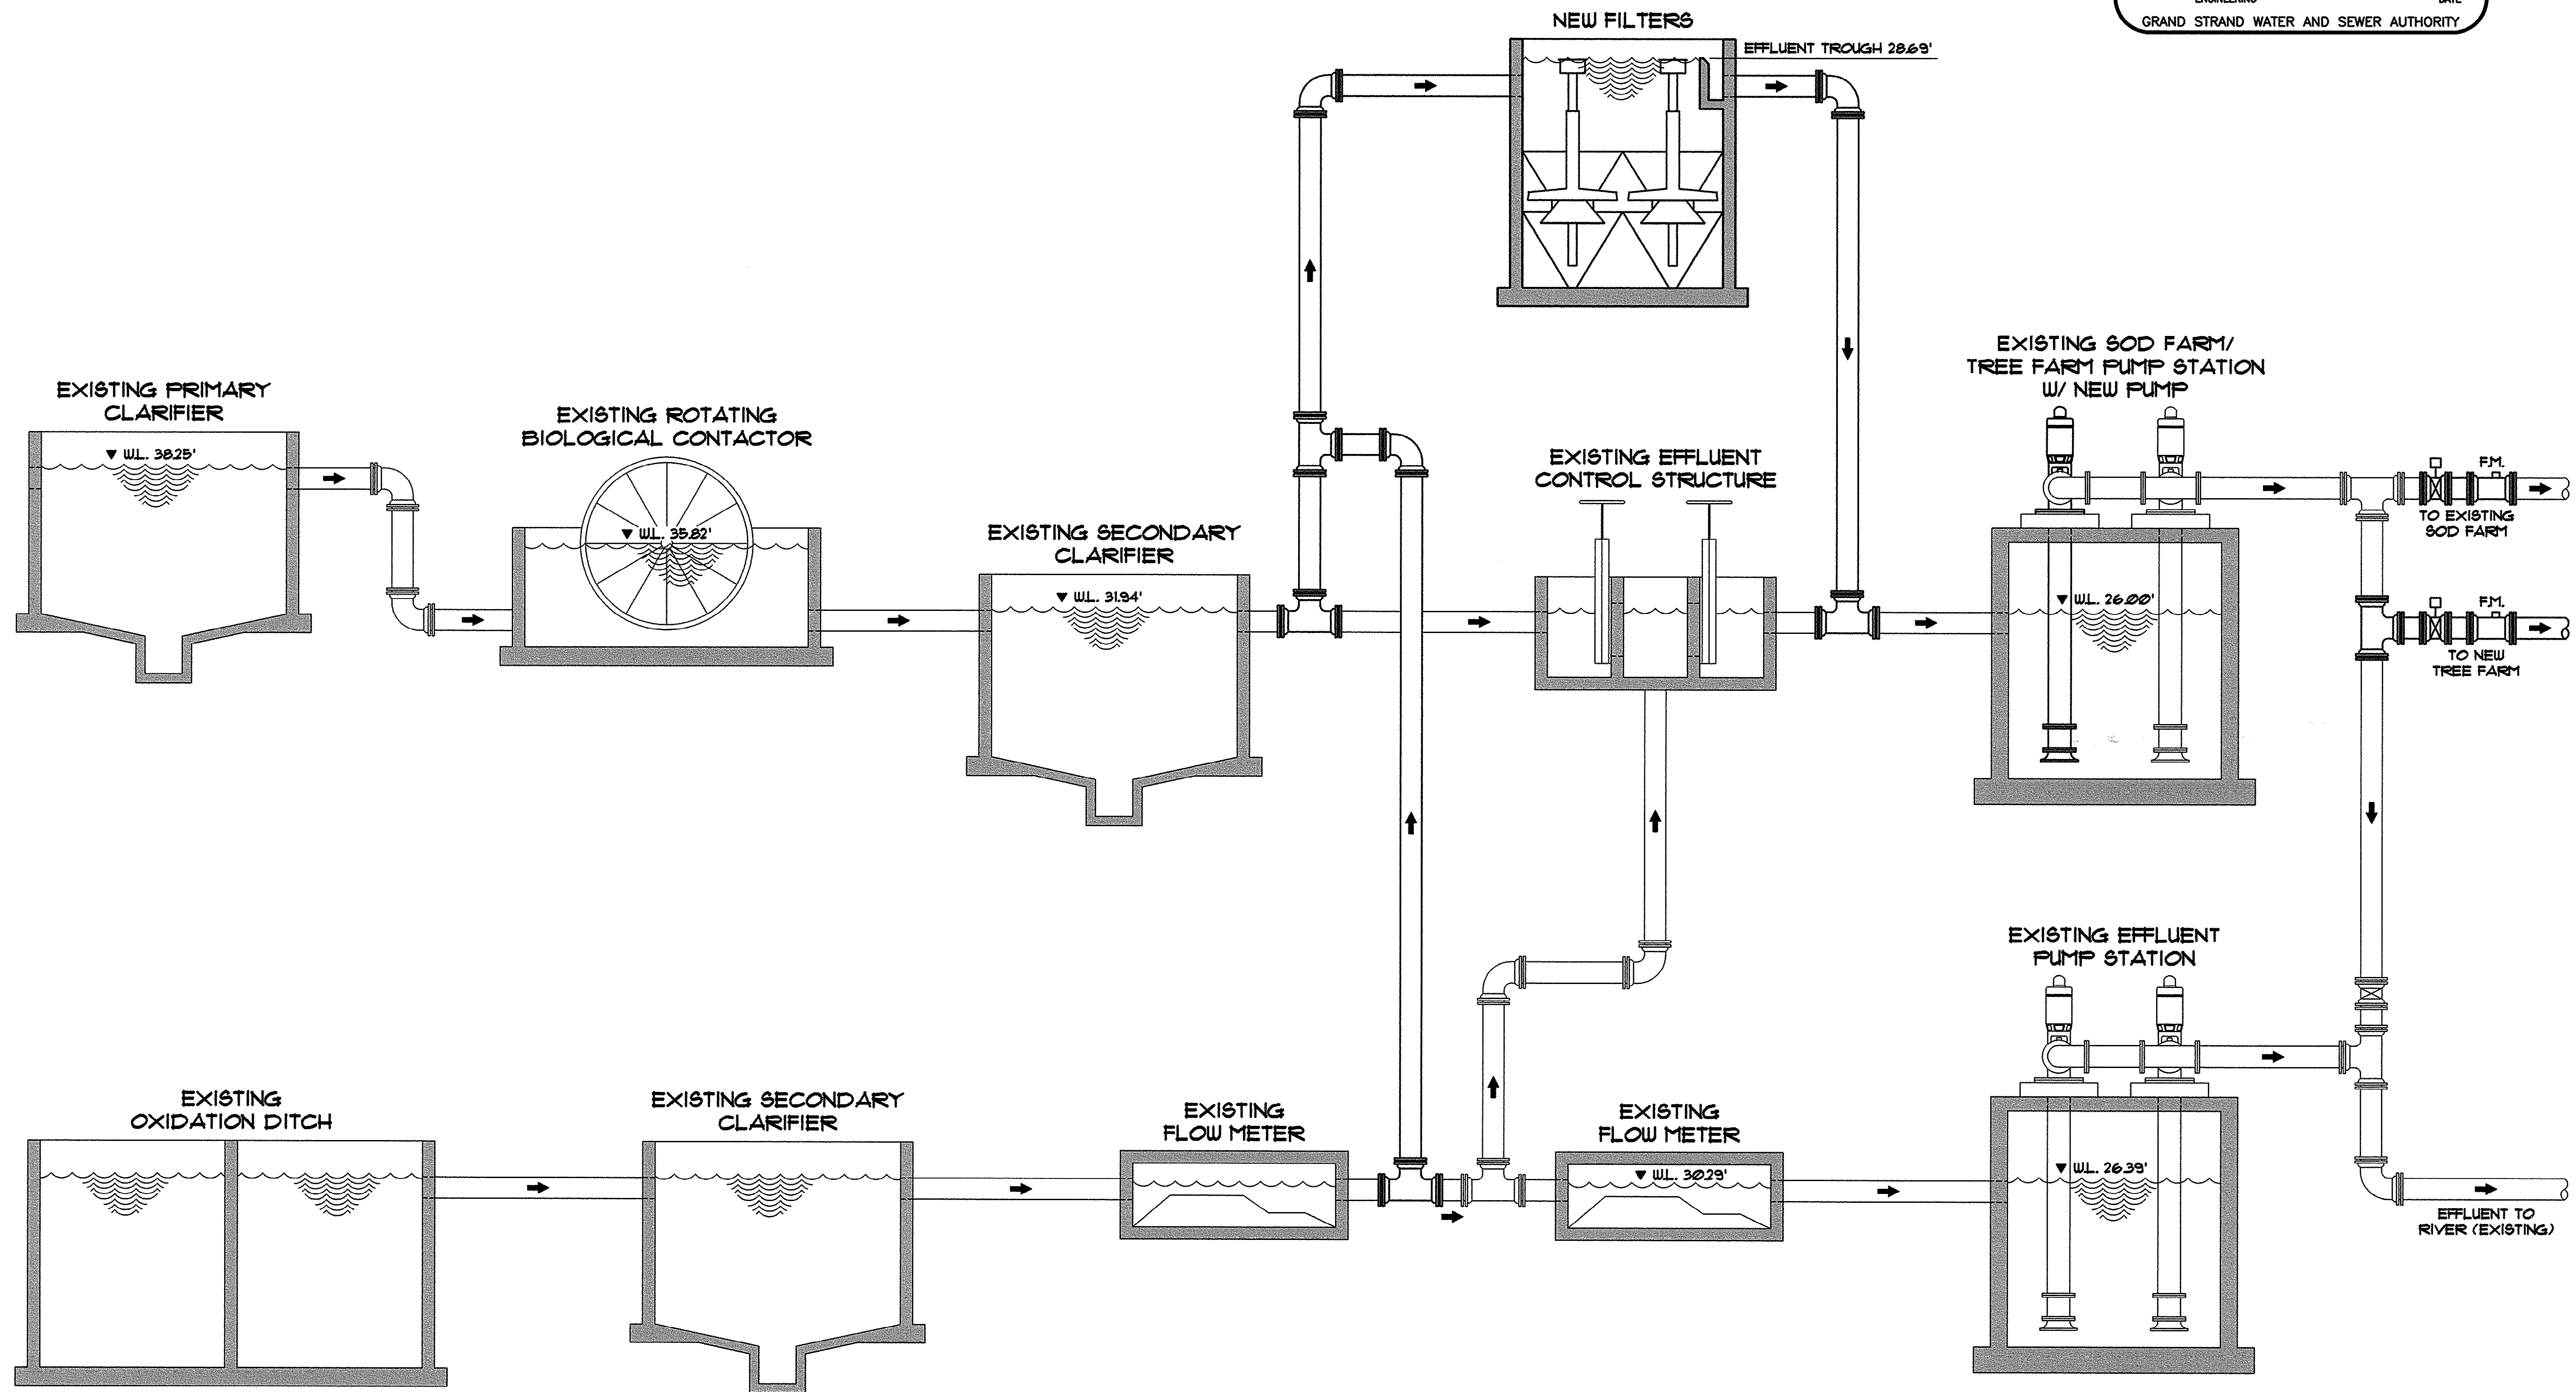


HYDRAULIC PROFILE
N.T.S.

THESE DRAWINGS REFLECT
AS-BUILT
CONDITIONS

REVIEWED BY:	INSPECTIONS	DATE
REVIEWED BY:	ENGINEERING	DATE

GRAND STRAND WATER AND SEWER AUTHORITY

REVISIONS	DATE	BY
DESCRIPTION	8/28/01	CAR
AS-BUILT		

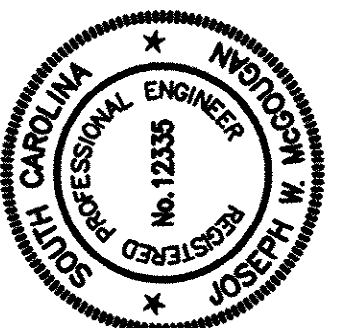

HOBBS, UPCHURCH & ASSOCIATES, P.A.
CONSULTING ENGINEERS
MYRTLE BEACH, SOUTH CAROLINA 29577


HYDRAULIC PROFILE

TIP-TOP TREE FARM
EFFLUENT LAND
APPLICATION PROJECT
GRAND STRAND WATER
AND SEWER AUTHORITY


DATE:	MAR. 1999
DESIGNED:	JWM
DRAWN:	DC
CHECKED:	JWM
SCALE:	AS SHOWN

45-003-003/53

HOBBS, UPCHURCH & ASSOC. MB J:\GSP901\6001820\G-DWGS\AB-G-04.dwg EDITED BY: ARABON DATE: 08/29/01 TIME: 11:03 Layout: Model

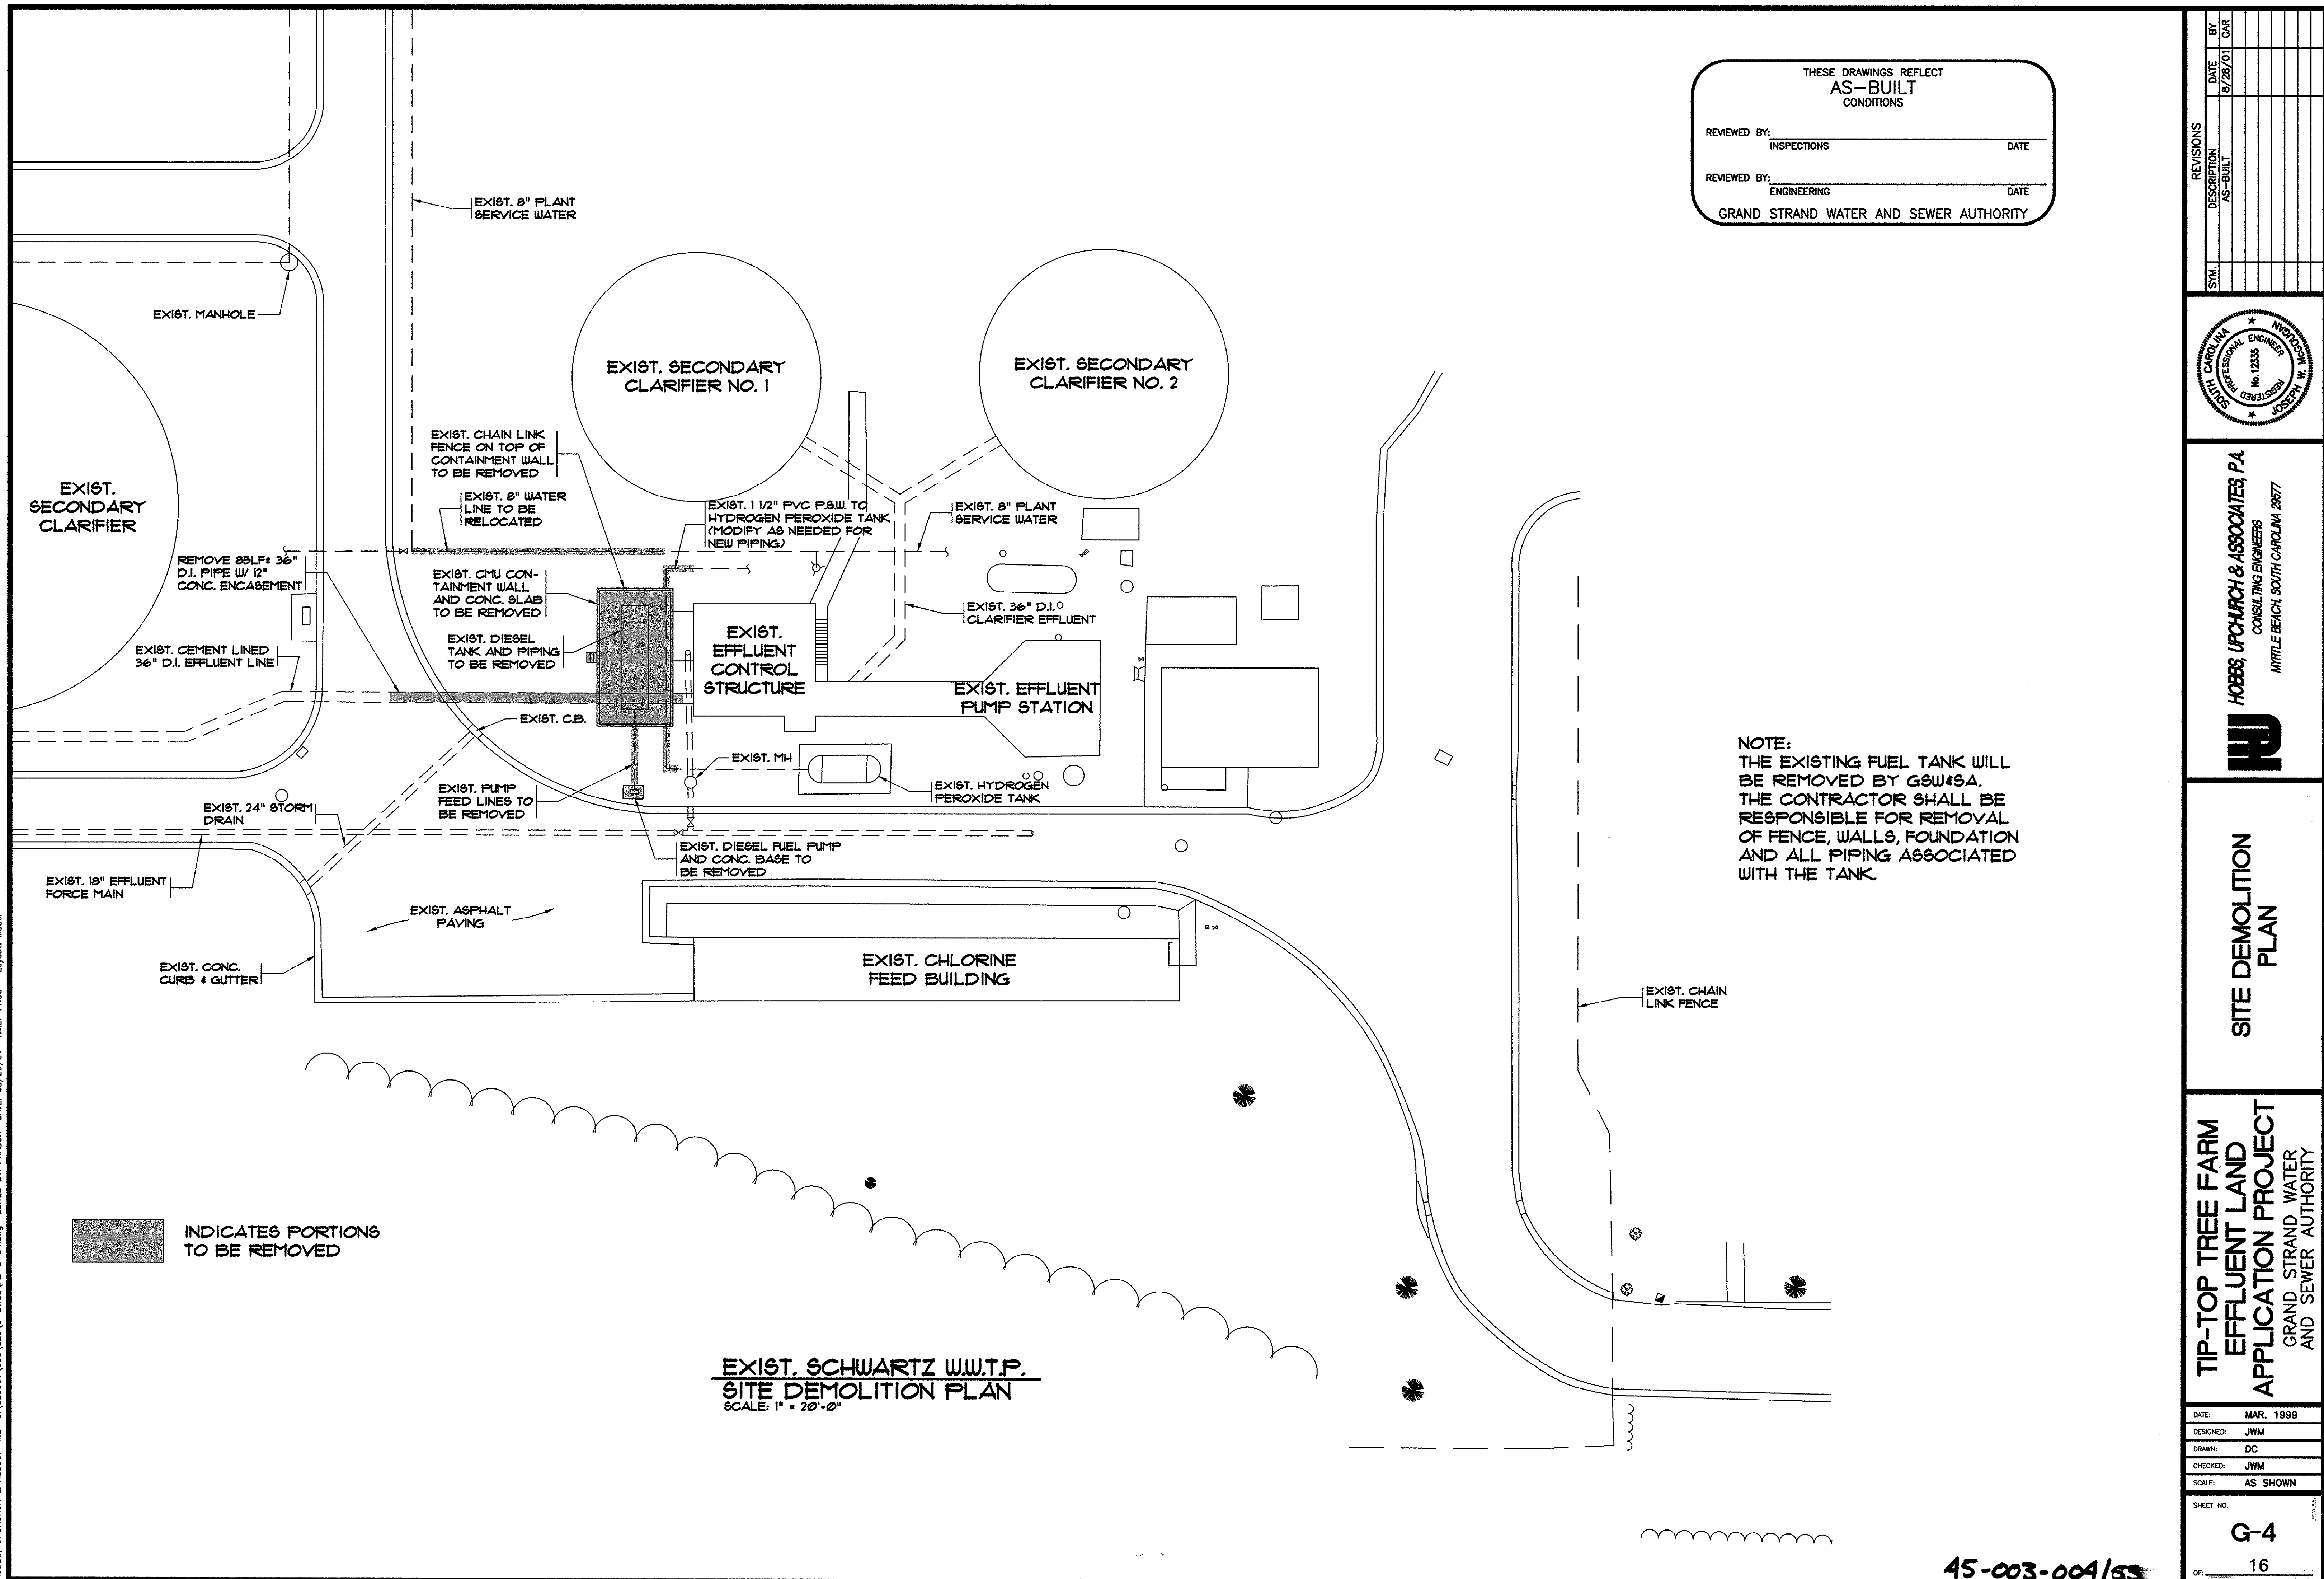

HOBBS, UPCHURCH & ASSOC. MB J:\G59901\800\820\G-05.dwg EDITED BY: ARAGON DATE: 08/29/01 TIME: 11:04 Layout Model

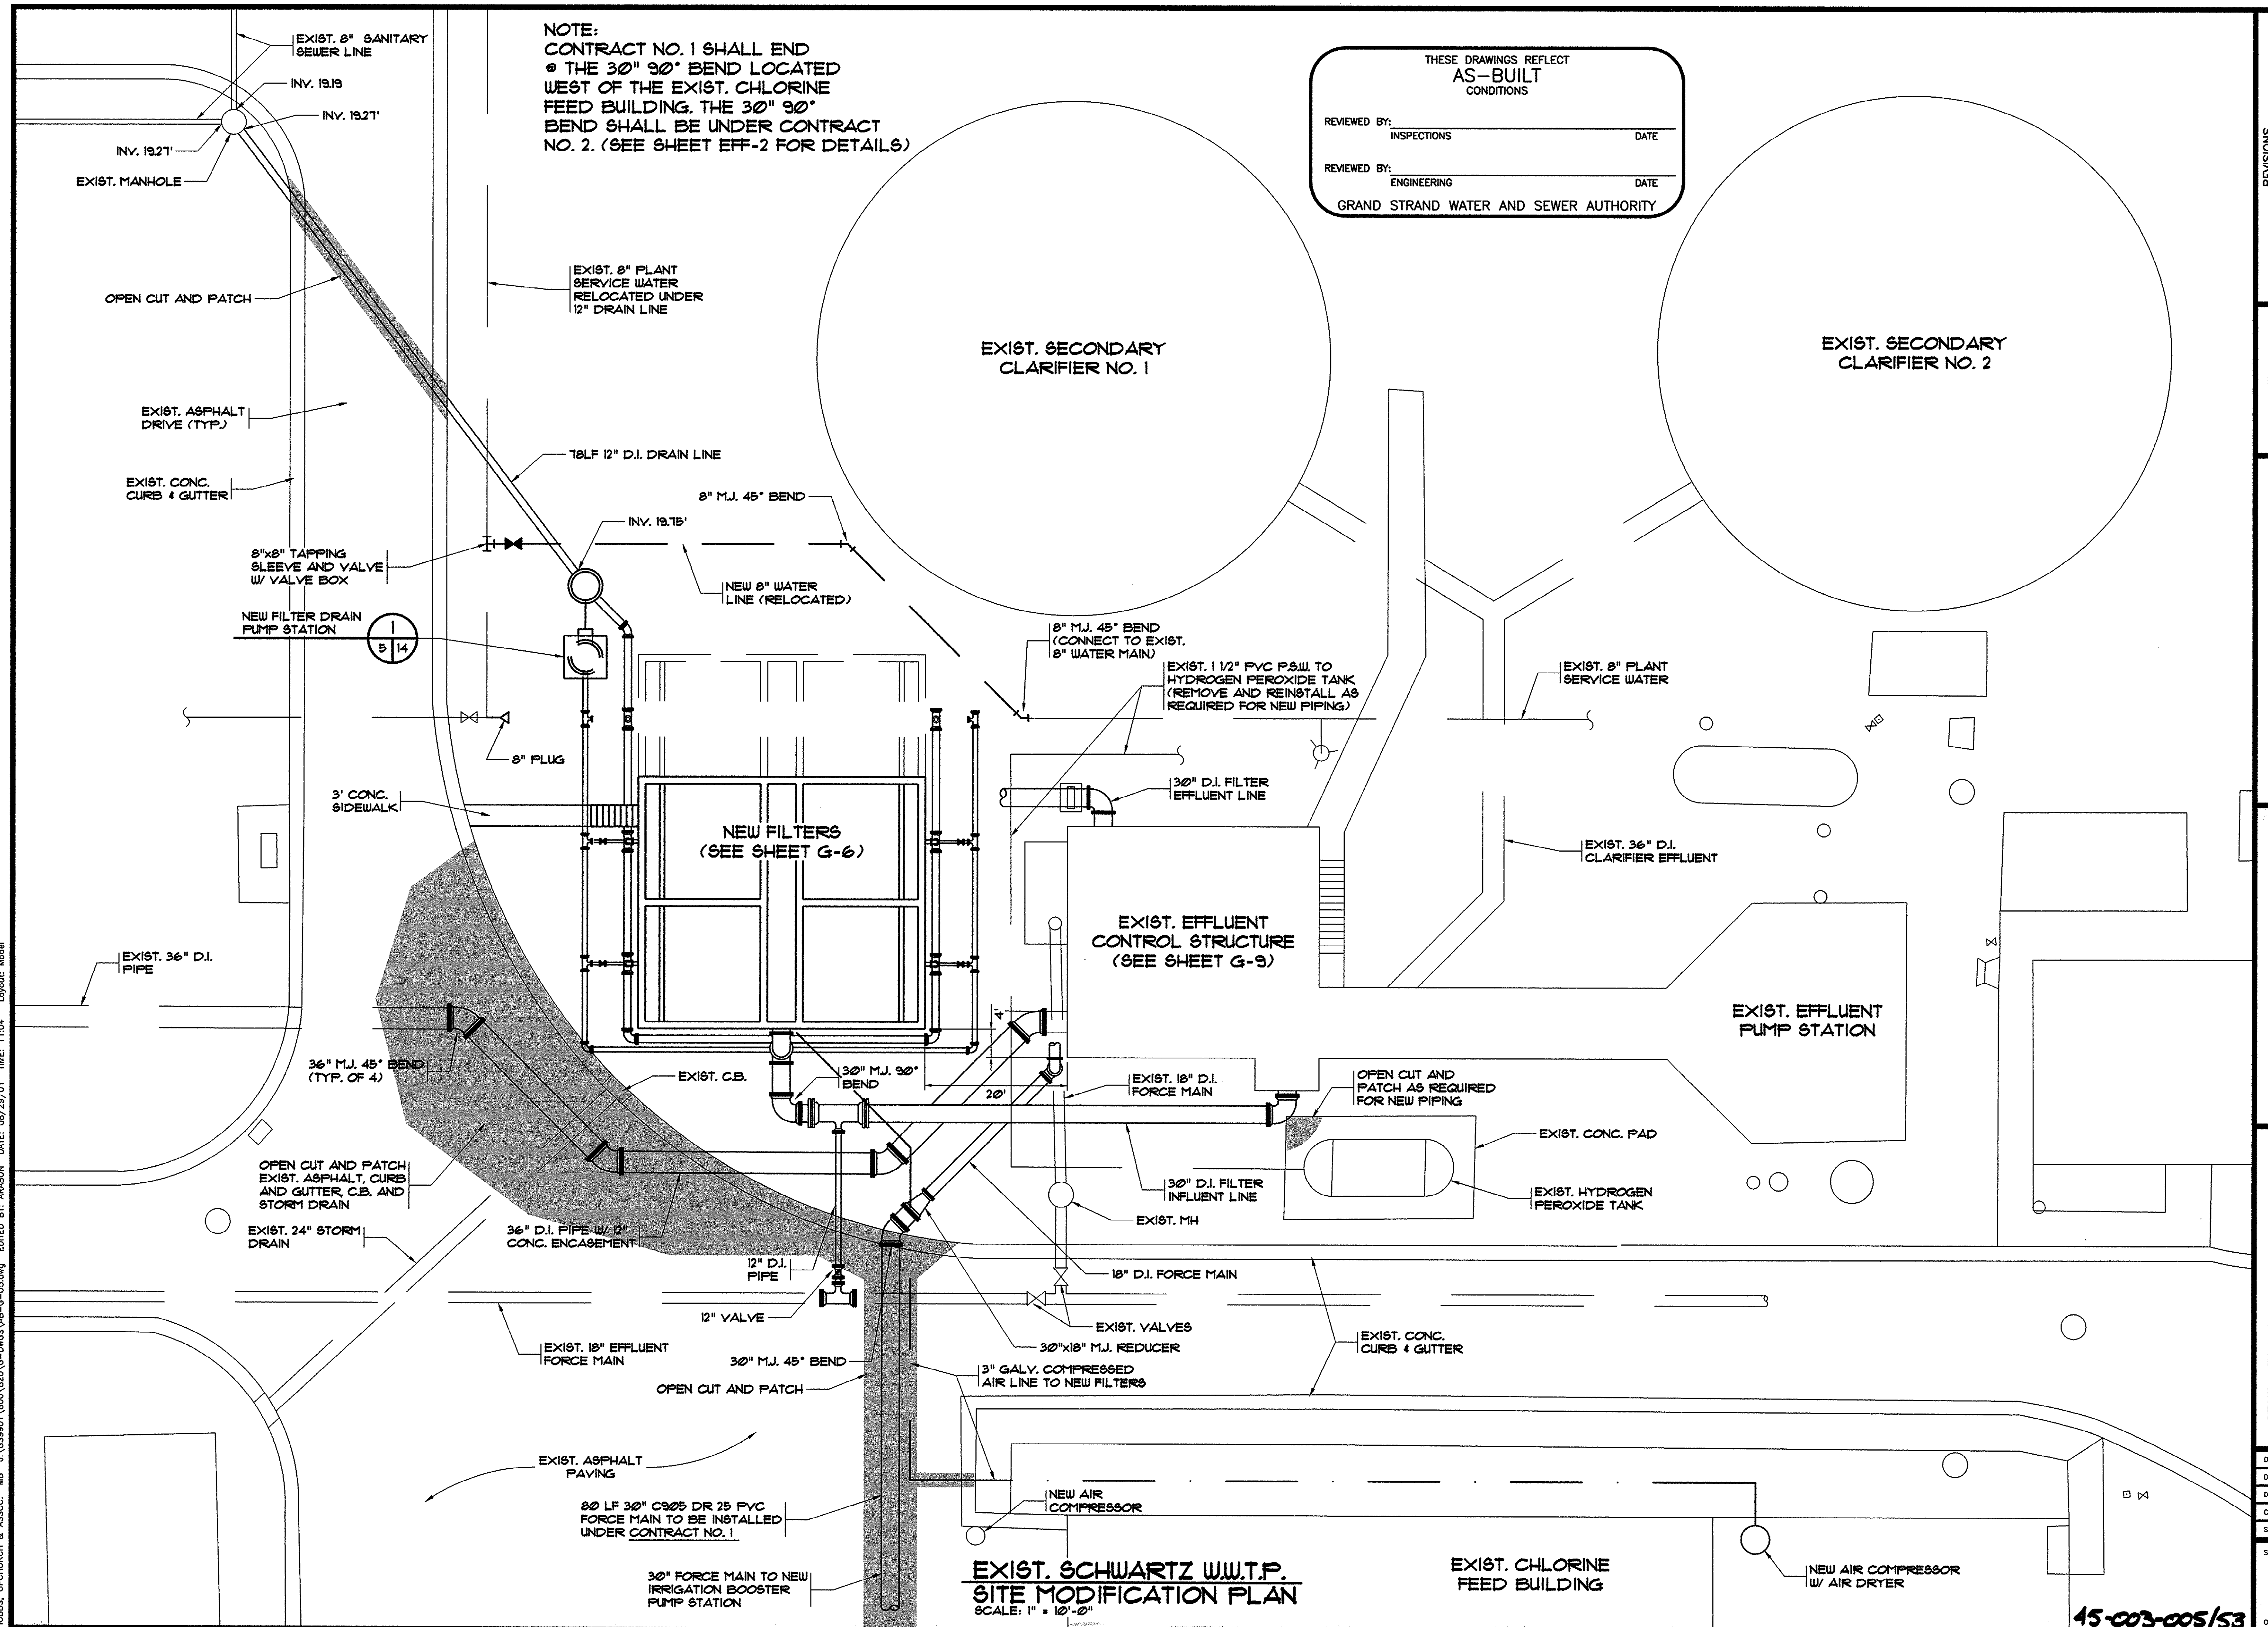


THESE DRAWINGS REFLECT
AS-BUILT
CONDITIONS

REVIEWED BY:	INSPECTIONS	DATE
REVIEWED BY:	ENGINEERING	DATE

GRAND STRAND WATER AND SEWER AUTHORITY

SYMBOL	DESCRIPTION	DATE	BY
	NOTES ADDED	9/13/99	JWM
	AS-BUILT	8/29/01	CAR

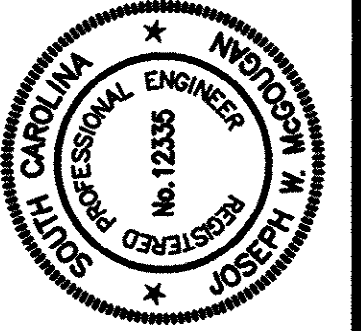

HOBBS, UPCHURCH & ASSOCIATES, P.A.
CONSULTING ENGINEERS
MYRTLE BEACH, SOUTH CAROLINA 29577


SITE MODIFICATION
PLAN

TIP-TOP TREE FARM
EFFLUENT LAND
APPLICATION PROJECT
GRAND STRAND WATER
AND SEWER AUTHORITY


DATE:	MAR. 1999
DESIGNED:	JWM
DRAWN:	DC
CHECKED:	JWM
SCALE:	AS SHOWN

45-003-005/53


HOBBS, UPCHURCH & ASSOC. MB J:\GS9801\800\820\G-DWGS\AB-G-08.dwg EDITED BY: ARABON DATE: 08/29/01 TIME: 11:09 Layout Model

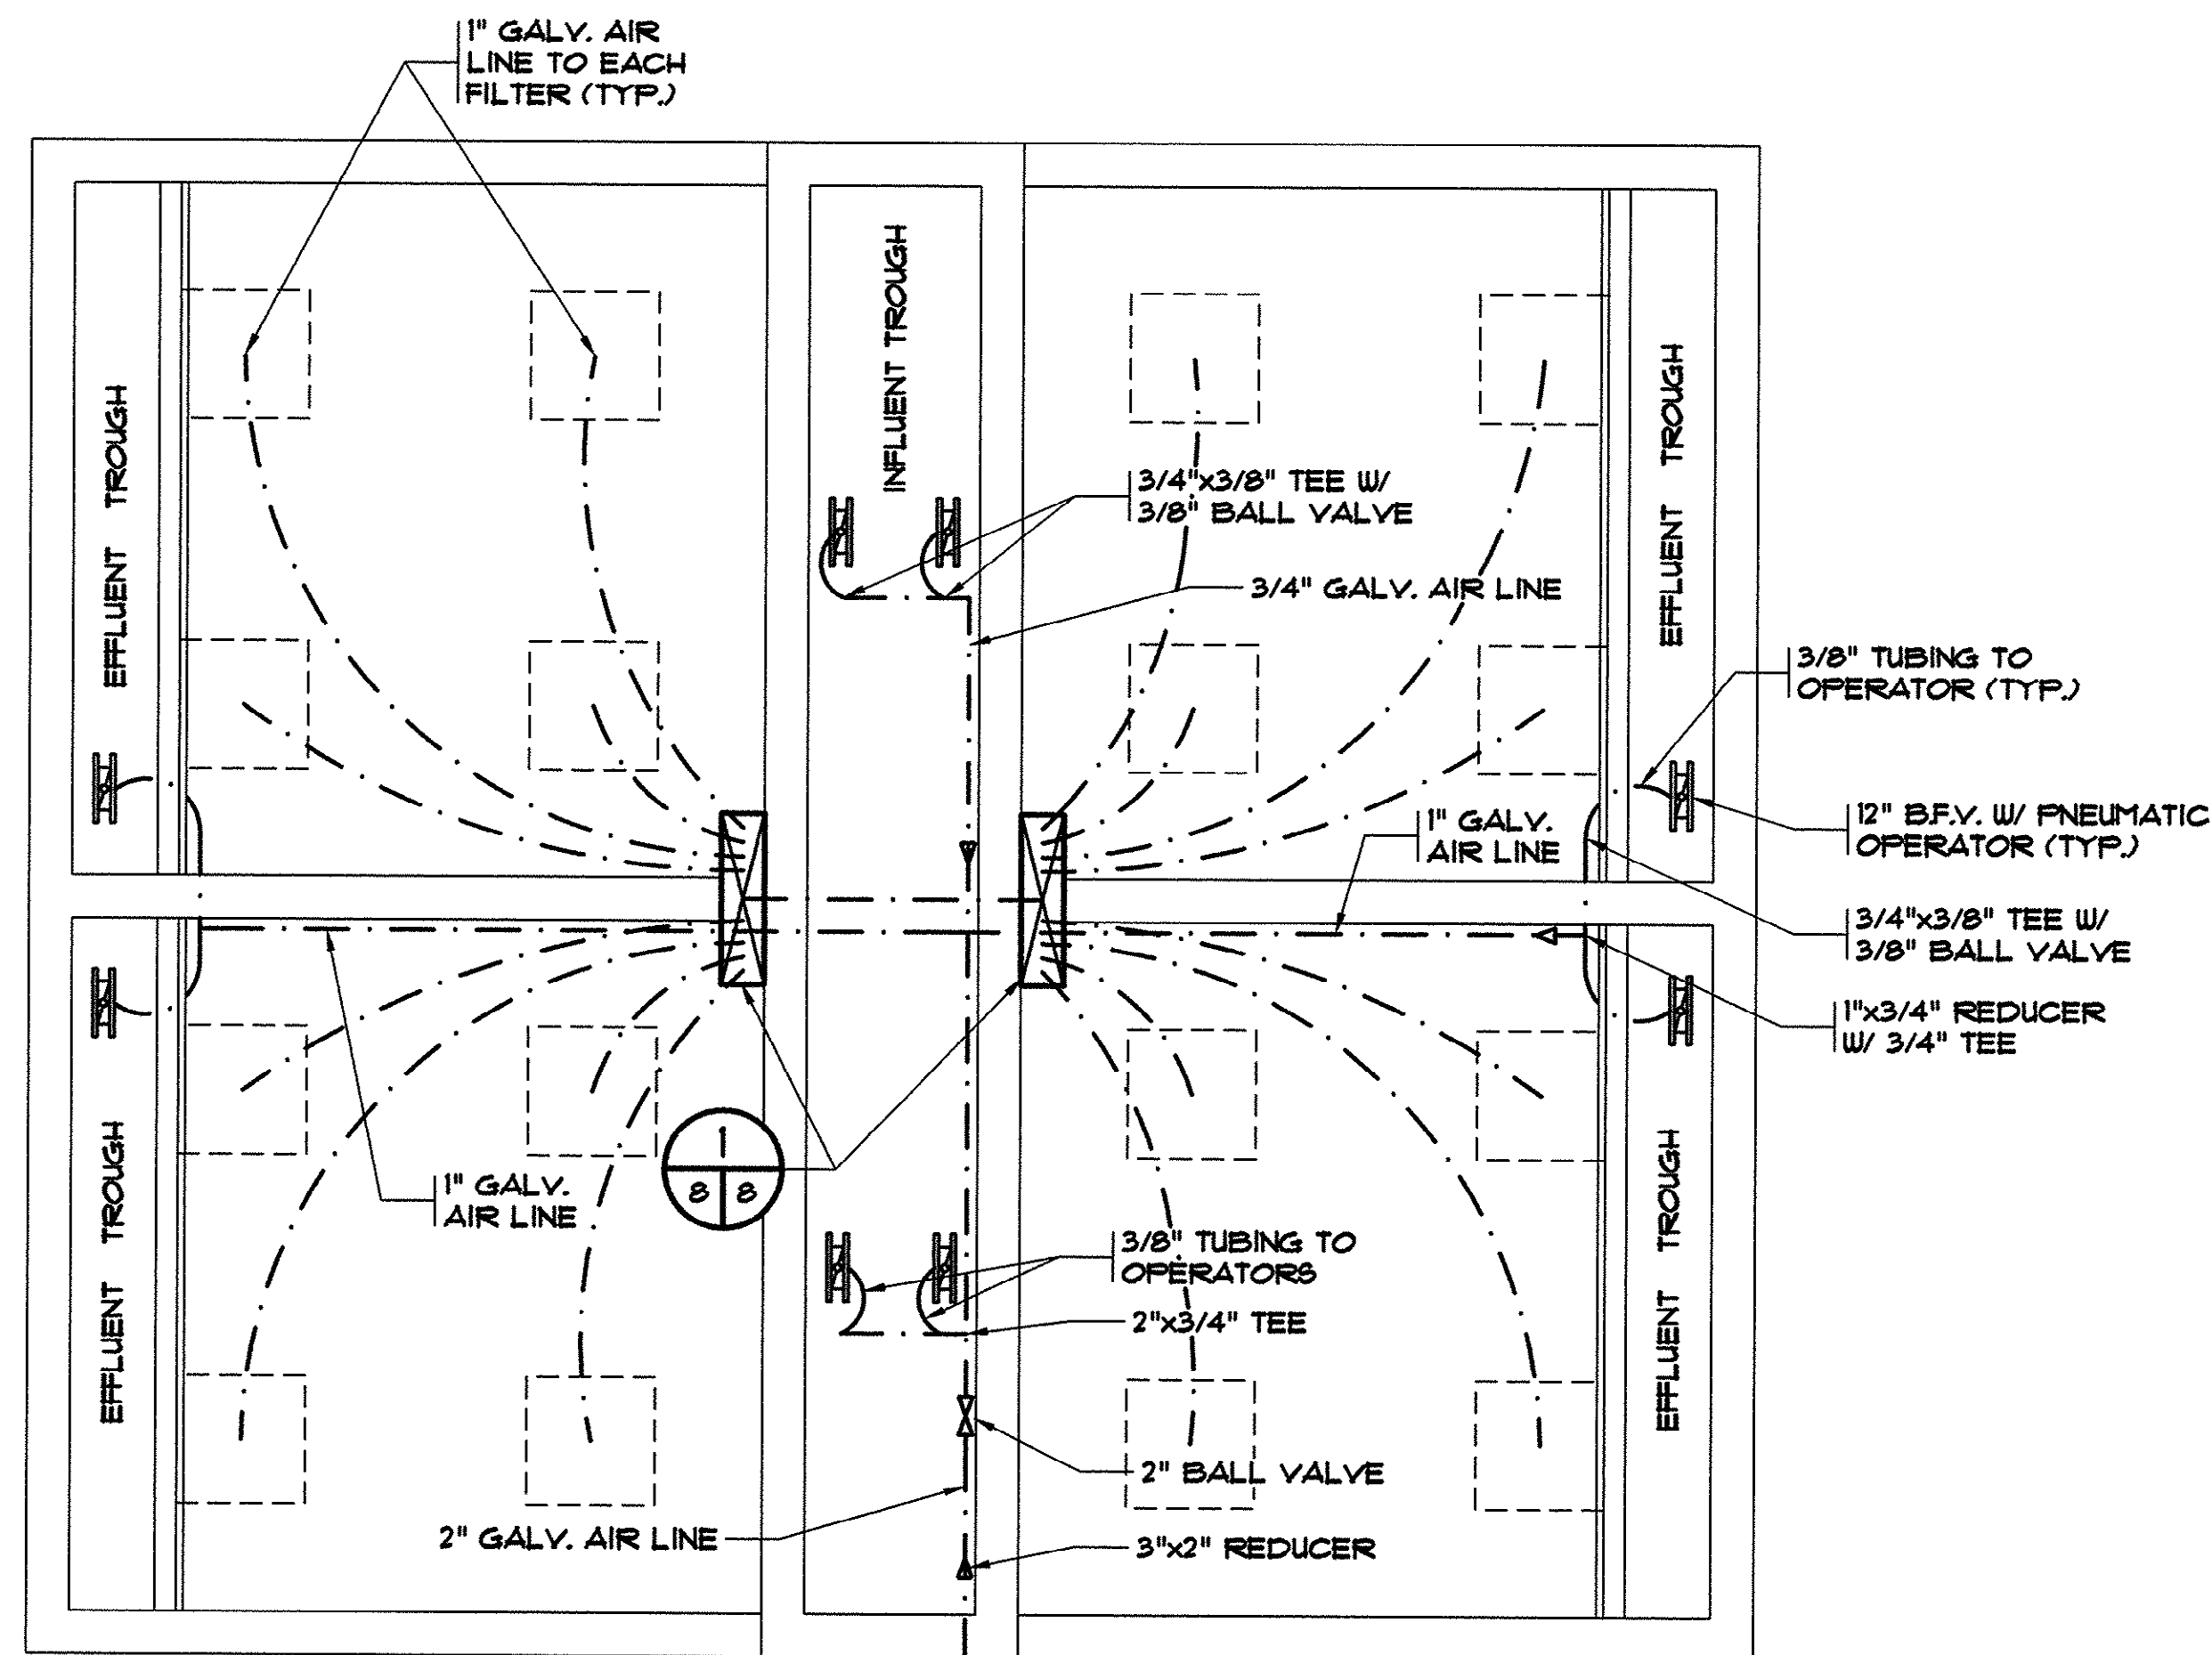


**DEEP BED SAND FILTERS
AIR LINE SCHEMATIC**
N.T.S.

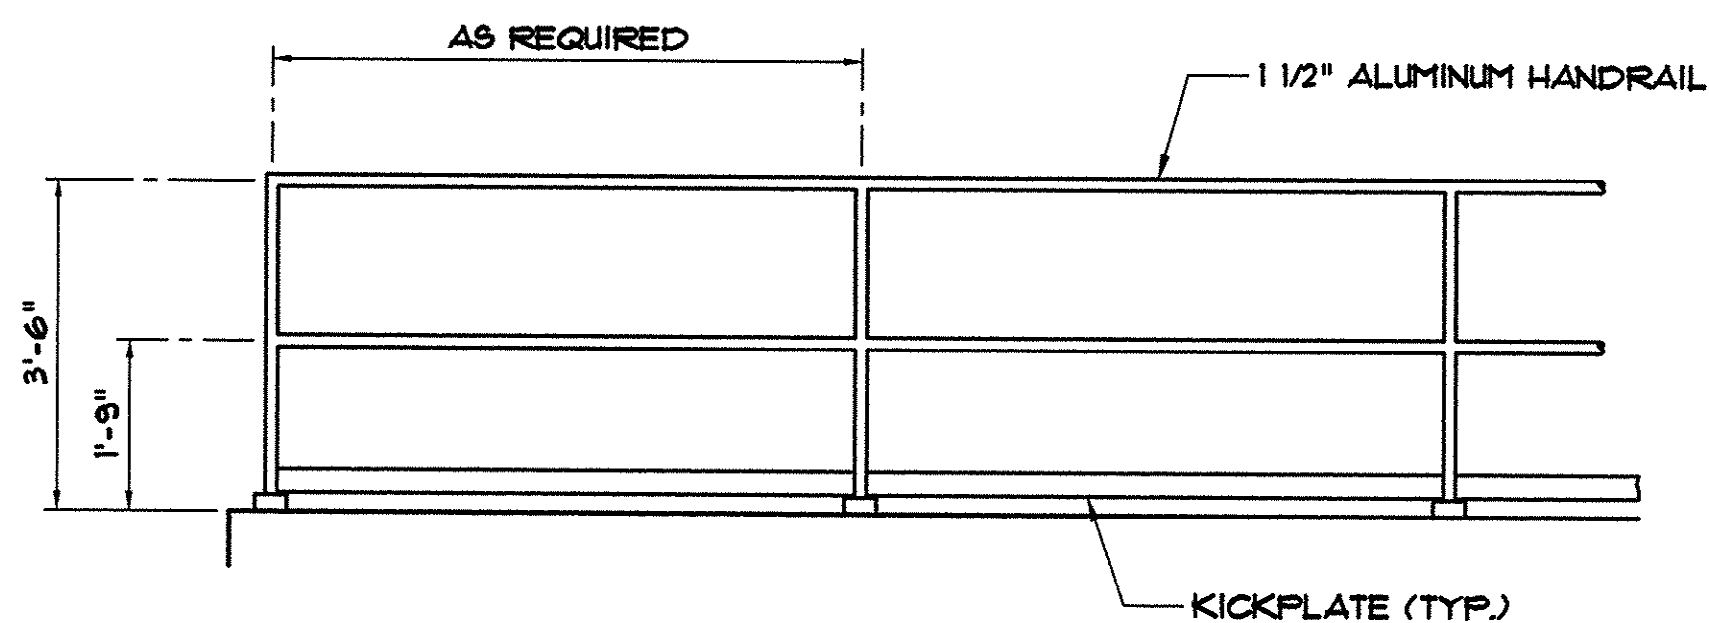

TYPICAL HANDRAIL DETAIL
N.T.S.

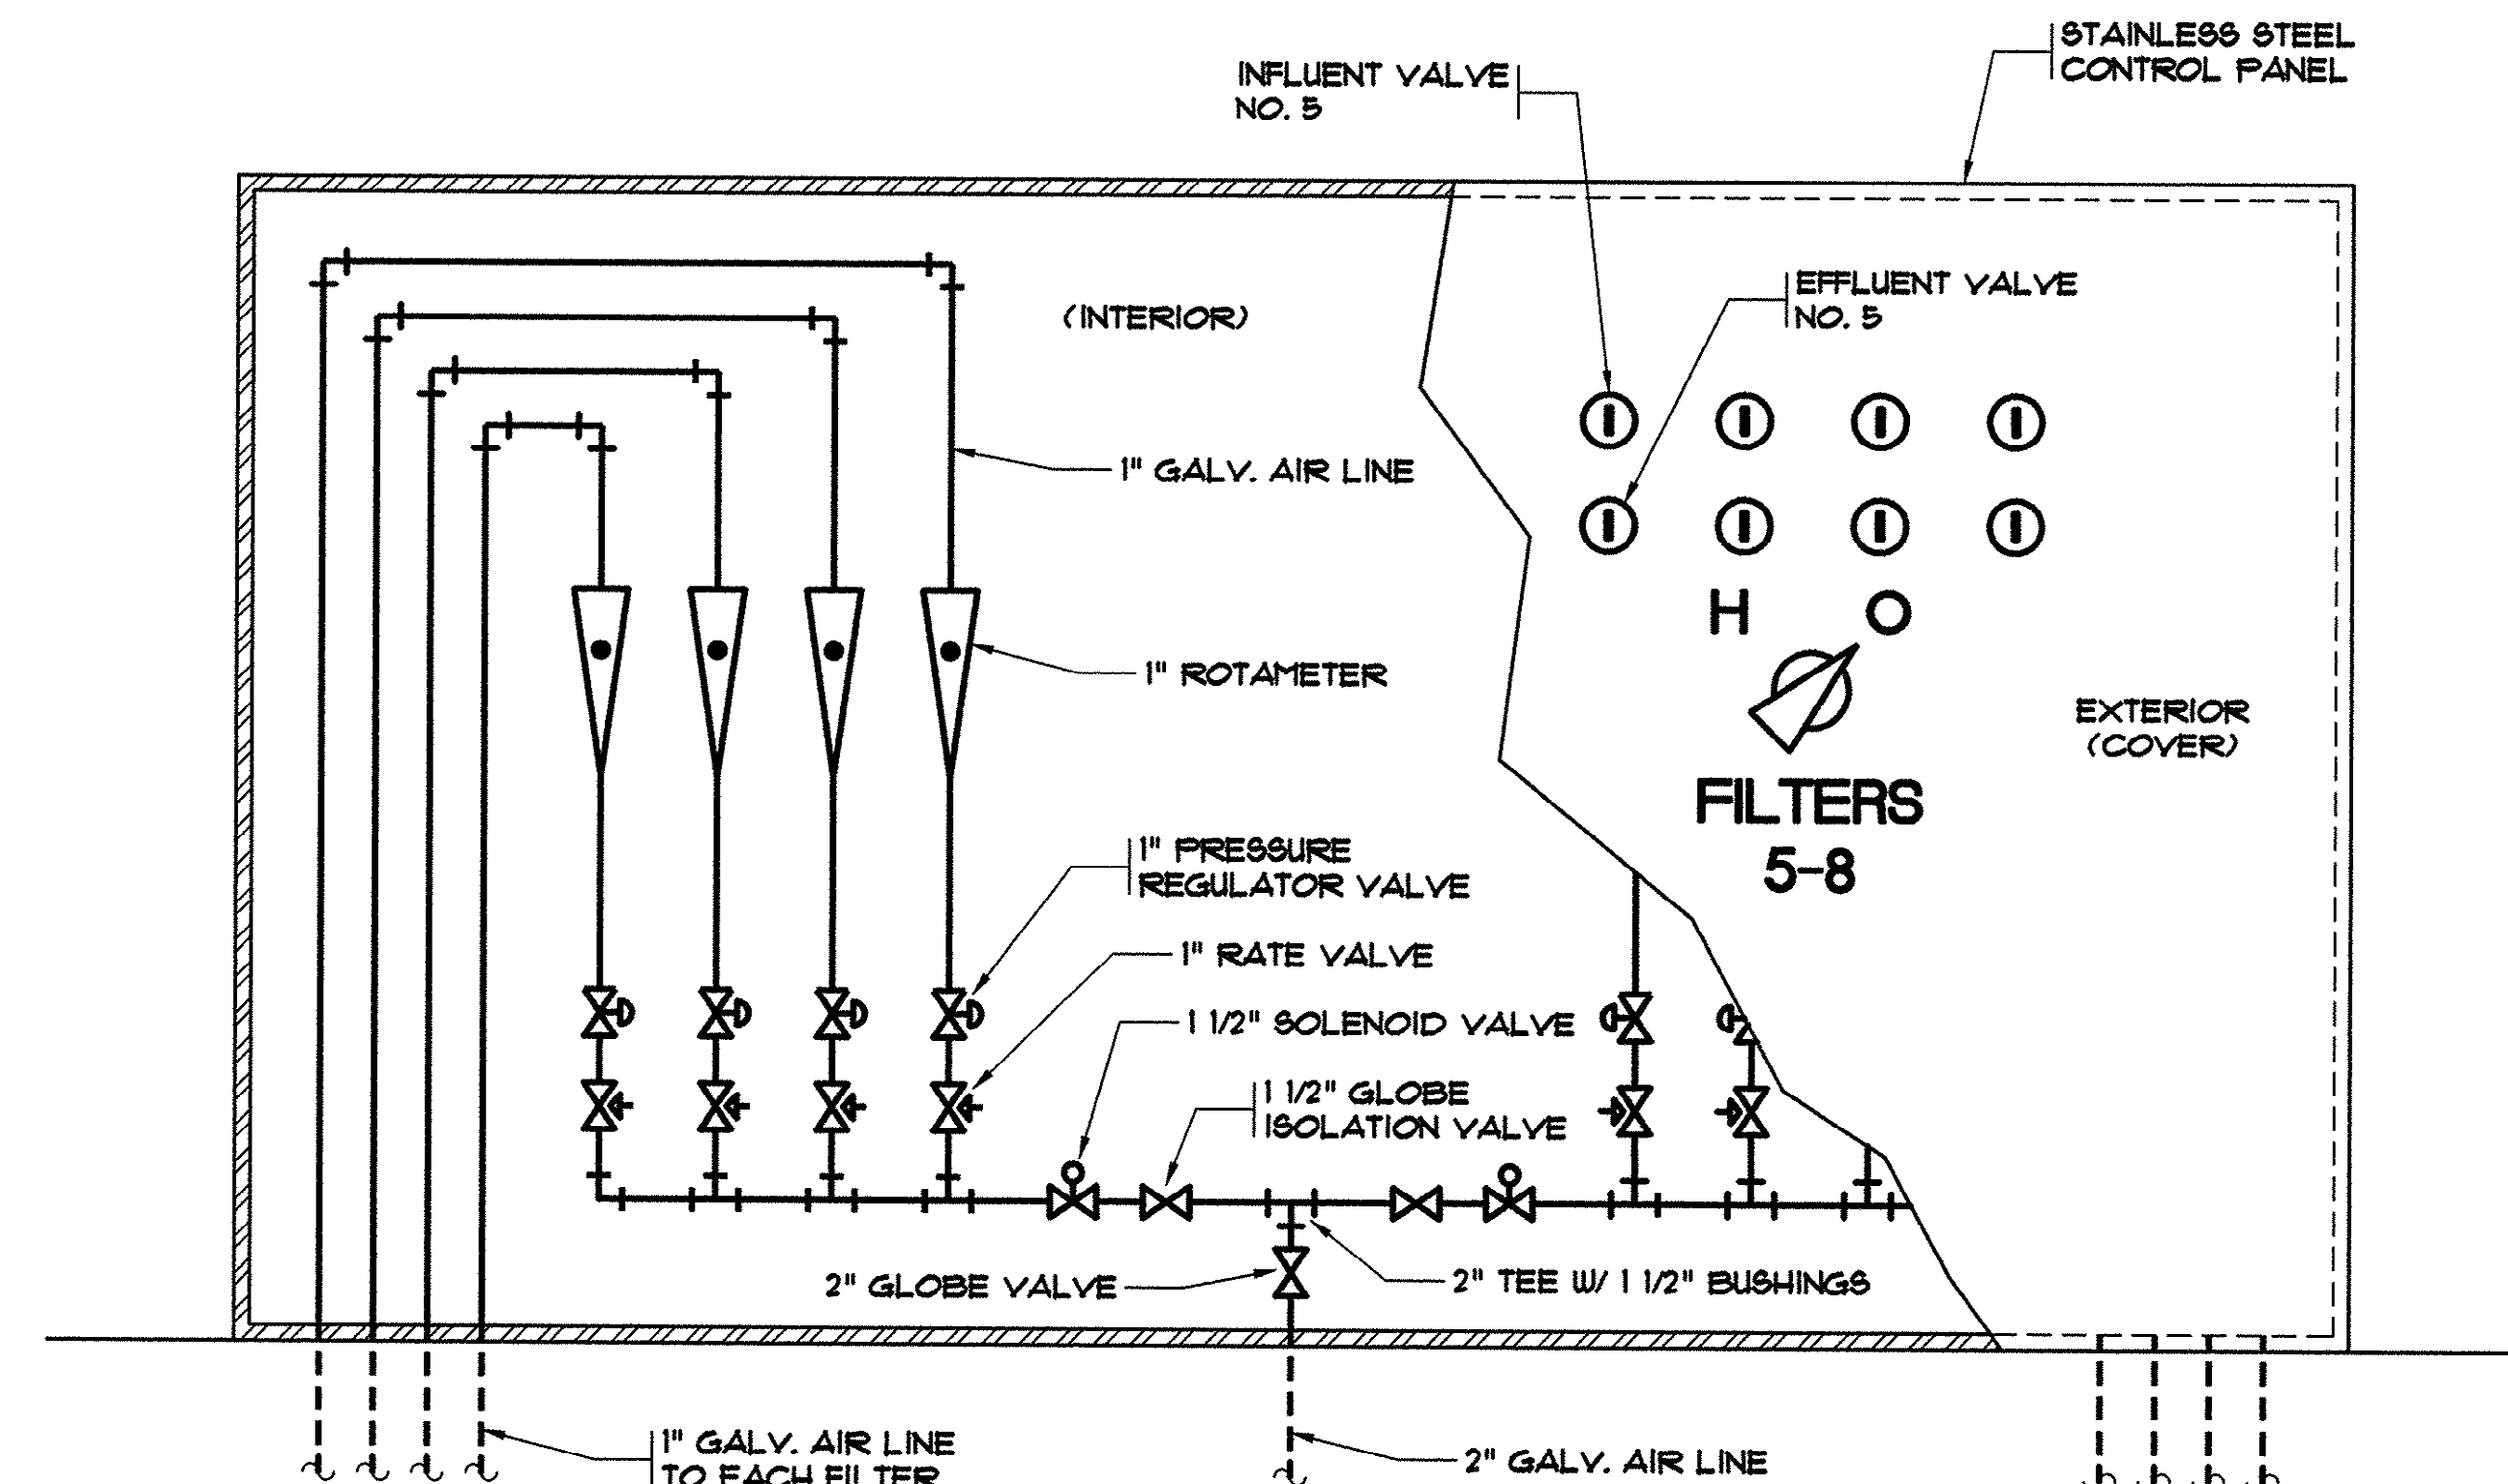

**CONTROL PANEL FOR FILTERS 1-8
(SIMILAR FOR FILTERS 9-16)**
N.T.S.

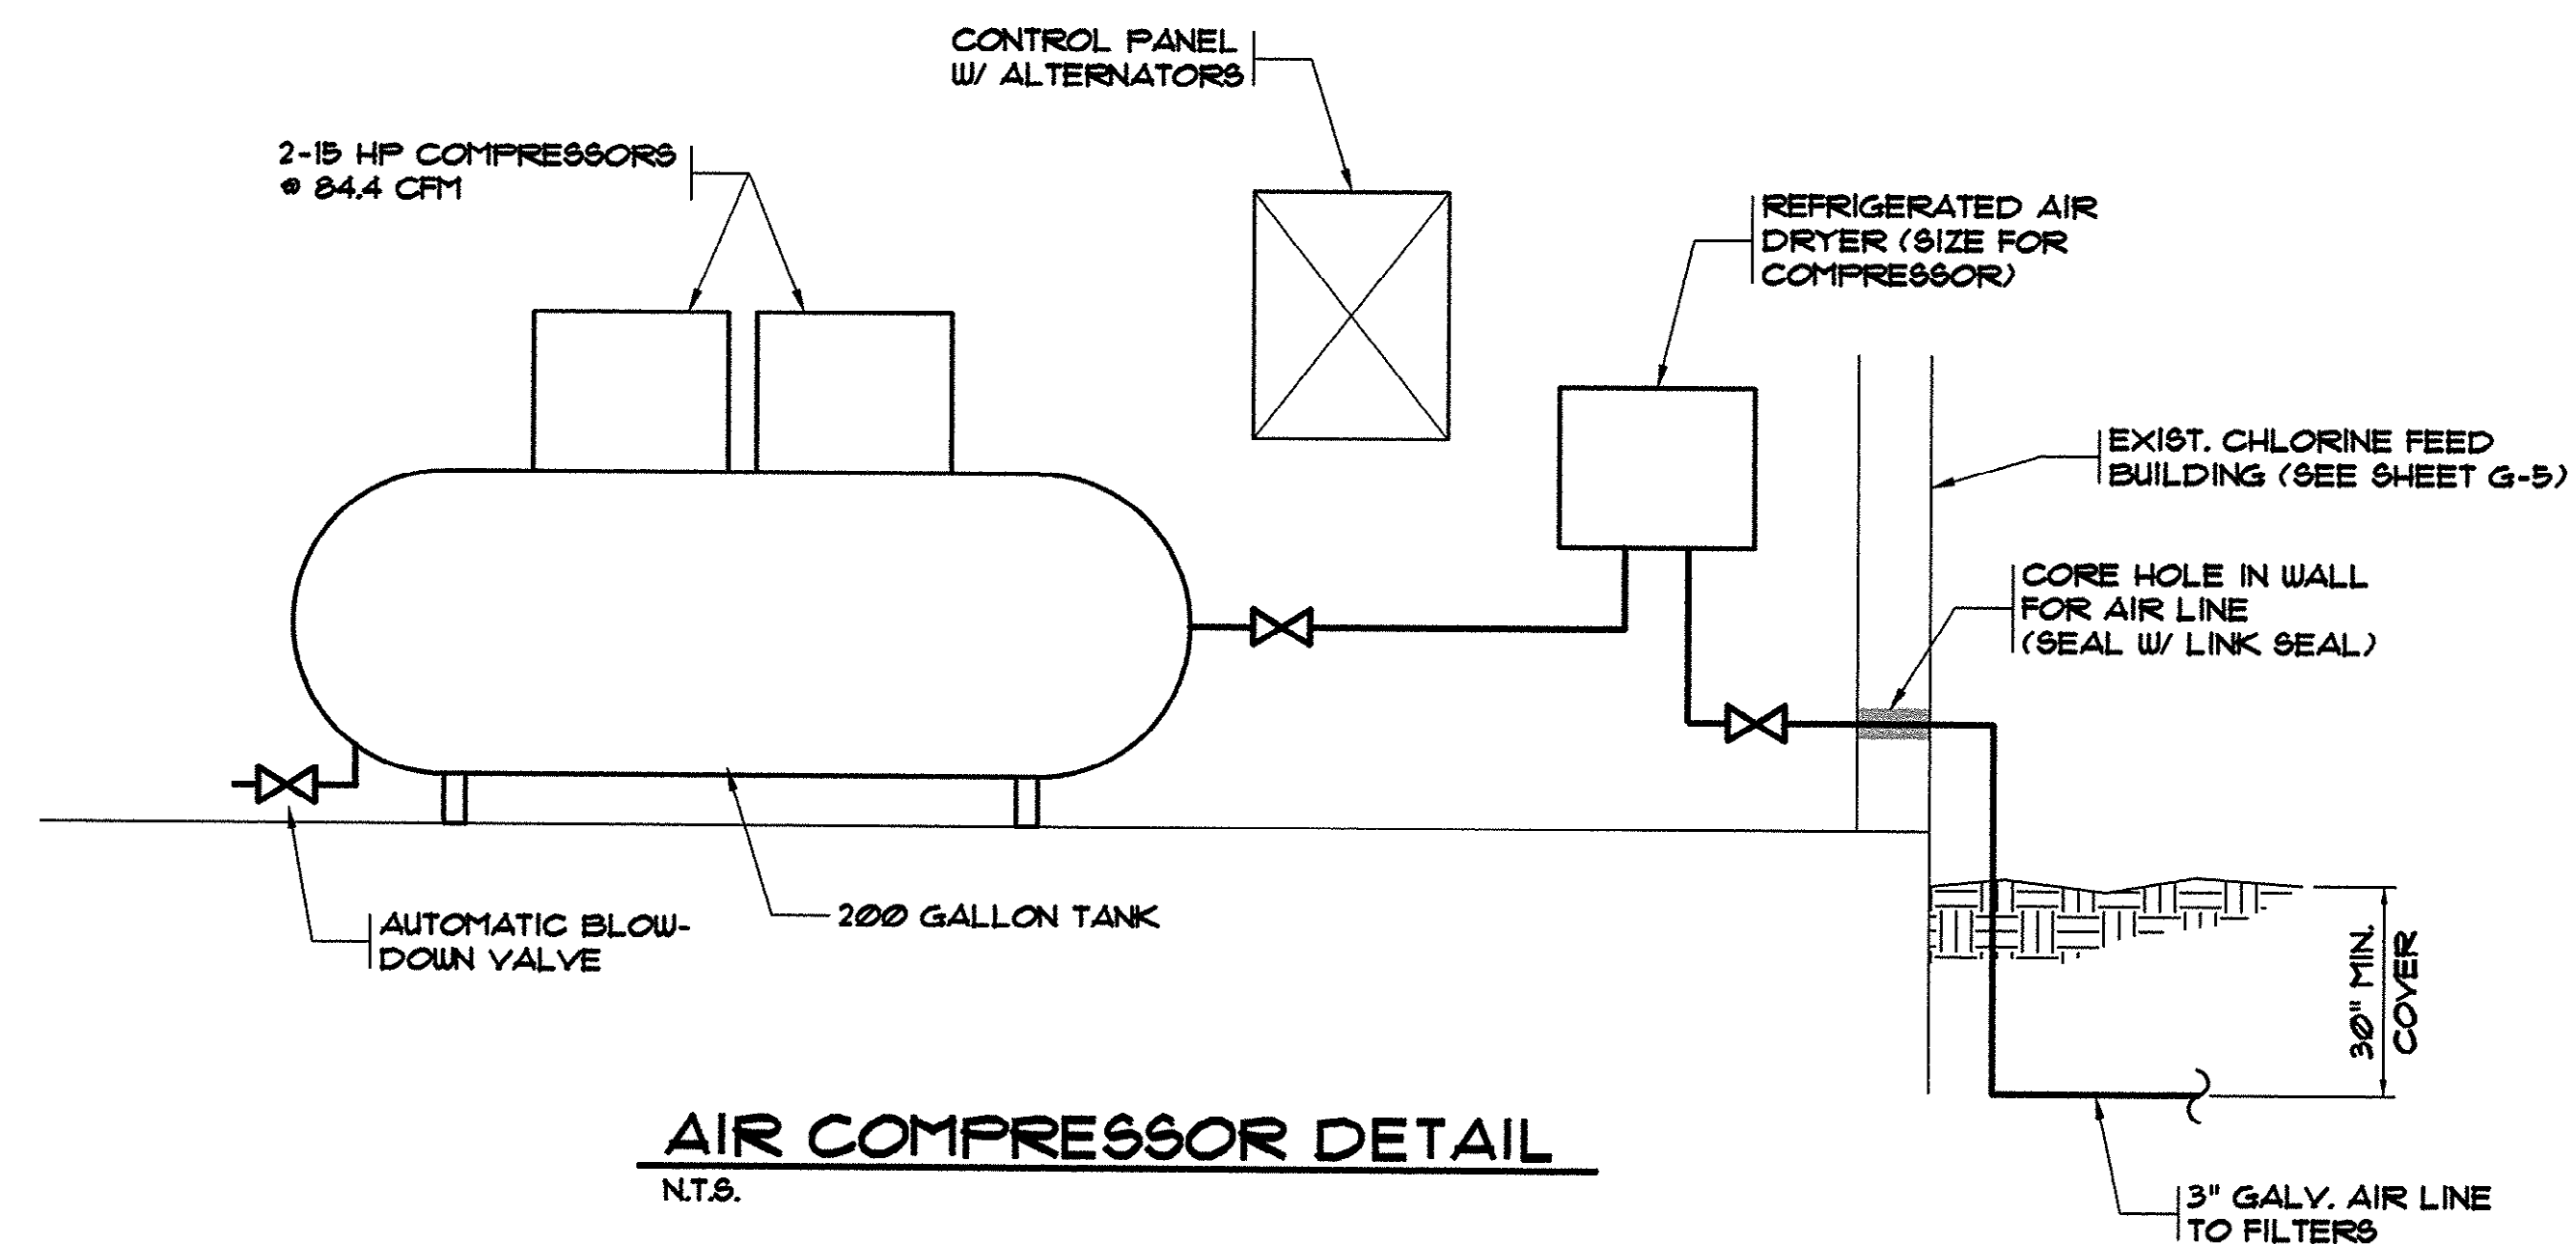

AIR COMPRESSOR DETAIL
N.T.S.

THESE DRAWINGS REFLECT
AS-BUILT
CONDITIONS

REVIEWED BY: INSPECTIONS DATE

REVIEWED BY: ENGINEERING DATE

GRAND STRAND WATER AND SEWER AUTHORITY


DEEP BED SAND FILTERS
AIR LINE SCHEMATIC
AND CONTROL PANEL
DETAILS

TIP-TOP TREE FARM
EFFLUENT LAND
APPLICATION PROJECT
GRAND STRAND WATER
AND SEWER AUTHORITY

DATE: MAR. 1999
DESIGNED: JWM
DRAWN: DC
CHECKED: JWM
SCALE: AS SHOWN


SHEET NO.
G-8
16

REVISIONS	DATE	BY
DESCRIPTION	8/02/01	CAR
AS-BUILT		
STYL.		

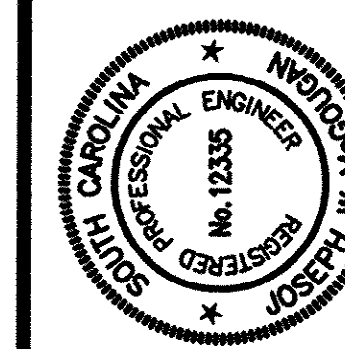

HOBBS, UPCHURCH & ASSOCIATES, P.A.
CONSULTING ENGINEERS
MYRTLE BEACH, SOUTH CAROLINA 29577


45-003-008/53

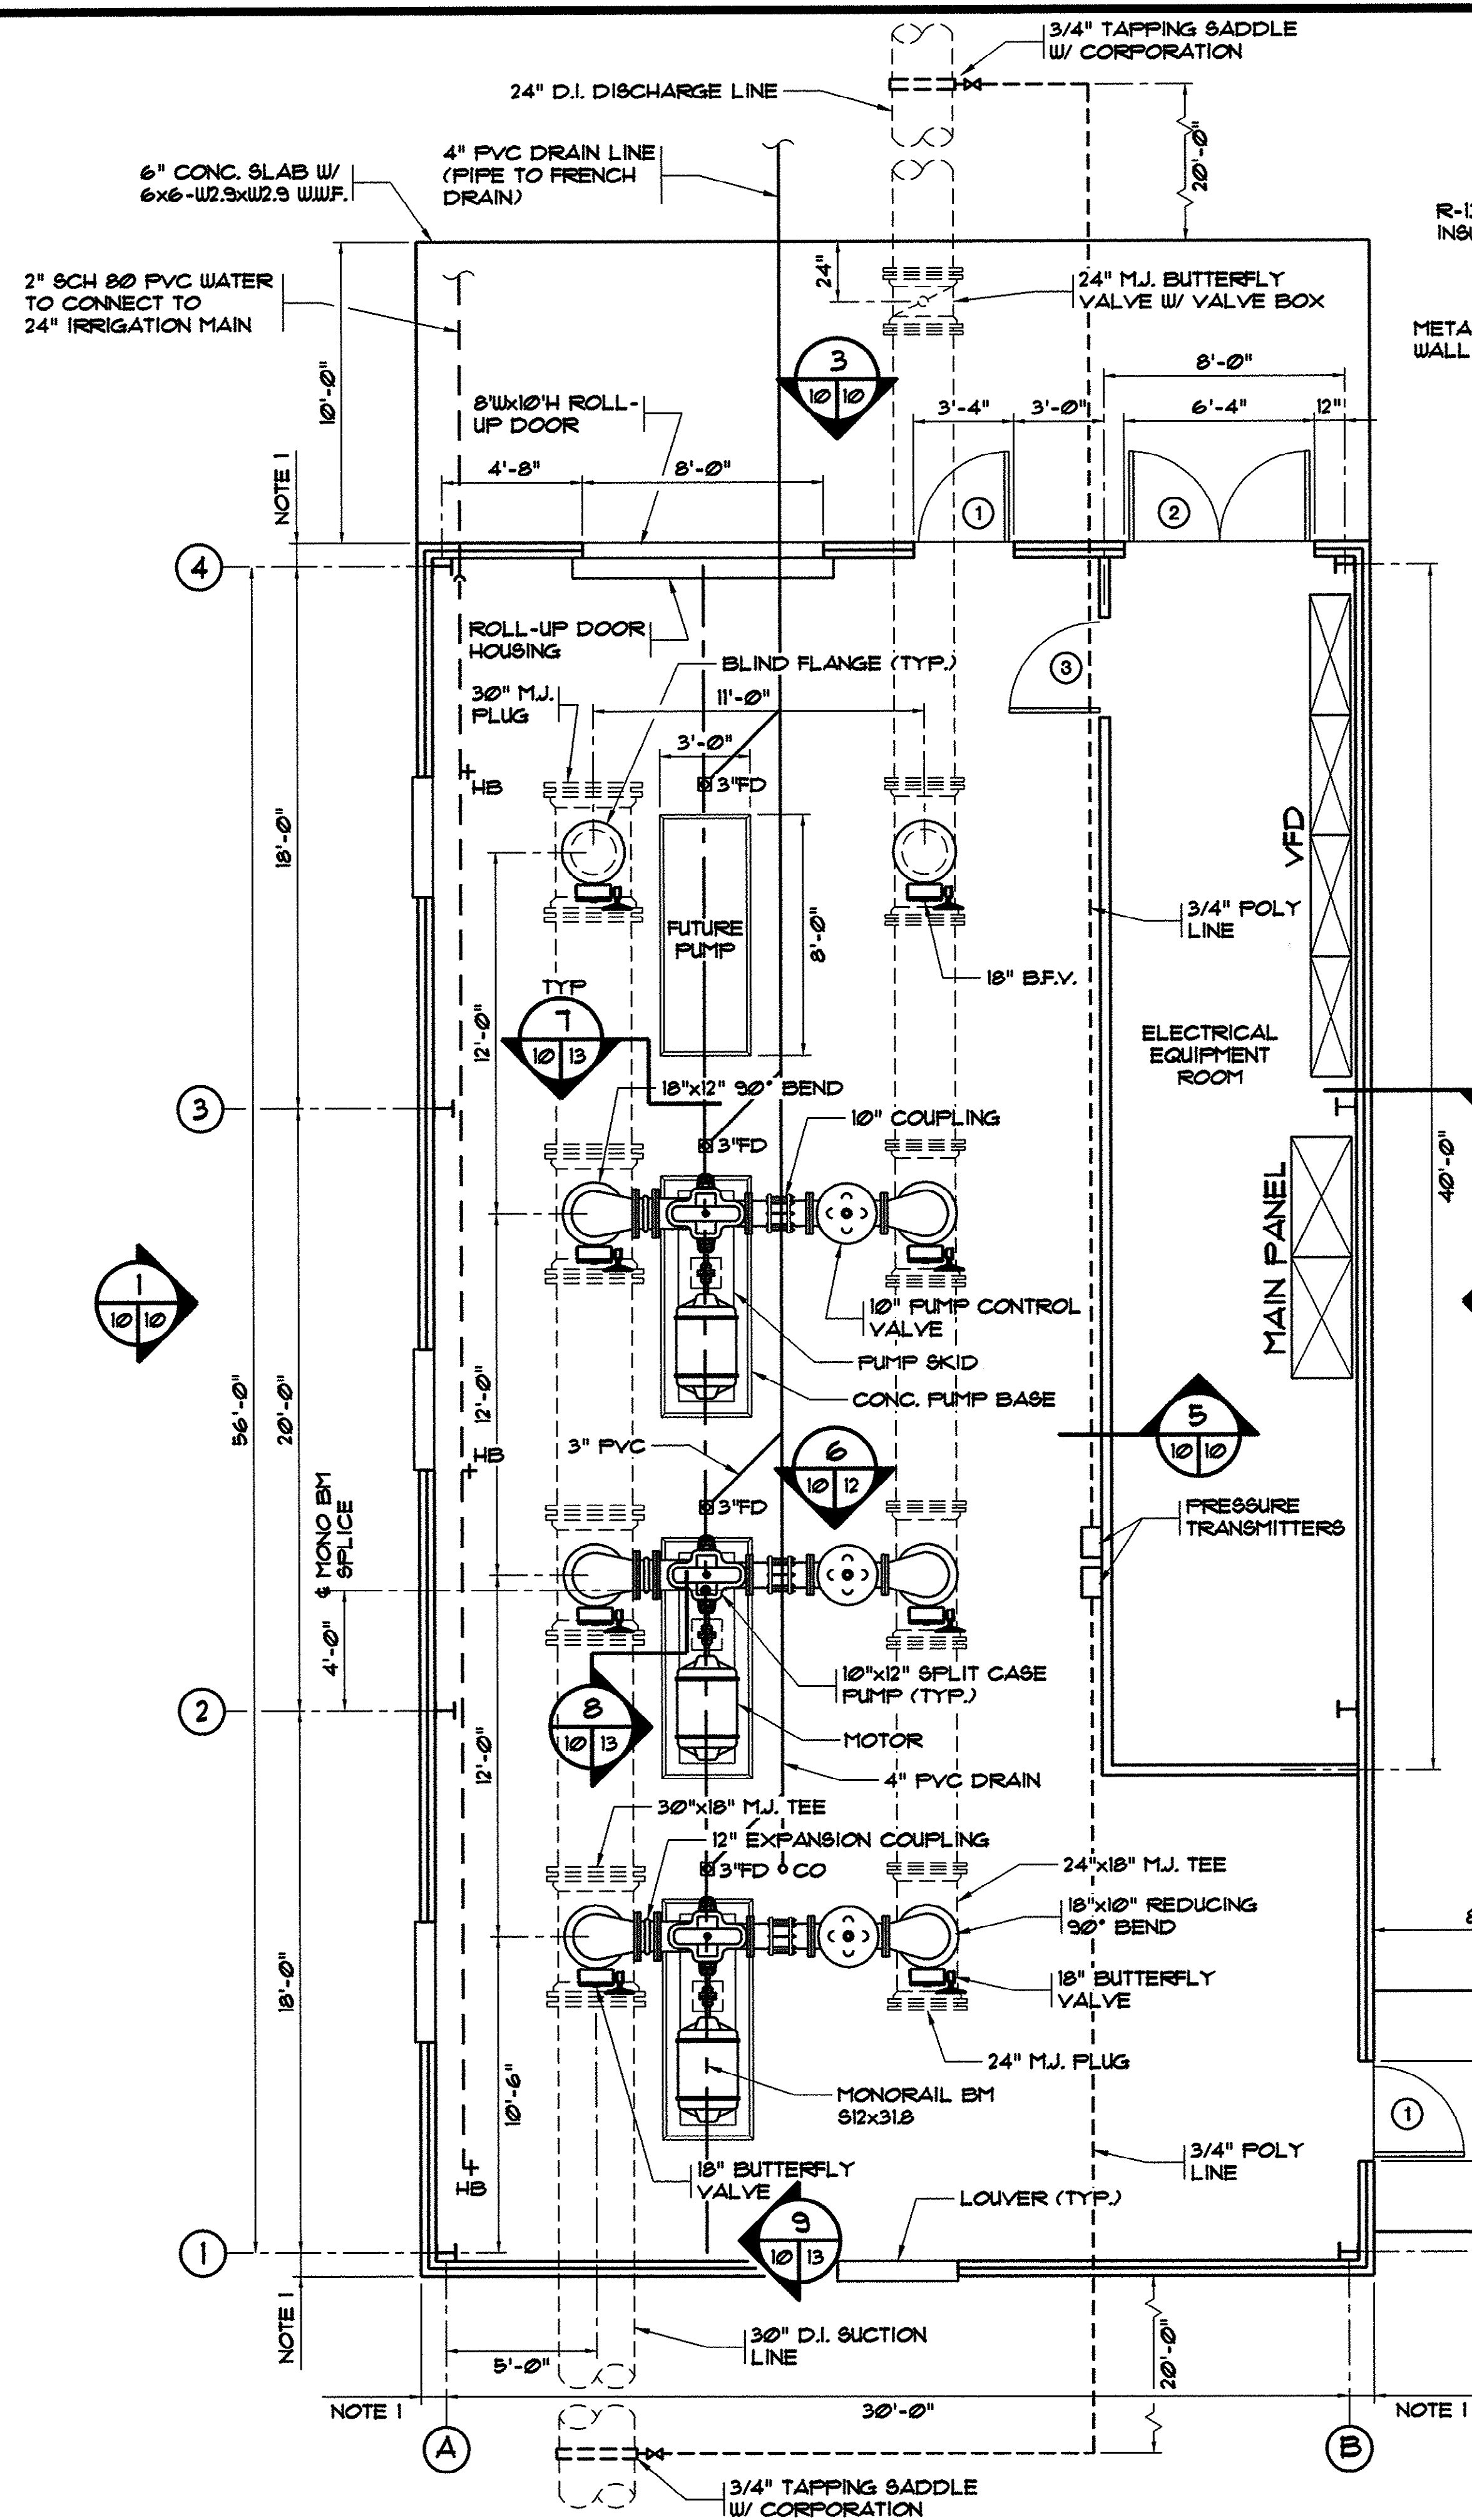

IRRIGATION BOOSTER PUMP STATION PLAN 1/4" = 1'-0"
NOTE:
1. OUTSIDE EDGE OF CONCRETE BUILDING SLAB SHALL CORRESPOND WITH BUILDING STRUCTURE LINE.
2. MONORAIL HOIST CAPACITY = 2 TONS.

5 WALL SECTION
N.T.S.

- NOTES:
- BUILDING TO BE BUTLER PANEL-LINE OR SIMILAR.
 - INSTALL BUILDING AS PER MANUFACTURER'S SPECIFICATIONS.
 - BUILDING MANUFACTURER SHALL COORDINATE BUILDING HEIGHT TO MAINTAIN MINIMUM 12'-0" CLEARANCE FROM FINISHED FLOOR TO BOTTOM OF MONORAIL BEAM.
 - BUILDING MANUFACTURER SHALL PROVIDE HORIZONTAL BRACING AS REQUIRED TO RESIST MONORAIL FORCES.

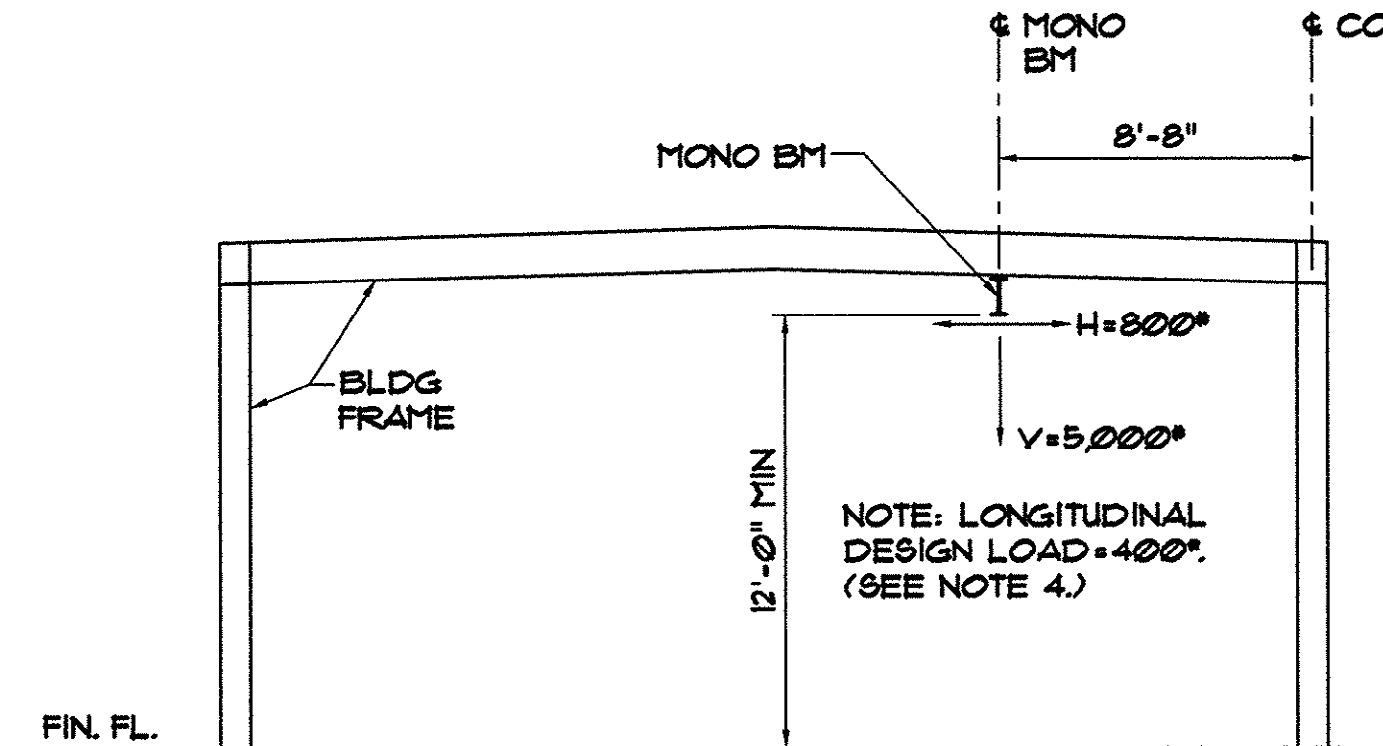

4 MONORAIL BM DESIGN LOADS
NO SCALE

THESE DRAWINGS REFLECT
AS-BUILT
CONDITIONS

REVIEWED BY: _____ DATE _____
INSPECTIONS


REVIEWED BY: _____ DATE _____
ENGINEERING

GRAND STRAND WATER AND SEWER AUTHORITY

WALL LEGEND


- 5 1/8" TYPICAL EXTERIOR WALL
EXTERIOR METAL WALL PANEL,
3" UNFACED INSULATION, 1 1/2" THICK
FOAM BOARD, INSULATED LINER PANEL
- 4 1/8" TYPICAL UNRATED WALL
1 LAYER 5/8" GYP. BOARD EACH SIDE
3 5/8" 20 GA. STEEL STUDS @ 16" O.C.
VERTICAL FIBERGLASS BATT
INSULATION. (EXTEND WALL UP TO
BOTTOM OF METAL ROOF DECK)

DOOR SCHEDULE									
NO.	DOOR						FRAME		REMARKS
	SIZE	TYPE	MTL.	GLASS	LOUVER	LABEL	TYPE	MTL.	
1	3'x7'x1.75"	A	INSUL. HM.	1/4" TEMP.	NONE	NONE	1	METAL	NONE
2	PR3'x7'x1.75"	A	INSUL. HM.	1/4" TEMP.	NONE	NONE	1	METAL	NONE
3	3'x7'x1.75"	B	INSUL. HM.	NONE	NONE	NONE	1	METAL	NONE

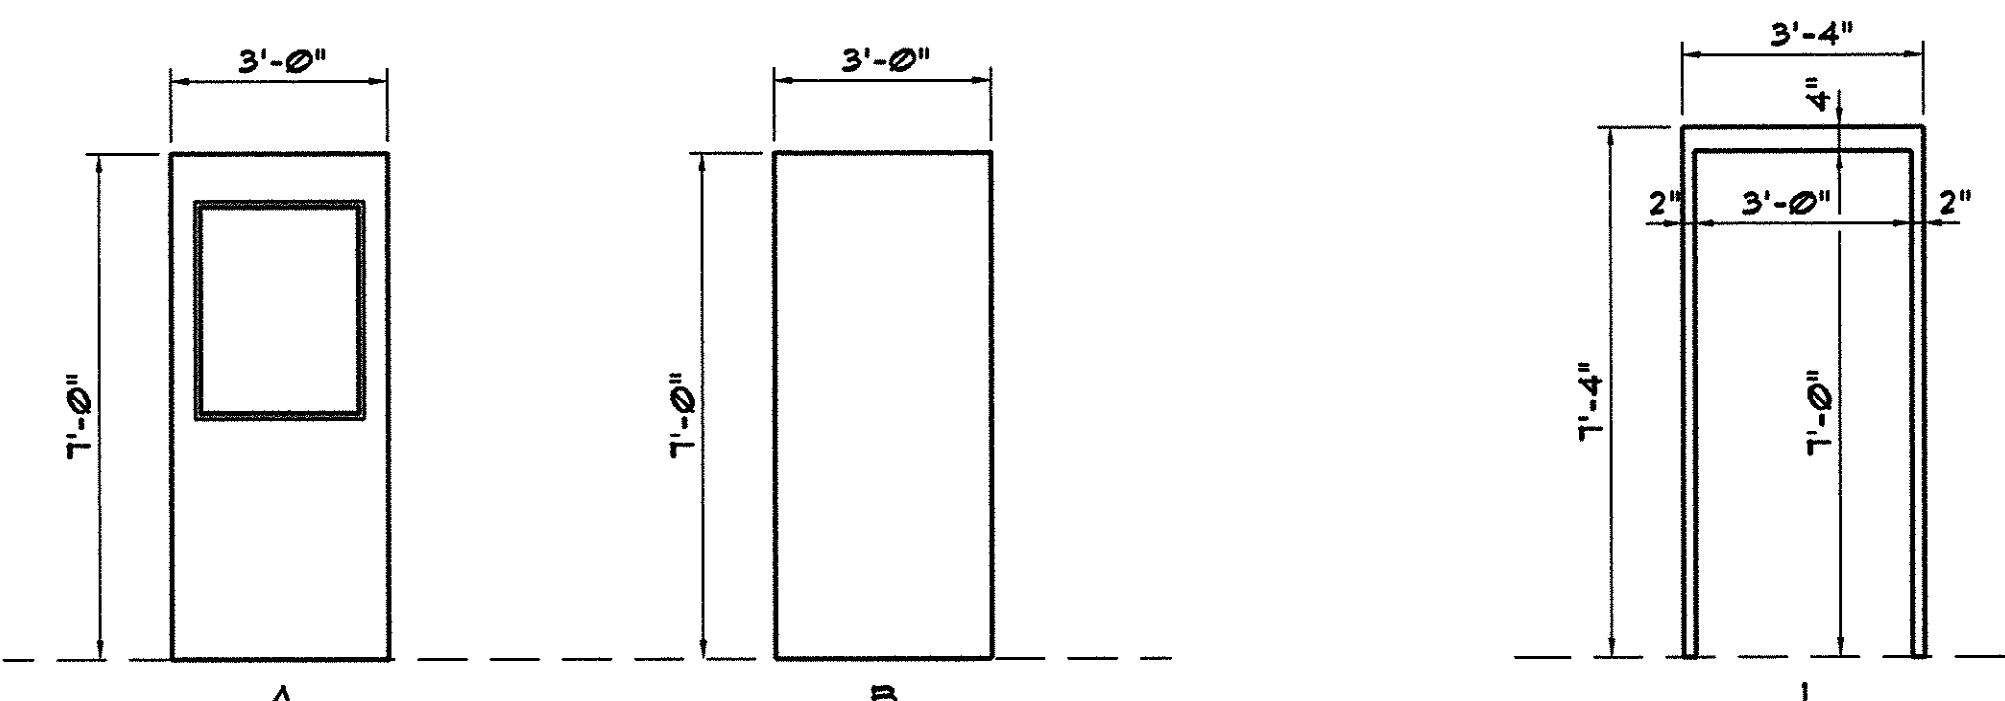


DOOR ELEVATIONS


FRAME ELEVATIONS

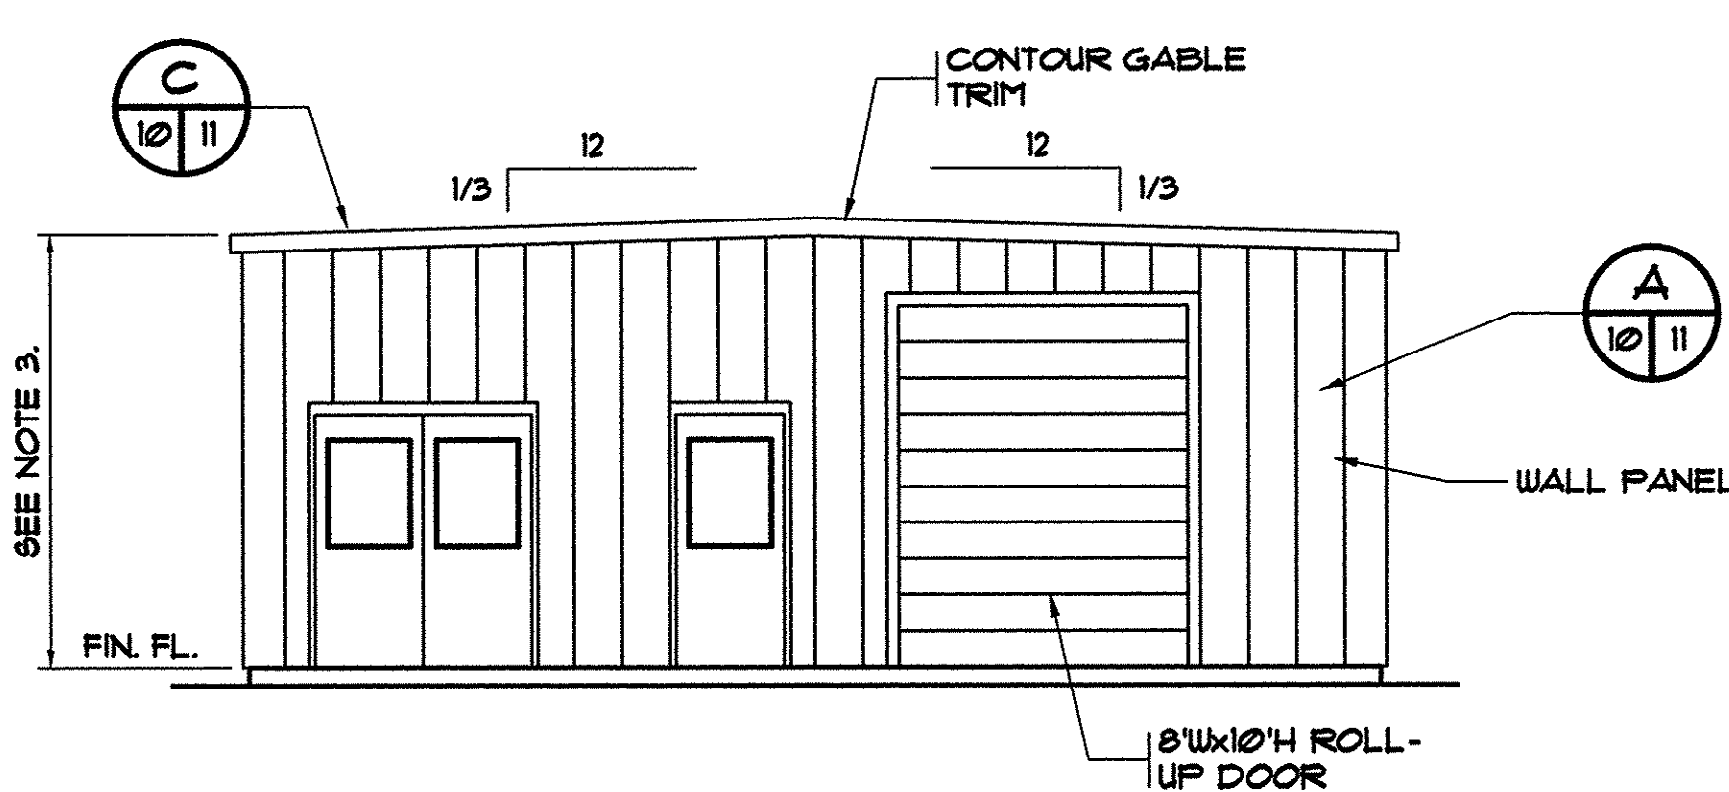

3 EXTERIOR ELEVATION
SCALE: 3/16" = 1'-0"

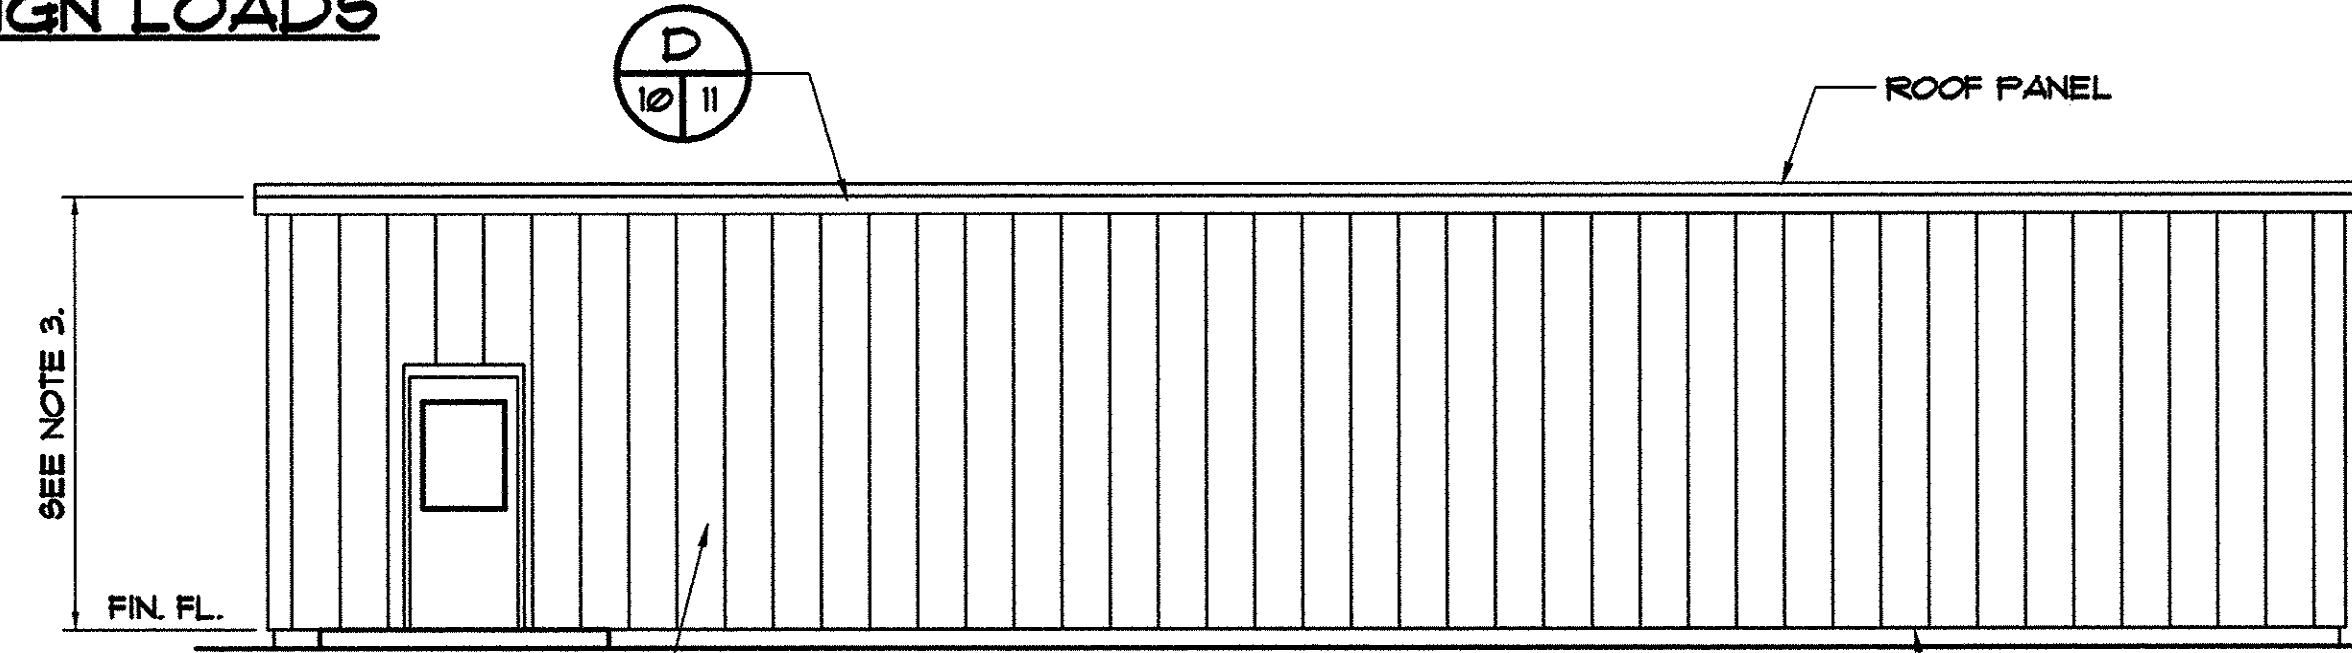


2 EXTERIOR ELEVATION
SCALE: 3/16" = 1'-0"

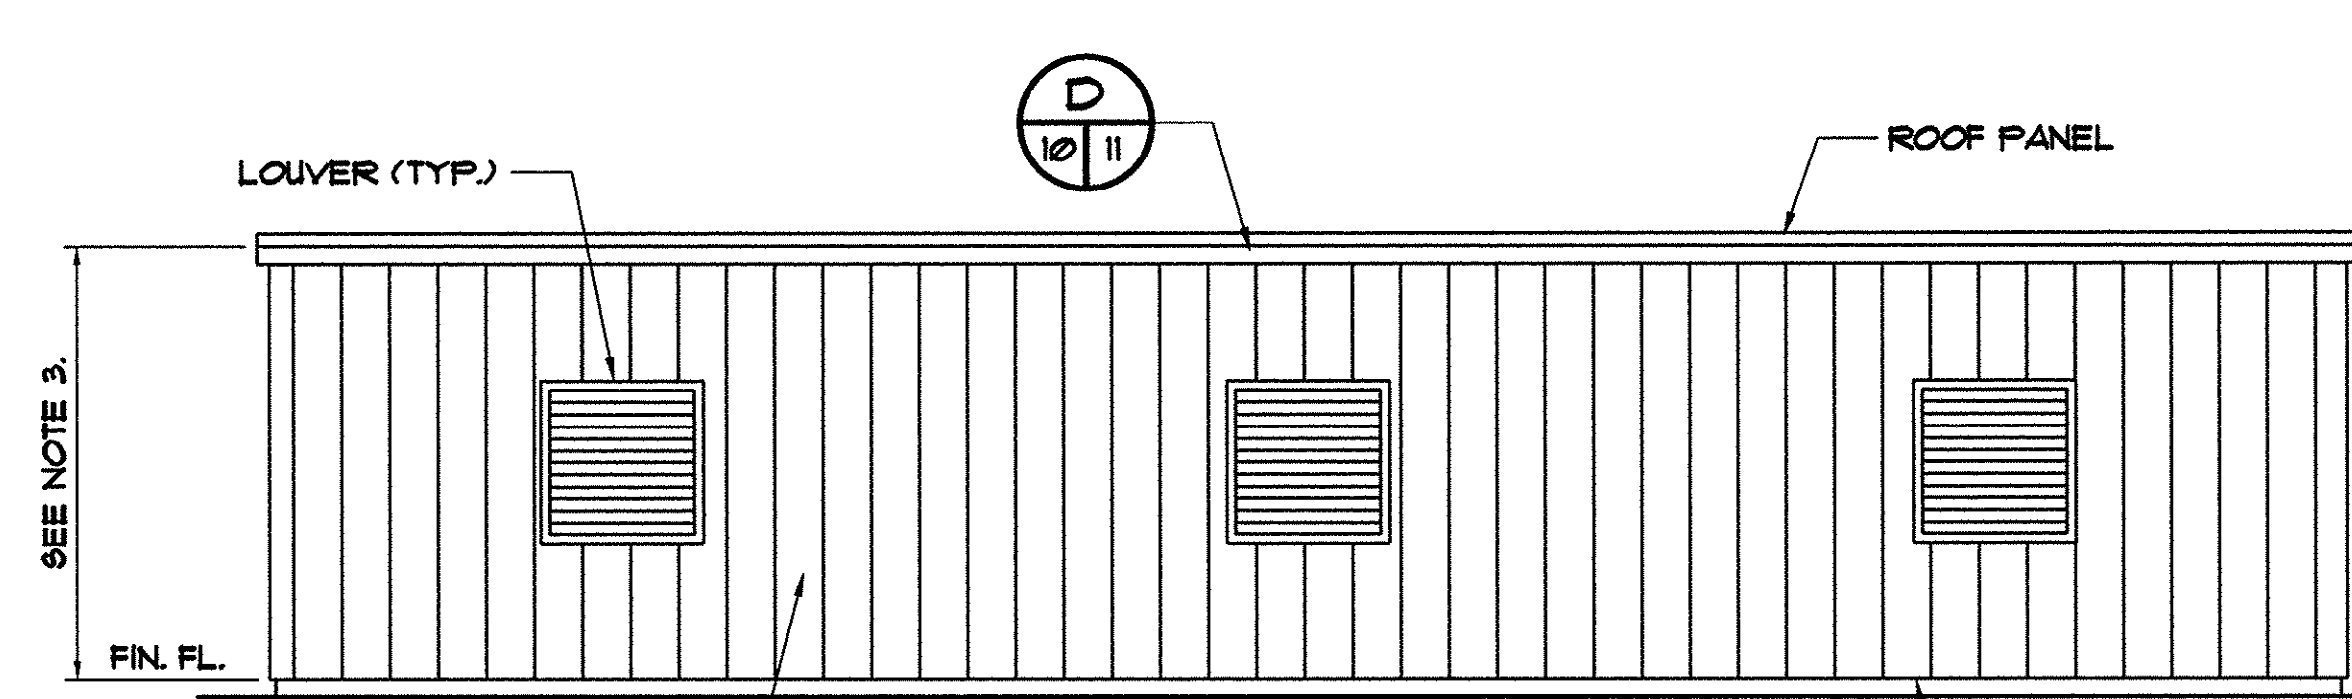

1 EXTERIOR ELEVATION
SCALE: 3/16" = 1'-0"

REVISIONS	DATE	BY
DESCRIPTION	8/22/01	CAR
AS-BUILT		

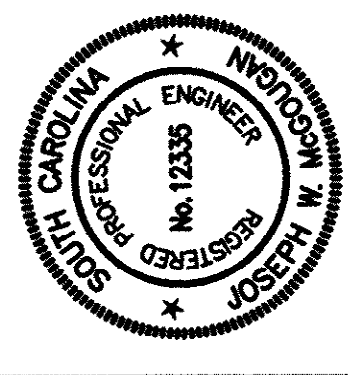


HOBBS, UPCHURCH & ASSOCIATES, P.A.
CONSULTING ENGINEERS
MYRTLE BEACH, SOUTH CAROLINA 29577

**IRRIGATION BOOSTER
PUMP STATION PLAN/
EXTERIOR ELEVATIONS
AND DETAILS**

**TIP-TOP TREE FARM
EFFLUENT LAND
APPLICATION PROJECT
GRAND STRAND WATER
AND SEWER AUTHORITY**

DATE:	MAR. 1999
DESIGNED:	JWM
DRAWN:	DC
CHECKED:	JWM
SCALE:	AS SHOWN

45-003-010/53

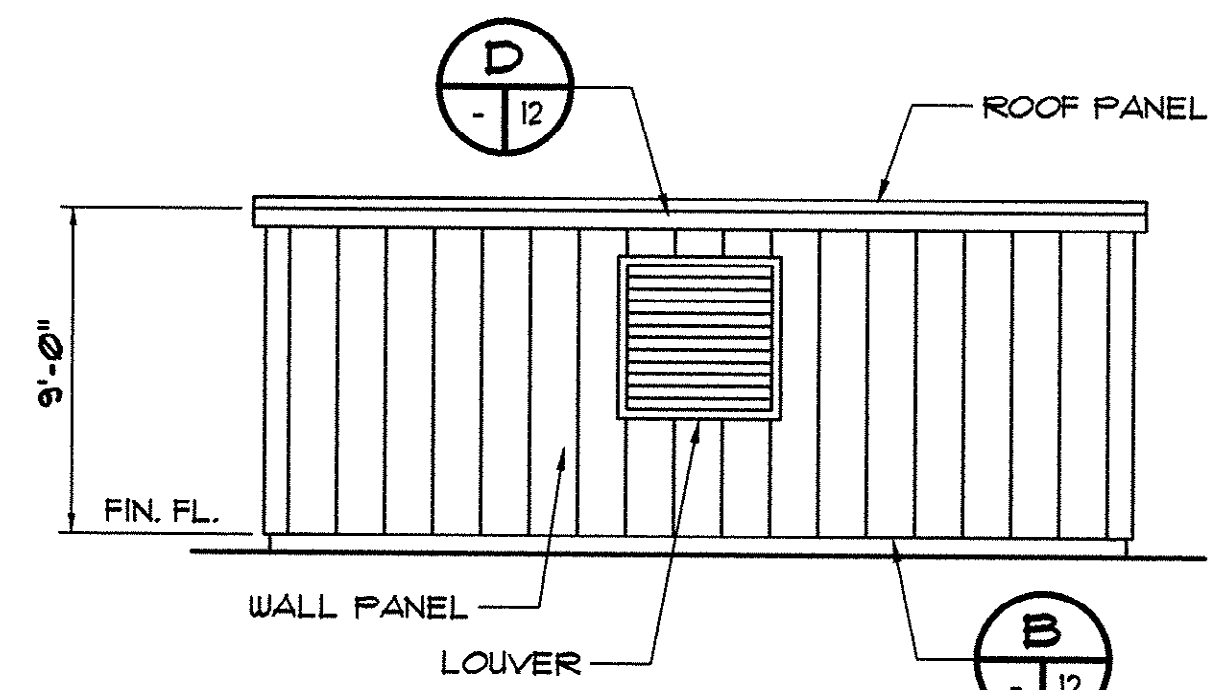

2 EXTERIOR ELEVATION
SCALE: 3/16" = 1'-0"

THESE DRAWINGS REFLECT
AS-BUILT
CONDITIONS

REVIEWED BY: _____ DATE _____
INSPECTIONS


REVIEWED BY: _____ DATE _____
ENGINEERING

GRAND STRAND WATER AND SEWER AUTHORITY

NOTE:
SEE G-13 FOR FOUNDATION
DETAILS. (SIMILAR)

Diagram of a rectangular frame with dimensions: 3'-4" (width), 1'-0" (height), 4" (inner width), 2" (inner height), 3'-0" (outer width), and 2" (outer height).

FRAME ELEVATIONS

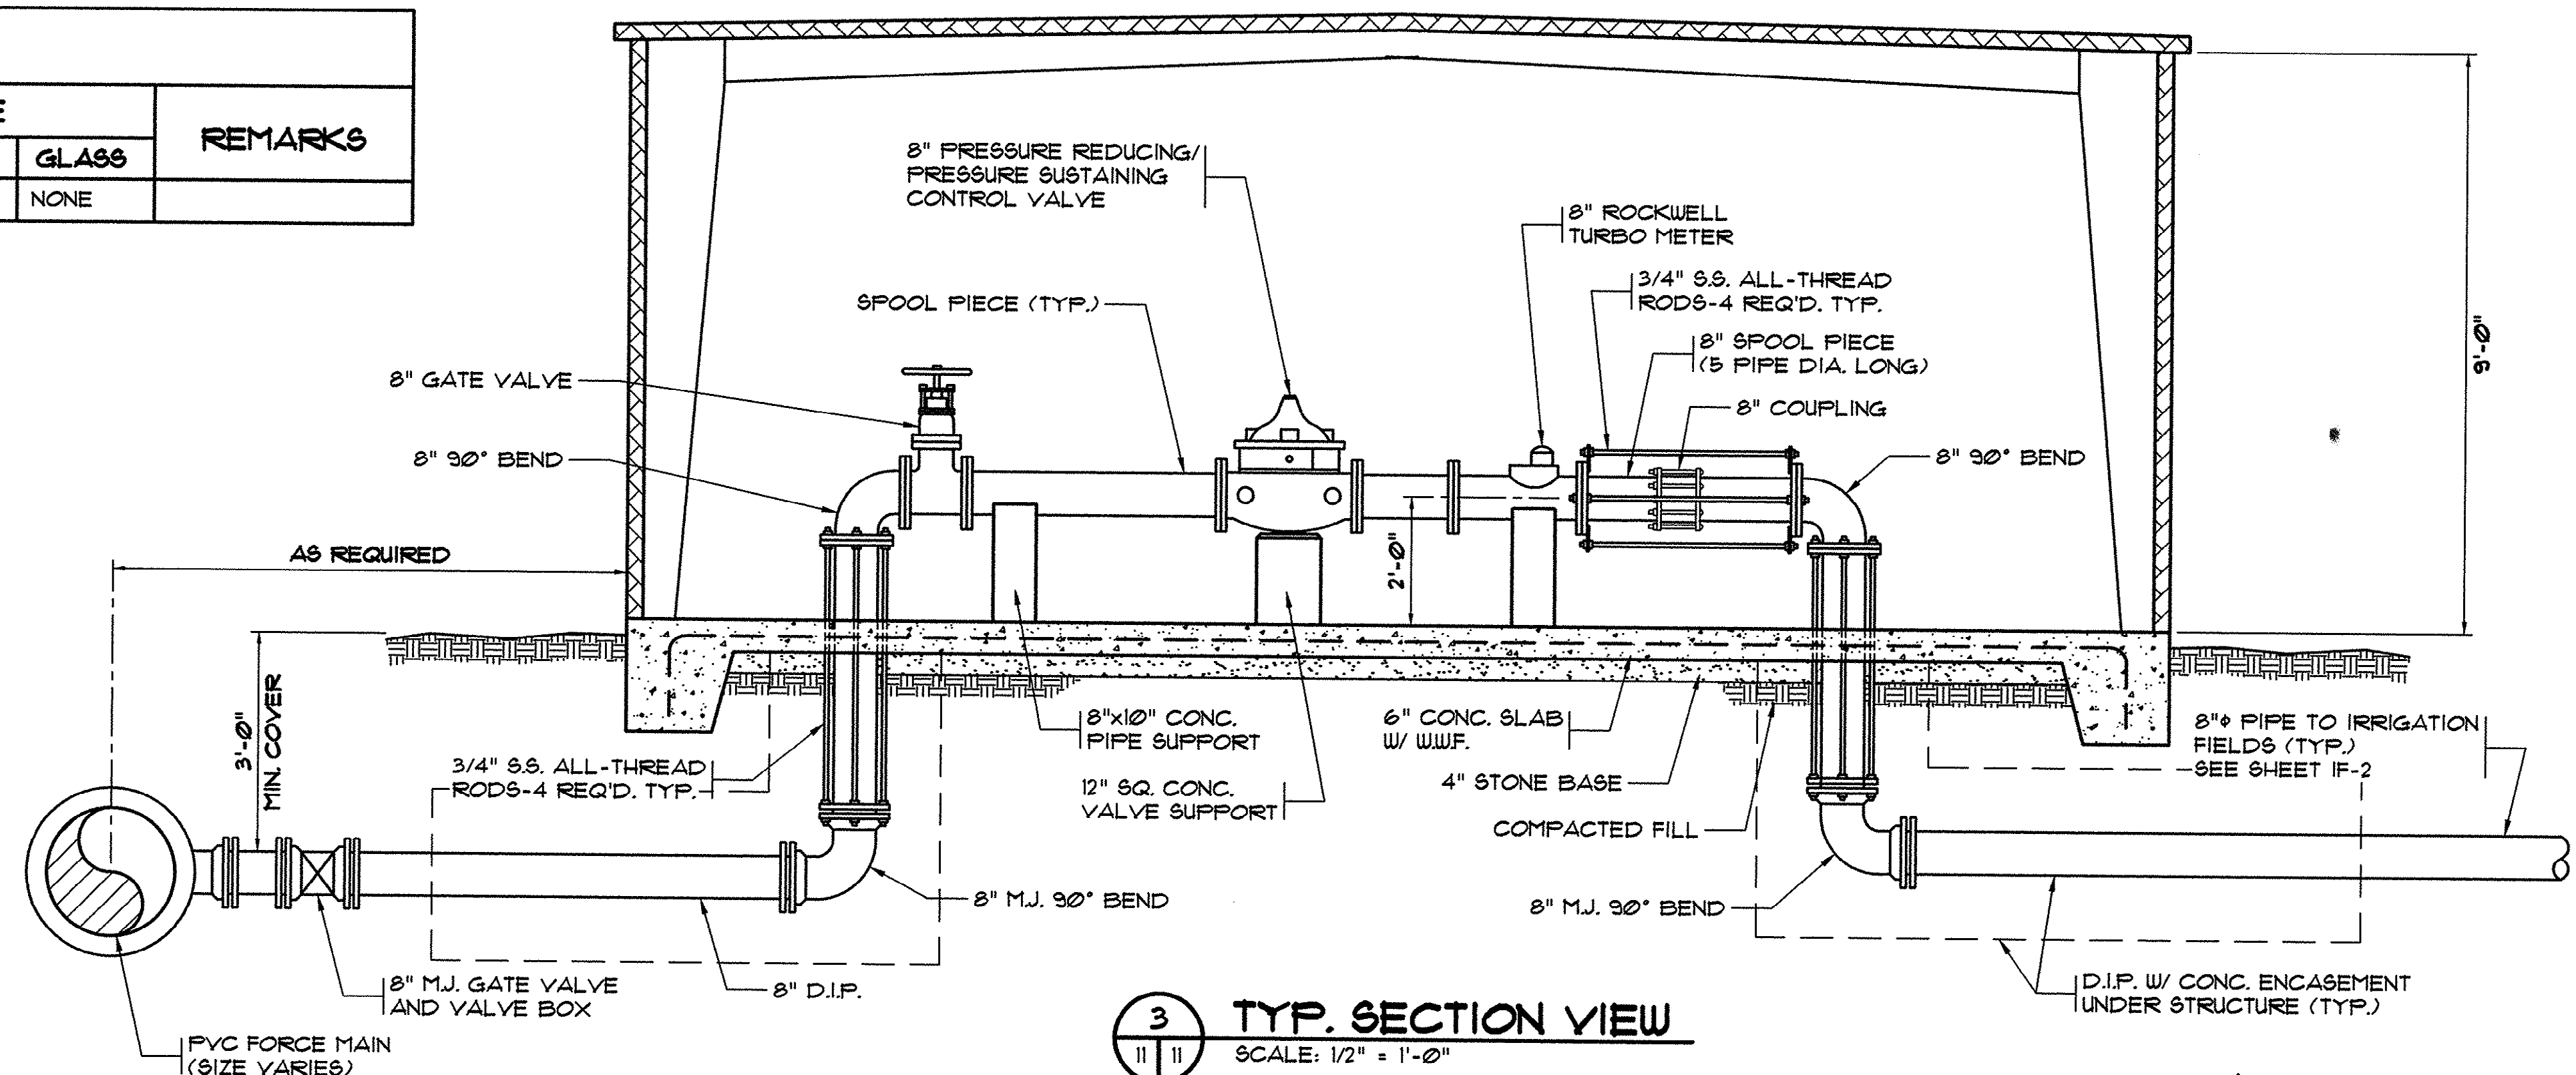

3 TYP. SECTION VIEW
SCALE: 1/2" = 1'-0"

45-003-011/53


IRRIGATION FIELDS DISTRIBUTION HEADER DETAILS AND BUILDING LAYOUT

THE 101 TREE FARM EFFLUENT LAND APPLICATION PROJECT GRAND STRAND WATER AND SEWER AUTHORITY

DATE:	MAR. 1999
DESIGNED BY:	JWM
BY:	DC
CHECKED BY:	JWM
NOTED BY:	AS SHOWN

G-11


16

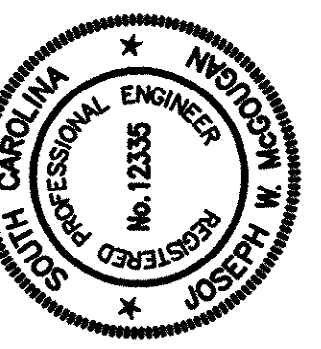[illegible]


HOBBS, OF CHURCH & ASSOCIATES, P.A.
CONSULTING ENGINEERS
MYRTLE BEACH, SOUTH CAROLINA 29577




HOBBES, UPCHURCH & ASSOC. MB J:\G59901\800\820\G-DWG\AB-G-12.dwg EDITED BY: ARAGON DATE: 08/29/01 TIME: 11:15 Layout: Model

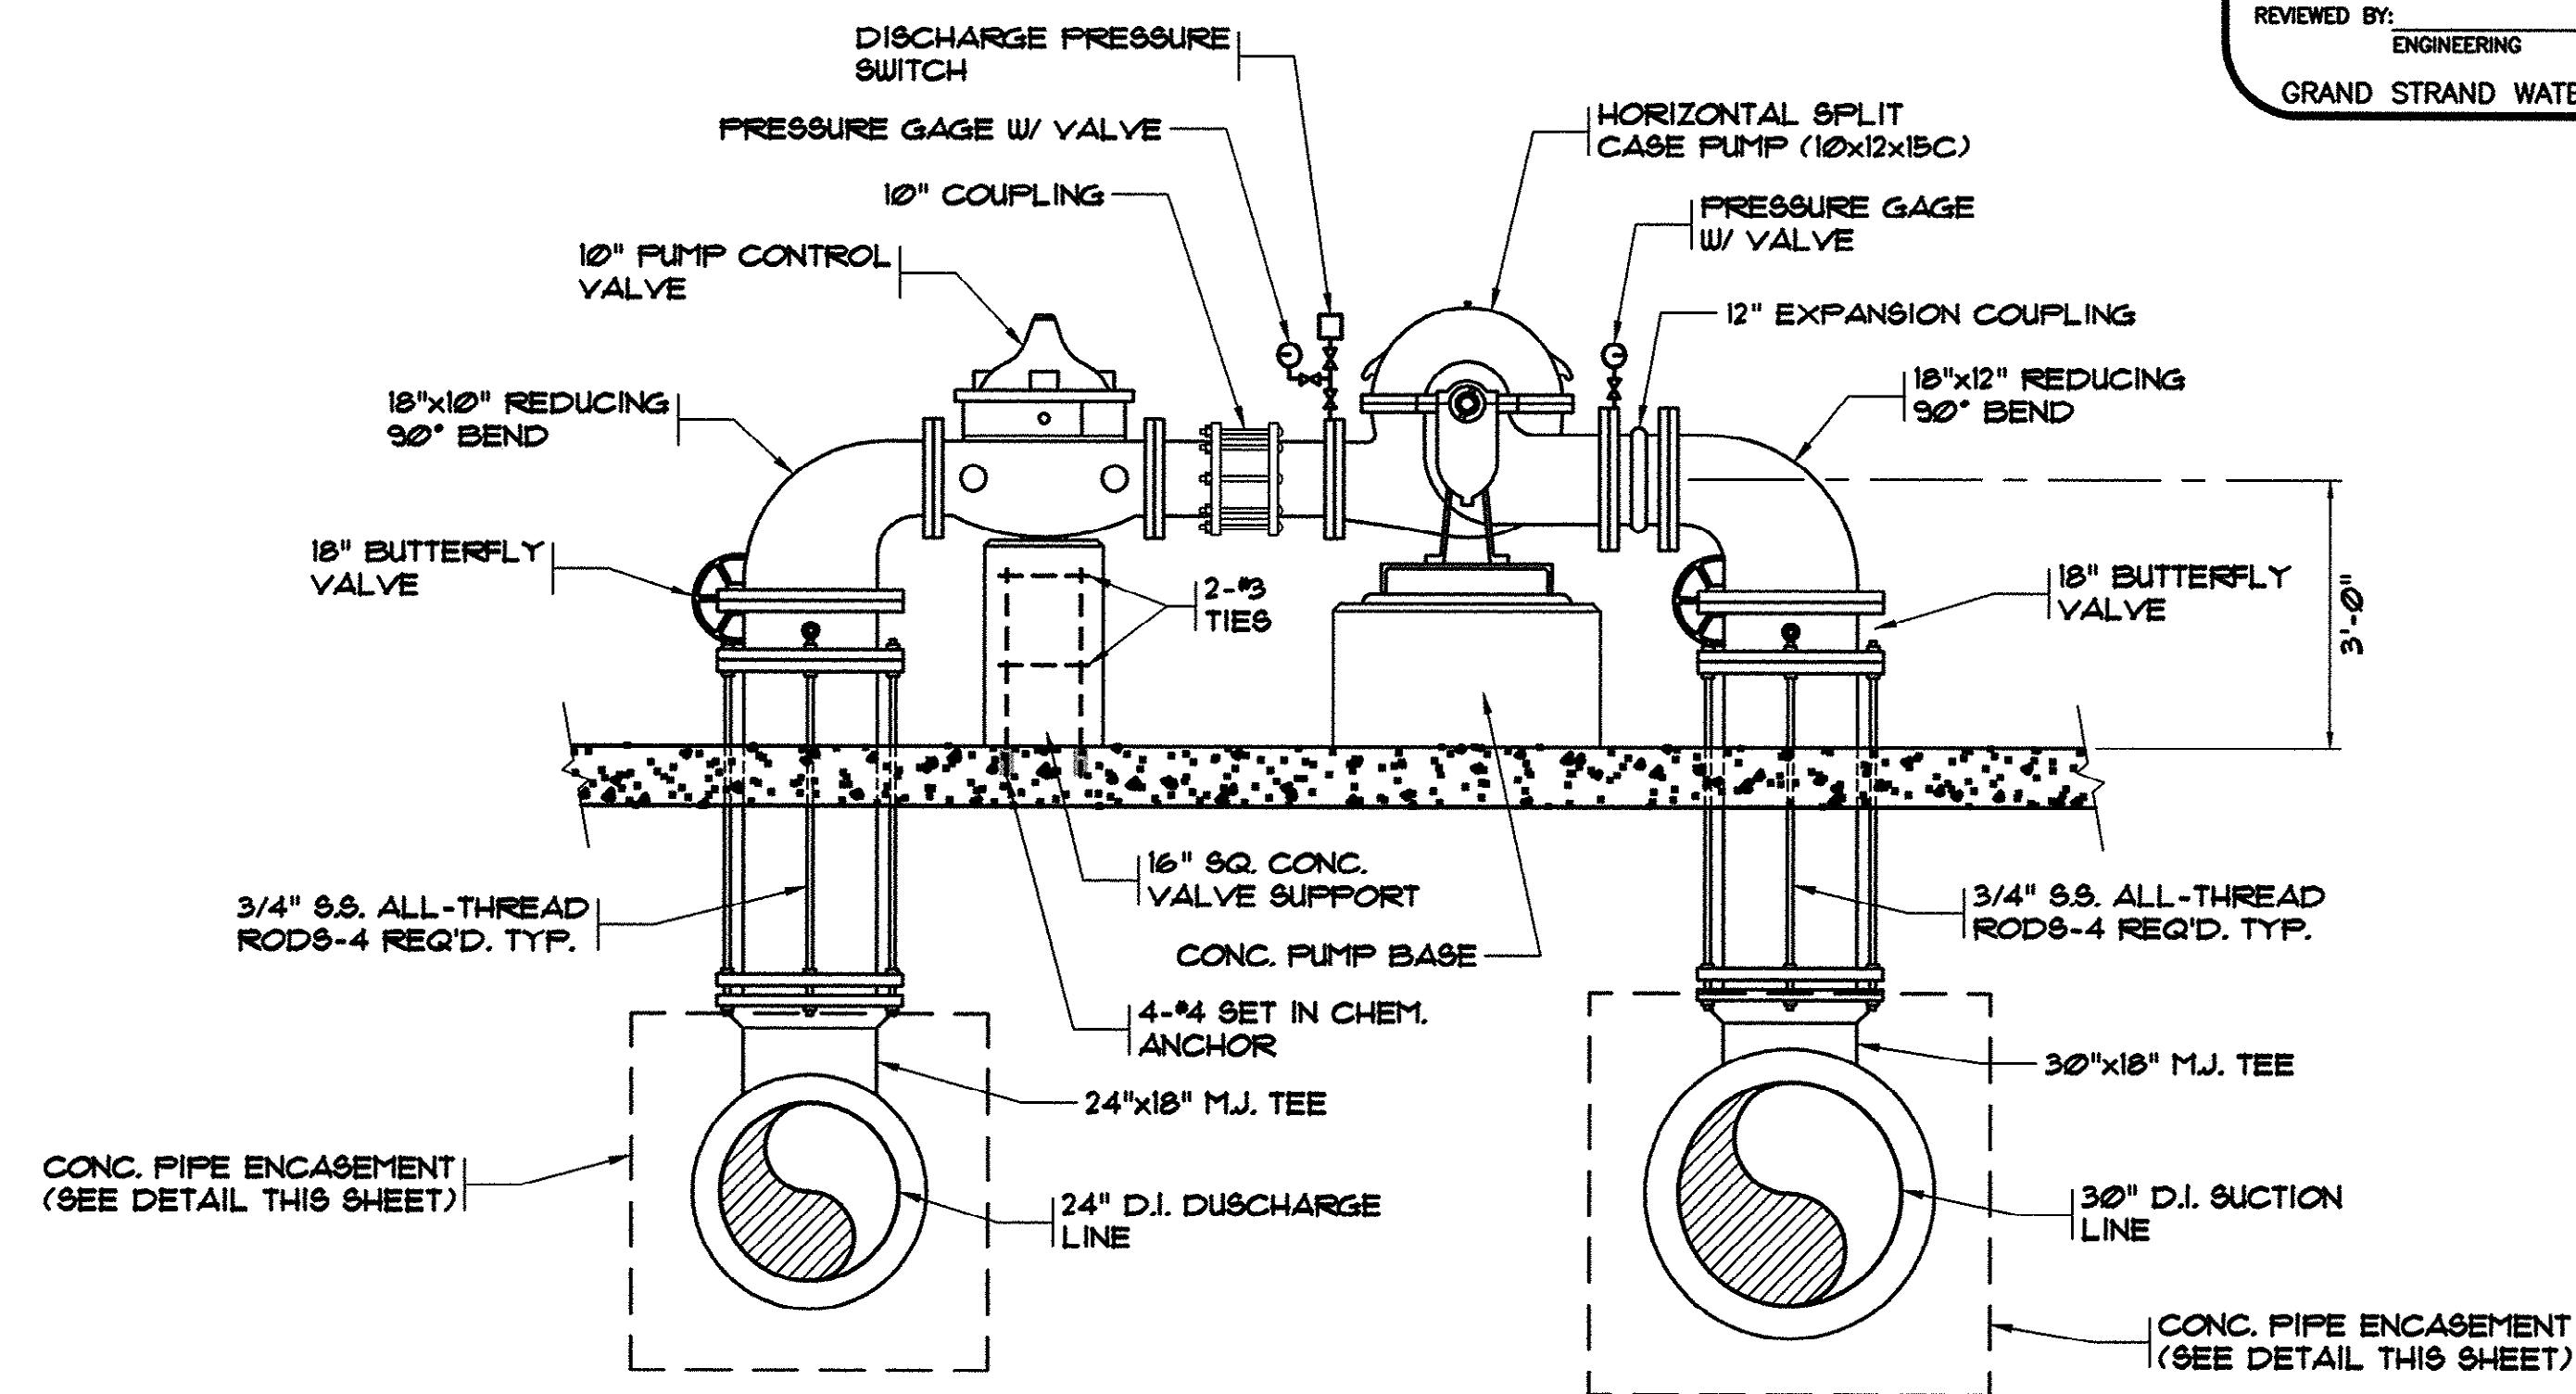

6 PUMP ELEVATION VIEW
SCALE: 1/2" = 1'-0"

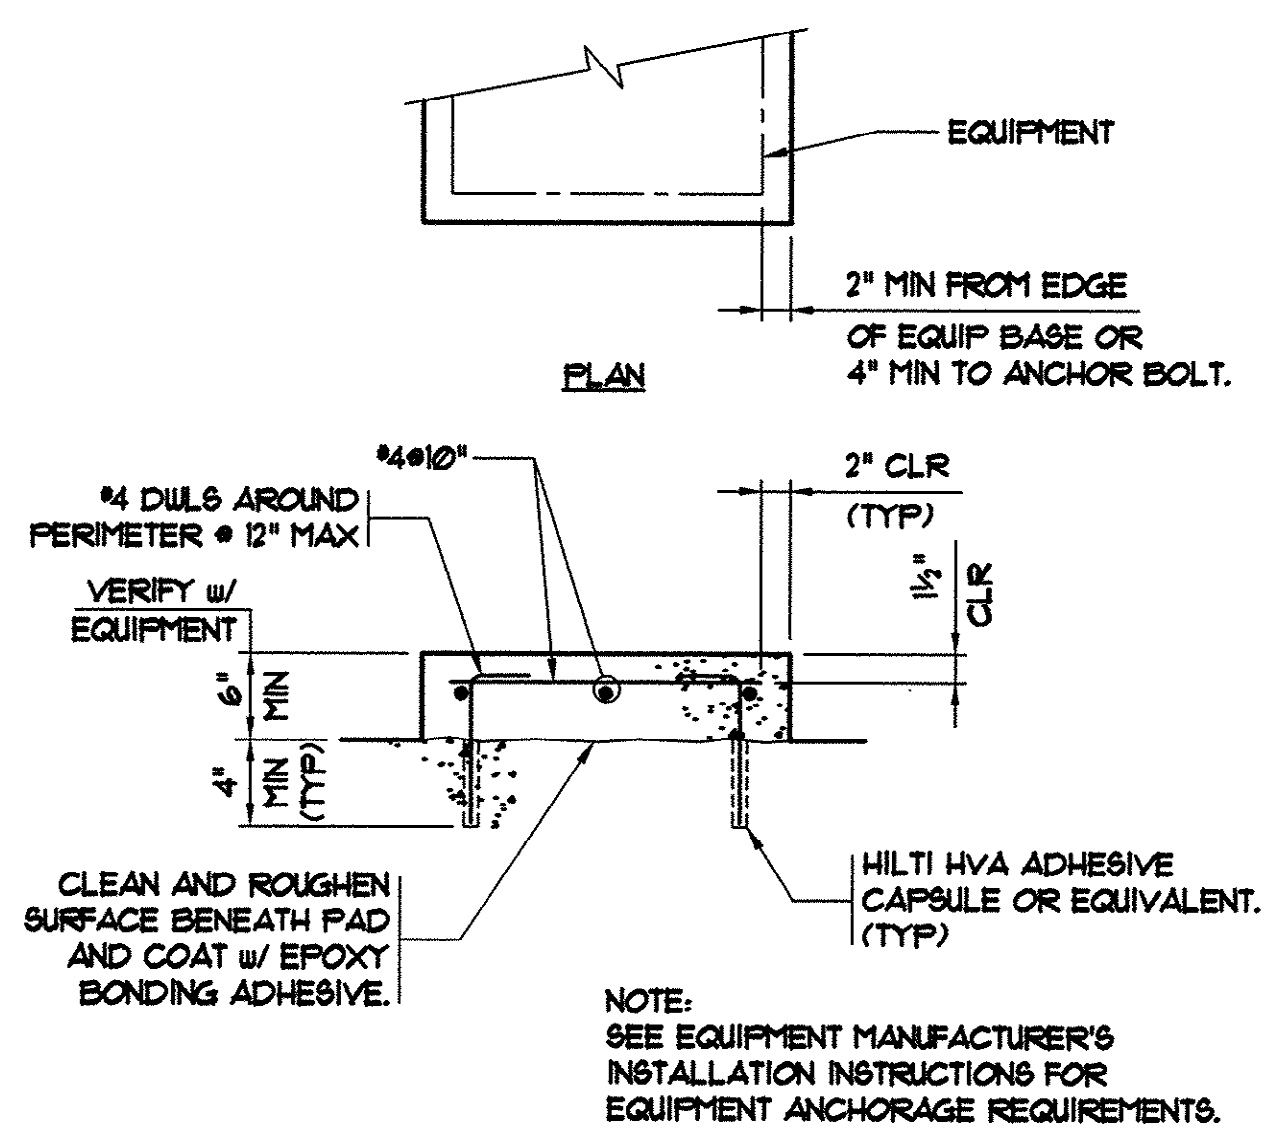

TYP. EQUIPMENT PAD DETAIL
NO SCALE

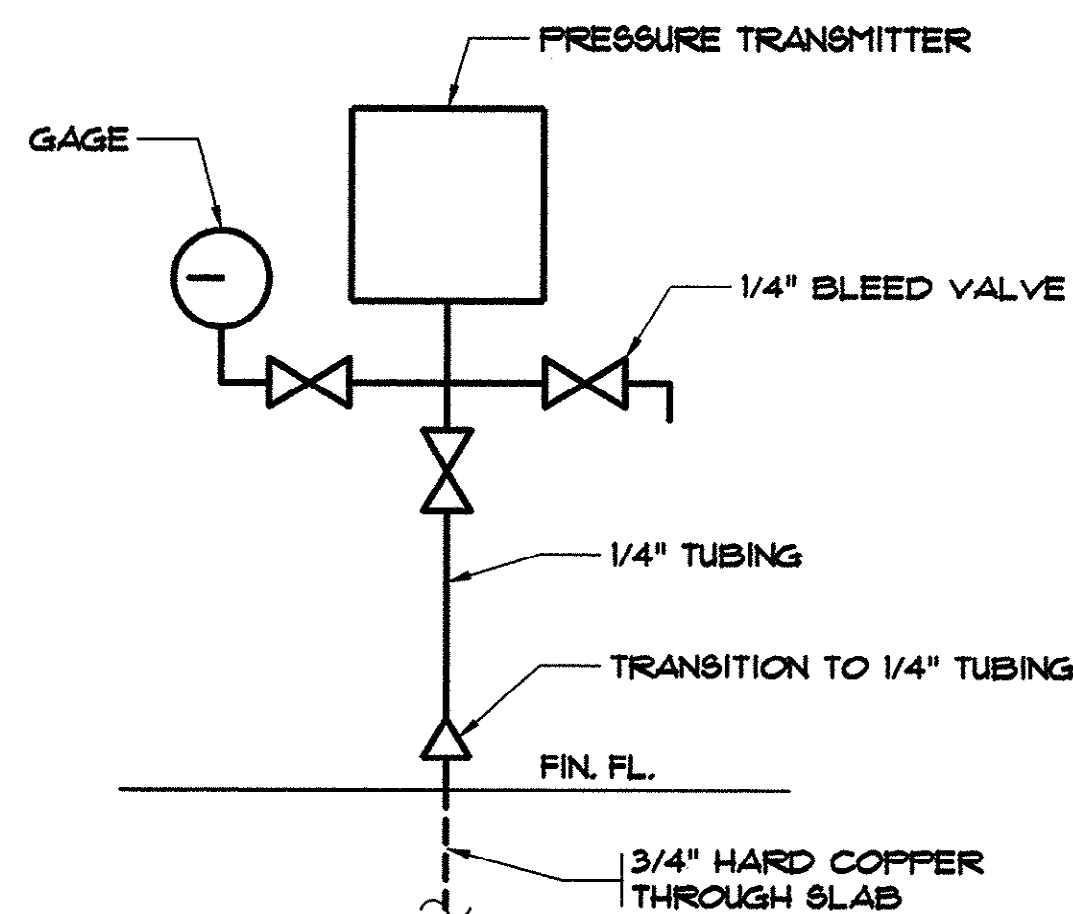

PRESSURE TRANSMITTER SCHEMATIC
N.T.S.


THESE DRAWINGS REFLECT
AS-BUILT
CONDITIONS

REVIEWED BY: _____ DATE: _____
INSPECTIONS

REVIEWED BY: _____ DATE: _____
ENGINEERING


GRAND STRAND WATER AND SEWER AUTHORITY

NOTE: ENCASE PIPES
UNDER ALL STRUCTURES
3'± BEYOND OUTSIDE
OF BUILDING.

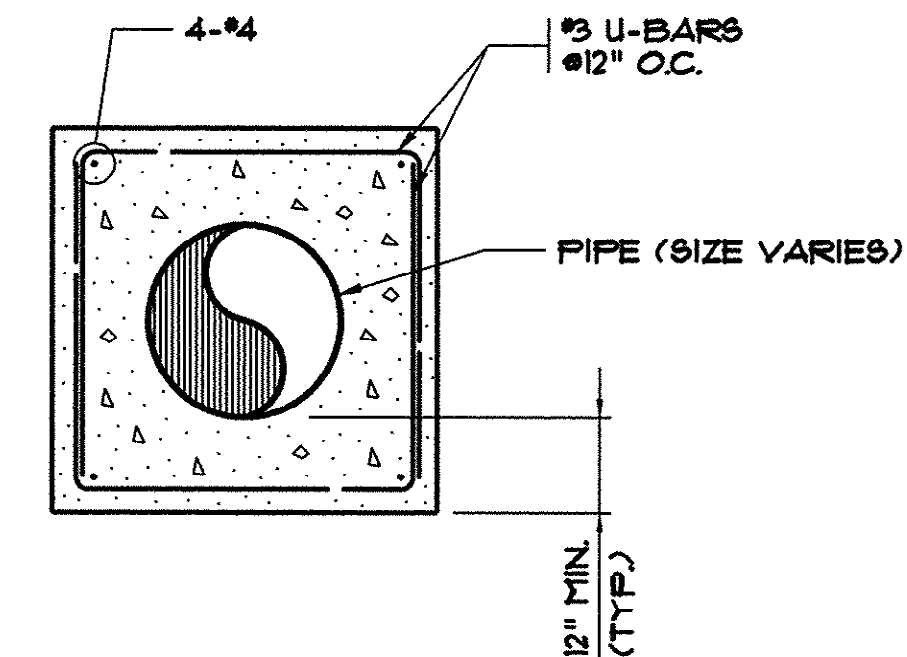


TYPICAL PIPE ENCASEMENT DETAIL
SCALE: 3/4" = 1'-0"


FURLIN SPACING			
BLDG.	'A'	BLDG.	'A'
12'	2'-10 1/2"	24'	3'-11"
16'	3'-10 1/2"	28'	4'-7"
20'	4'-10 1/2"	32'	3'-11 1/4"

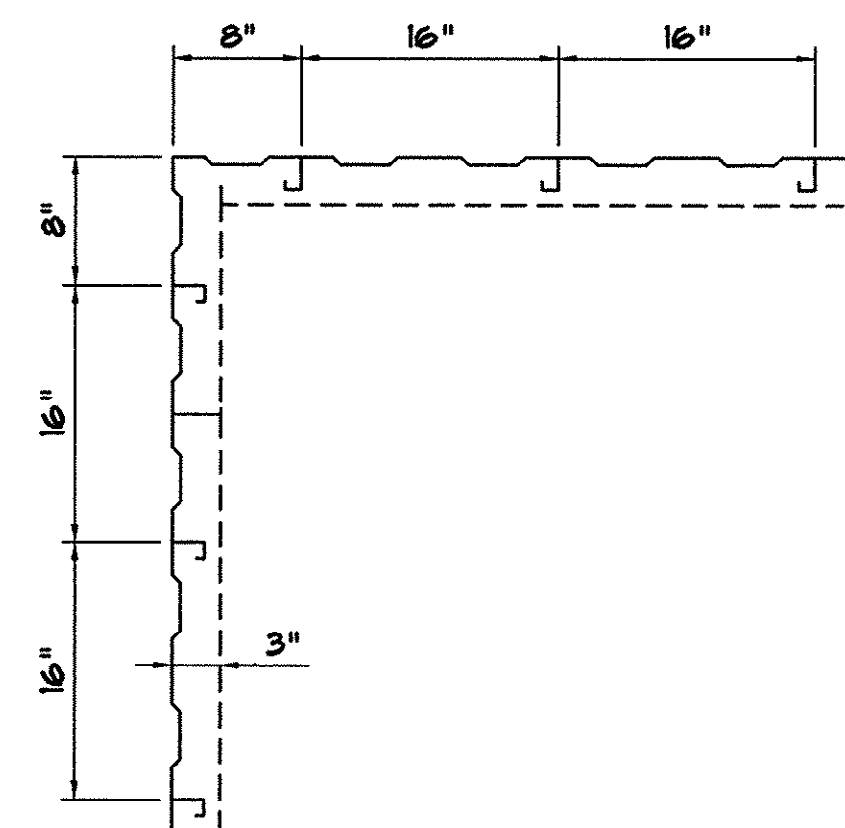


A CORNER DETAIL
SCALE: 1/4" = 1'-0"

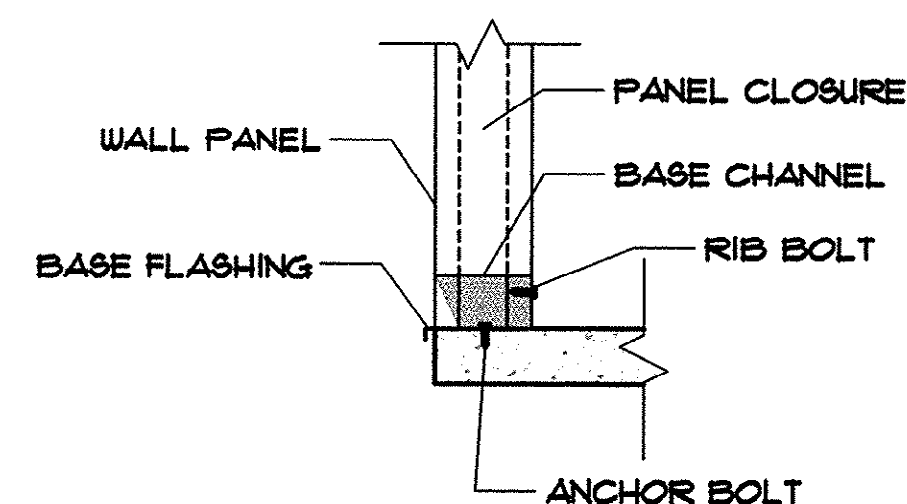


B BASE DETAIL
N.T.S.

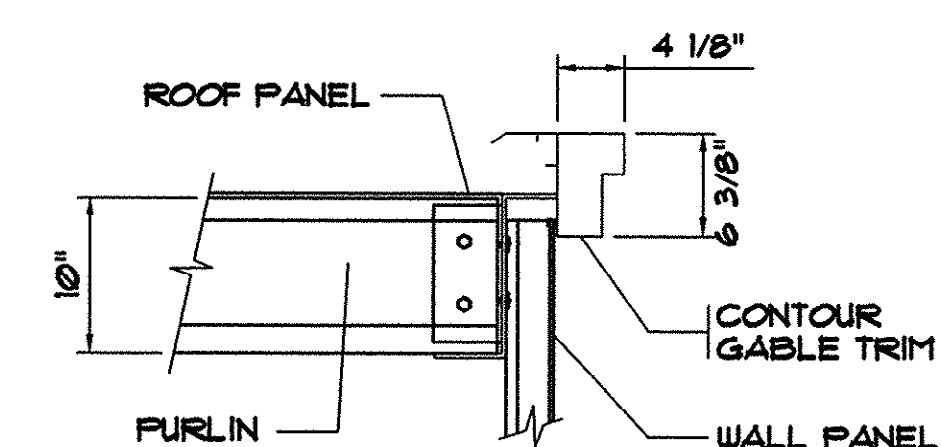

C SECTION AT ENDWALL
SCALE: 1/4" = 1'-0"

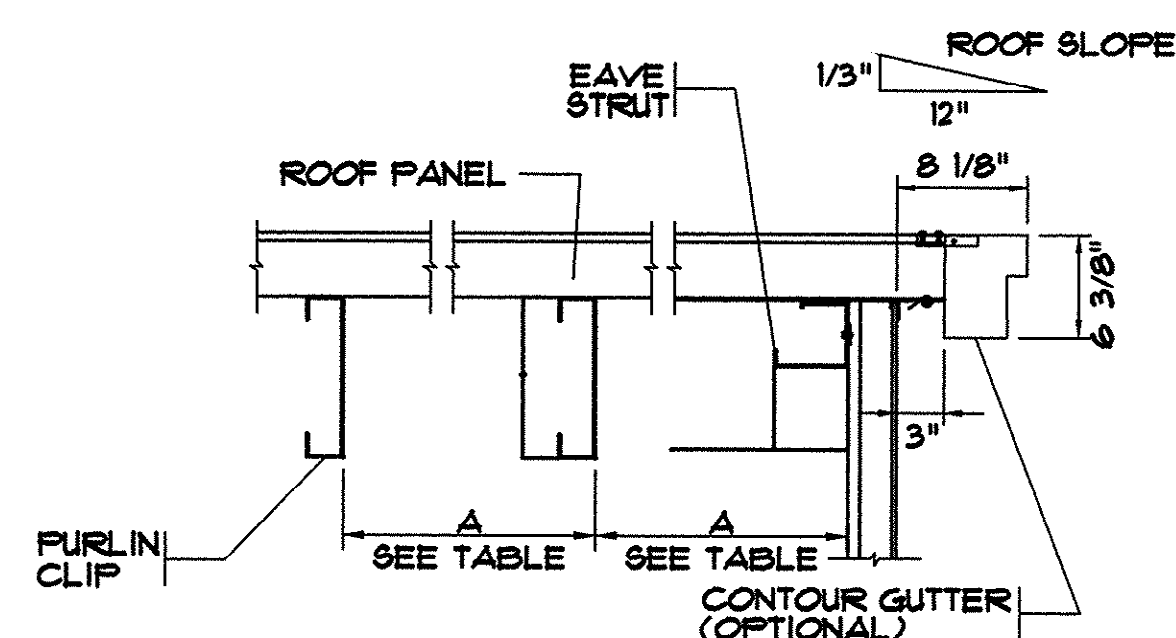

D SECTION AT EAVE
SCALE: 1/4" = 1'-0"

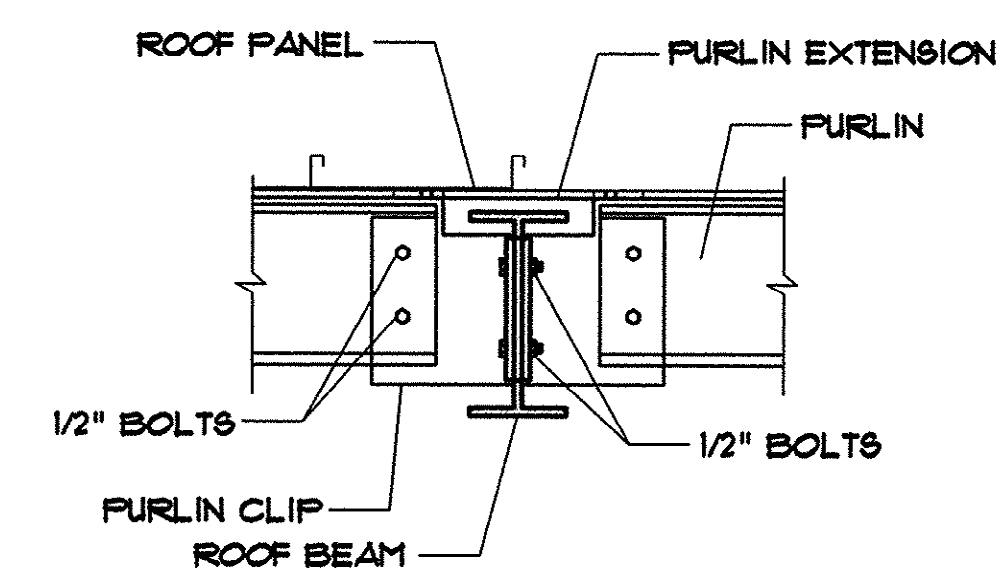

PURLIN TO FRAME DETAIL
SCALE: 1/4" = 1'-0"


IRRIGATION BOOSTER
PUMP STATION
PUMP ELEVATION AND
BUILDING DETAILS

TIP-TOP TREE FARM
EFFLUENT LAND
APPLICATION PROJECT
GRAND STRAND WATER
AND SEWER AUTHORITY

DATE: MAR. 1999
DESIGNED: JWM
DRAWN: DC
CHECKED: JWM
SCALE: AS SHOWN
SHEET NO.


G-12
16

45-003-012/53

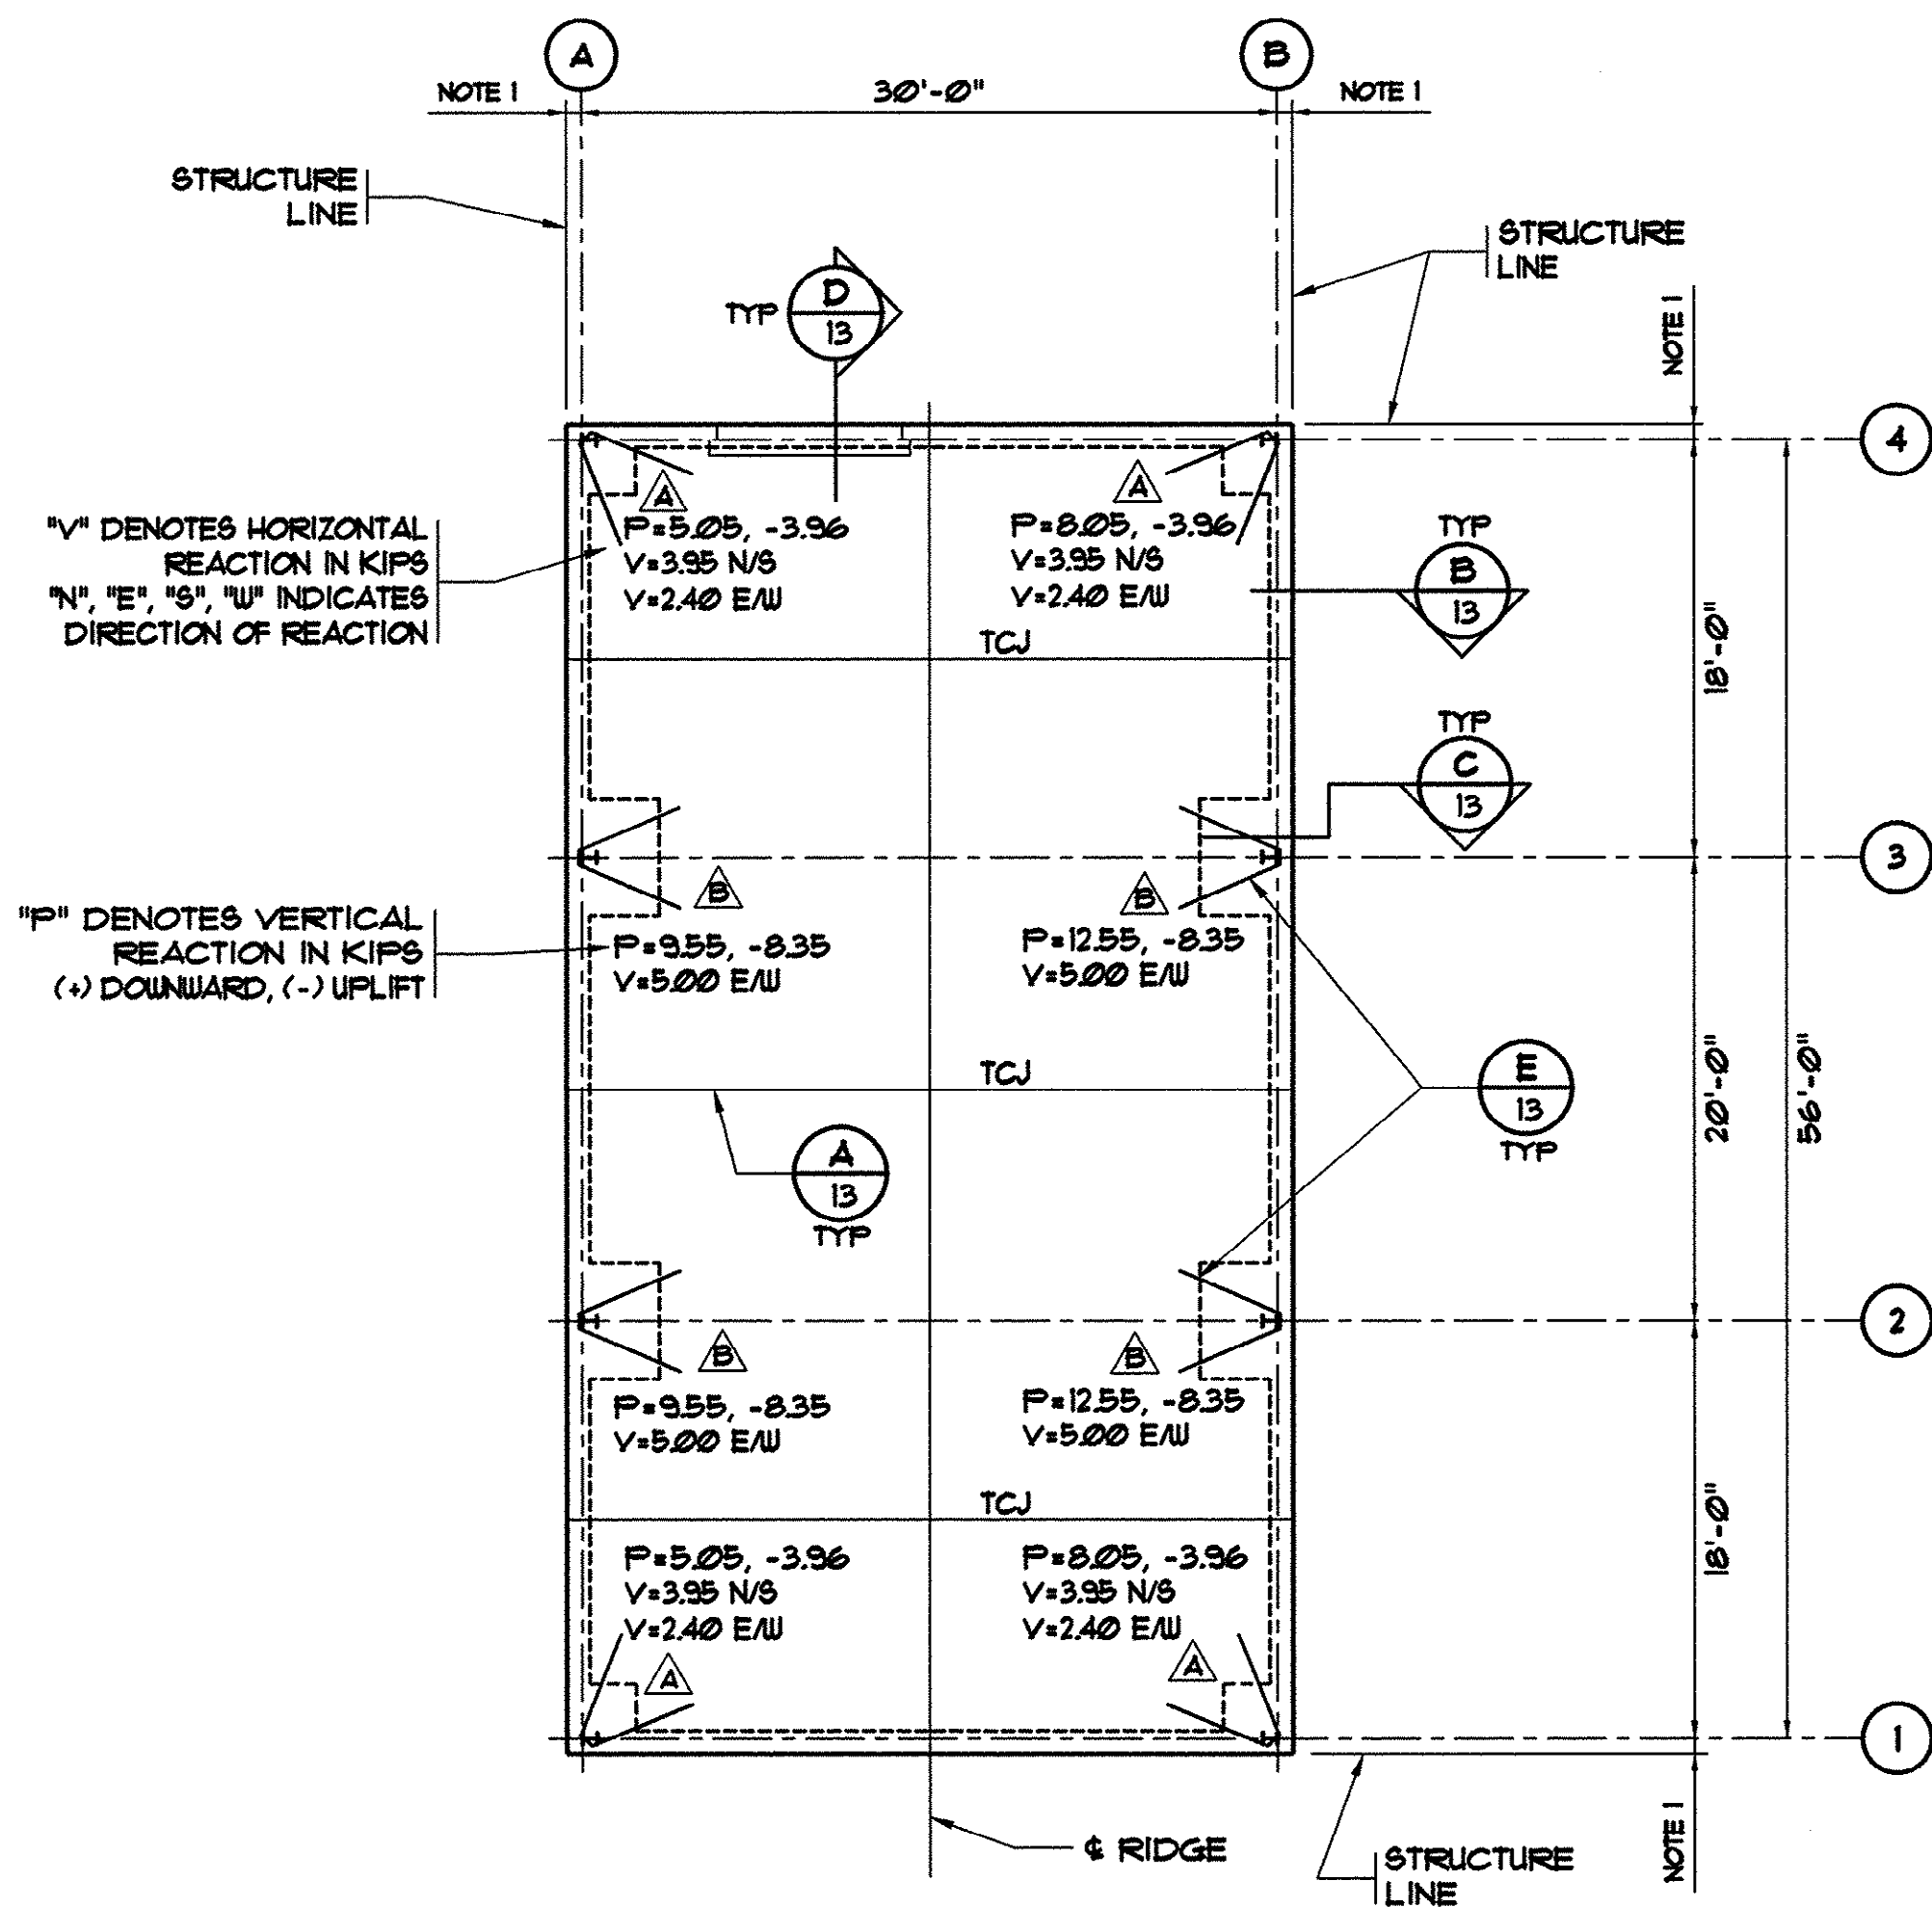

FOUNDATION PLAN

- NOTE:
1. OUTSIDE EDGE OF CONCRETE BUILDING SLAB SHALL CORRESPOND WITH BUILDING STRUCTURE LINE. (COORDINATE WITH BUILDING MANUFACTURER.)
 2. SEE SITE PLAN FOR TOP OF SLAB ELEVATIONS.
 3. ALL SLABS SHALL BE 6" THICKNESS, UON.
 4. ALL SLABS SHALL BE PLACED OVER VAPOR BARRIER AND 4" COMPACTED STONE AND REINFORCED WITH 6x6-W2.5xW2.5 WUF, UON.
 5. VERTICAL REACTIONS SHOWN INCLUDE MAX REACTIONS DUE TO MONORAIL LOADS.

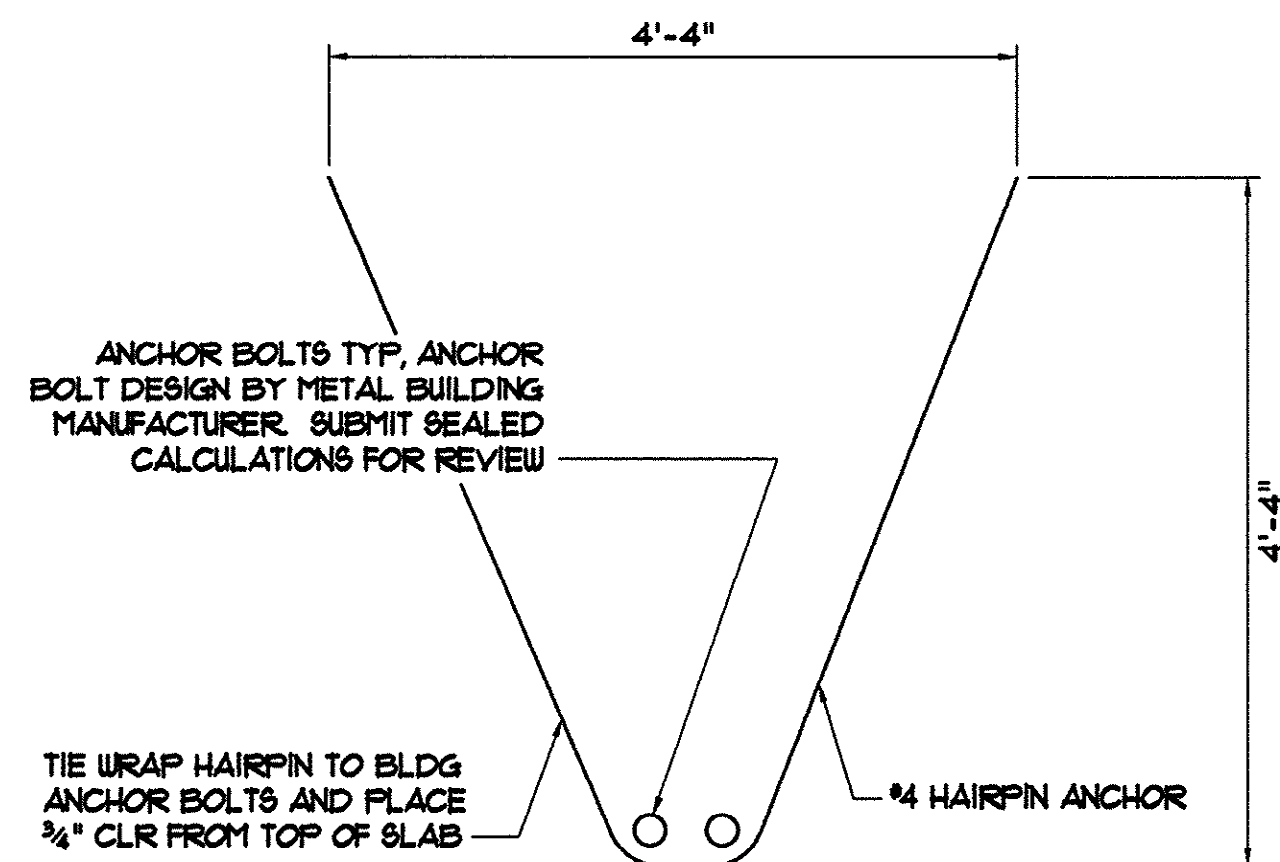


TYP HAIRPIN ANCHOR DETAIL

NO SCALE

TYP CONTROL JOINT "TCJ"

NO SCALE

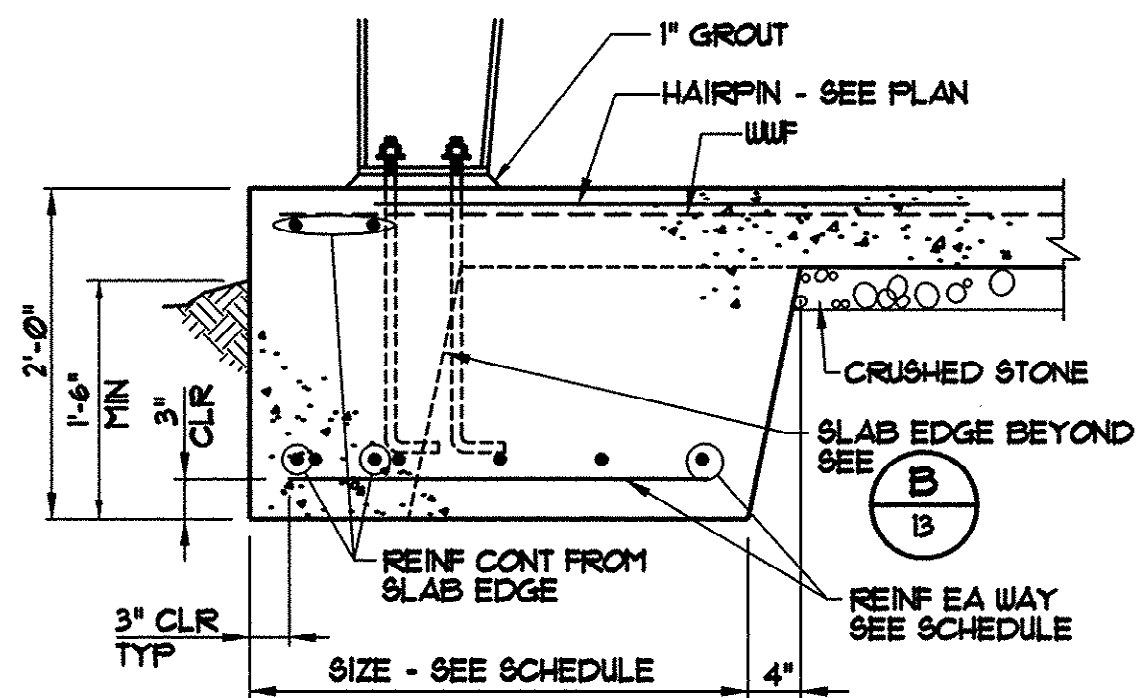


TYP SLAB EDGE FOOTING REINF DETAIL

NO SCALE

TYP SLAB EDGE REINF DETAIL

NO SCALE

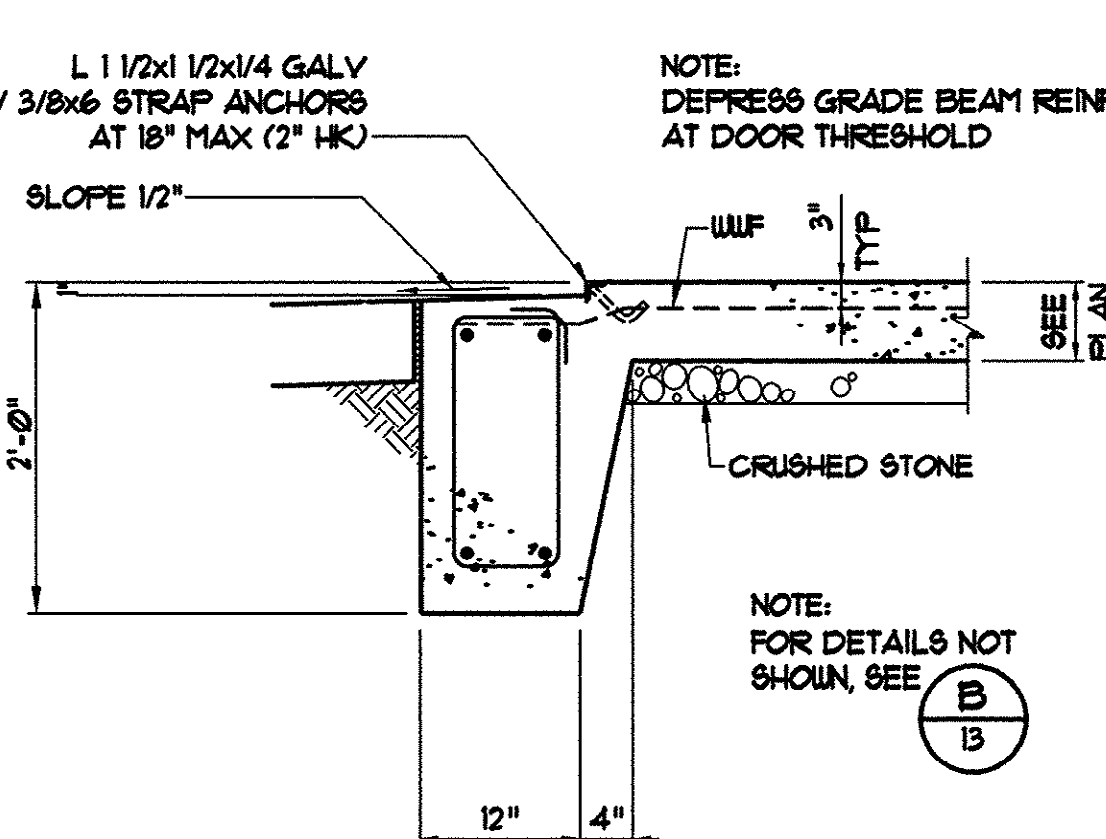

TYP SLAB EDGE AT OH DOOR

NO SCALE


COLUMN FOOTING SCHEDULE			
MARK	SIZE	DEPTH	REIN. EA WAY
A	3'-0"x3'-0"	24"	4-#5
B	4'-0"x5'-0"	24"	6-#5 BW 5-#5 LW

THESE DRAWINGS REFLECT
AS-BUILT
CONDITIONS

REVIEWED BY: INSPECTIONS DATE


REVIEWED BY: ENGINEERING DATE

GRAND STRAND WATER AND SEWER AUTHORITY

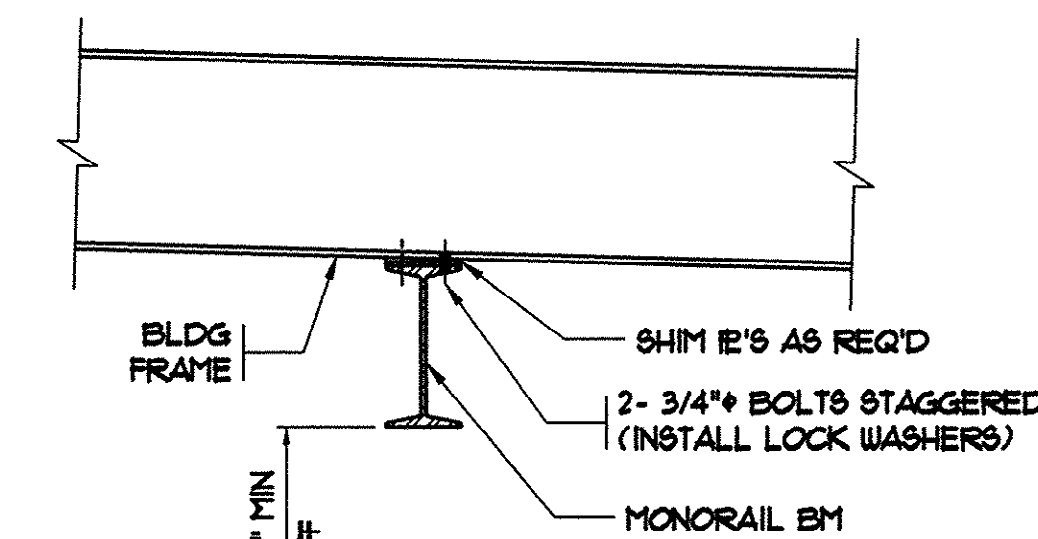


TYP MONORAIL BM CONN DETAIL

SCALE: 1/2"=1'-0"

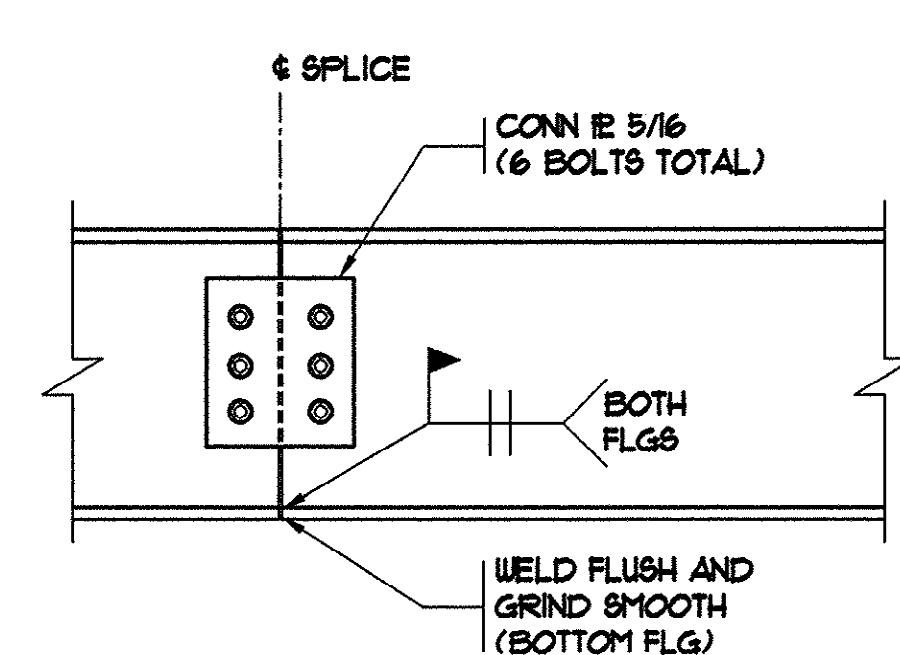

TYP MONORAIL BM SPLICE DETAIL


SCALE: 1/2"=1'-0"

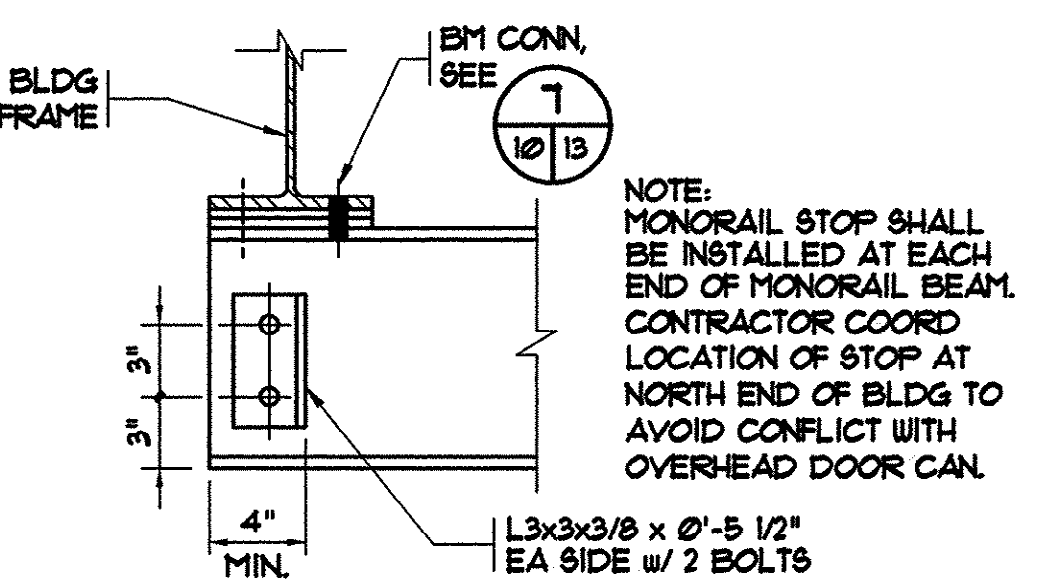

TYP MONORAIL STOP DETAIL

SCALE: 1/2"=1'-0"

REVISIONS	DATE	BY
DESCRIPTION	8/02/01	CAR
AS-BUILT		

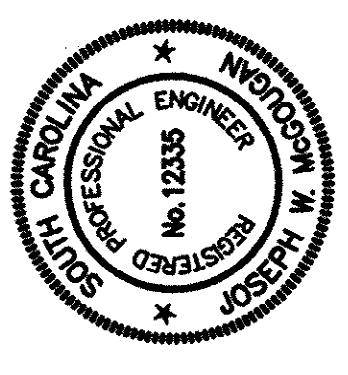

HOBBS, UPCHURCH & ASSOCIATES, P.A.
CONSULTING ENGINEERS
MYRTLE BEACH, SOUTH CAROLINA 29577

IRRIGATION BOOSTER
PUMP STATION
FOUNDATION PLAN
AND DETAILS

TIP-TOP TREE FARM
EFFLUENT LAND
APPLICATION PROJECT
GRAND STRAND WATER
AND SEWER AUTHORITY





DATE:	MAR. 1999
DESIGNED:	JWM
DRAWN:	DC
CHECKED:	JWM
SCALE:	AS SHOWN

SHEET NO.

G-13

OF 16

45-003-013/53

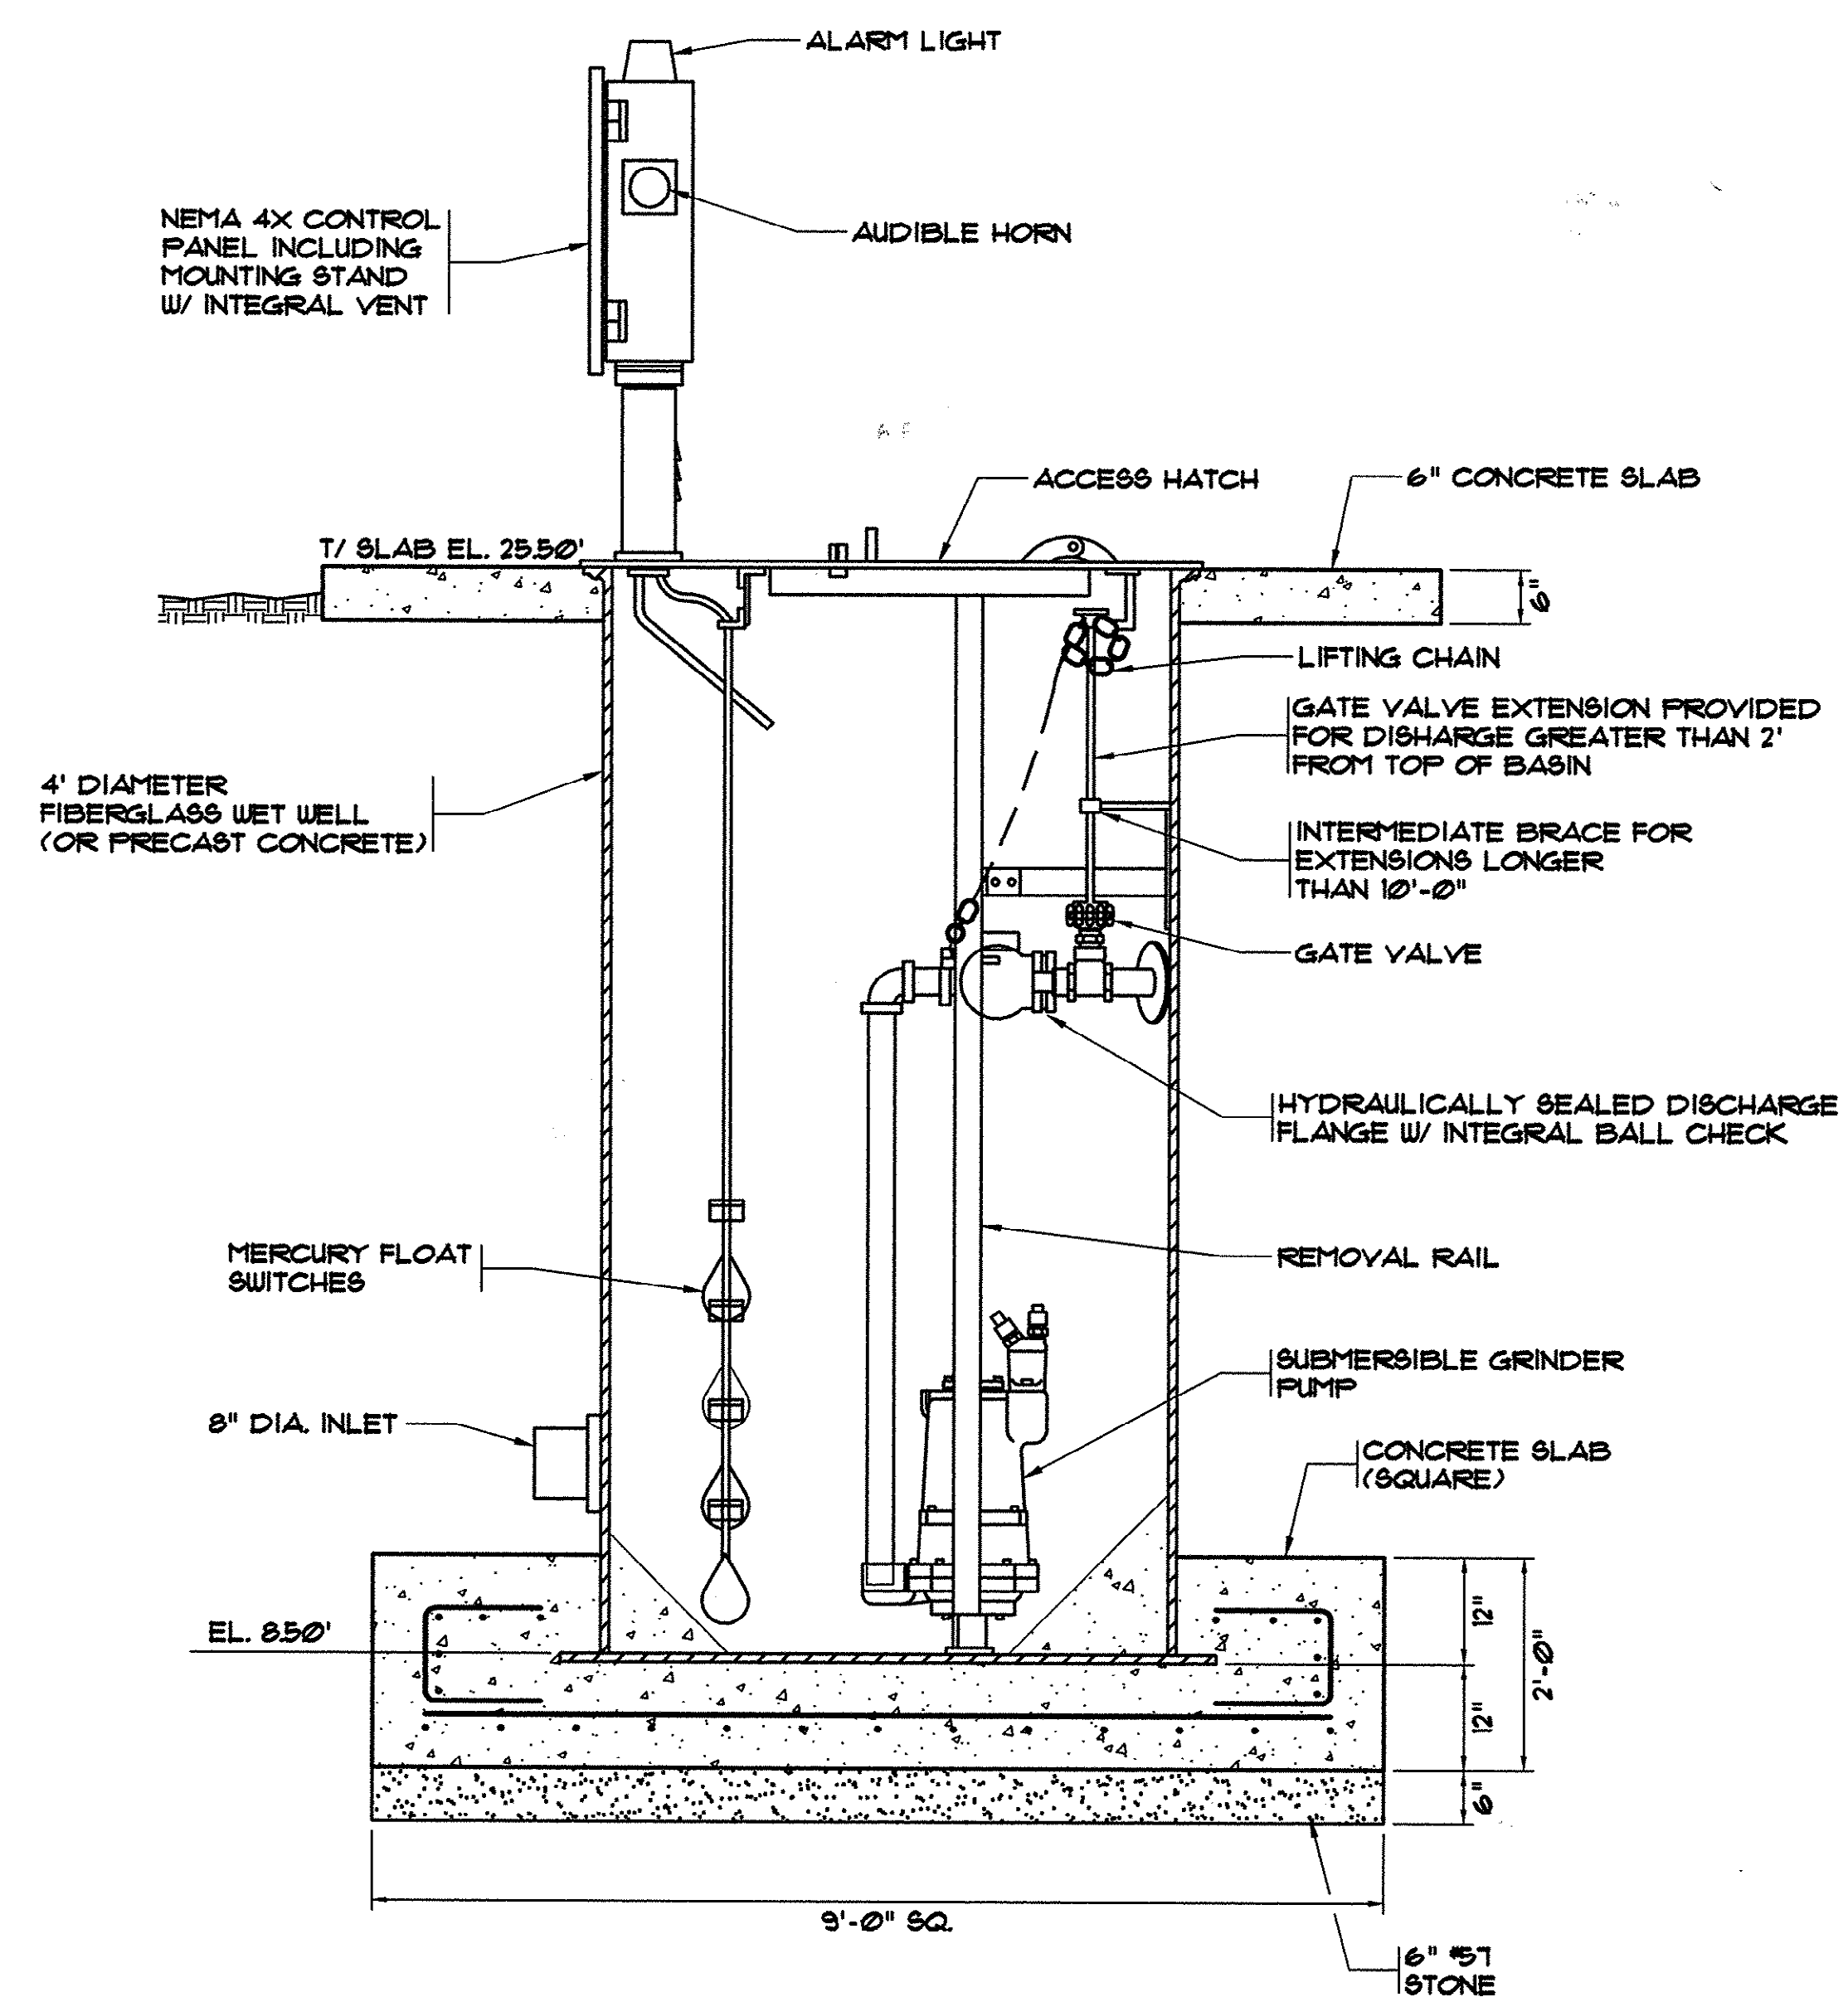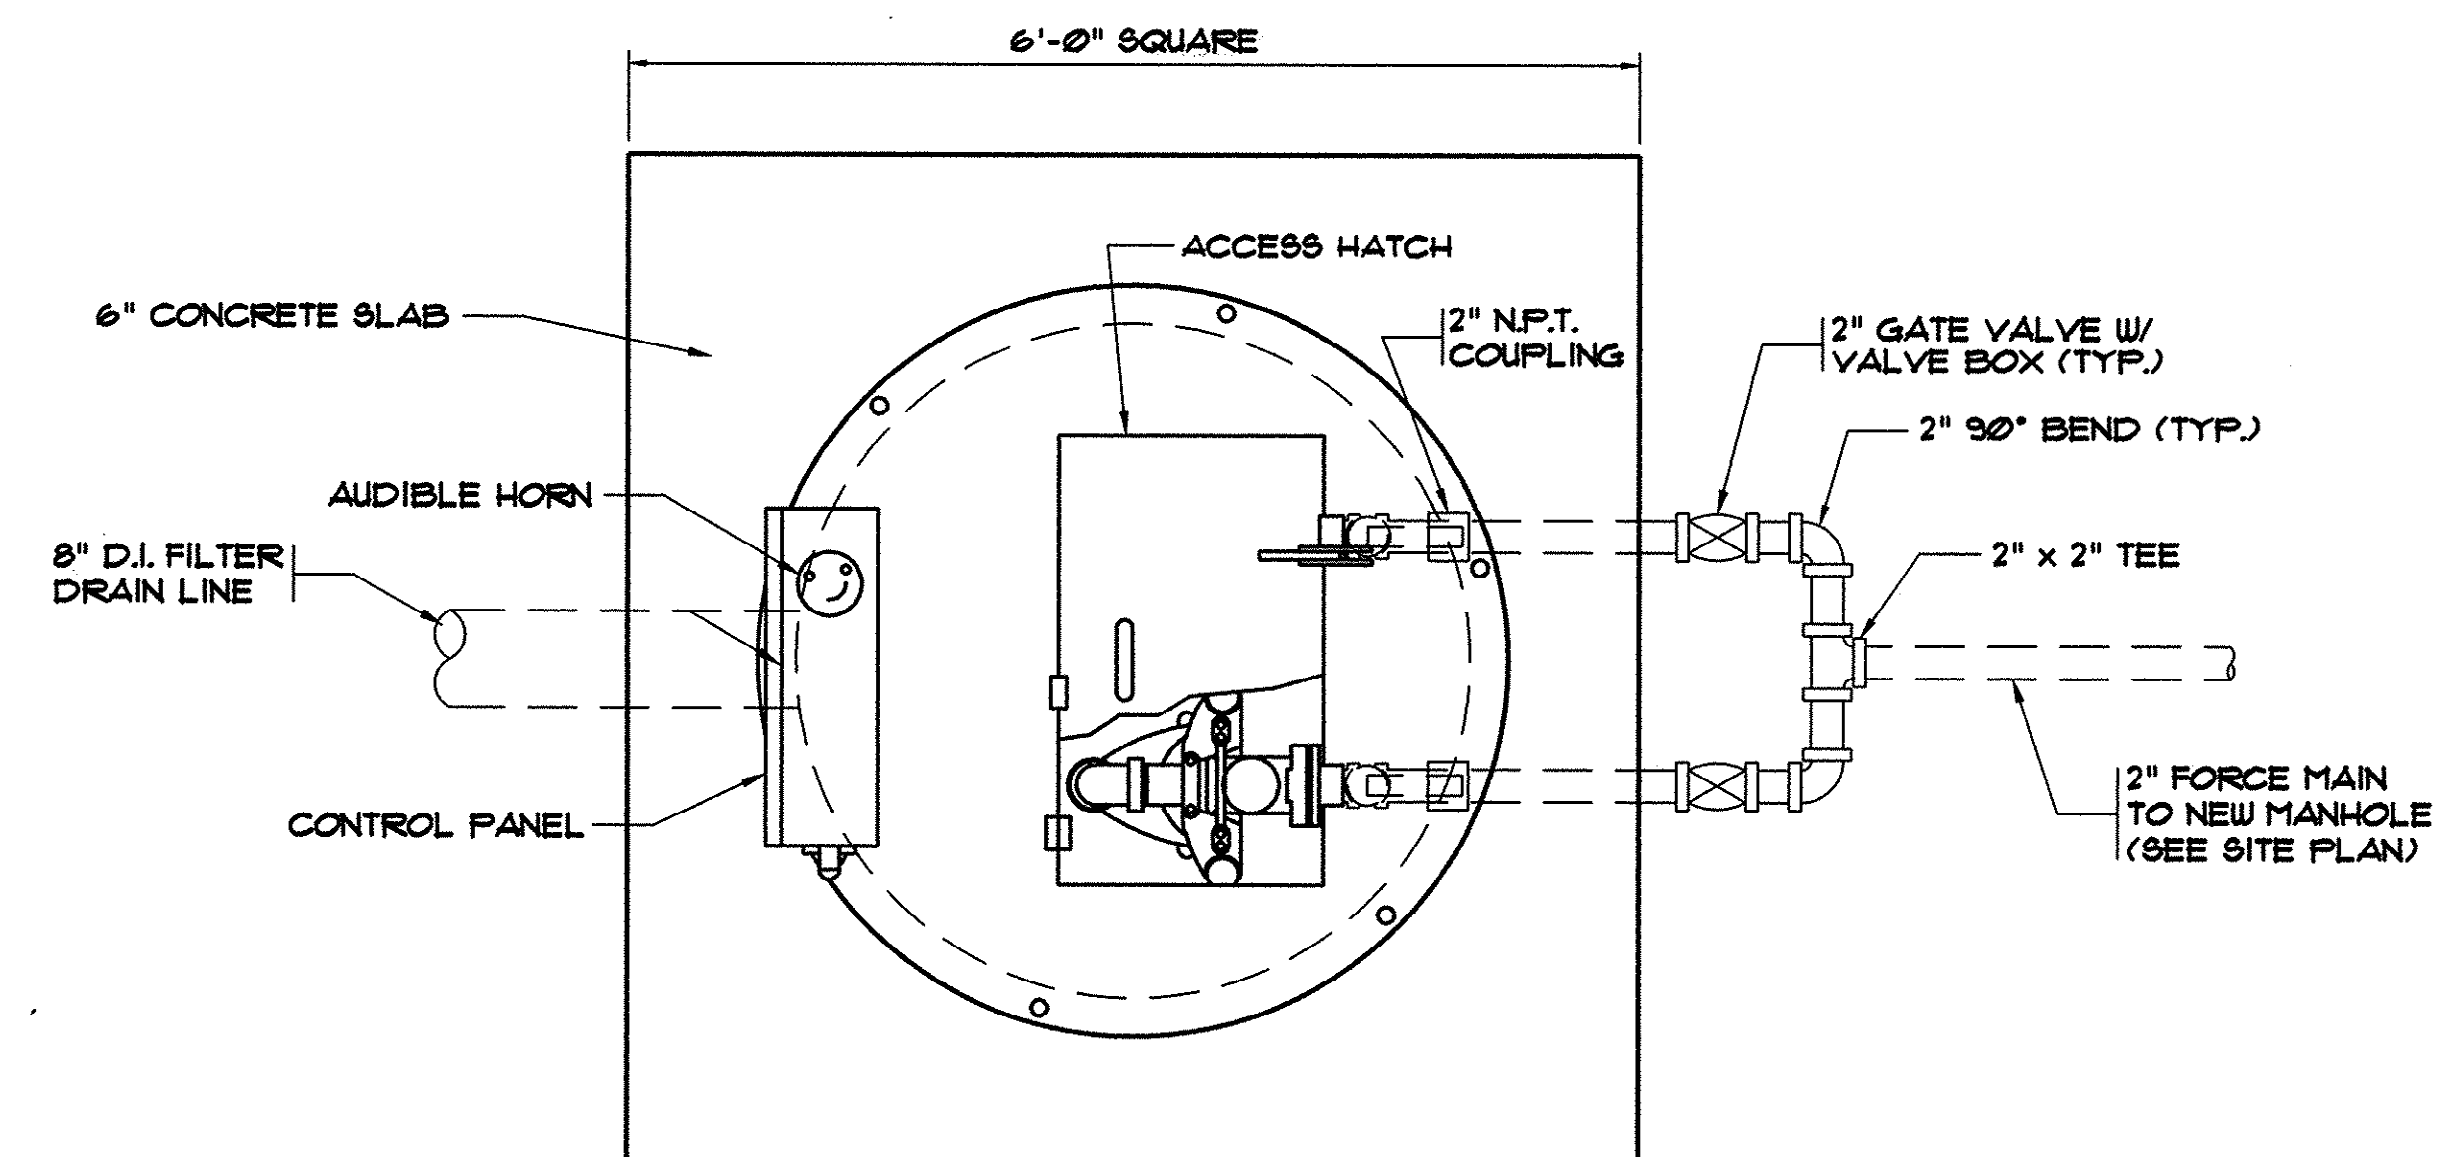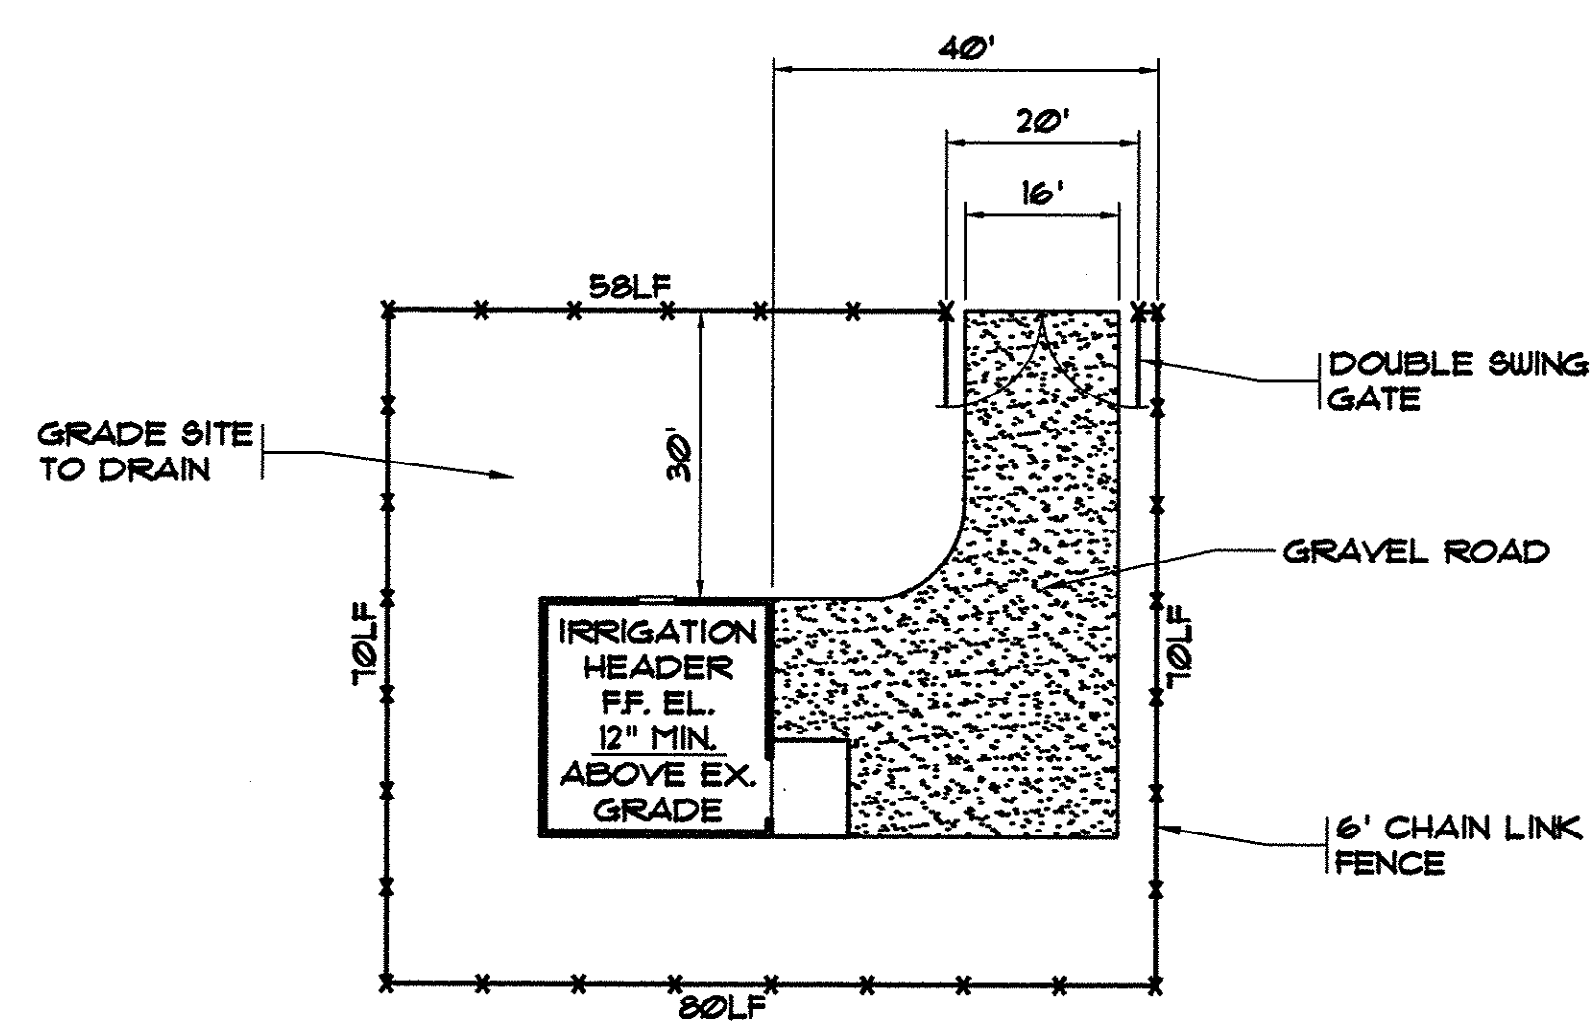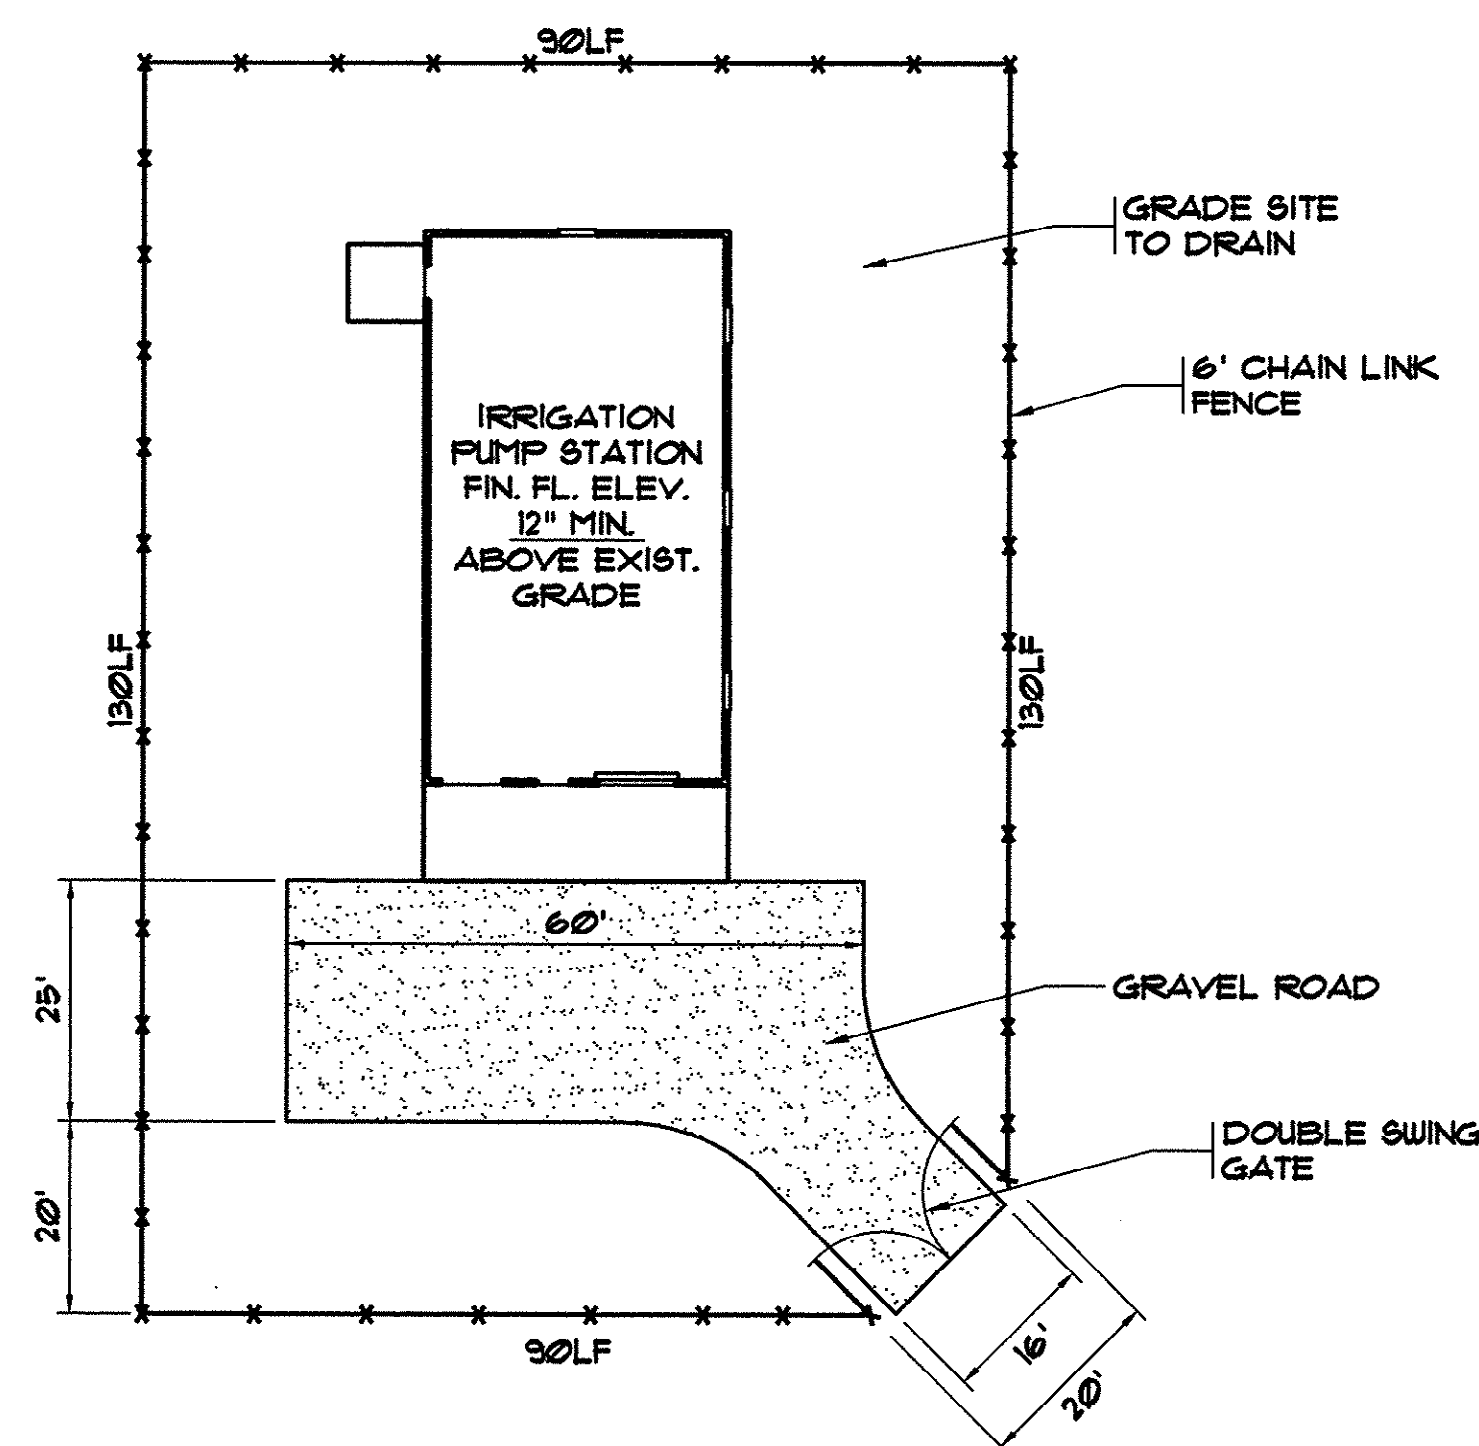


THESE DRAWINGS REFLECT
AS-BUILT
CONDITIONS

REVIEWED BY: _____ DATE _____
INSPECTIONS

REVIEWED BY: _____ DATE _____
ENGINEERING

GRAND STRAND WATER AND SEWER AUTHORITY

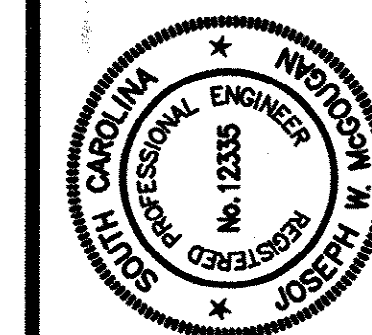[illegible]

HOBBES, UPCHURCH & ASSOCIATES, P.A.
CONSULTING ENGINEERS
MYRTLE BEACH, SOUTH CAROLINA 29577



SITE PLANS FILTER DRAIN PUMP STATION PLAN AND SECTION

TOP-TOP TREE FARM EFFLUENT LAND APPLICATION PROJECT


DATE:	MAR. 1999
DESIGNED:	JWM
DRAWN:	DC
CHECKED:	JWM
SCALE:	AS SHOWN

SHEET NO.

G-14


16

45-003-014/53

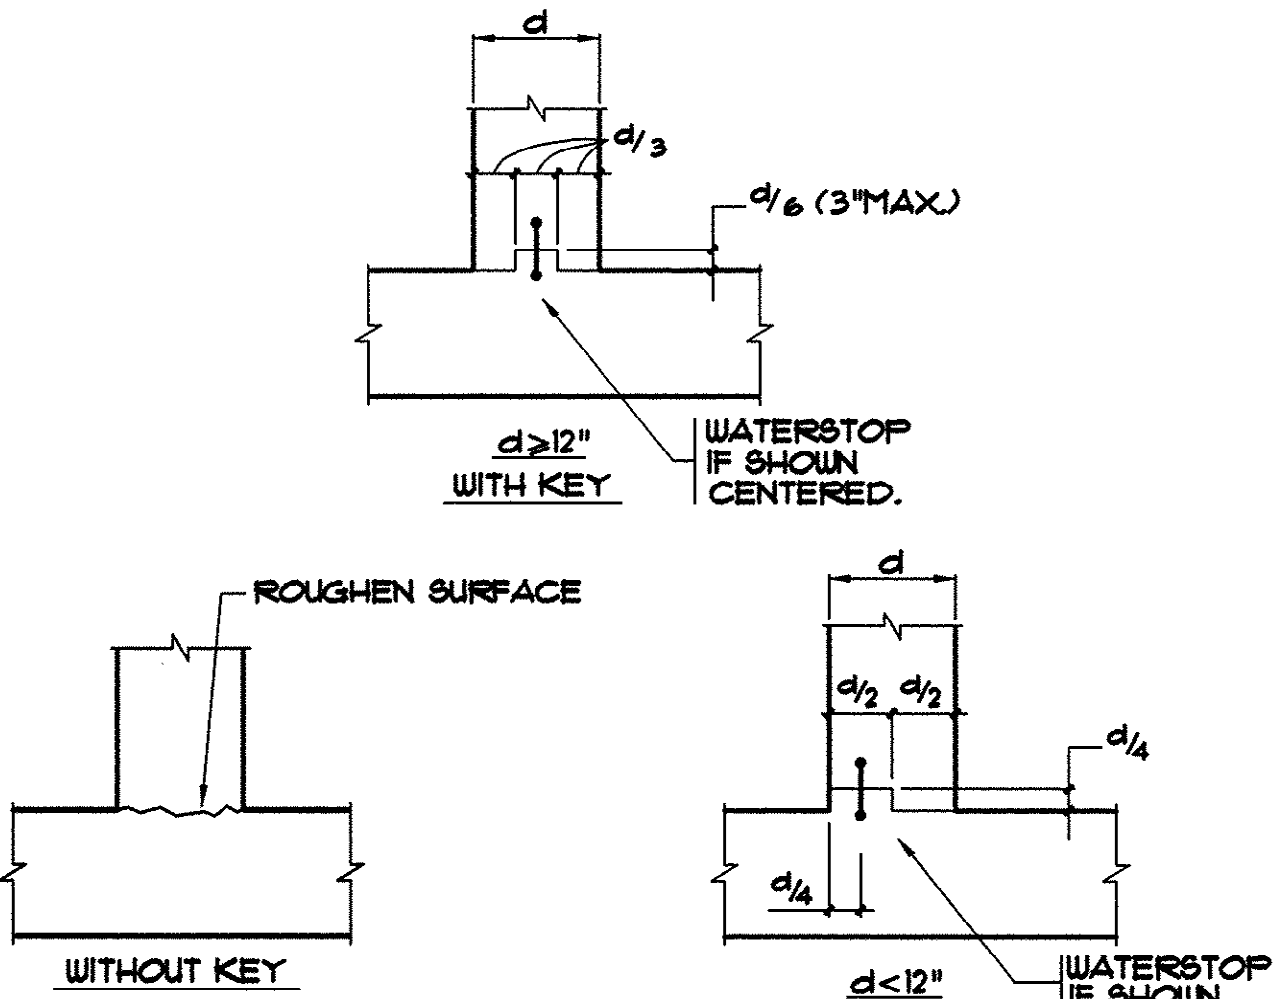


NOTE: ALL WATERSTOPS 6" PVC "DUMBBELL" TYPE UNLESS OTHERWISE NOTED.


STANDARD CONSTRUCTION JOINT DETAILS

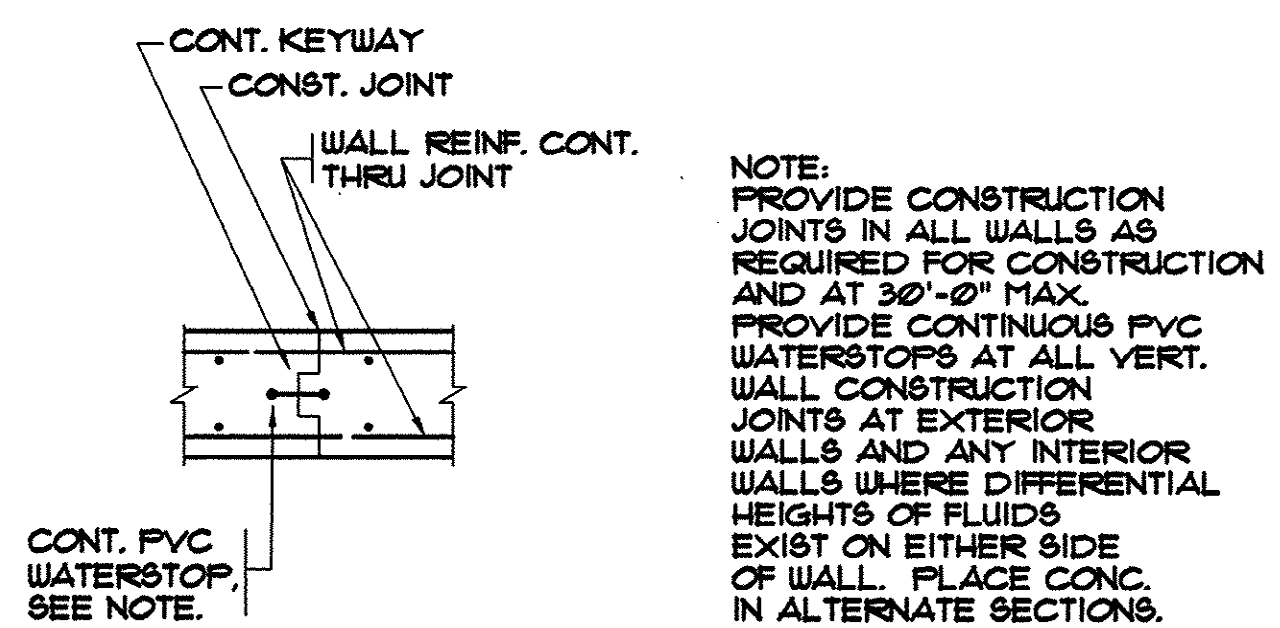


TYPICAL WALL OR SLAB CONSTRUCTION JOINT

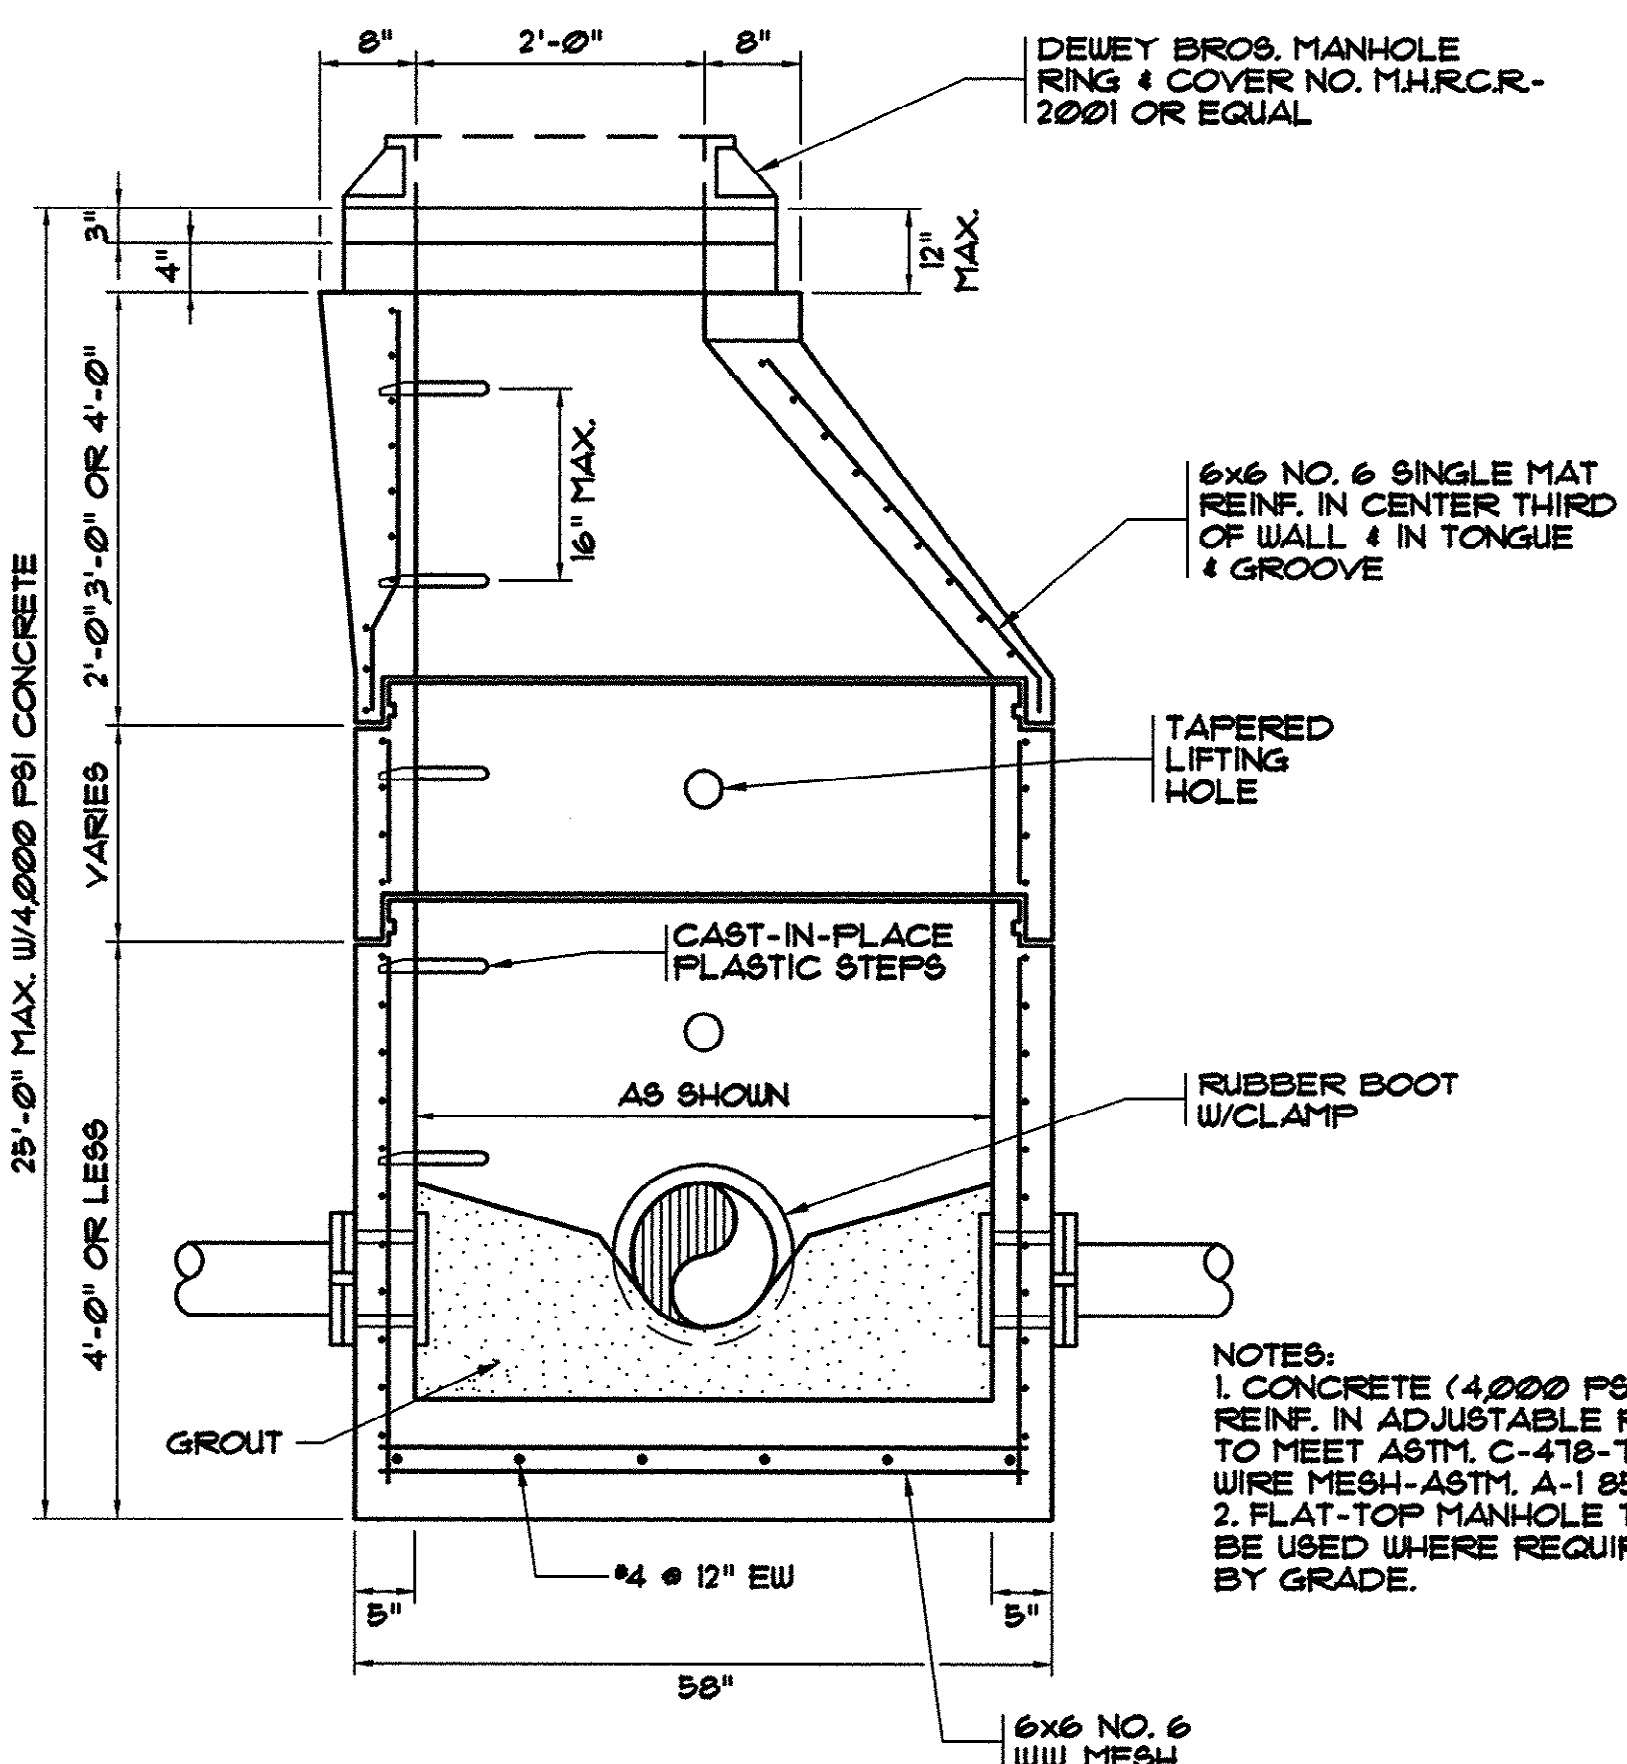


PRECAST MANHOLE DETAIL

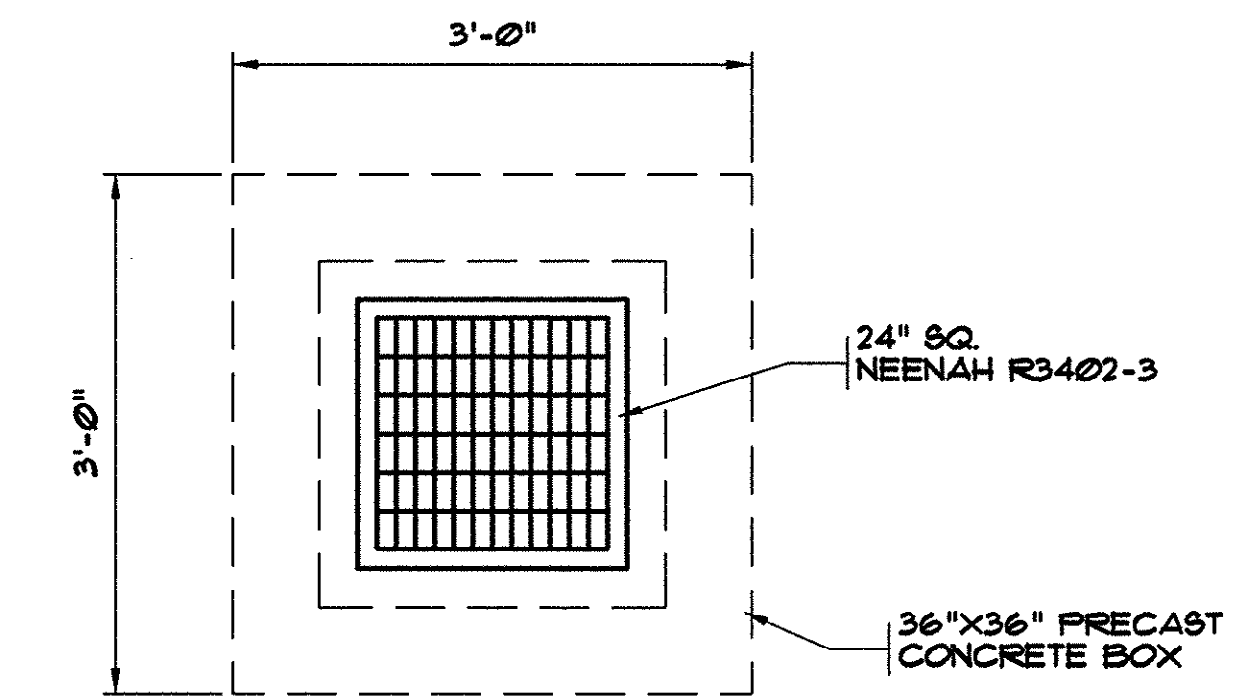

DROP INLET - PLAN VIEW

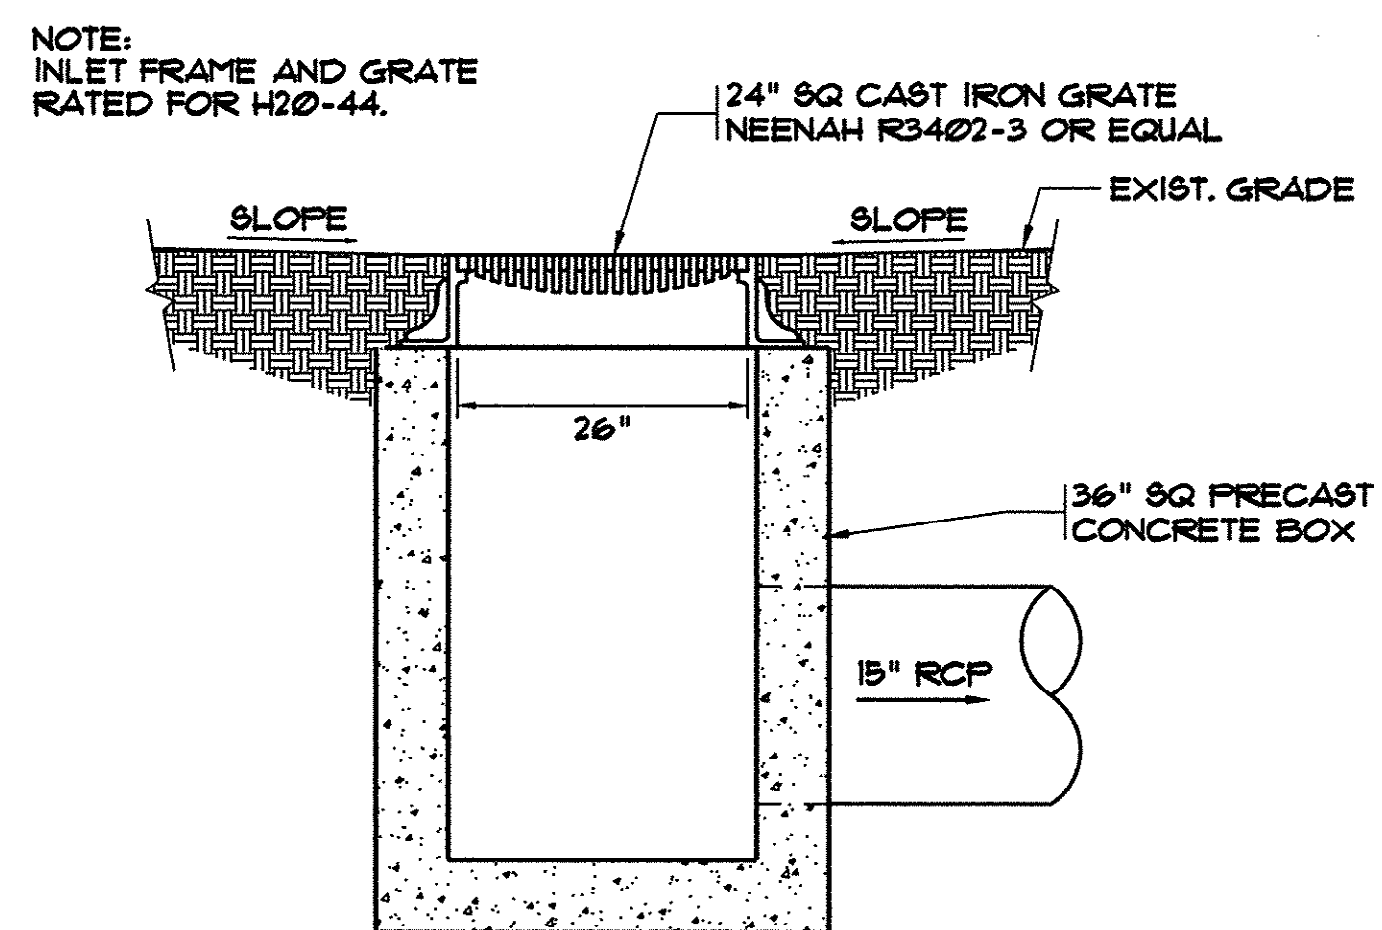

DROP INLET - SECTION

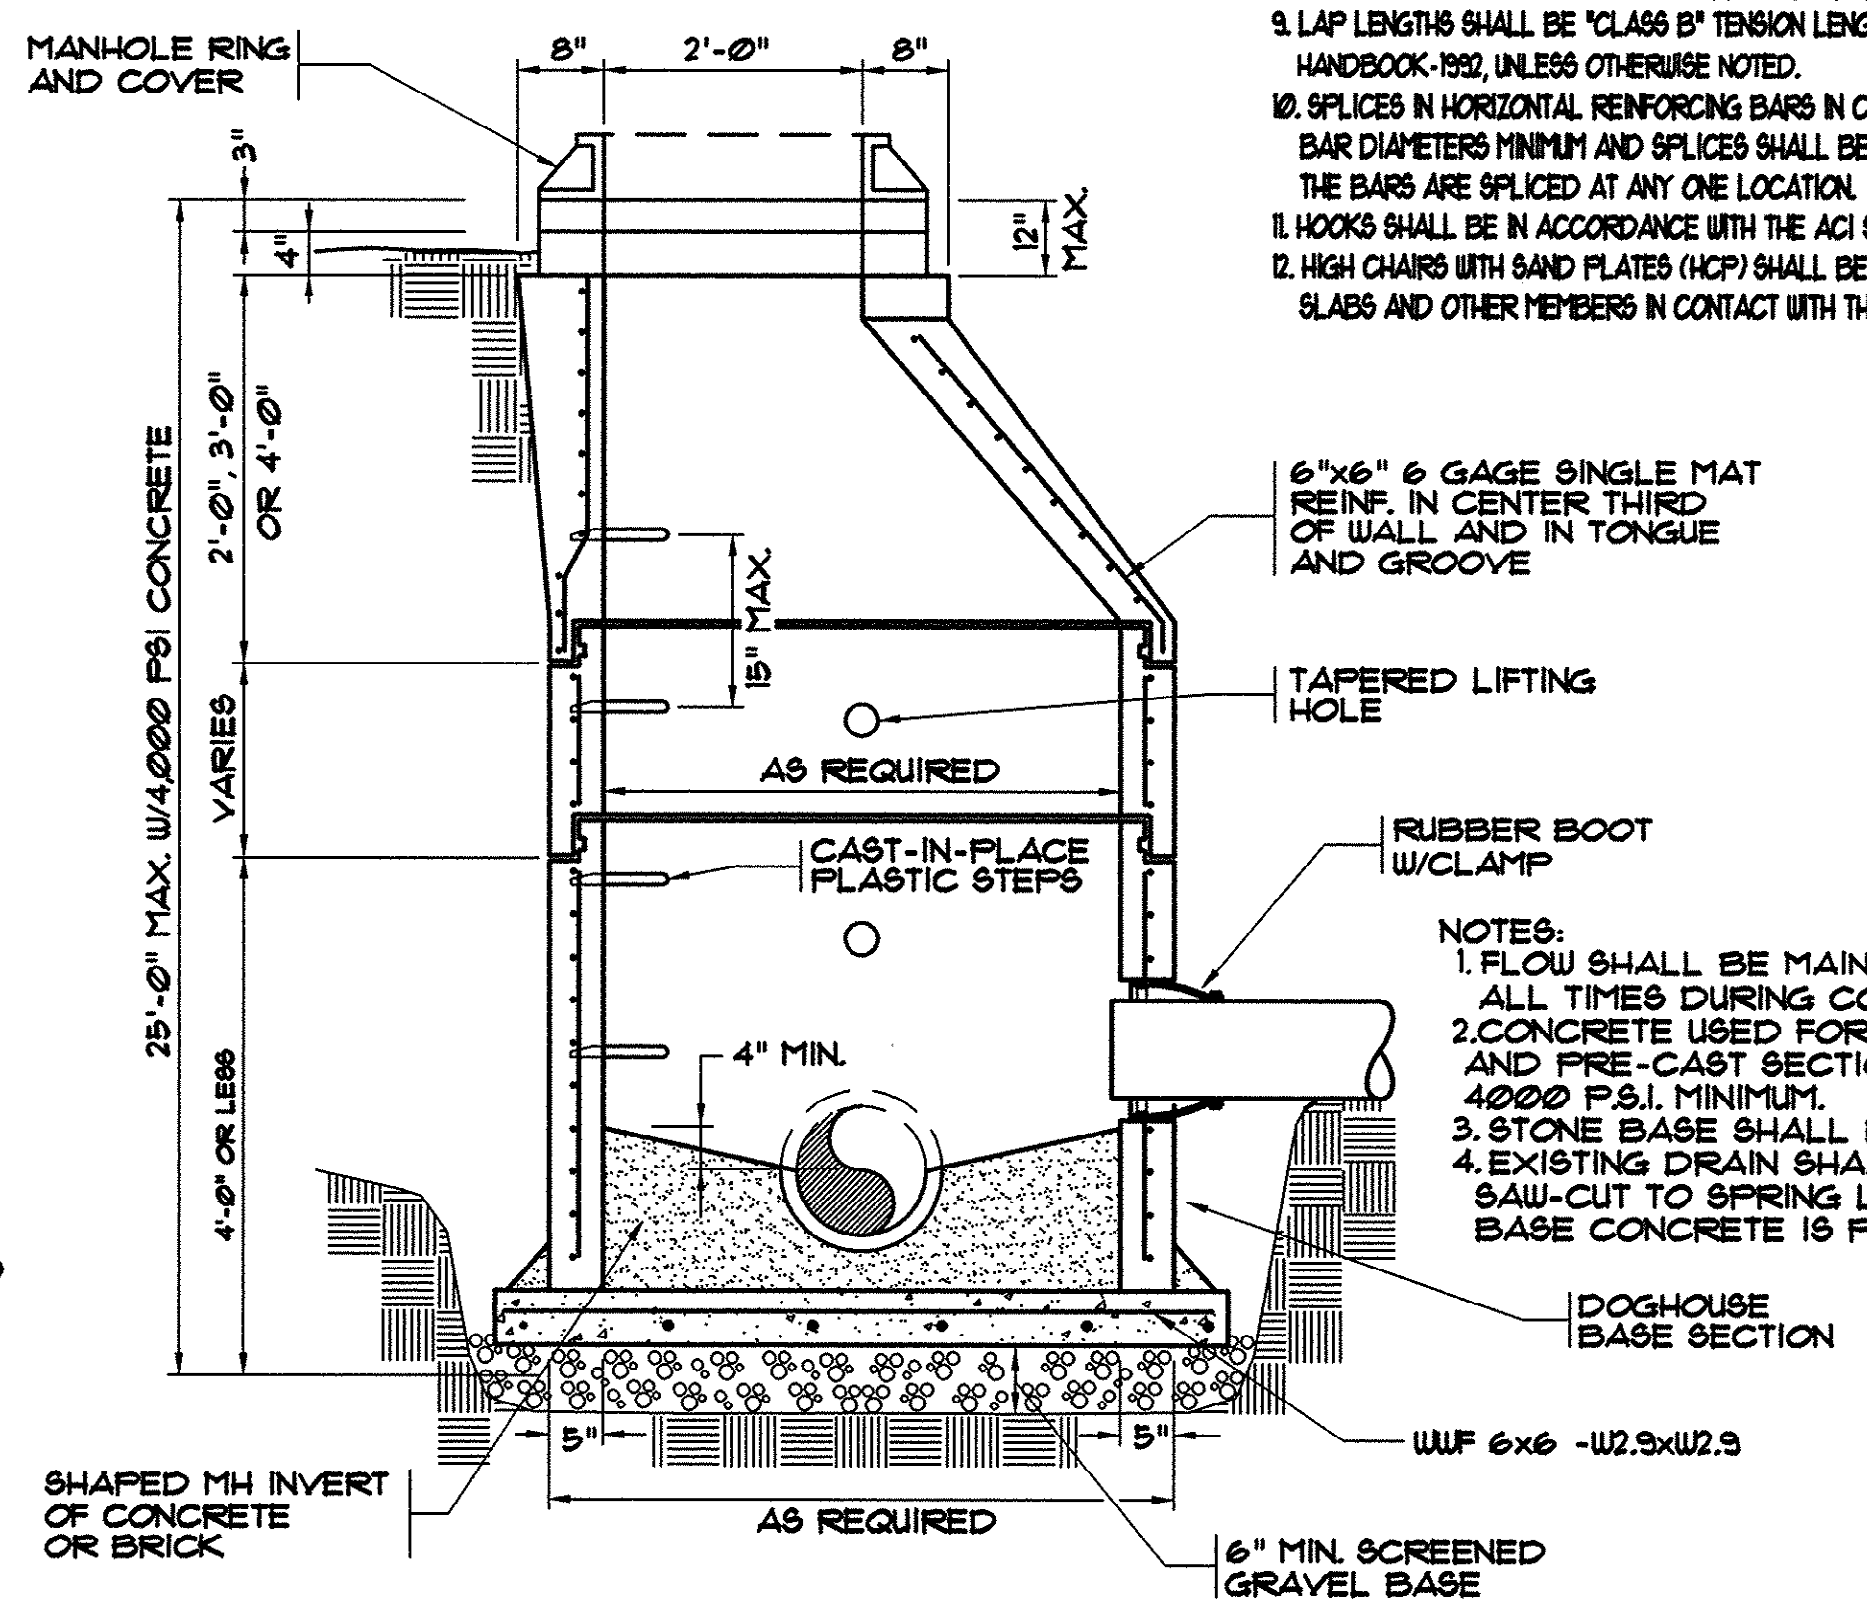


DOGHOUSE MANHOLE DETAIL (BUILT OVER EXISTING LINE)


GENERAL NOTES

- A. FOUNDATIONS.**
 1. MAXIMUM ALLOWABLE NET BEARING PRESSURE = 5000 PSF (FILTER FOUNDATION).
 2. EXCAVATIONS AND FORMS SHALL BE REVIEWED BY THE ENGINEER PRIOR TO PLACING CONCRETE.
 3. AS DIRECTED BY THE ENGINEER, LOOSE AND UNSUITABLE MATERIAL SHALL BE REMOVED FROM THE BOTTOM OF THE FOUNDATIONS AND REPLACED WITH COMPACTED STRUCTURAL FILL OR STONE.
 4. PLACE CONCRETE FOR WALLS AND SLABS IN ALTERNATE SECTIONS AND PROVIDE CONSTRUCTION JOINTS AT LOCATIONS SHOWN ON THE DRAWINGS, OR AT 30 FEET MAXIMUM.
 5. PROVIDE BRACING AGAINST WALLS AS REQUIRED TO PREVENT DAMAGE DURING COMPACTION OF FILL.
 6. ALL FILL BENEATH STRUCTURES AND ALL BACKFILL BEHIND WALLS SHALL BE SELECT MATERIAL FREE FROM ROOTS, TRASH, WOOD SCRAPS, AND OTHER EXTRANEIOUS MATERIALS. PLACE FILL AND BACKFILL IN LIFTS NOT EXCEEDING EIGHT (8) INCHES AND COMPACT EACH LIFT TO 95% DENSITY AT OPTIMUM MOISTURE CONTENT AS MEASURED BY ASTM D698. FILL AND BACKFILL PLACEMENT SHALL BE UNDER THE CONTROL OF AN INDEPENDENT TESTING LABORATORY.
- B. CONCRETE.**
 1. CONCRETE SHALL DEVELOP 4000 PSI MINIMUM COMPRESSIVE STRENGTH AT 28 DAYS.
 2. CONCRETE WORK SHALL CONFORM TO ACI 318-95 INCLUDING SUPPLEMENTS AND ACI 308R-93.
 3. IN ADDITION, CONCRETE WORK SHALL CONFORM TO ACI 301-96, EXCEPT AS OTHERWISE NOTED.
 4. CONCRETE SHALL BE CURED A MINIMUM OF 7 DAYS BY ONE OR MORE METHODS SPECIFIED IN SECTION 536.4 OF ACI 301-96 EXCEPT POLYETHYLENE FILMS SHALL NOT BE USED FOR THE CURING OF CONCRETE WORK.
 5. CONCRETE FORMWORK SHALL CONFORM TO ACI 347R-94 AND ACI MANUAL SP-4(95).
 6. SLABS-ON-GRADE 6 INCHES THICK, UNLESS OTHERWISE NOTED.
 7. PLACE 1/2 INCH EXPANSION JOINT MATERIAL BETWEEN EDGES OF SLABS AND VERTICAL SURFACES UNLESS OTHERWISE NOTED. AT SLABS OVER JOIST THE JOINT MATERIAL SHALL BE THE FULL DEPTH OF THE SLAB AND METAL FORMS.
 8. PROVIDE CONSTRUCTION OR CONTROL JOINTS IN SLABS AT LOCATIONS SHOWN ON DRAWINGS, AT OFFSETS AND CHANGES IN DIRECTION, AND AT 30 FEET MAXIMUM.
 9. CHAMFER EXPOSED EDGES OF CONCRETE 3/4 INCH, UNLESS OTHERWISE NOTED.
- C. WATERSTOPS.**
 1. PROVIDE CONTINUOUS PVC WATERSTOPS WHERE SHOWN ON DRAWINGS, AT EXTERIOR WALL CONSTRUCTION JOINTS AND WHERE DIFFERENTIAL HEIGHTS OF FLUIDS EXIST ON EITHER SIDE OF WALL.
 2. WATERSTOPS SHALL BE MANUFACTURED OF VIRGIN MATERIAL COMPOSED OF AN ELASTOMERIC POLYVINYL CHLORIDE COMPOUND MEETING THE REQUIREMENTS OF CORPS OF ENGINEERS CRD-C572. SUBMIT MANUFACTURER'S LITERATURE SHOWING COMPLIANCE WITH THE ABOVE SPECIFICATION AND SHOWING WATERSTOP SHAPES FOR USE.
 3. WATERSTOPS AT CONSTRUCTION JOINTS SHALL BE 6-INCH MIN. WIDTH "DUMBBELL" TYPE UNLESS OTHERWISE INDICATED ON DRAWINGS.
 4. ALL SPLICING OF WATERSTOPS SHALL BE SHOP FABRICATED EXCEPT THAT BUTT SPLICES MAY BE FIELD FABRICATED.
- D. REINFORCING STEEL.**
 1. BARS SHALL BE ROLLED FROM NEW BILLET-STEEL OF DOMESTIC MANUFACTURE CONFORMING TO "STANDARD SPECIFICATION FOR DEFORMED AND PLAIN BILLET-STEEL BARS FOR CONCRETE REINFORCEMENT," ASTM A 615, GRADE 60, AND SUPPLEMENTARY REQUIREMENT S1.
 2. WELDED WIRE FABRIC SHALL CONFORM TO "STANDARD SPECIFICATION FOR WELDED STEEL WIRE FABRIC FOR CONCRETE REINFORCEMENT," ASTM A 186.
 3. DETAIL AND FABRICATE REINFORCING STEEL IN ACCORDANCE WITH THE AMERICAN CONCRETE INSTITUTE "ACI DETAILING MANUAL - 1988" PUBLICATION SP-66(94).
 4. REINFORCING STEEL IN PLACE SHALL BE REVIEWED BY THE ENGINEER PRIOR TO PLACING CONCRETE.
 5. FABRICATE CONTINUOUS BARS IN GRADE BEAMS TO THE LONGEST PRACTICABLE LENGTHS. SPLICE TOP BARS AT MID-SPAN ONLY AND BOTTOM BARS OVER SUPPORTS ONLY.
 6. PROVIDE BARS AT CORNERS AND INTERSECTIONS OF THE SAME NUMBER AND SIZE AS LONGITUDINAL BARS IN FOOTINGS, GRADE BEAMS, SLABS AND WALLS, OR PROVIDE HOOKS IN HORIZONTAL BARS IN ACCORDANCE WITH "ACI DETAILING MANUAL."
 7. PROVIDE 4-5 BARS (2 EACH FACE) AT EACH SIDE OF OPENINGS IN SLABS AND WALLS AND EXTEND 2'-0" PAST OPENING. IF SUCH AN EXTENSION IS NOT OBTAINABLE, TERMINATE THE BAR WITH A STANDARD HOOK.
 8. FABRICATE CONTINUOUS BARS IN WALLS AND SLABS TO THE LONGEST PRACTICABLE LENGTHS.
 9. LAP LENGTHS SHALL BE "CLASS B" TENSION LENGTHS AS SPECIFIED IN TABLE 5-5(B) IN THE CRSI HANDBOOK-1992, UNLESS OTHERWISE NOTED.
 10. SPLICES IN HORIZONTAL REINFORCING BARS IN CURVED OR CIRCULAR WALLS SHALL BE 40 BAR DIAMETERS MINIMUM AND SPLICES SHALL BE STAGGERED SO THAT NOT MORE THAN ONE HALF THE BARS ARE SPLICED AT ANY ONE LOCATION.
 11. HOOKS SHALL BE IN ACCORDANCE WITH THE ACI SPECIFICATIONS, UNLESS OTHERWISE NOTED.
 12. HIGH CHAIRS WITH SAND PLATES (HCP) SHALL BE USED TO SUPPORT REINFORCING STEEL IN FOOTINGS, SLABS AND OTHER MEMBERS IN CONTACT WITH THE EARTH.

- E. GROUT.**
 1. PROVIDE NON-SHRINK GROUT UNDER ALL COLUMN BASE PLATES AND BEAM BEARING PLATES. NON-SHRINK GROUT SHALL CONFORM TO CORPS OF ENGINEERS SPECIFICATION CRD-C 621-83. GROUT SHALL BE NON-METALLIC AND NON-STAINING.
- F. STRUCTURAL STEEL.**
 1. STEEL SHALL CONFORM TO "STANDARD SPECIFICATION FOR STRUCTURAL STEEL," ASTM A 36.
 2. STEEL WORK SHALL CONFORM TO THE "SPECIFICATION FOR THE DESIGN, FABRICATION AND ERECTION OF STRUCTURAL STEEL FOR BUILDINGS," OF THE AMERICAN INSTITUTE OF STEEL CONSTRUCTION, INC., EFFECTIVE NOVEMBER 1, 1978, INCLUDING ALL SUPPLEMENTS, AND THE "CODE OF STANDARD PRACTICE FOR STEEL BUILDINGS AND BRIDGES," EFFECTIVE SEPTEMBER 1, 1986.
 3. CONNECTION BOLTS SHALL BE 3/4 INCH DIAMETER CONFORMING TO "STANDARD SPECIFICATION FOR HIGH-STRENGTH BOLTS FOR STRUCTURAL STEEL JOINTS," ASTM A 325, UNLESS OTHERWISE NOTED. CONNECTIONS ARE BEARING TYPE WITH THREADS EXCLUDED FROM SHEAR PLANES. INSTALL EACH BOLT WITH A HARDENED WASHER UNDER THE NUT OR HEAD, WHICHEVER IS TURNED FOR TIGHTENING TO THE REQUIRED TENSION.
 4. OVERSIZE HOLES AND SLOTTED HOLES SHALL NOT BE USED FOR BOLTED CONNECTIONS ON THIS PROJECT EXCEPT AT LOCATIONS NOTED ON THE DRAWINGS.
 5. WELDING SHALL BE BY WELDERS AND WELDING OPERATORS WHO HAVE BEEN PREVIOUSLY QUALIFIED BY TESTS AS PRESCRIBED IN THE "STRUCTURAL WELDING CODE," AUG 11-84 OF THE AMERICAN WELDING SOCIETY TO PERFORM THE TYPES OF WELDS REQUIRED ON THIS PROJECT.
 6. THE CONTRACTOR SHALL PROVIDE ADEQUATE TEMPORARY BRACING UNTIL SUCH PROTECTION IS NO LONGER REQUIRED FOR THE SAFE SUPPORT OF THE FRAMING.
 7. ALL CORNERS, BLOCKS, CUTS, CUT-OUTS AND OTHER CUTTING OF STRUCTURAL MEMBERS SHALL HAVE ALL REINSTRANT CORNERS SHAPED, NOTCH FREE, TO A RADIUS OF AT LEAST 1/2 INCH. THE FILLET AND ITS CONTIGUOUS CUTS SHALL MEET WITHOUT OFFSET OR CUTTING PAST THE POINT OF TANGENCY.
 8. ANCHOR BOLT LENGTHS SHOWN ON THE DRAWINGS SHALL INCLUDE HOOKS OF NOT LESS THAN 3 INCHES IN LENGTH. PROVIDE ONE NUT AND ONE WASHER WITH EACH ANCHOR BOLT UNLESS OTHERWISE NOTED.
- G. DESIGN LIVE LOADS.**
 1. STRUCTURAL MEMBERS ARE DESIGNED FOR FULL DEAD LOADS AND THE FOLLOWING LIVE LOADS:
 - A. GRATING LIVE LOAD 100 PSF
 - B. WIND ASCE 1-93 EXPOSURE C, 1-105, V=100 MPH
 - C. LATERAL EARTH LOADS 45 PCF EQUIVALENT FLUID PRESSURE (ABOVE WATER TABLE) 85 PCF EQUIVALENT FLUID PRESSURE (BELOW WATER TABLE) A₀=0.05, A_v=0.05, EXPOSURE GROUP I
 2. SEISMIC
- H. DIMENSIONS.**
 1. DIMENSIONS SHOWN TO EXISTING CONSTRUCTION ARE PLUS OR MINUS REGARDLESS OF WHETHER SHOWN AS SUCH ON THE DRAWINGS OR NOT. THE CONTRACTOR SHALL VERIFY IN THE FIELD ALL DIMENSIONS TO EXISTING CONSTRUCTION. THE CONTRACTOR SHALL ADVISE THE ENGINEER OF ANY DIFFERENCES IN DIMENSIONS PRIOR TO COMMENCING CONSTRUCTION.
- I. ABBREVIATIONS.**
 1. THE FOLLOWING LIST OF ABBREVIATIONS IS NOT INTENDED TO REPRESENT ALL THOSE USED ON THESE DRAWINGS, BUT TO SUPPLEMENT THE MORE COMMON ABBREVIATIONS USED:
 - 1. TYP. - TYPICAL
 - 2. SIM. - SIMILAR
 - 3. UNL. - UNLESS OTHERWISE NOTED
 - 4. CLR. - CLEAR, CLEARANCE
 - 5. T.CJ. - TYPICAL CONTROL JOINT, TYPICAL CONSTRUCTION JOINT
 - 6. EJ. - EXPANSION JOINT
- K. CONSTRUCTION SAFETY.**
 1. THESE STRUCTURAL DRAWINGS DO NOT CONTAIN NECESSARY COMPONENTS FOR SAFETY DURING CONSTRUCTION.

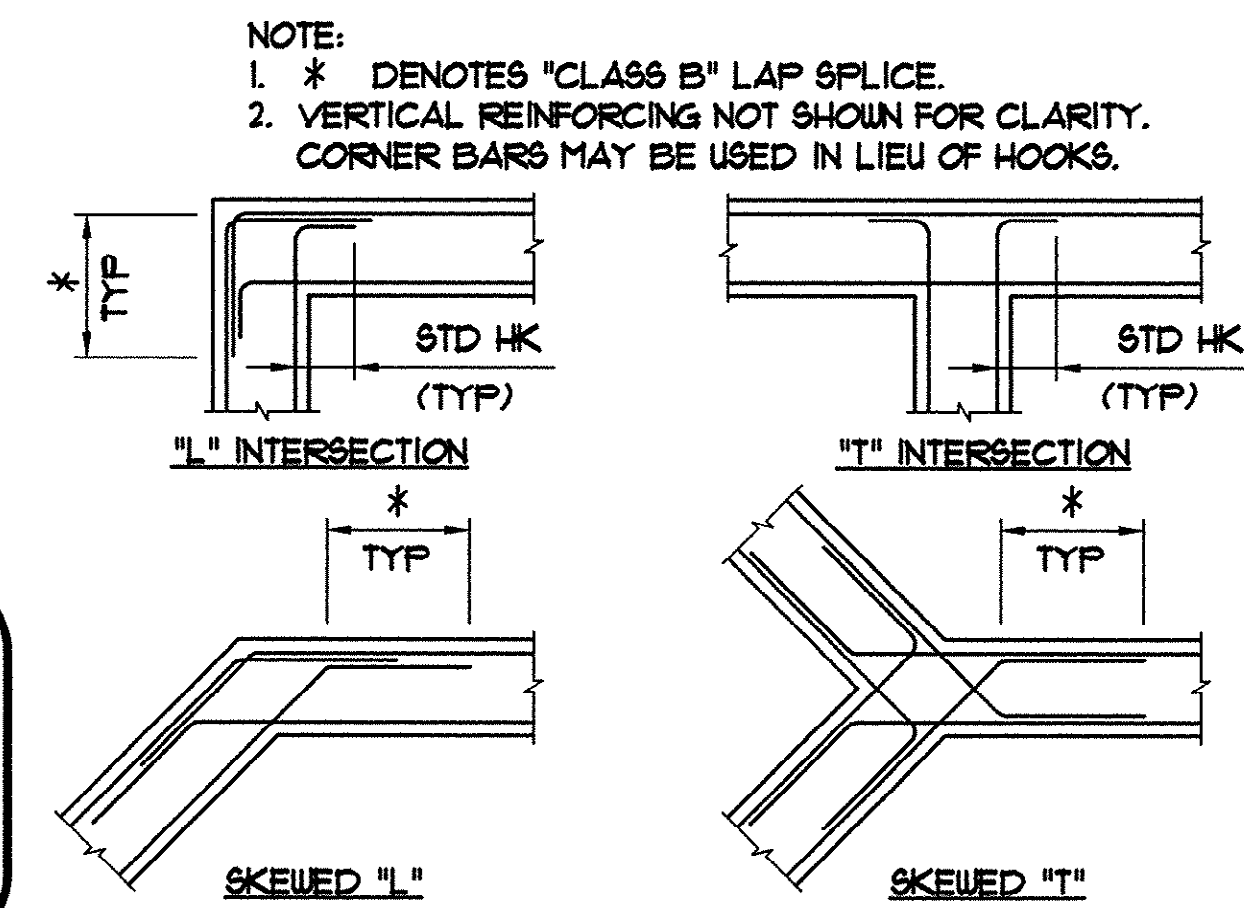

TYPICAL WALL INTERSECTION REINFORCING DETAIL

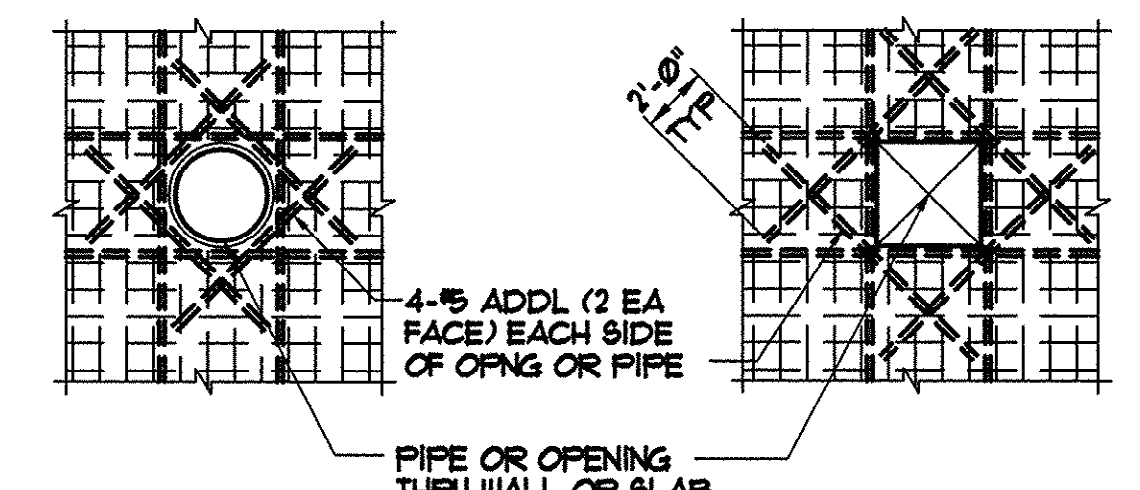

- NOTE:
1. PROVIDE ADDITIONAL HORIZONTAL AND VERTICAL BARS EQUAL TO THE NUMBER OF BARS TERMINATED AT OPENING, HALF EACH SIDE.

TYPICAL ADDITIONAL REINFORCING AT PIPE OR OPENING

DATE	8/02/01	BY	CAR
DESCRIPTION	AS-BUILT	SYN	
REVISIONS			

HOBBS, UPCHURCH & ASSOCIATES, P.A.
CONSULTING ENGINEERS
MYRTLE BEACH, SOUTH CAROLINA 29577


**STRUCTURAL DETAILS/
GENERAL NOTES**

**TIP-TOP TREE FARM
EFFLUENT LAND
APPLICATION PROJECT**
GRAND STRAND WATER
AND SEWER AUTHORITY

DATE:	MAR. 1999
DESIGNED:	JWM
DRAWN:	DC
CHECKED:	JWM
SCALE:	AS SHOWN
SHEET NO.	G-15
OF	16

45-003-015/53

HOBBES, UPCHURCH & ASSOC. MB J:\G59901\800\820\G-DWG\MB-G-16.dwg EDITED BY: ARABON DATE: 08/29/01 TIME: 11:18 Layout: Model

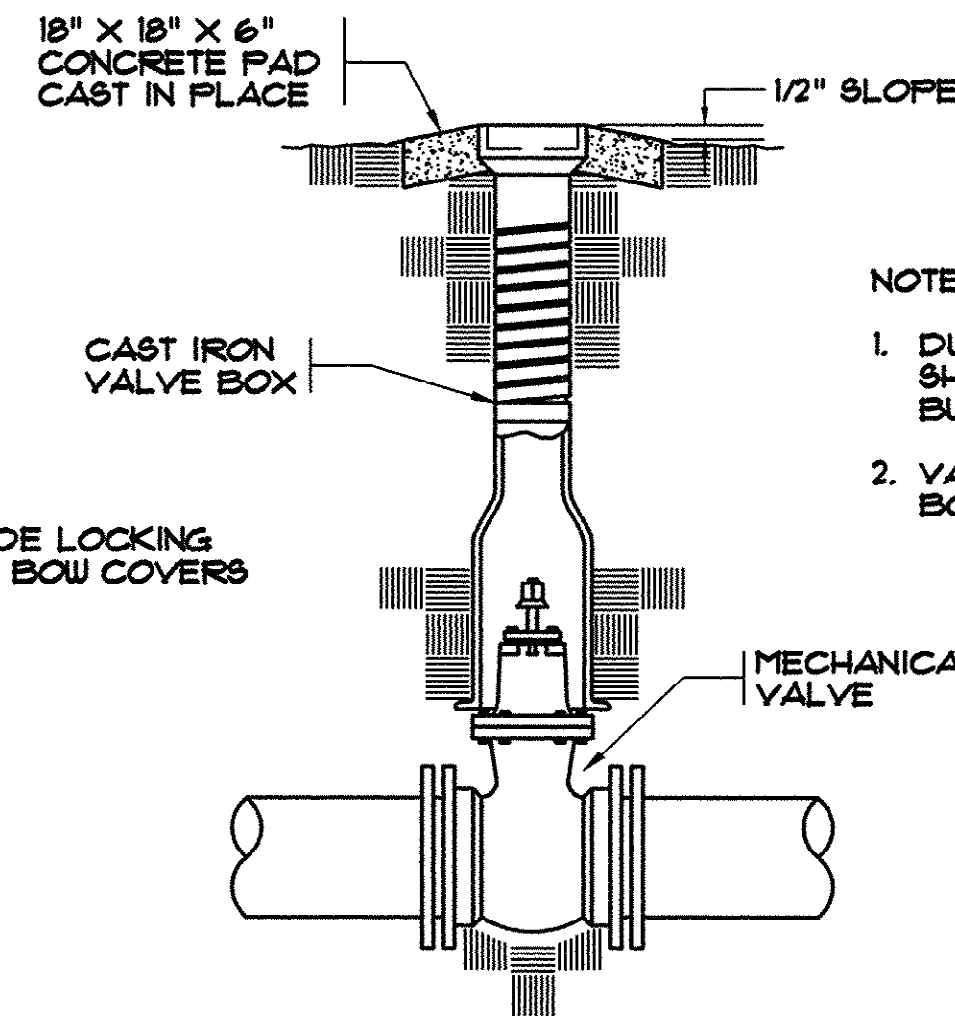


VALVE BOX ASSEMBLY
N.T.S.

NOTES:

1. DUCTILE IRON VALVE BOX EXTENSIONS SHALL BE USED ON THE VALVES WITH BURY DEPTHS OVER 15 FEET
2. VALVE EXTENSION STEMS SHALL BE BOLTED TO VALVE OPERATOR NUT.

NOTE: THRUST BLOCKING DIMENSIONS ARE BASED ON A TEST PRESSURE OF 200 PSI. CONTRACTOR SHALL SUBMIT CALCULATIONS TO ENGINEER FOR REDUCED BLOCKING DIMENSIONS BASED ON ACTUAL OPERATING PRESSURES.

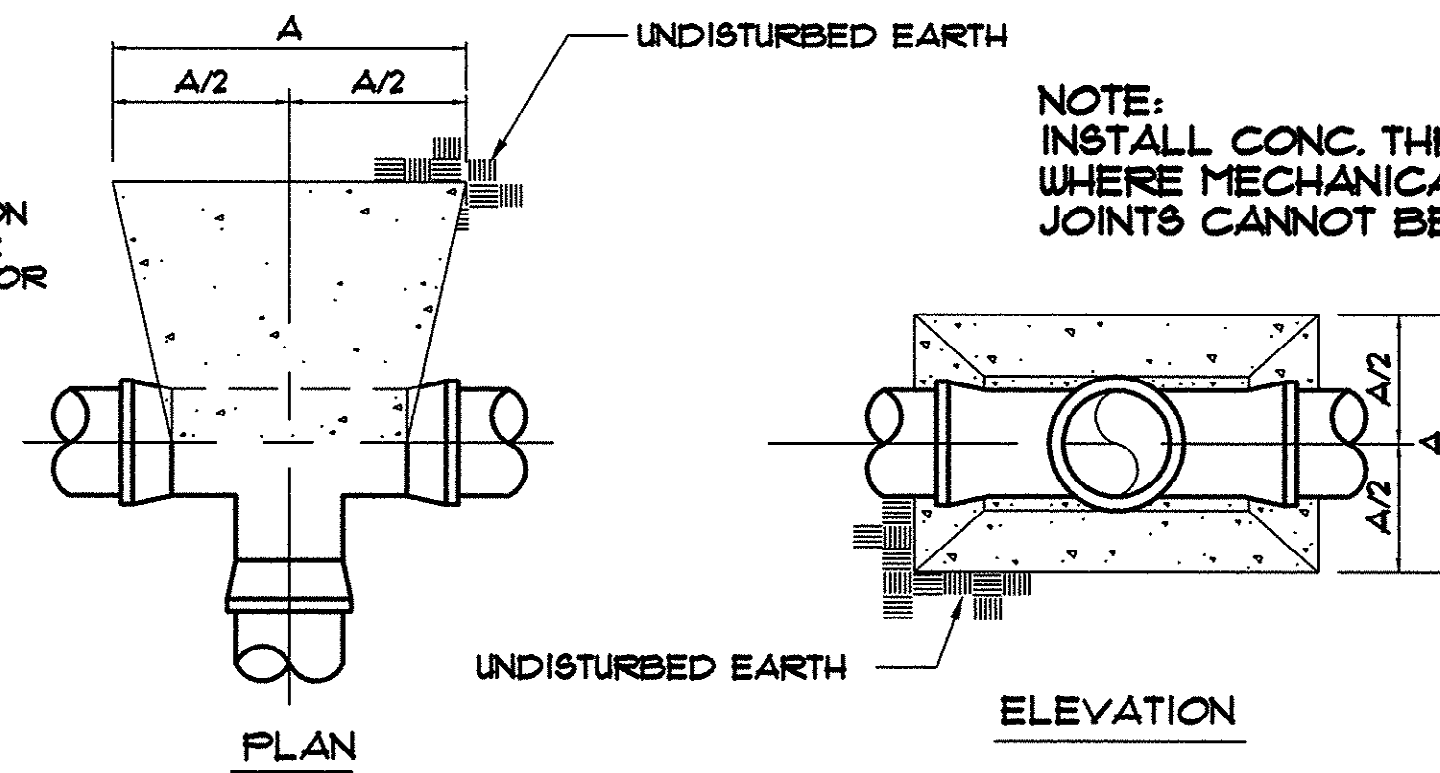


NOTE: THRUST BLOCK SIZE DETERMINED BY SMALLEST DIA. OF TEE

DIM. (IN INCHES)	PIPE SIZE (INCHES)								
	6"	8"	12"	16"	20"	24"	30"	36"	48"
A	5	9	19	35	53	71	120	172	320

THRUST BLOCK DETAIL FOR TEES

N.T.S.

NOTE: INSTALL CONC. THRUST BLOCKING WHERE MECHANICAL RESTRAINED JOINTS CANNOT BE UTILIZED.

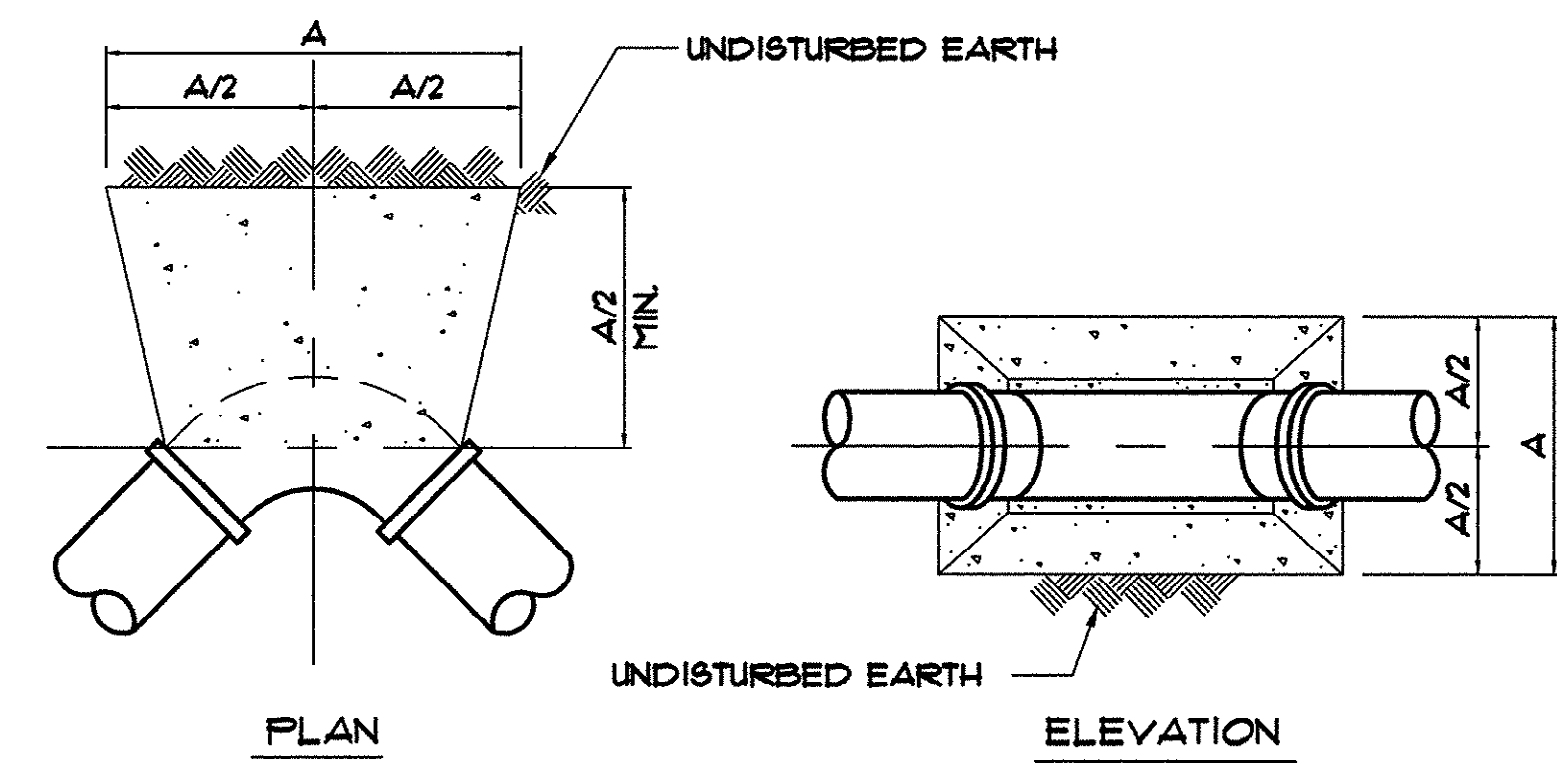


NOTE: THRUST BLOCKS SHALL BE CONSTRUCTED OF 2000 P.S.I. CONCRETE

BEND	PIPE SIZE (NOM. DIA. IN INCHES)								
	6"	8"	12"	16"	20"	24"	30"	36"	48"
90°	5	9	19	35	53	71	120	172	320
45°	3	5	11	19	23	42	65	94	166
22 1/2°	2	3	6	10	15	22	34	48	85
11 1/4°	1	2	3	5	8	11	17	24	43

THRUST BLOCK DETAIL FOR WATER MAIN BENDS

N.T.S.

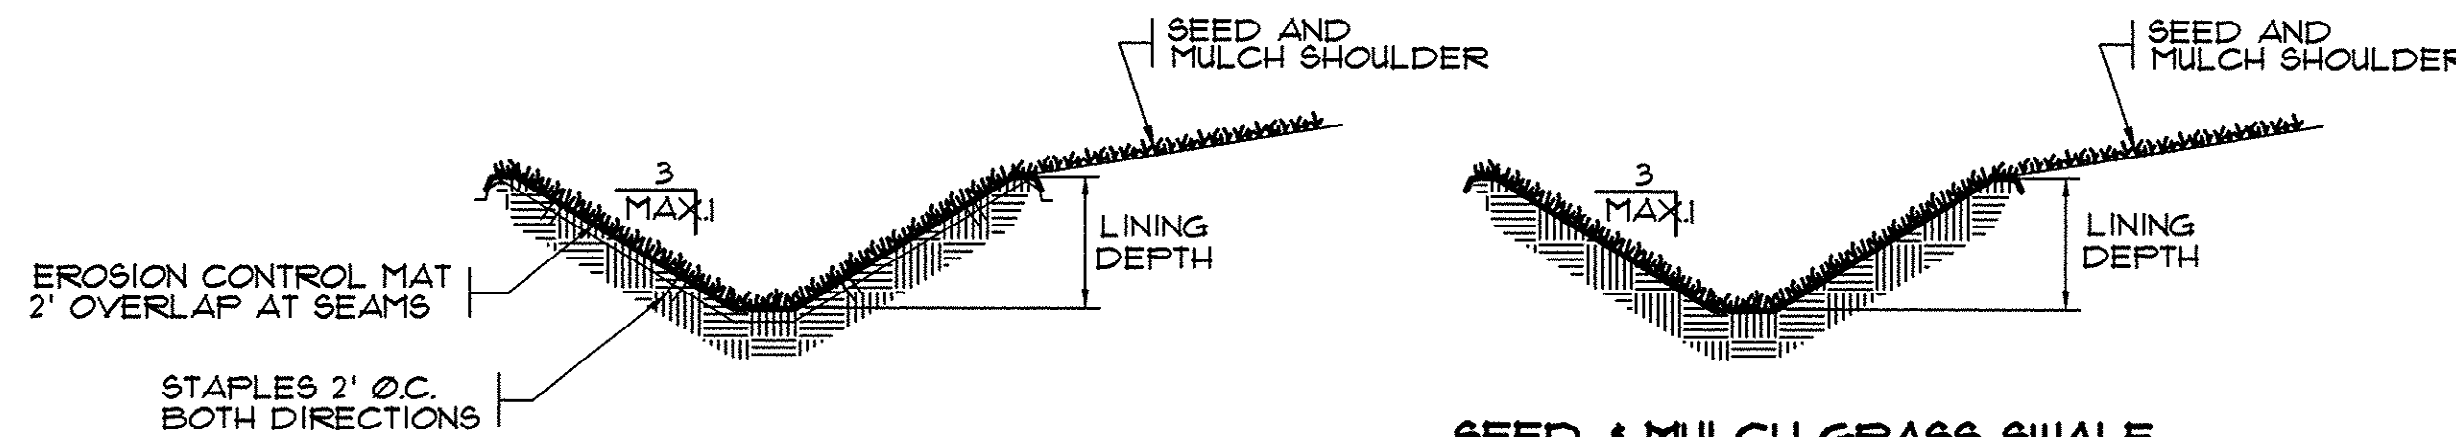


E.C. MAT GRASS SWALE
(SHALL BE USED IN ALL SWALE CROSSINGS)

SWALE/SHOULDER PROTECTION


N.T.S.

NOTE: PREPARE, SEED, AND INSTALL TEMPORARY LINING ON DISTURBED AREA OF DITCH.

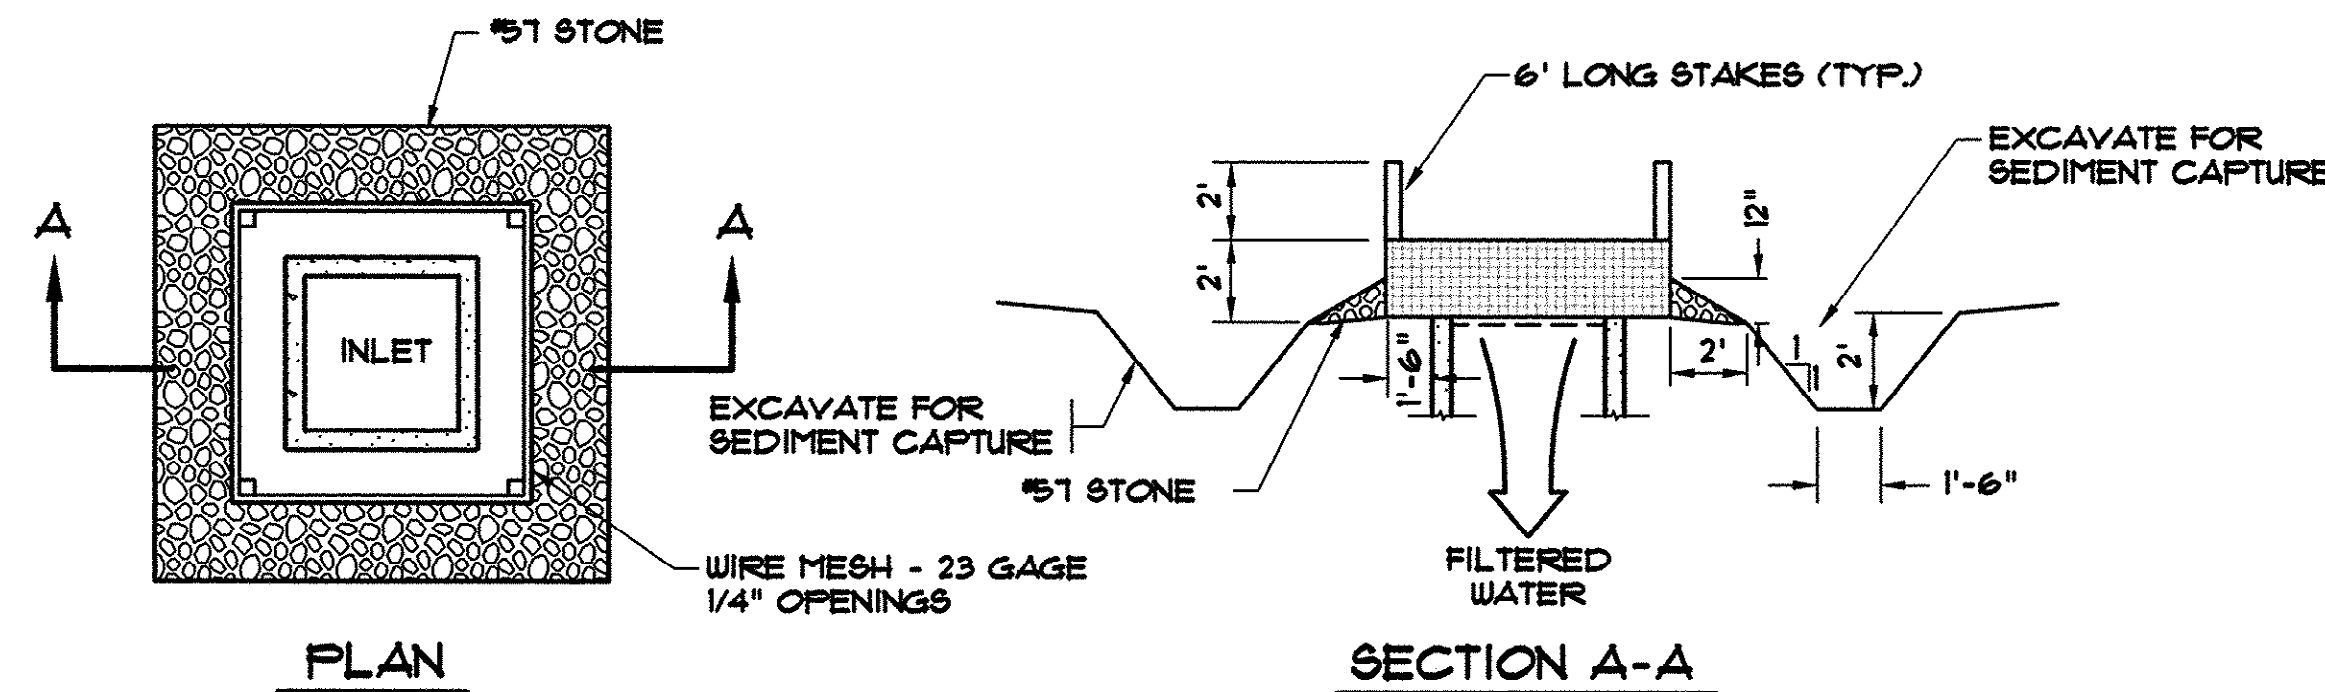


TEMPORARY INLET PROTECTION DETAIL

SCALE: NONE

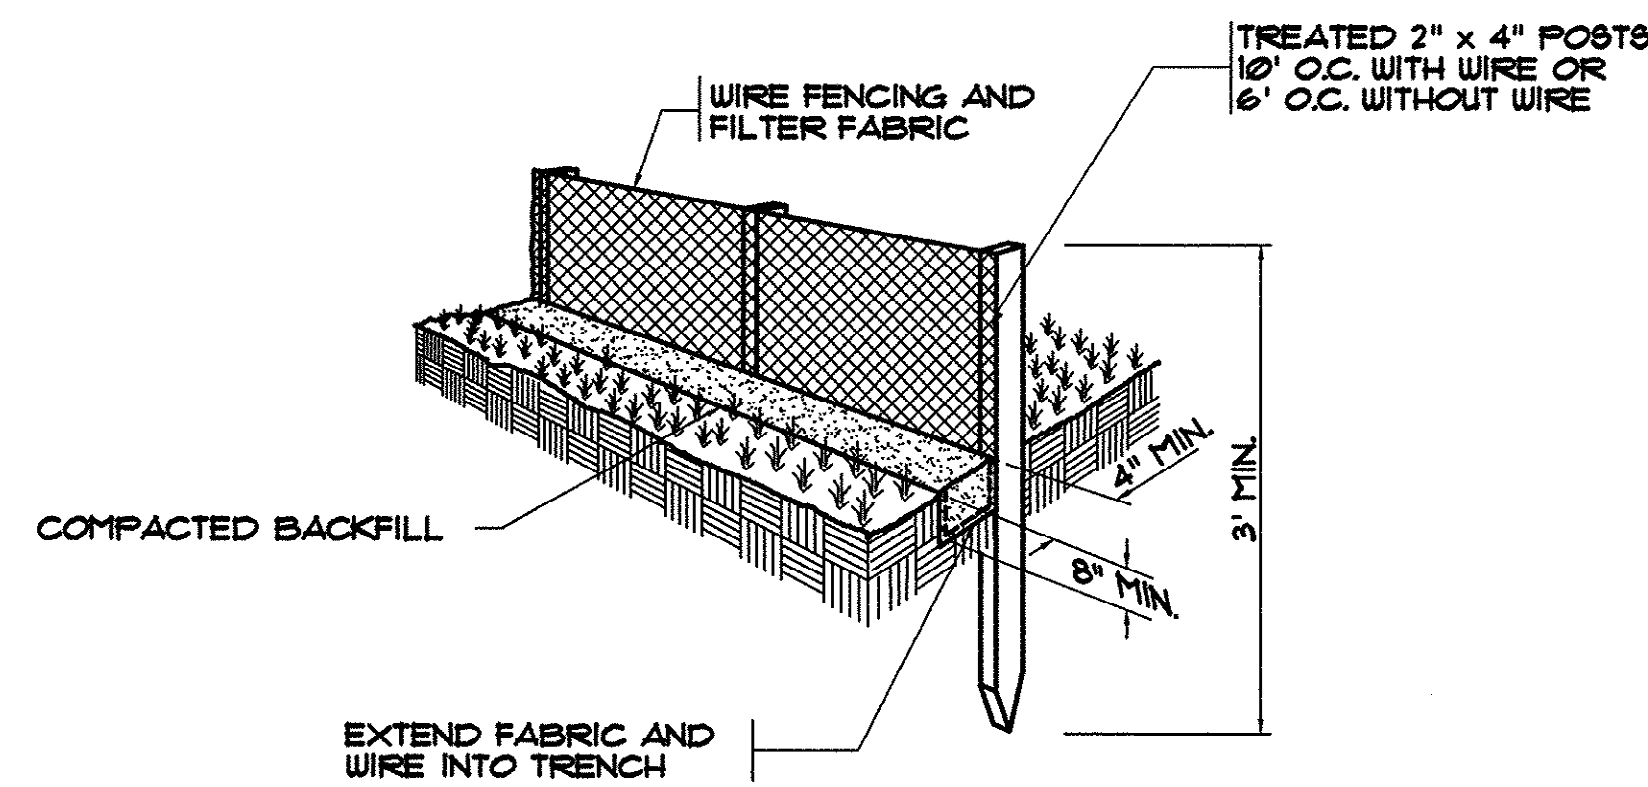

SILT FENCE DETAIL

N.T.S.

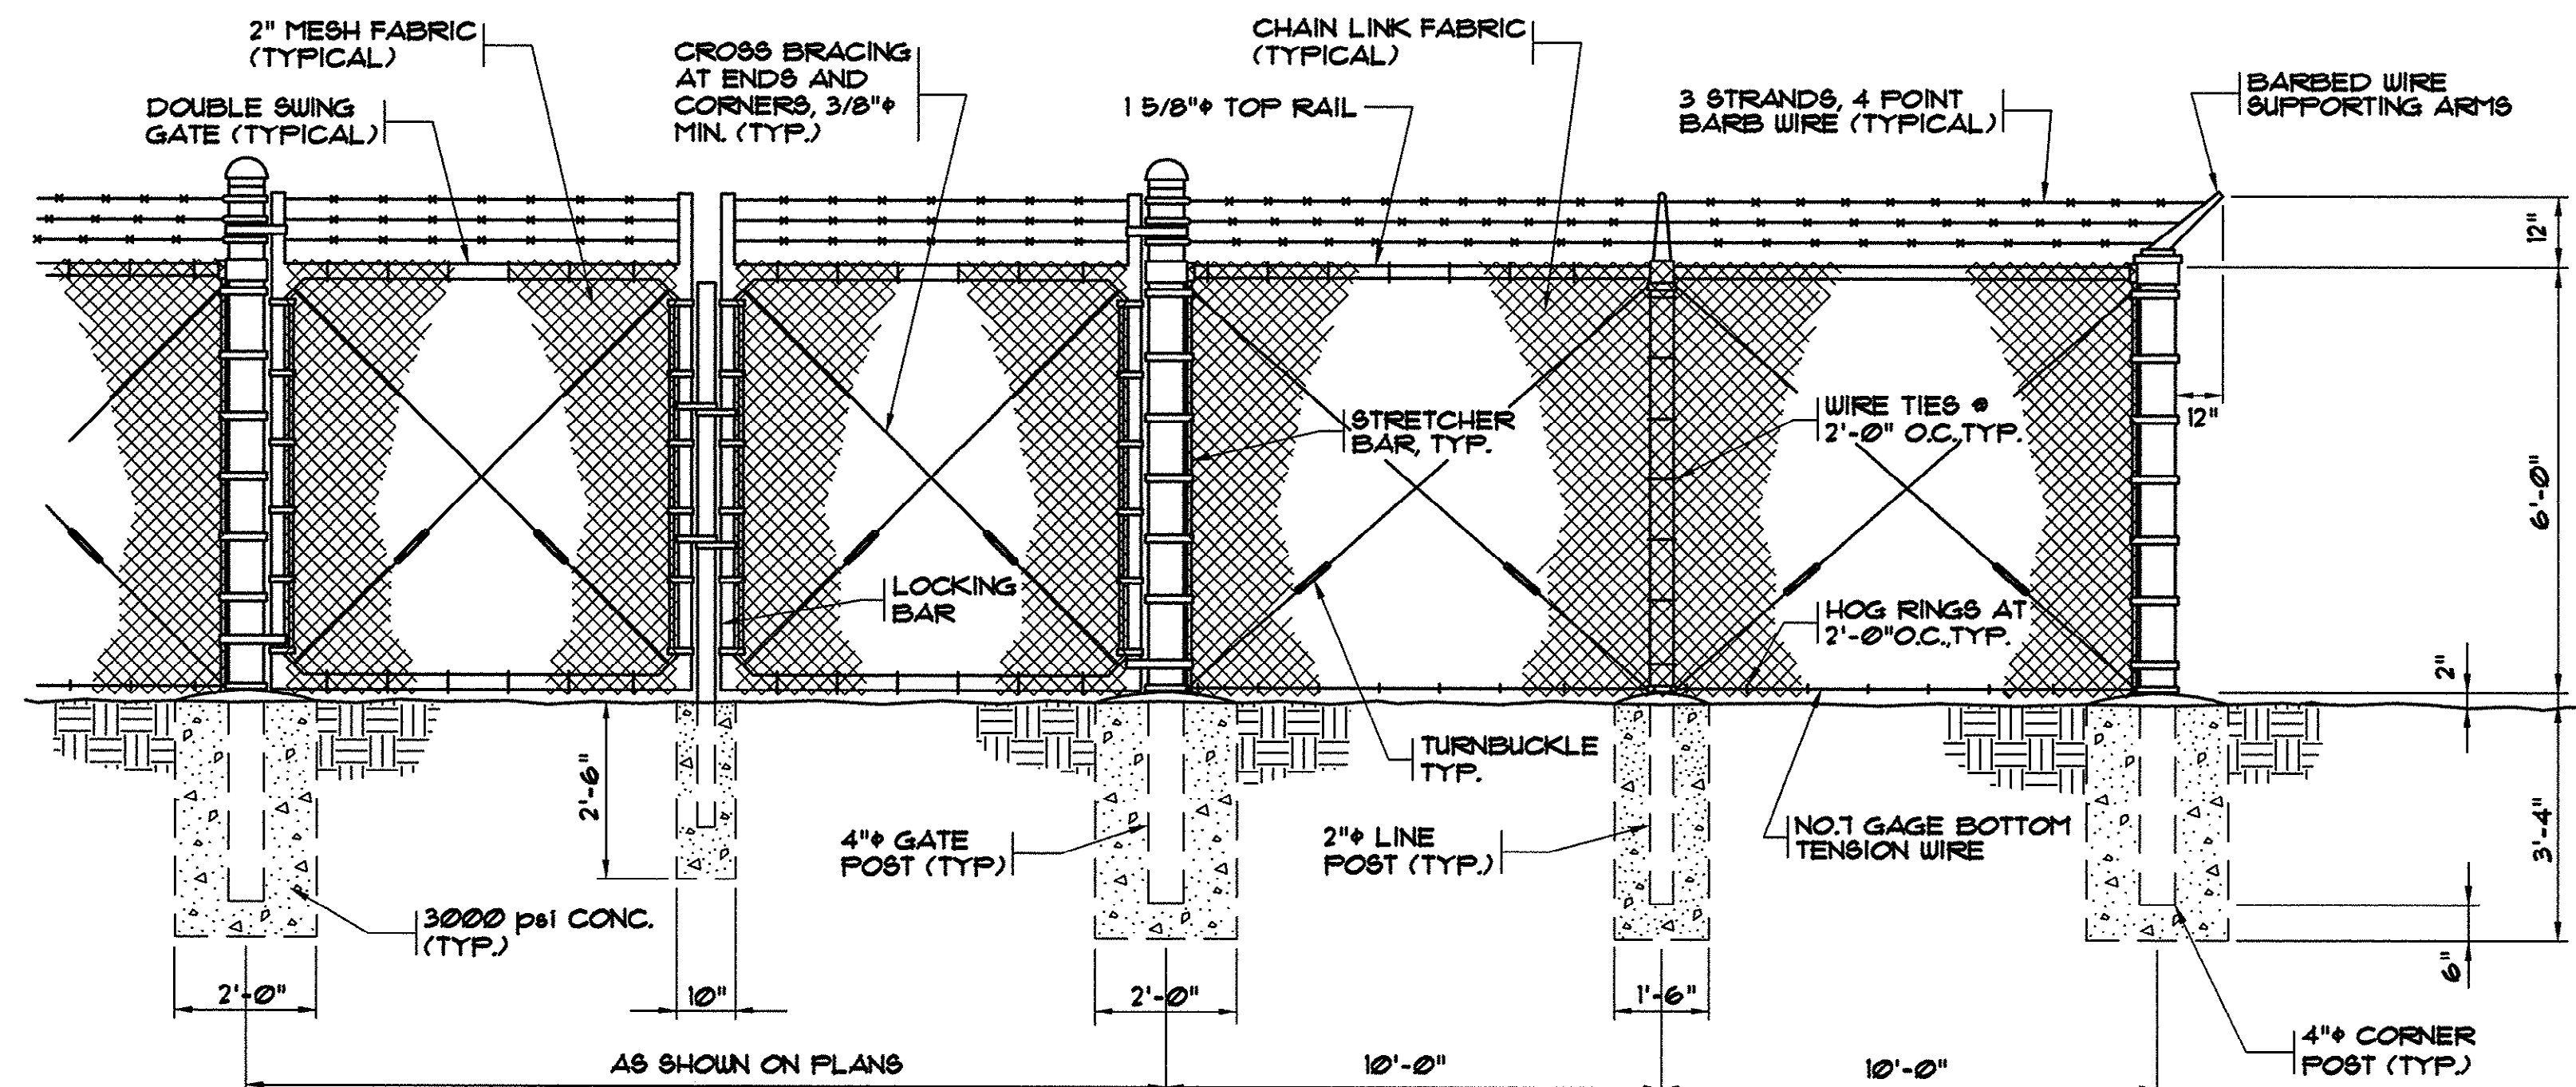

6' CHAIN LINK FENCE AND DOUBLE SWING GATE DETAIL

N.T.S.

THESE DRAWINGS REFLECT
AS-BUILT
CONDITIONS

REVIEWED BY: _____ DATE: _____
INSPECTIONS


REVIEWED BY: _____ DATE: _____
ENGINEERING

GRAND STRAND WATER AND SEWER AUTHORITY

SEEDBED PREPARATION

1. CHISEL COMPACTED AREAS AND SPREAD TOPSOIL 3 INCHES DEEP OVER ADVERSE SOIL CONDITIONS, IF AVAILABLE.
2. RIP THE ENTIRE AREA TO 6" DEPTH.
3. REMOVE ALL LOOSE ROCK, ROOTS, AND OTHER OBSTRUCTIONS LEAVING SURFACE REASONABLY SMOOTH AND UNIFORM.
4. APPLY AGRICULTURAL LIME AND FERTILIZER UNIFORMLY AND MIX WITH SOIL (SEE BELOW *).
5. CONTINUE TILLAGE UNTIL A WELL-PULVERIZED, FIRM, REASONABLY UNIFORM SEEDBED IS PREPARED 4 TO 6 INCHES DEEP.
6. SEED ON A FRESHLY PREPARED SEEDBED AND COVER SEED LIGHTLY WITH SEEDING EQUIPMENT OR CULTIPACK AFTER SEEDING.
7. MULCH IMMEDIATELY AFTER SEEDING.
8. INSPECT ALL SEEDING AREAS AND MAKE NECESSARY REPAIRS OR RESEED WITHIN THE PLANTING SEASON, IF POSSIBLE. IF STAND SHOULD BE OVER 60% DAMAGED, REESTABLISH FOLLOWING ORIGINAL LIME, FERTILIZER, AND SEEDING RATES.
9. CONSULT CONSERVATION INSPECTOR ON MAINTENANCE AND FERTILIZATION AFTER PERMANENT COVER IS ESTABLISHED.

DATE	BY
8/22/01	CAC
SYMBOL	DESCRIPTION
	AS-BUILT

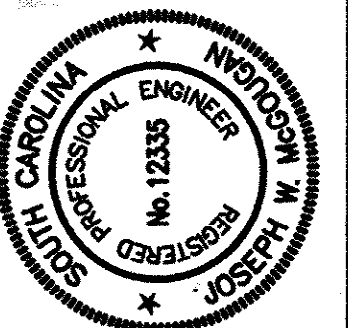

HOBBES, UPCHURCH & ASSOCIATES, P.A.
CONSULTING ENGINEERS
MYRTLE BEACH, SOUTH CAROLINA 29577



MISCELLANEOUS
DETAILS

TIP-TOP TREE FARM
EFFLUENT LAND
APPLICATION PROJECT
GRAND STRAND WATER
AND SEWER AUTHORITY

DATE:	MAR. 1999
DESIGNED:	JWM
DRAWN:	DC
CHECKED:	JWM
SCALE:	AS SHOWN


SHEET NO.

G-16

OF: 16

45-003-016/53

HOBBS, UPCHURCH & ASSOC. MB J:\G9901\800\820\LAYOUT.dwg EDITED BY: ARABON DATE: 08/29/01 TIME: 11:23 XREFS: J:\G9901\800\805\Bucksville_parcels.dwg Layout: Layout1

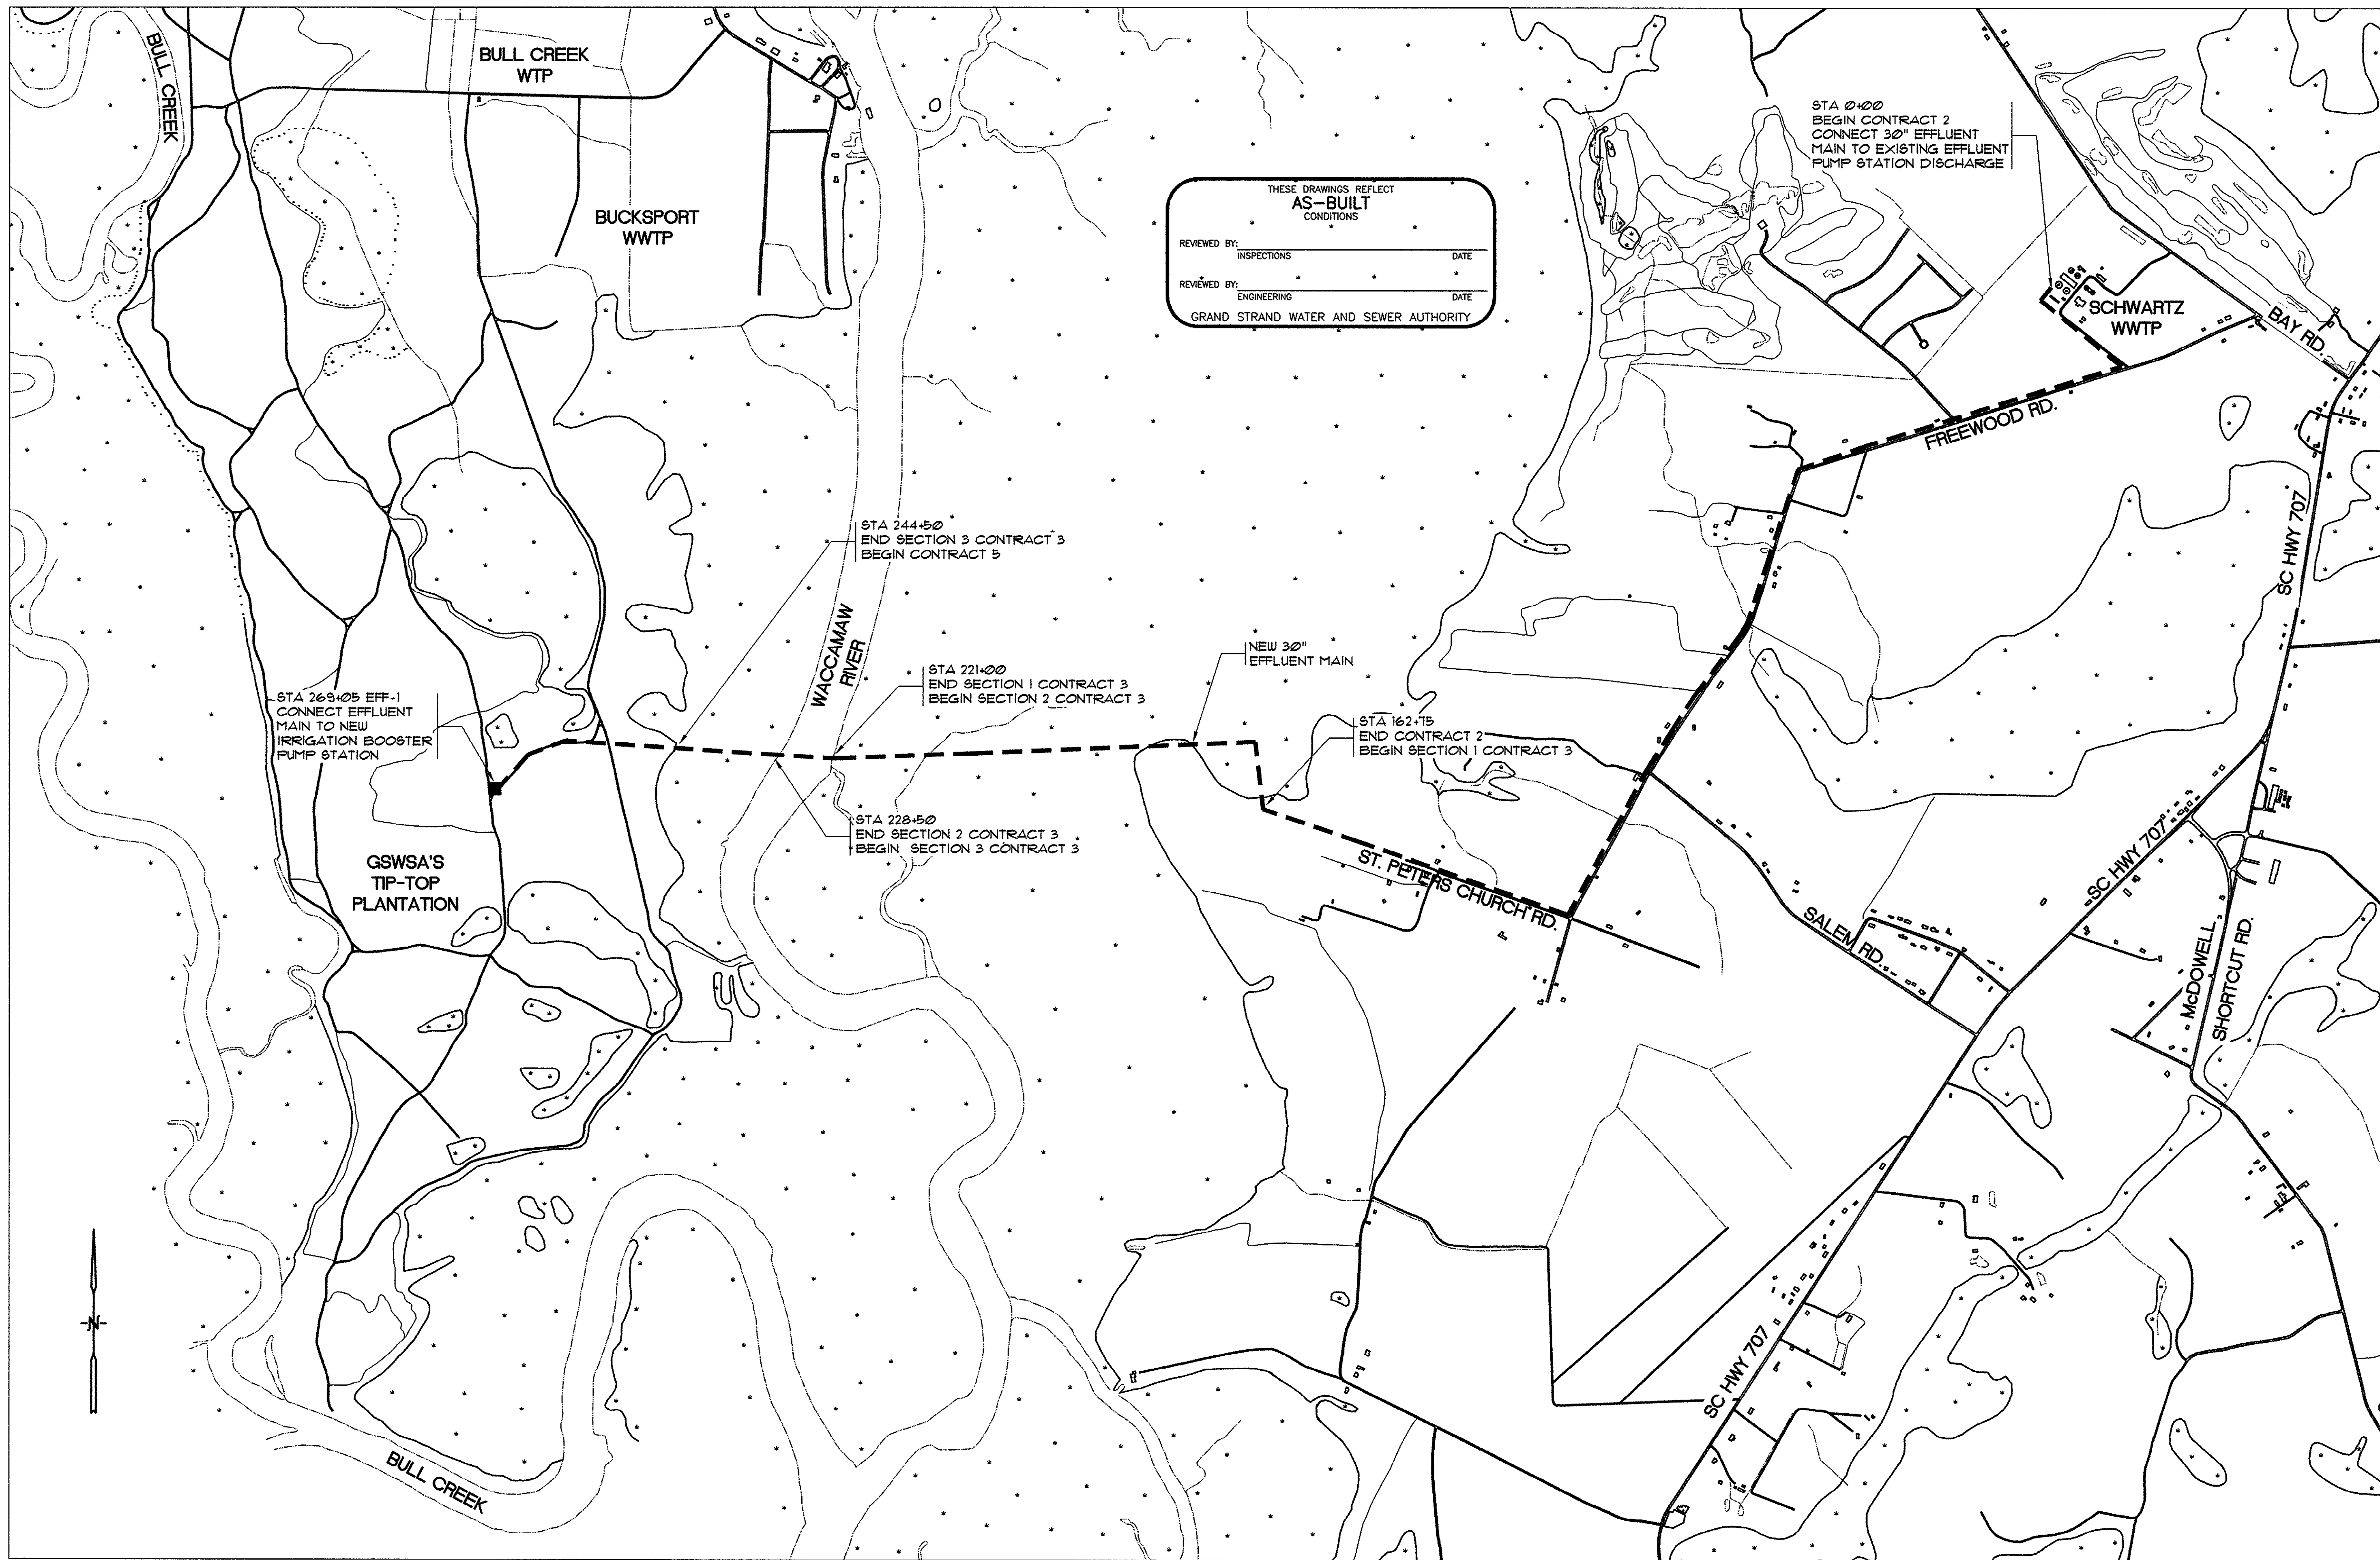

30" EFFLUENT MAIN
LAYOUT MAP
SCALE: 1" = 3000'
3000' 0 3000' 6000'

THESE DRAWINGS REFLECT
AS-BUILT
CONDITIONS

REVIEWED BY: _____ DATE _____
INSPECTIONS

REVIEWED BY: _____ DATE _____
ENGINEERING

GRAND STRAND WATER AND SEWER AUTHORITY

REVISIONS	
SYM.	DESCRIPTION
SECTION 3 CONTRACT 3	AS-BUILT
DATE	BY
8/29/01	KLM
8/27/01	CAR

HOBBS, UPCHURCH & ASSOCIATES, P.A.
CONSULTING ENGINEERS
MYRTLE BEACH, SOUTH CAROLINA 29577

30" EFFLUENT MAIN LAYOUT MAP

TIP-TOP TREE FARM EFFLUENT LAND APPLICATION PROJECT

GRAND STRAND WATER
AND SEWER AUTHORITY


DATE:	MAR. 1999
DESIGNED:	WDL
DRAWN:	KLM
CHECKED:	WDL
SCALE:	AS SHOWN

SHEET NO.
EFF-1

OF 21

45-003-018/53

J:\GSP901\800\820\Contract 2\asbuilt\eff-1-pp01.dwg DATE: 07/30/01 TIME: 06:51 XREFS: J:\GSP901\800\810\points.dwg Layout: Layout1

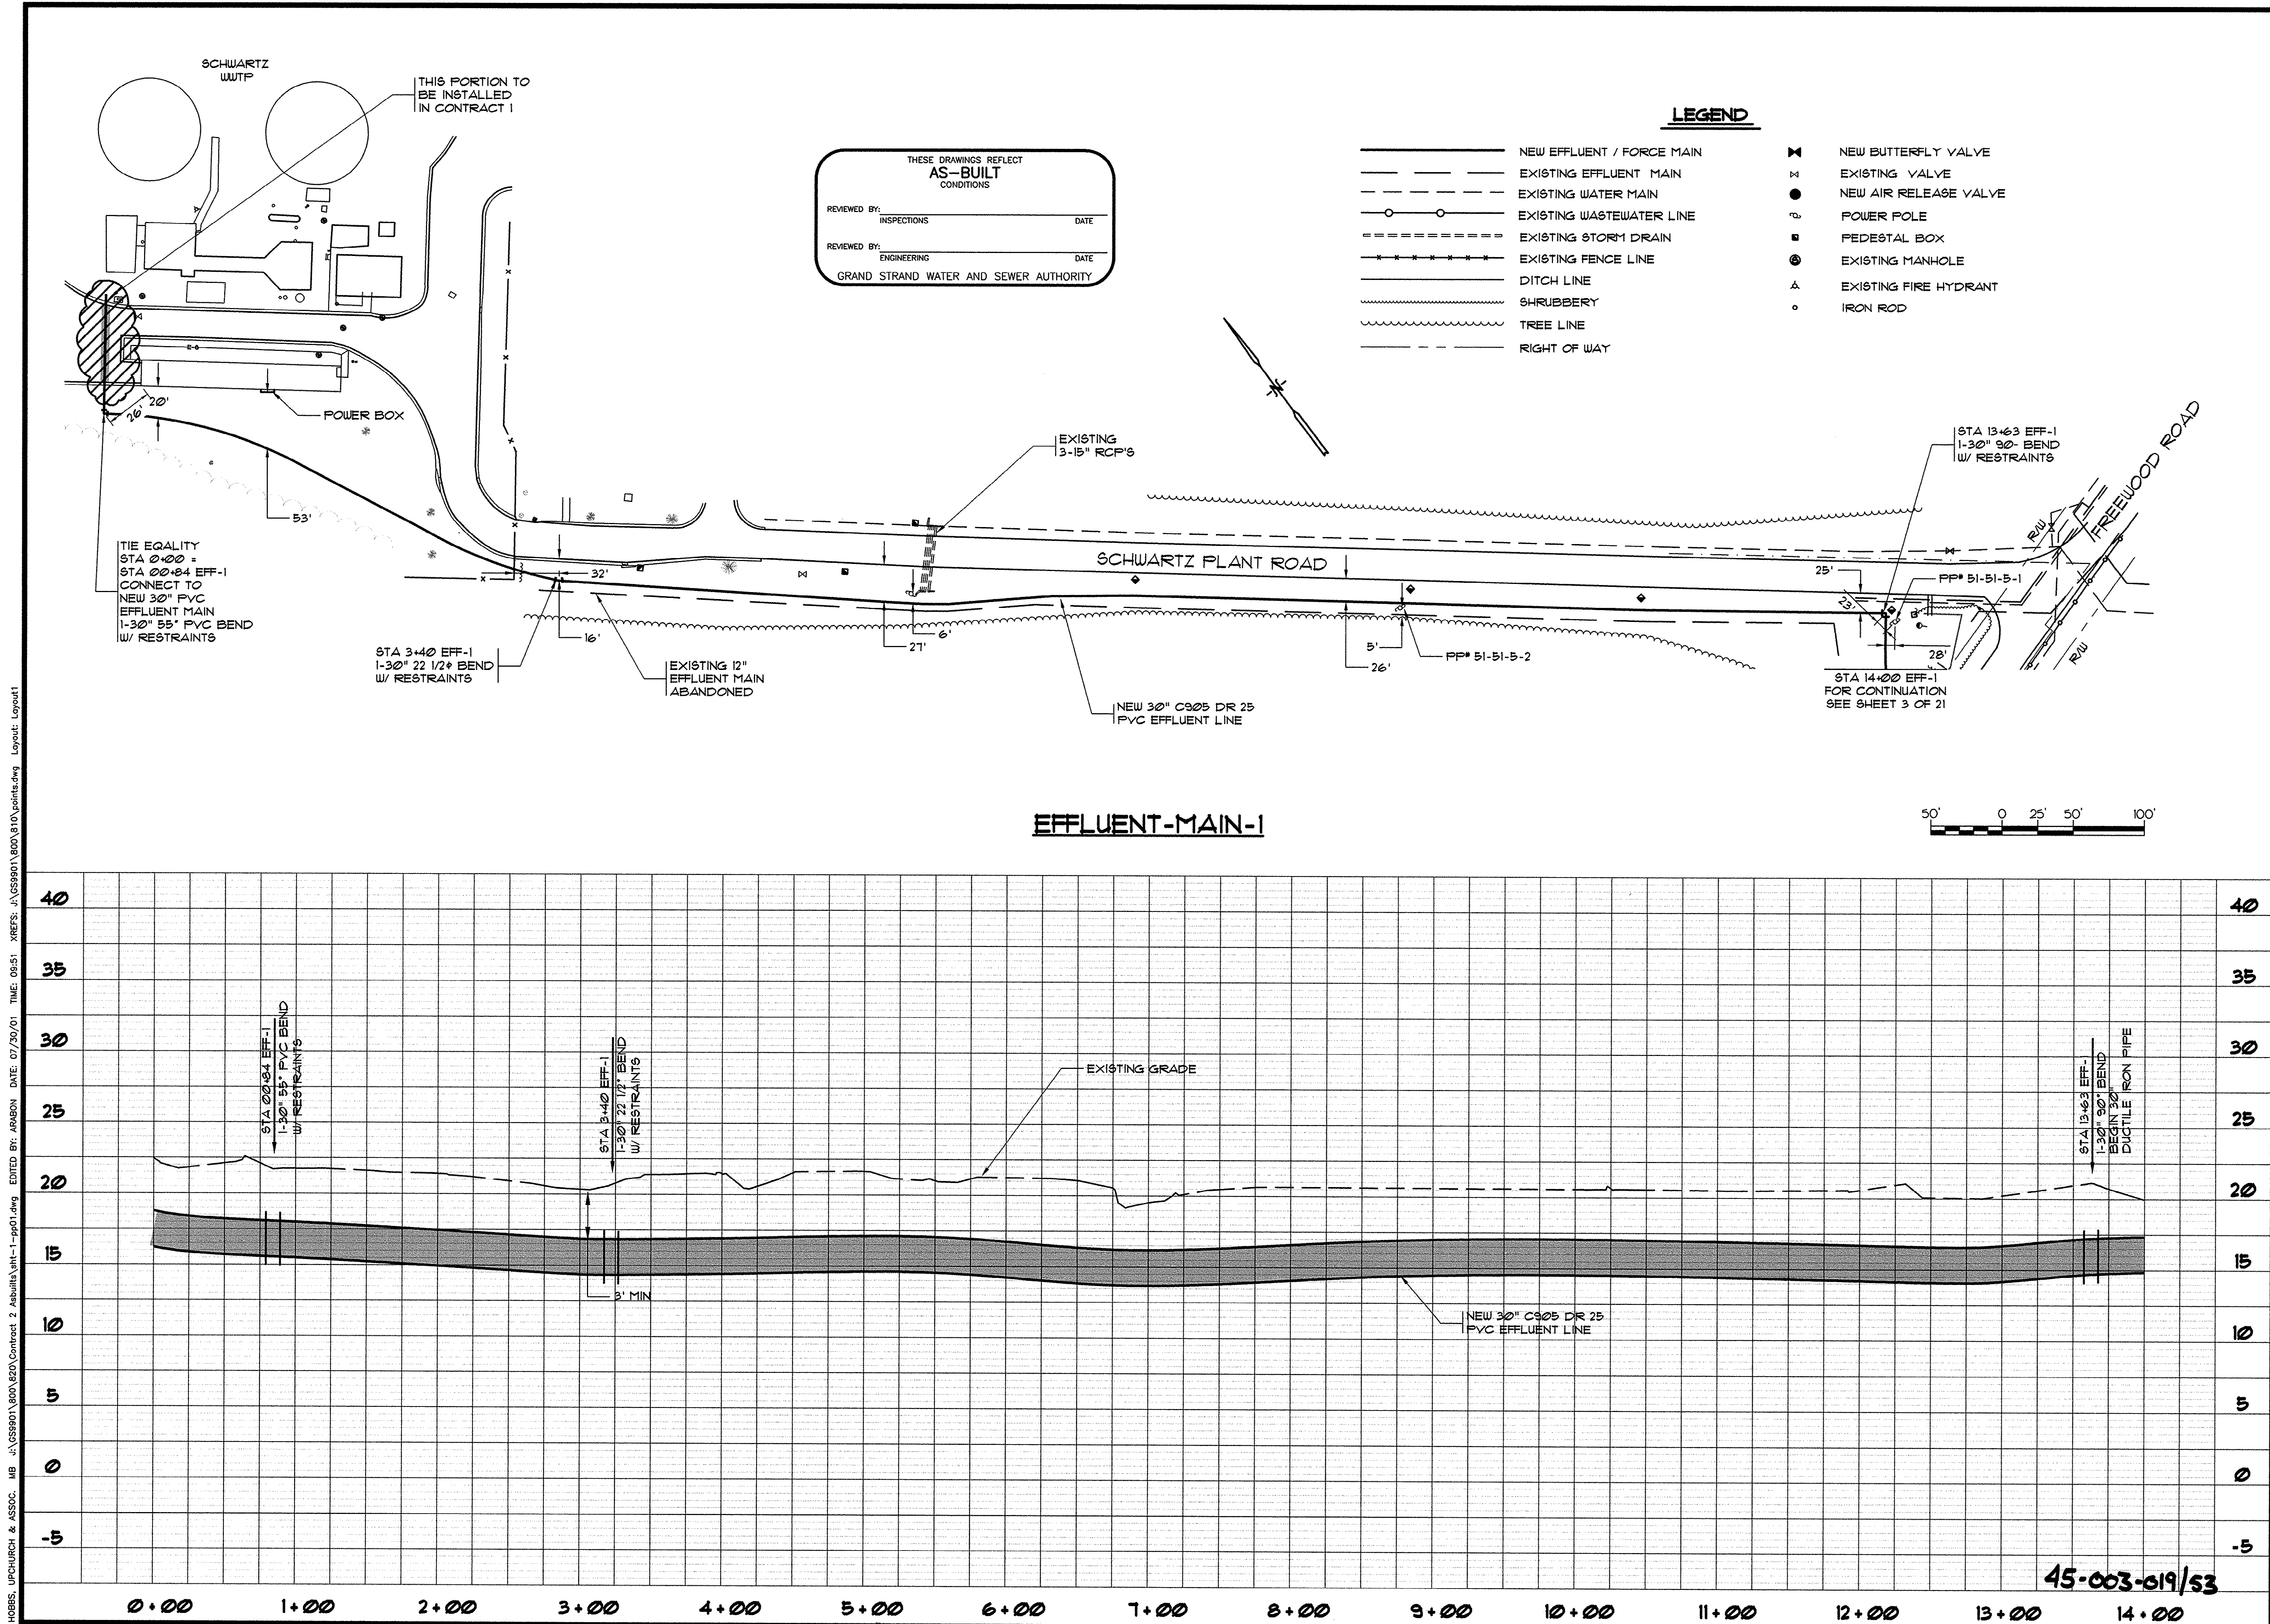

SYN.	DESCRIPTION	DATE	BY
	TIE EQUALITY STA 00+84	9/8/99	KLM
	AS-BUILT	12/5/00	ARM
	AS-BUILT	7/19/01	CAR

REVISIONS

HOBBES, UPCHURCH & ASSOCIATES, P.A.
CONSULTING ENGINEERS
MYRTLE BEACH, SOUTH CAROLINA 29577

PLAN AND PROFILE
EFFLUENT MAIN 1

TIP-TOP TREE FARM
EFFLUENT LAND
APPLICATION PROJECT
GRAND STRAND WATER
AND SEWER AUTHORITY

DATE: MAR. 1999
DESIGNED: WDL
DRAWN: KLM
CHECKED: WDL
SCALE: AS SHOWN
SHEET NO. 21

EFF-2

HOBBES, UPCHURCH & ASSOC. MB J:\GS9801\800\820\Contract 2 Asubilla\plan-1-pp03.dwg EDITED BY: ARAGON DATE: 07/19/01 TIME: 08:22 XREFS: J:\GS9801\800\810\points.dwg Layout: Layout1

THESE DRAWINGS REFLECT
AS-BUILT
CONDITIONS


REVIEWED BY: _____ DATE _____
INSPECTIONS

REVIEWED BY: _____ DATE _____
ENGINEERING


GRAND STRAND WATER AND SEWER AUTHORITY

LEGEND


- NEW EFFLUENT / FORCE MAIN
- EXISTING EFFLUENT MAIN
- EXISTING WATER MAIN
- EXISTING WASTEWATER LINE
- EXISTING STORM DRAIN
- EXISTING FENCE LINE
- DITCH LINE
- SHRUBBERY
- TREE LINE
- RIGHT OF WAY
- NEW BUTTERFLY VALVE
- EXISTING VALVE
- NEW AIR RELEASE VALVE
- POWER POLE
- PEDESTAL BOX
- EXISTING MANHOLE
- EXISTING FIRE HYDRANT
- IRON ROD

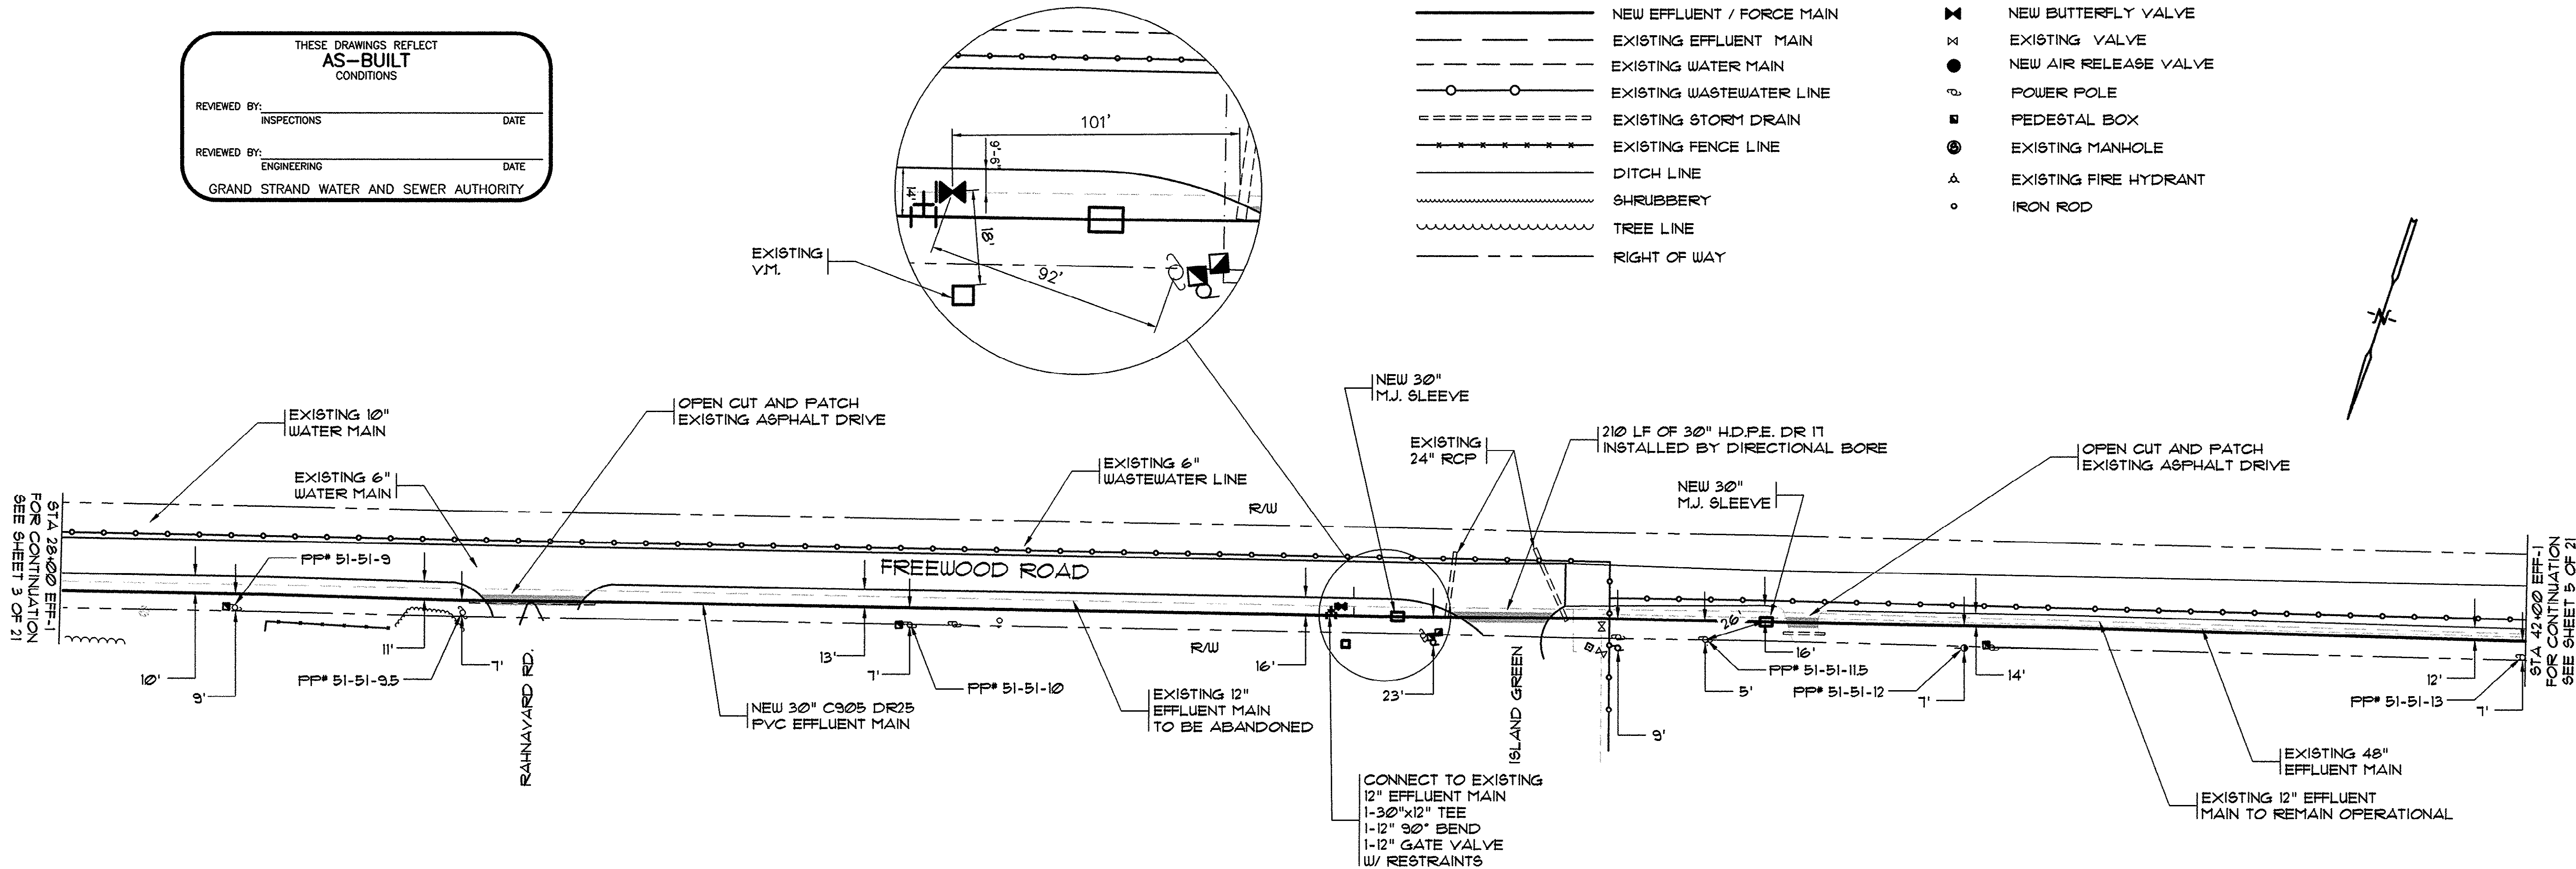

EFFLUENT-MAIN-1

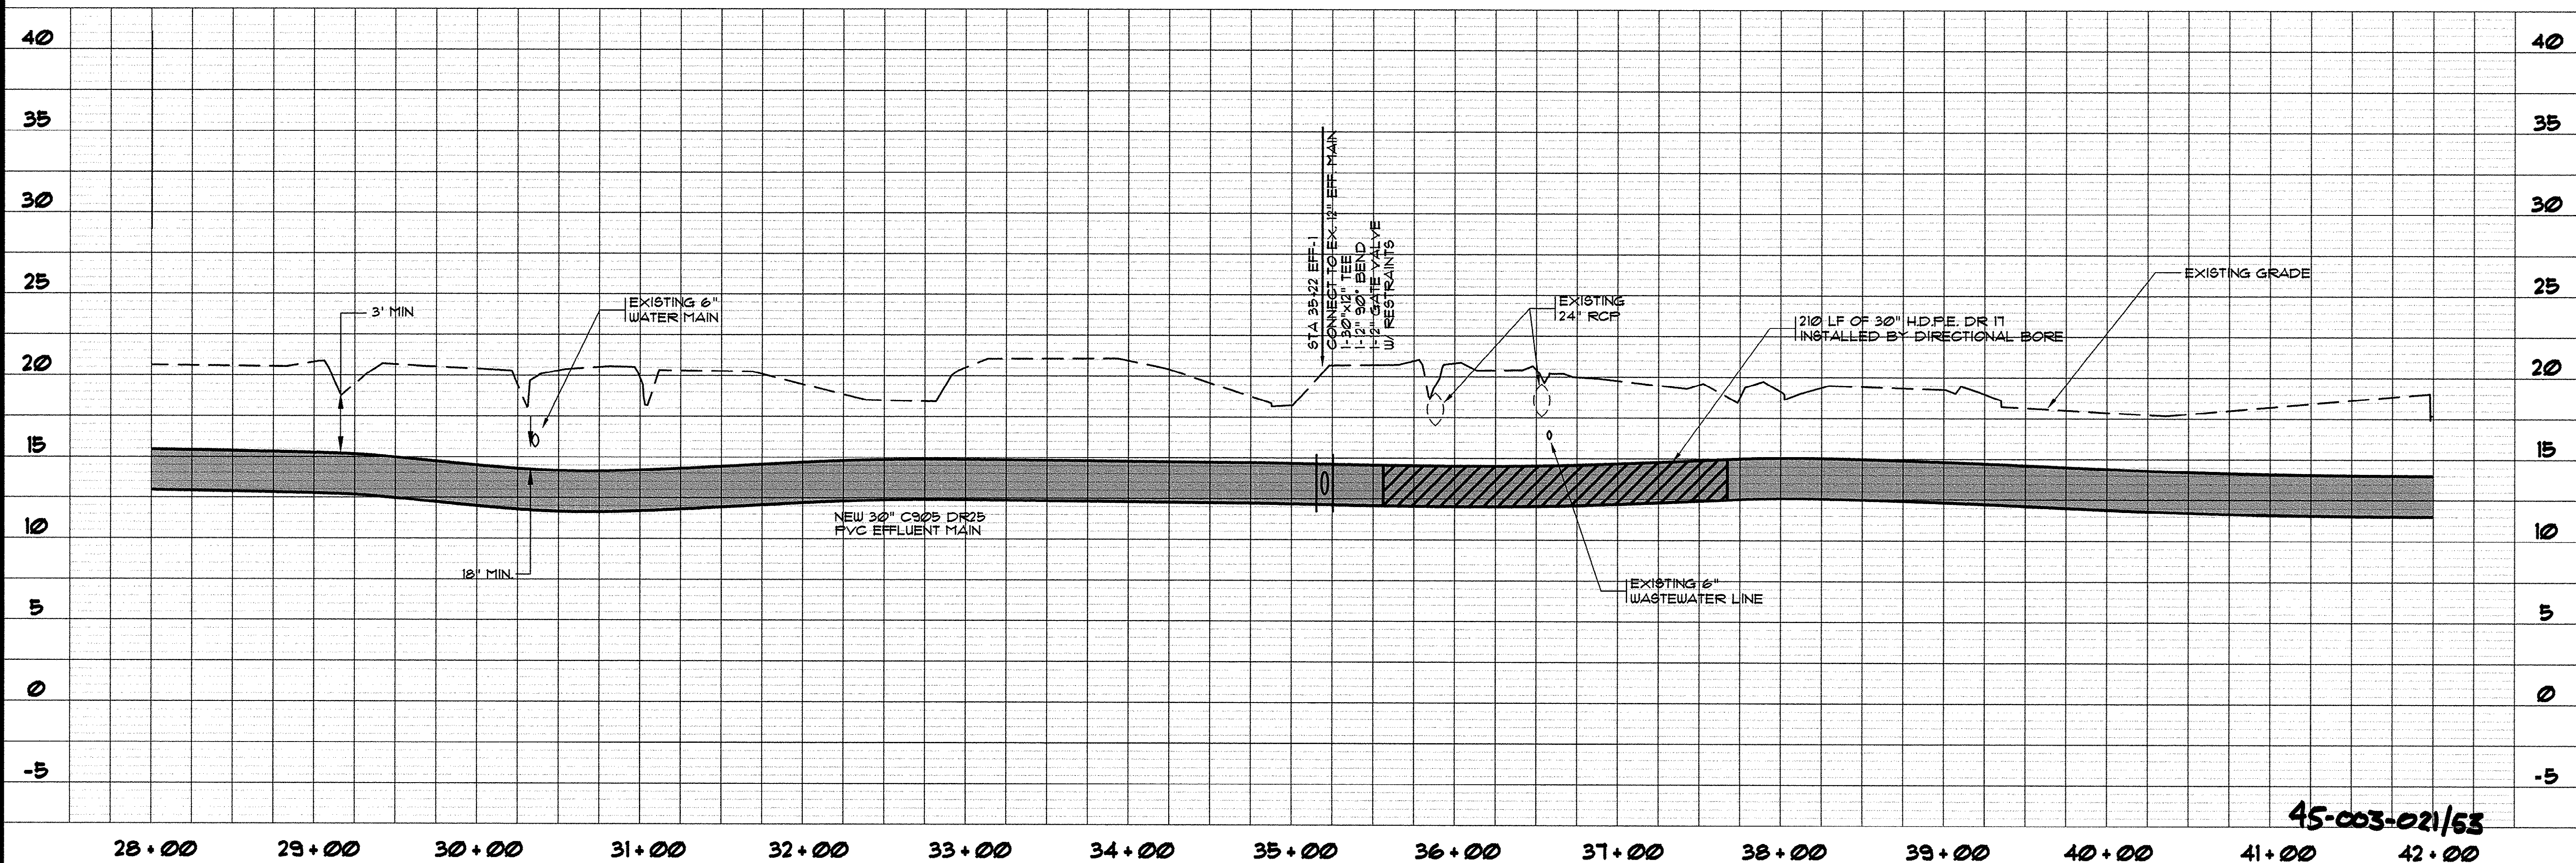

SYMBOL	DESCRIPTION	REVISIONS			
		DATE	BY	DESCRIPTION	
	ADDITIONAL OPEN CUT AND PATCH	9/7/99	KLM		
	AS-BUILT	12/15/00	ARU		
	AS-BUILT	7/19/01	CAR		

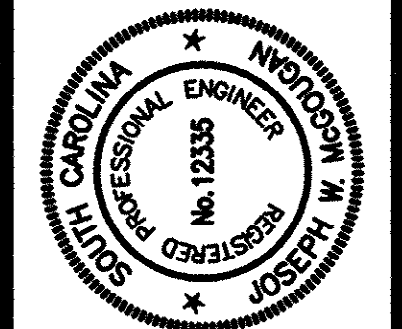

HOBBES, UPCHURCH & ASSOCIATES, P.A.
CONSULTING ENGINEERS
MYRTLE BEACH, SOUTH CAROLINA 29577



PLAN AND PROFILE
EFFLUENT MAIN 1

TIP-TOP TREE FARM
EFFLUENT LAND
APPLICATION PROJECT
GRAND STRAND WATER
AND SEWER AUTHORITY

DATE:	MAR. 1999
DESIGNED:	WDL
DRAWN:	KLM
CHECKED:	WDL
SCALE:	AS SHOWN
SHEET NO.	EFF-4
OF:	21

45-003-021/53

HOBBES, UPCHURCH & ASSOC. MB J:\GS9901\800\815\815-1-05.dwg EDITED BY: ARM DATE: 11/29/00 TIME: 15:07 XREFS: J:\GS9901\800\810\points.dwg Layout: Layout1


THESE DRAWINGS REFLECT
AS-BUILT
CONDITIONS

REVIEWED BY: _____ DATE: _____
INSPECTIONS


REVIEWED BY: _____ DATE: _____
ENGINEERING

GRAND STRAND WATER AND SEWER AUTHORITY

- LEGEND**
- | | | | |
|---------------|---------------------------|---|-----------------------|
| — | NEW EFFLUENT / FORCE MAIN | ✕ | NEW BUTTERFLY VALVE |
| - - - | EXISTING EFFLUENT MAIN | ✕ | EXISTING VALVE |
| - - - | EXISTING WATER MAIN | ● | NEW AIR RELEASE VALVE |
| - ○ - | EXISTING WASTEWATER LINE | ⊗ | POWER POLE |
| ===== | EXISTING STORM DRAIN | ■ | PEDESTAL BOX |
| - * - * - * - | EXISTING FENCE LINE | ⊙ | EXISTING MANHOLE |
| - - - | DITCH LINE | △ | EXISTING FIRE HYDRANT |
| ~~~~~ | SHRUBBERY | ○ | IRON ROD |
| ~~~~~ | TREE LINE | | |
| - - - | RIGHT OF WAY | | |

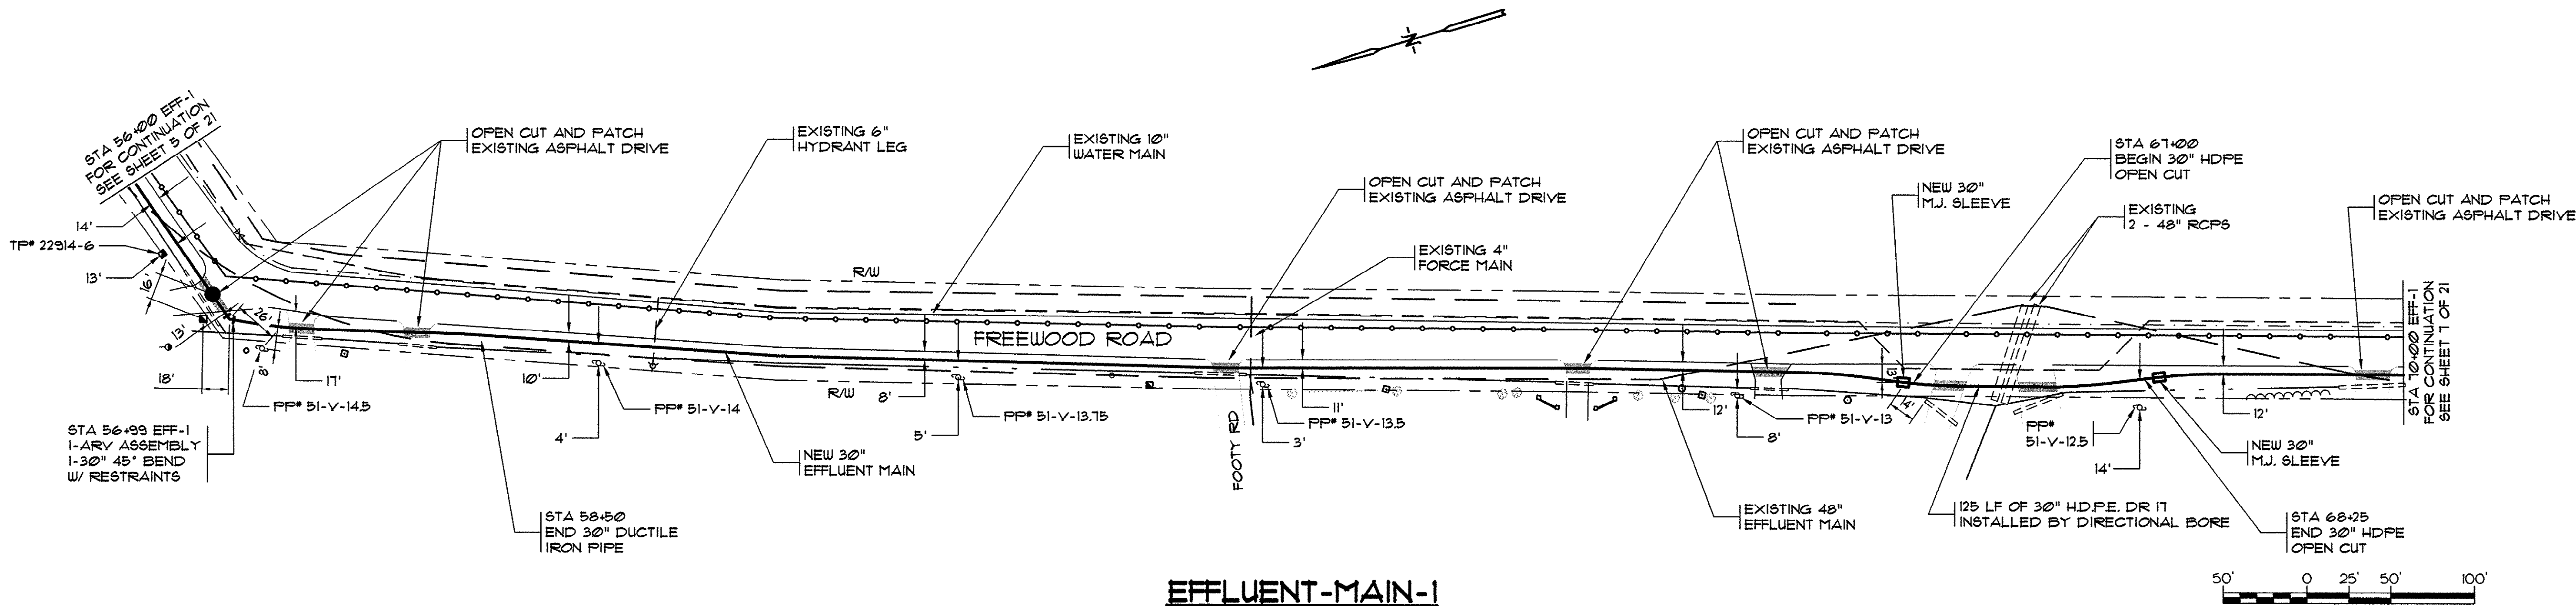

EFFLUENT-MAIN-1

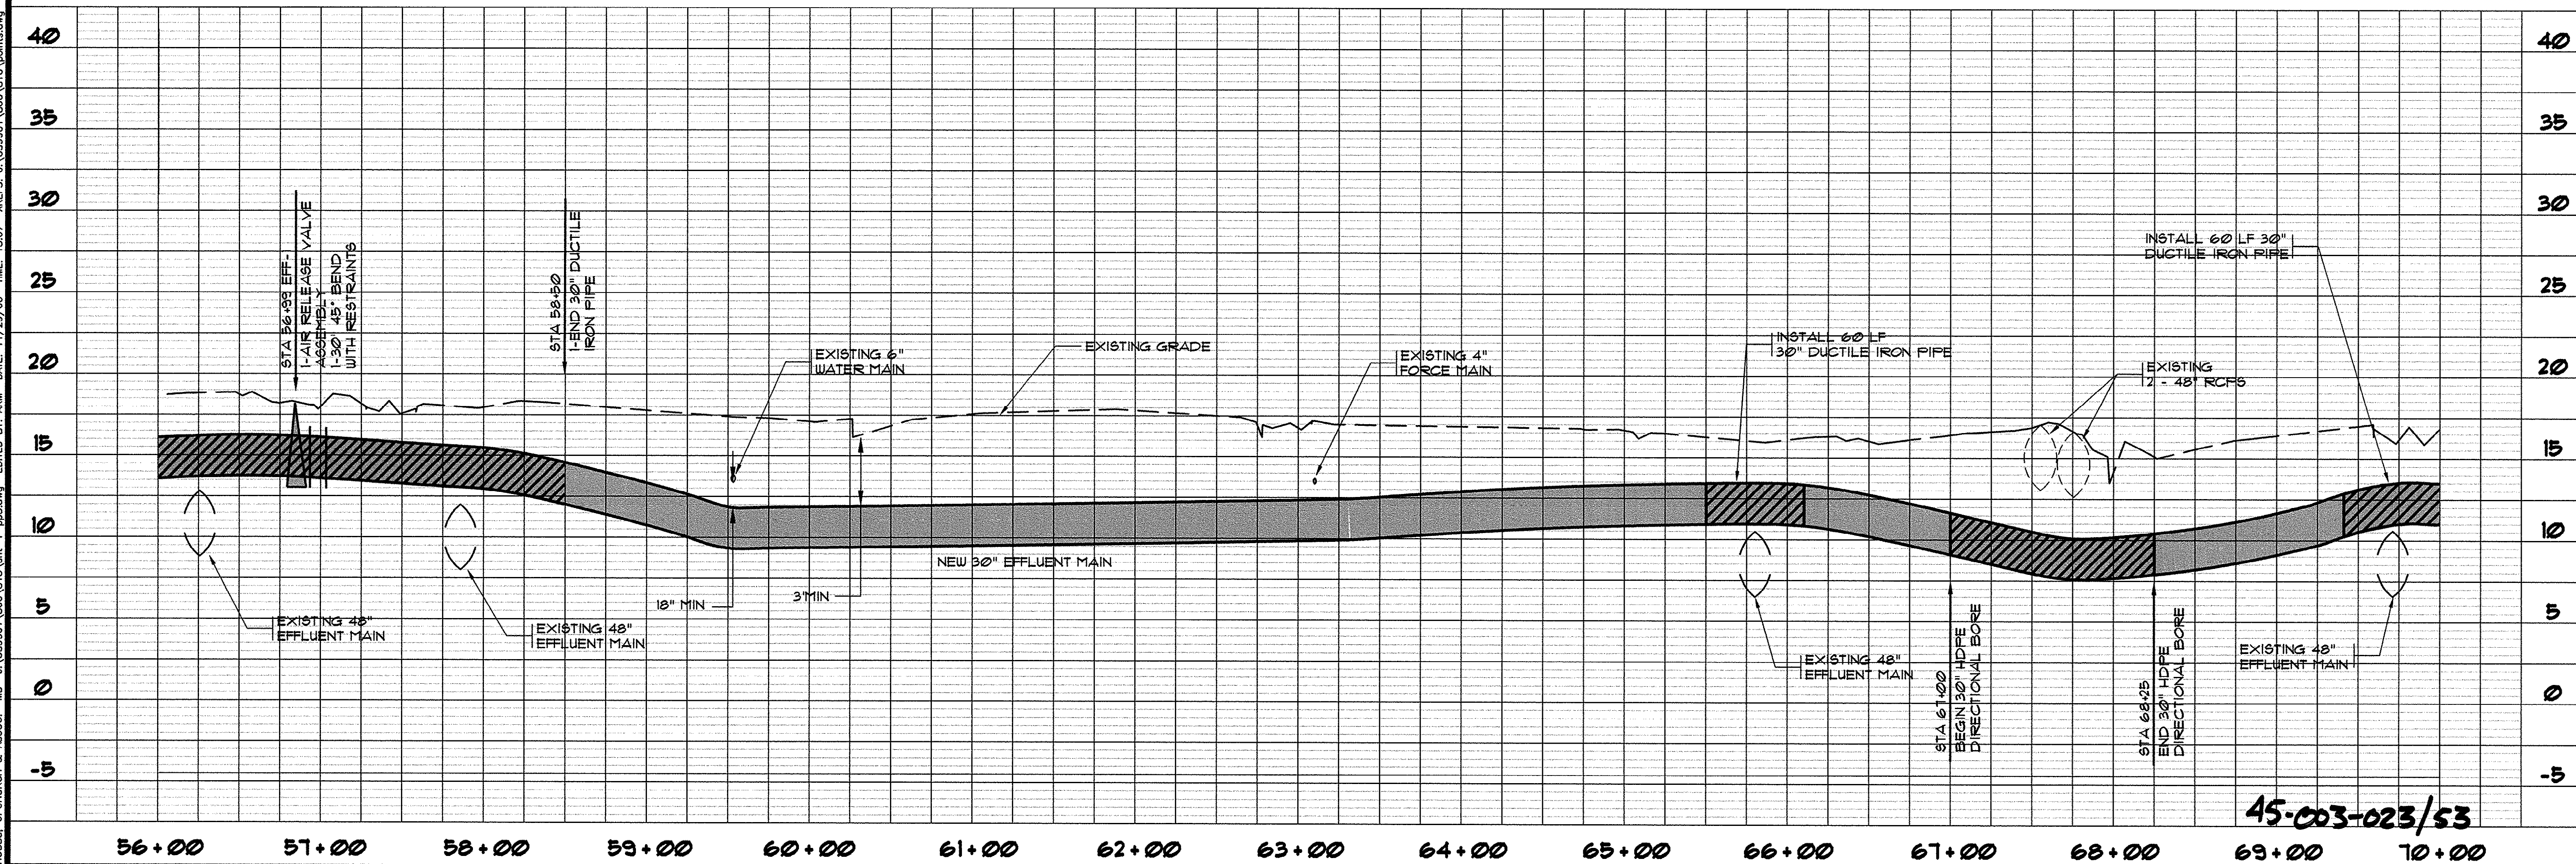

45-003-023/53

HOBBS, UPCHURCH & ASSOCIATES, P.A.
CONSULTING ENGINEERS
MYRTLE BEACH, SOUTH CAROLINA 29577

PLAN AND PROFILE
EFFLUENT MAIN 1


TIP-TOP TREE FARM
EFFLUENT LAND
APPLICATION PROJECT
GRAND STRAND WATER
AND SEWER AUTHORITY

DATE: MAR. 1999
DESIGNED: WDL
DRAWN: KLM
CHECKED: WDL
SCALE: AS SHOWN
SHEET NO.


EFF-6

OF 21


SYL.	DESCRIPTION	DATE	BY
	ADDITIONAL OPEN CUT AND PATCH AS-BUILT	9/7/99	KLM
		7/19/01	CAR

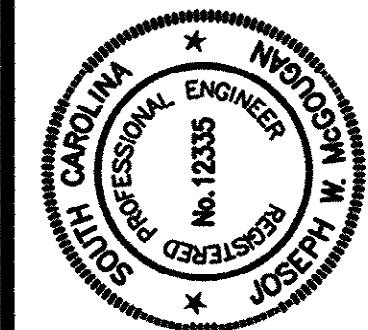


HOBBS, UPCHURCH & ASSOC. MB J:\GS9901\800\220\Contract 2 Asbuilt\eff-1-p06.dwg EDITED BY: APABON DATE: 07/20/01 TIME: 10:21 XREFS: J:\GS9901\800\810\points.dwg Layout: Layout1

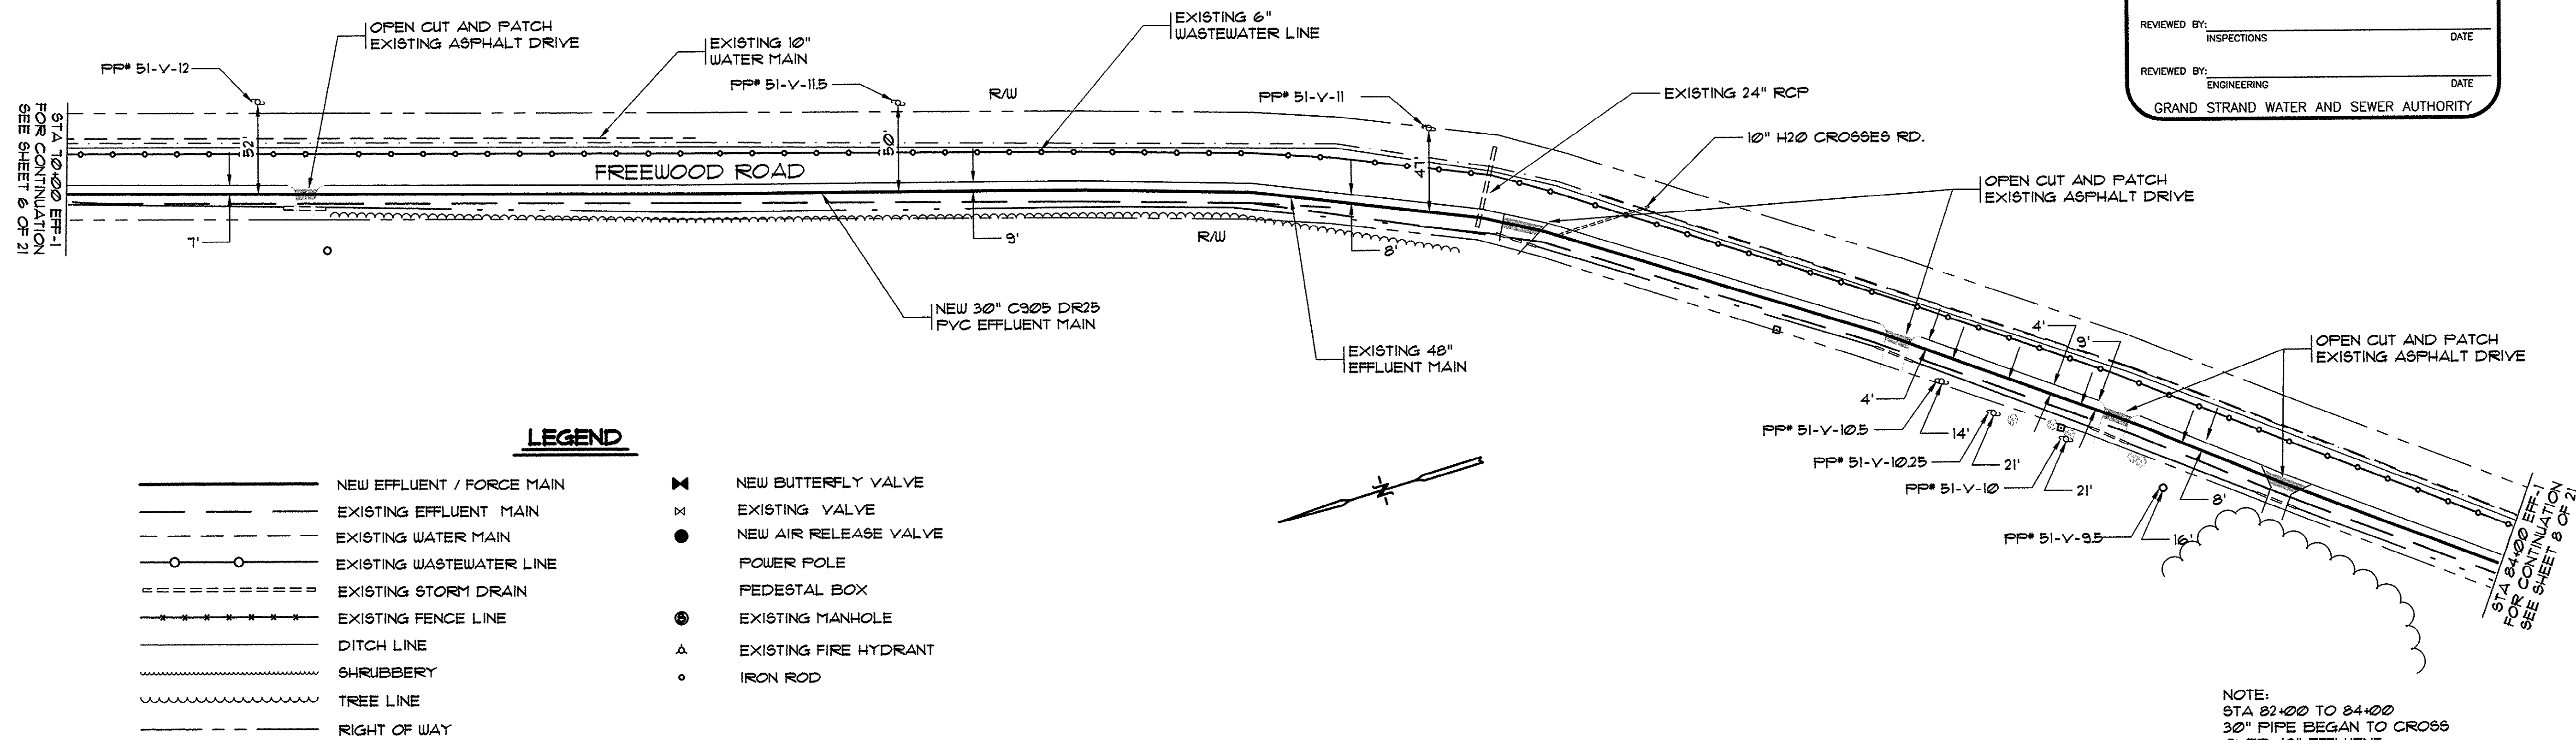

EFFLUENT-MAIN-1

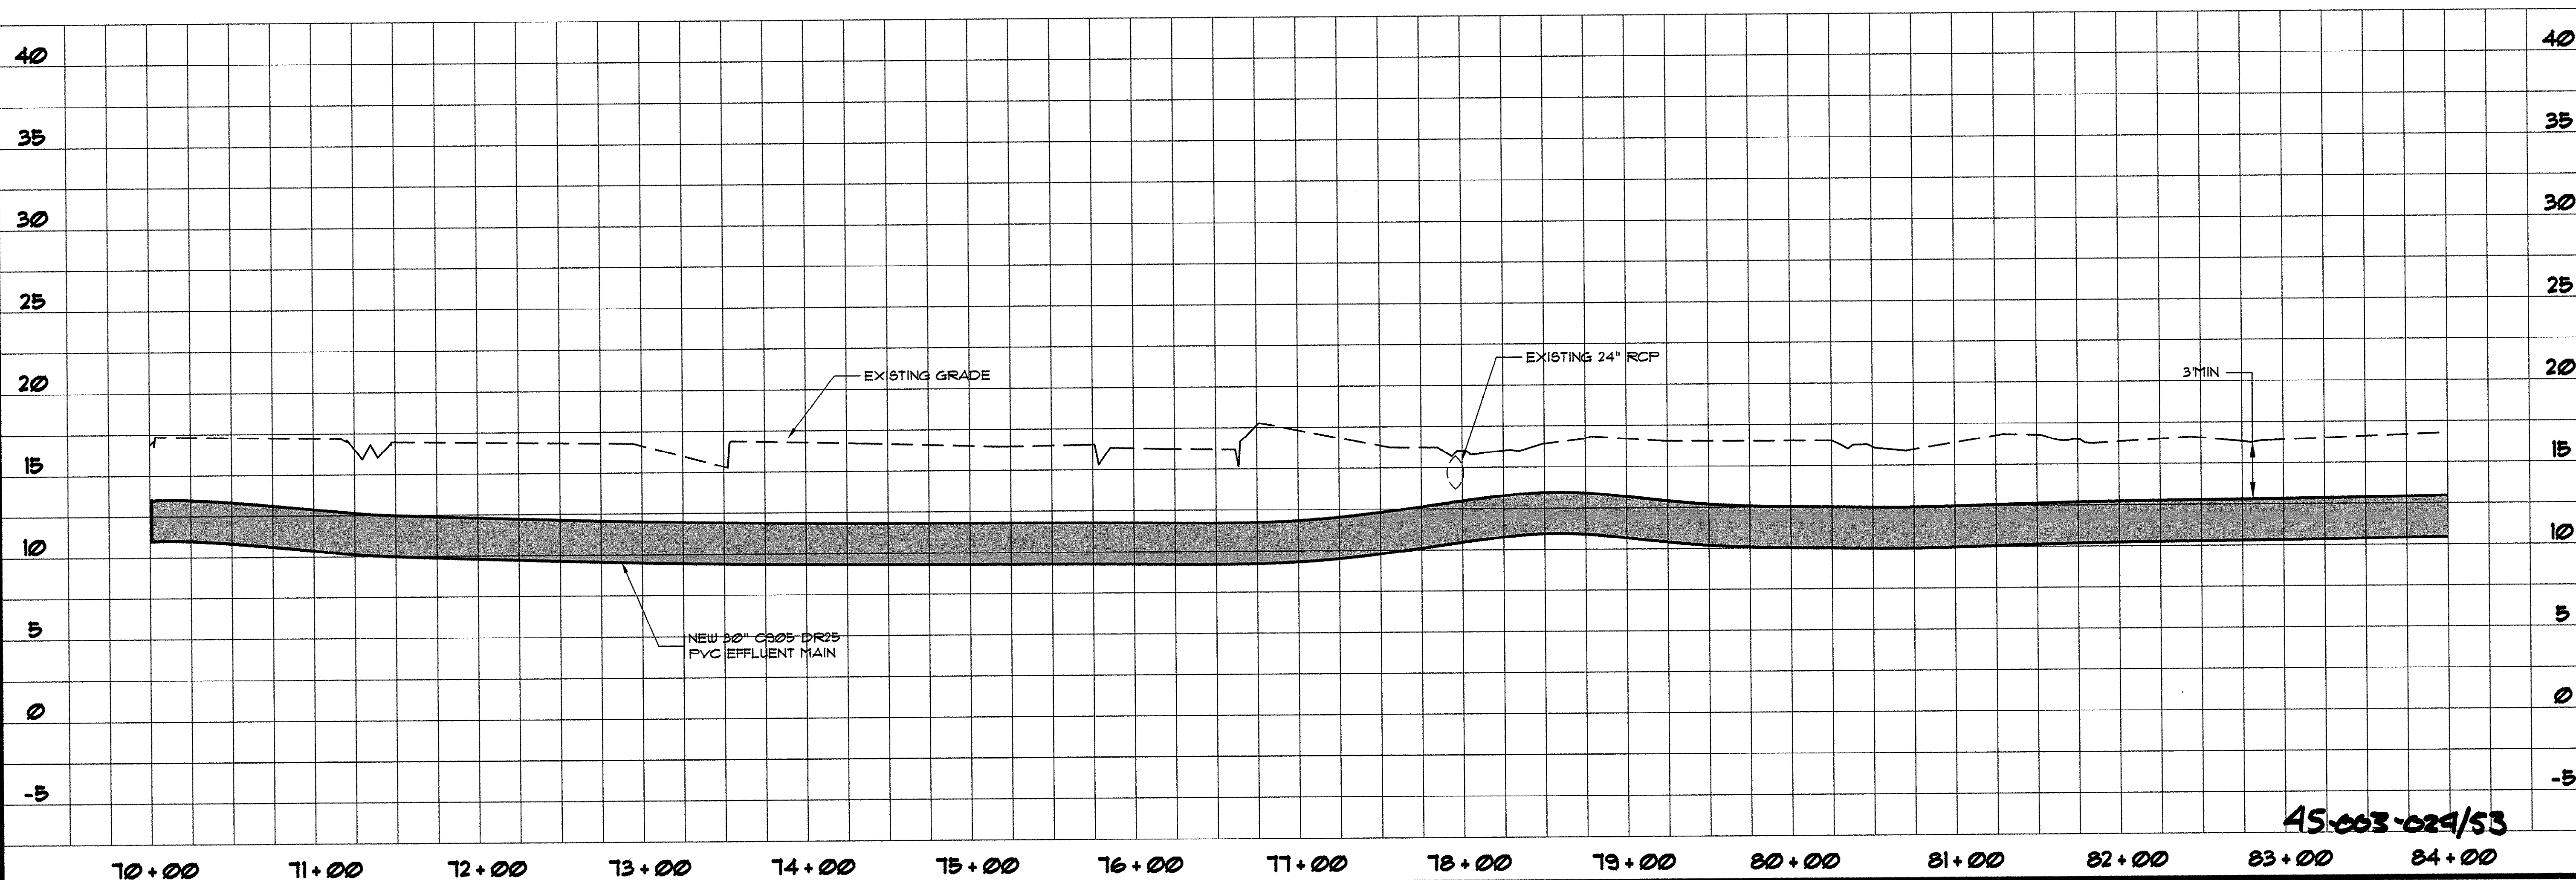

HOBBS, UPCHURCH & ASSOC. MB A:\SS9901\800\820\Contract 2 As-built\plan-1-p007.dwg EDITED BY: ARABON DATE: 07/20/01 TIME: 10:20 XREFS: A:\SS9901\800\810\points.dwg Layout: layout1

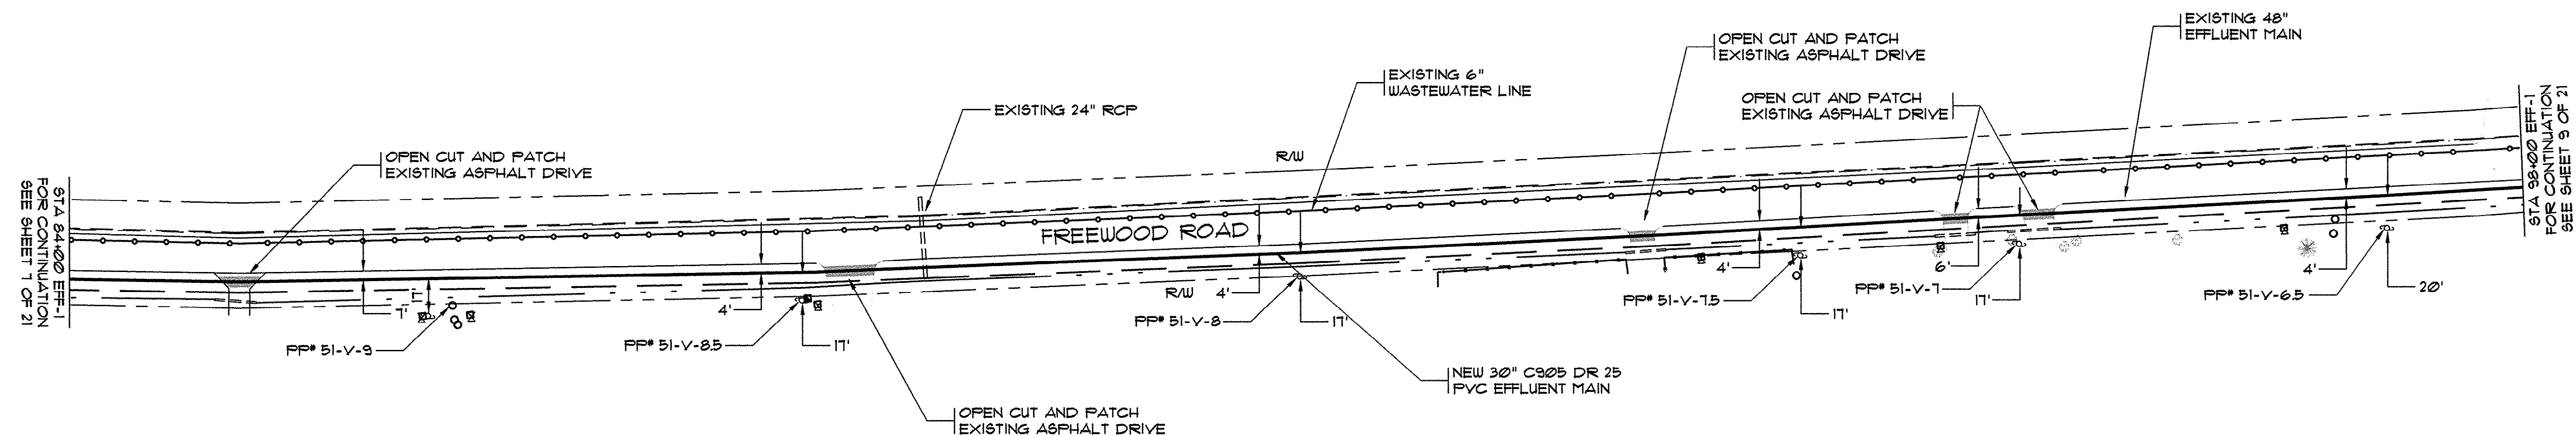

LEGEND


	NEW EFFLUENT / FORCE MAIN		NEW BUTTERFLY VALVE
	EXISTING EFFLUENT MAIN		EXISTING VALVE
	EXISTING WATER MAIN		NEW AIR RELEASE VALVE
	EXISTING WASTEWATER LINE		POWER POLE
	EXISTING STORM DRAIN		PEDESTAL BOX
	EXISTING FENCE LINE		EXISTING MANHOLE
	DITCH LINE		EXISTING FIRE HYDRANT
	SHRUBBERY		IRON ROD
	TREE LINE		
	RIGHT OF WAY		

THESE DRAWINGS REFLECT
AS-BUILT
CONDITIONS


REVIEWED BY: _____ DATE: _____
INSPECTIONS

REVIEWED BY: _____ DATE: _____
ENGINEERING

 
GRAND STRAND WATER AND SEWER AUTHORITY



EFFLUENT-MAIN-1

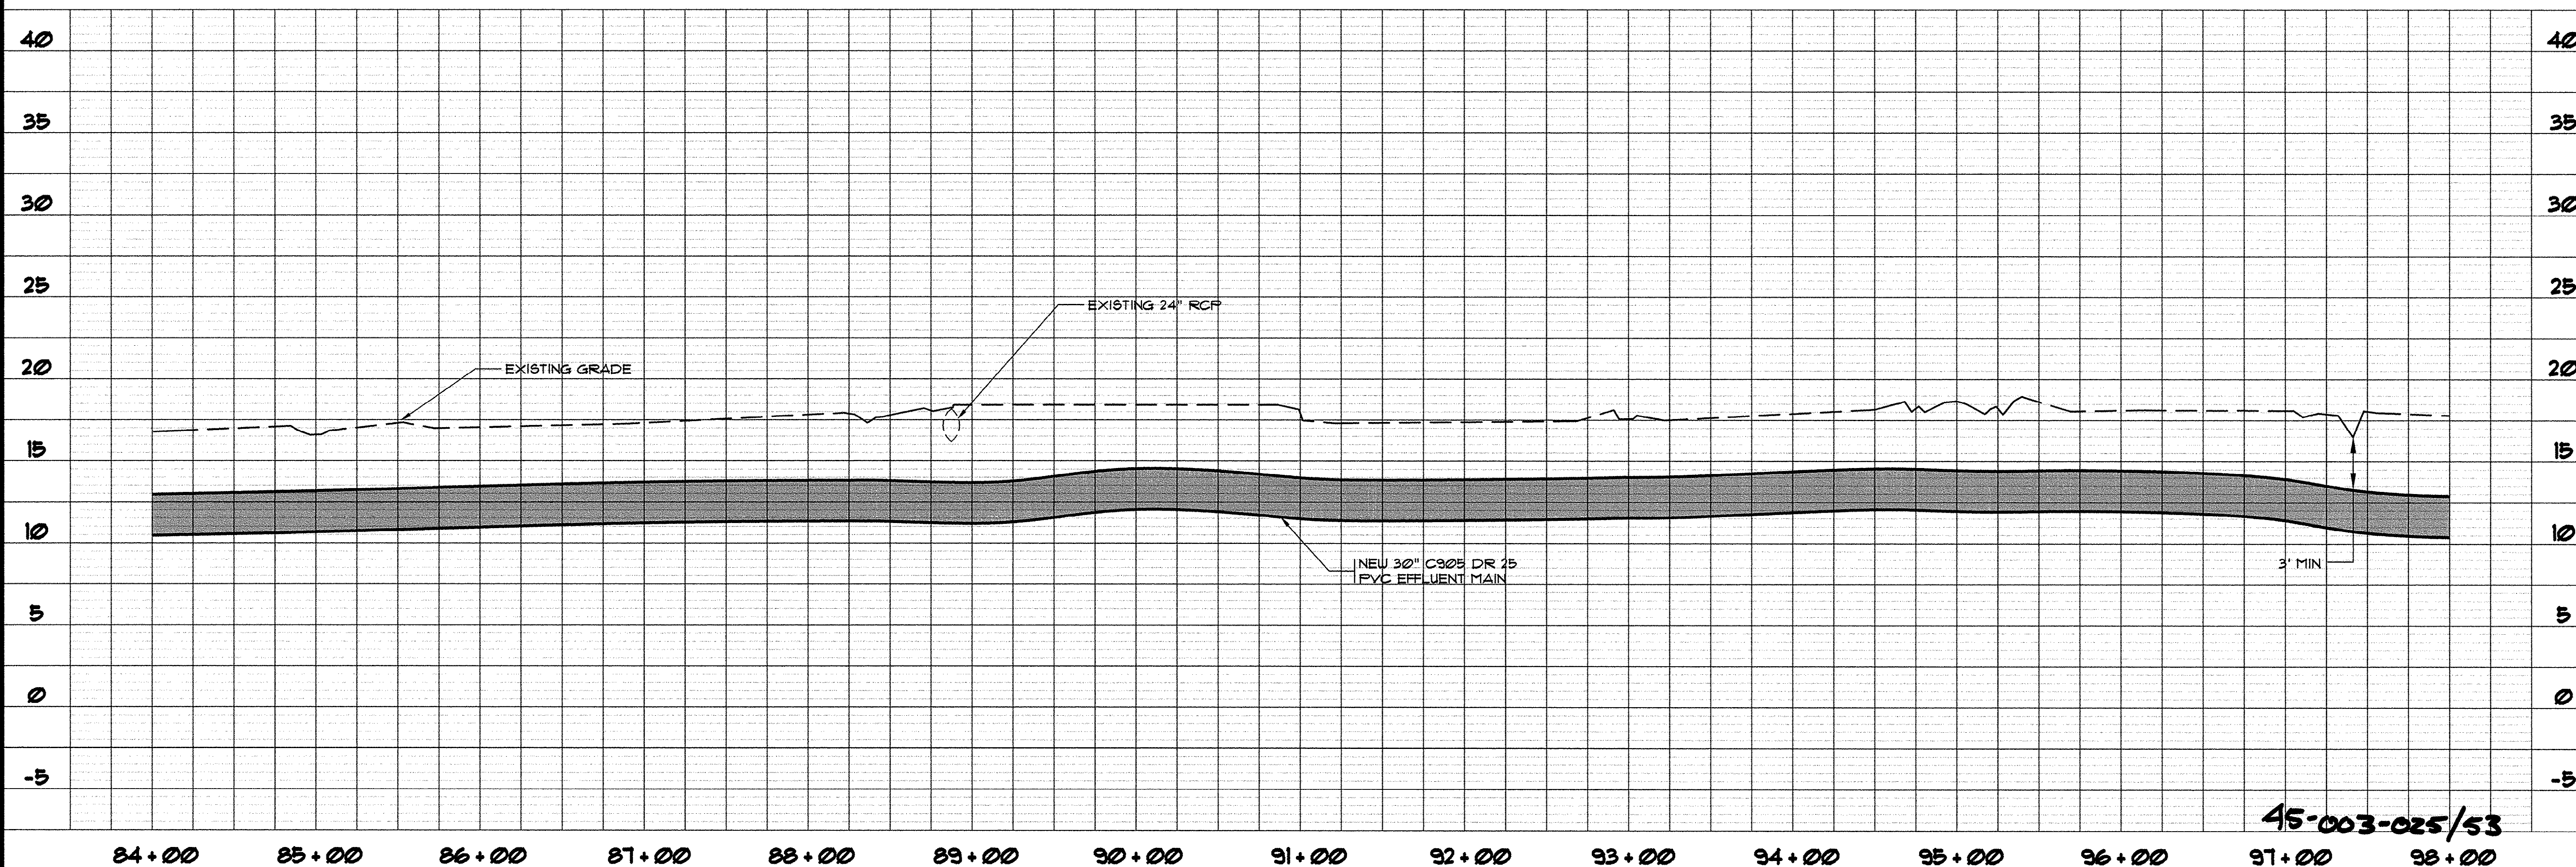

SYMBOL	DESCRIPTION	DATE	BY
	ADDITIONAL OPEN CUT AND PATCH	9/7/99	KLM
	AS-BUILT	12/8/00	ARW
	AS-BUILT	7/20/01	CAR

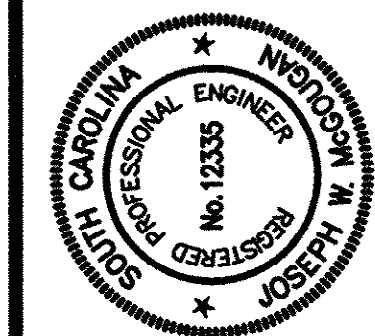

HOBBS, UPCHURCH & ASSOCIATES, P.A.
CONSULTING ENGINEERS
MYRTLE BEACH, SOUTH CAROLINA 29577

PLAN AND PROFILE
EFFLUENT MAIN 1


TIP-TOP TREE FARM
EFFLUENT LAND
APPLICATION PROJECT
GRAND STRAND WATER
AND SEWER AUTHORITY

DATE:	MAR. 1999
DESIGNED:	WDL
DRAWN:	KLM
CHECKED:	WDL
SCALE:	AS SHOWN

SHEET NO.
EFF-8
OF: 21

45-003-025/53

HOBBS, UPCHURCH & ASSOC. MB A:\SS9901\800\820\Contract 2 Asbuilt\eff-1-pp08.dwg EDITED BY: ARABON DATE: 07/20/01 TIME: 11:39 XREFS: A:\SS9901\800\810\Joint.dwg Layout: Layout1

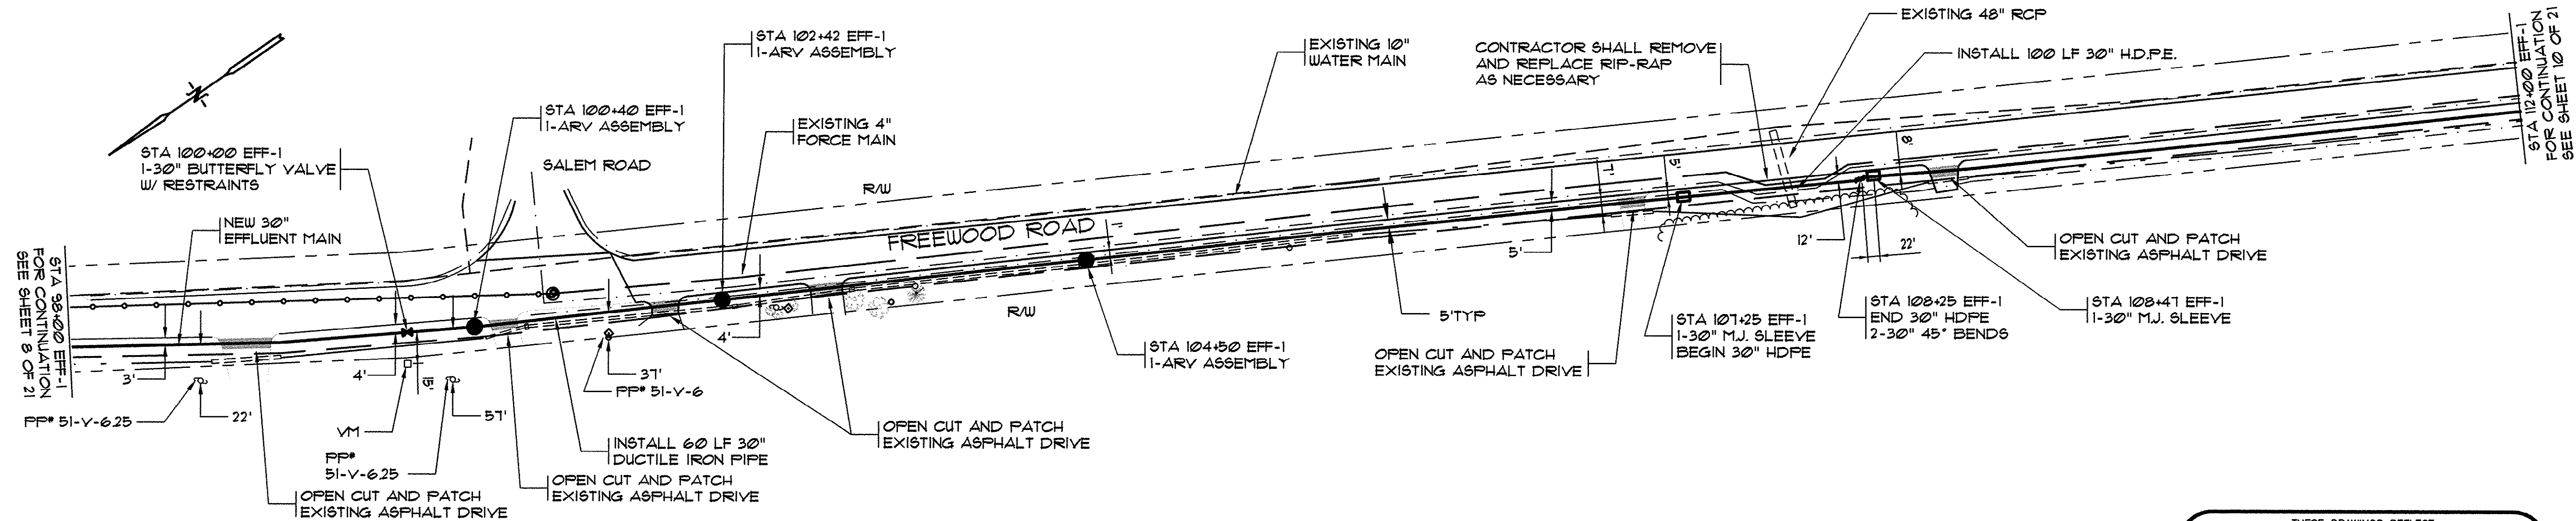


LEGEND	
	NEW EFFLUENT / FORCE MAIN
	EXISTING EFFLUENT MAIN
	EXISTING WATER MAIN
	EXISTING WASTEWATER LINE
	EXISTING STORM DRAIN
	EXISTING FENCE LINE
	DITCH LINE
	SHRUBBERY
	TREE LINE
	RIGHT OF WAY
	NEW BUTTERFLY VALVE
	EXISTING VALVE
	NEW AIR RELEASE VALVE
	POWER POLE
	PEDESTAL BOX
	EXISTING MANHOLE
	EXISTING FIRE HYDRANT
	IRON ROD

THESE DRAWINGS REFLECT AS-BUILT CONDITIONS	
REVIEWED BY: _____	DATE: _____
INSPECTIONS	
REVIEWED BY: _____	DATE: _____
ENGINEERING	
GRAND STRAND WATER AND SEWER AUTHORITY	




EFFLUENT-MAIN-1

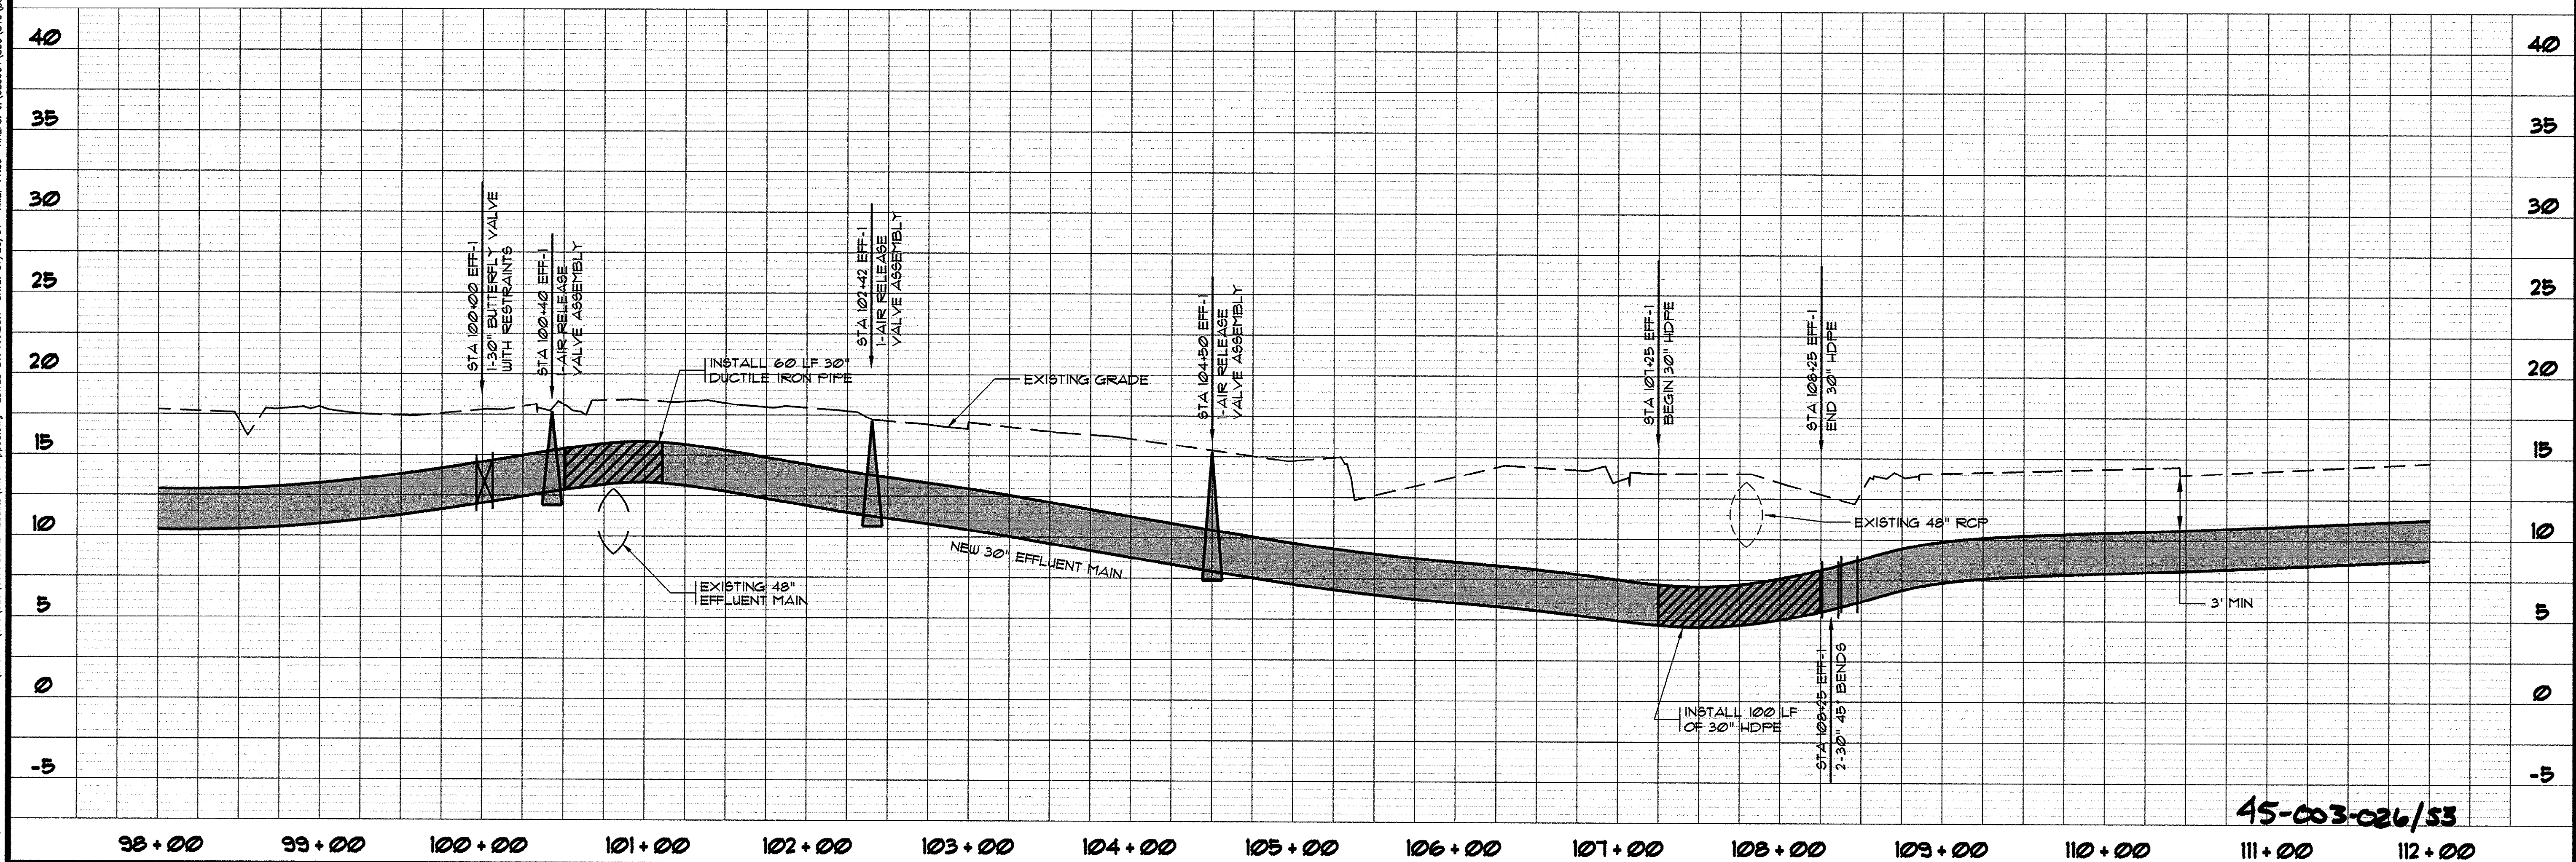

45-003-026/53

SYN.	DESCRIPTION	DATE	BY
	ADDITIONAL OPEN CUT AND PATCH	9/7/99	KLM
	AS-BUILT	7/20/01	CAR

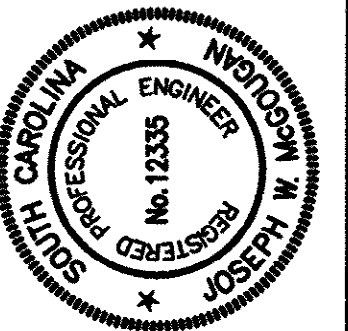

HOBBS, UPCHURCH & ASSOCIATES, P.A.
CONSULTING ENGINEERS
MYRTLE BEACH, SOUTH CAROLINA 29577



PLAN AND PROFILE
EFFLUENT MAIN 1

TIP-TOP TREE FARM
EFFLUENT LAND
APPLICATION PROJECT
GRAND STRAND WATER
AND SEWER AUTHORITY

DATE:	MAR. 1999
DESIGNED:	WDL
DRAWN:	KLM
CHECKED:	WDL
SCALE:	AS SHOWN


SHEET NO.

EFF-9

OF 21


HOBBES, UPCHURCH & ASSOC. MB J:\GS9901\800\820\Contract 2 Asbuilt\sh-1-1-p09.dwg EDITED BY: ARABON DATE: 07/20/01 TIME: 13:20 XREFS: J:\GS9901\800\810\points.dwg Layout: Layout1

THESE DRAWINGS REFLECT AS-BUILT CONDITIONS		
REVIEWED BY:	INSPECTIONS	DATE
REVIEWED BY:	ENGINEERING	DATE
GRAND STRAND WATER AND SEWER AUTHORITY		

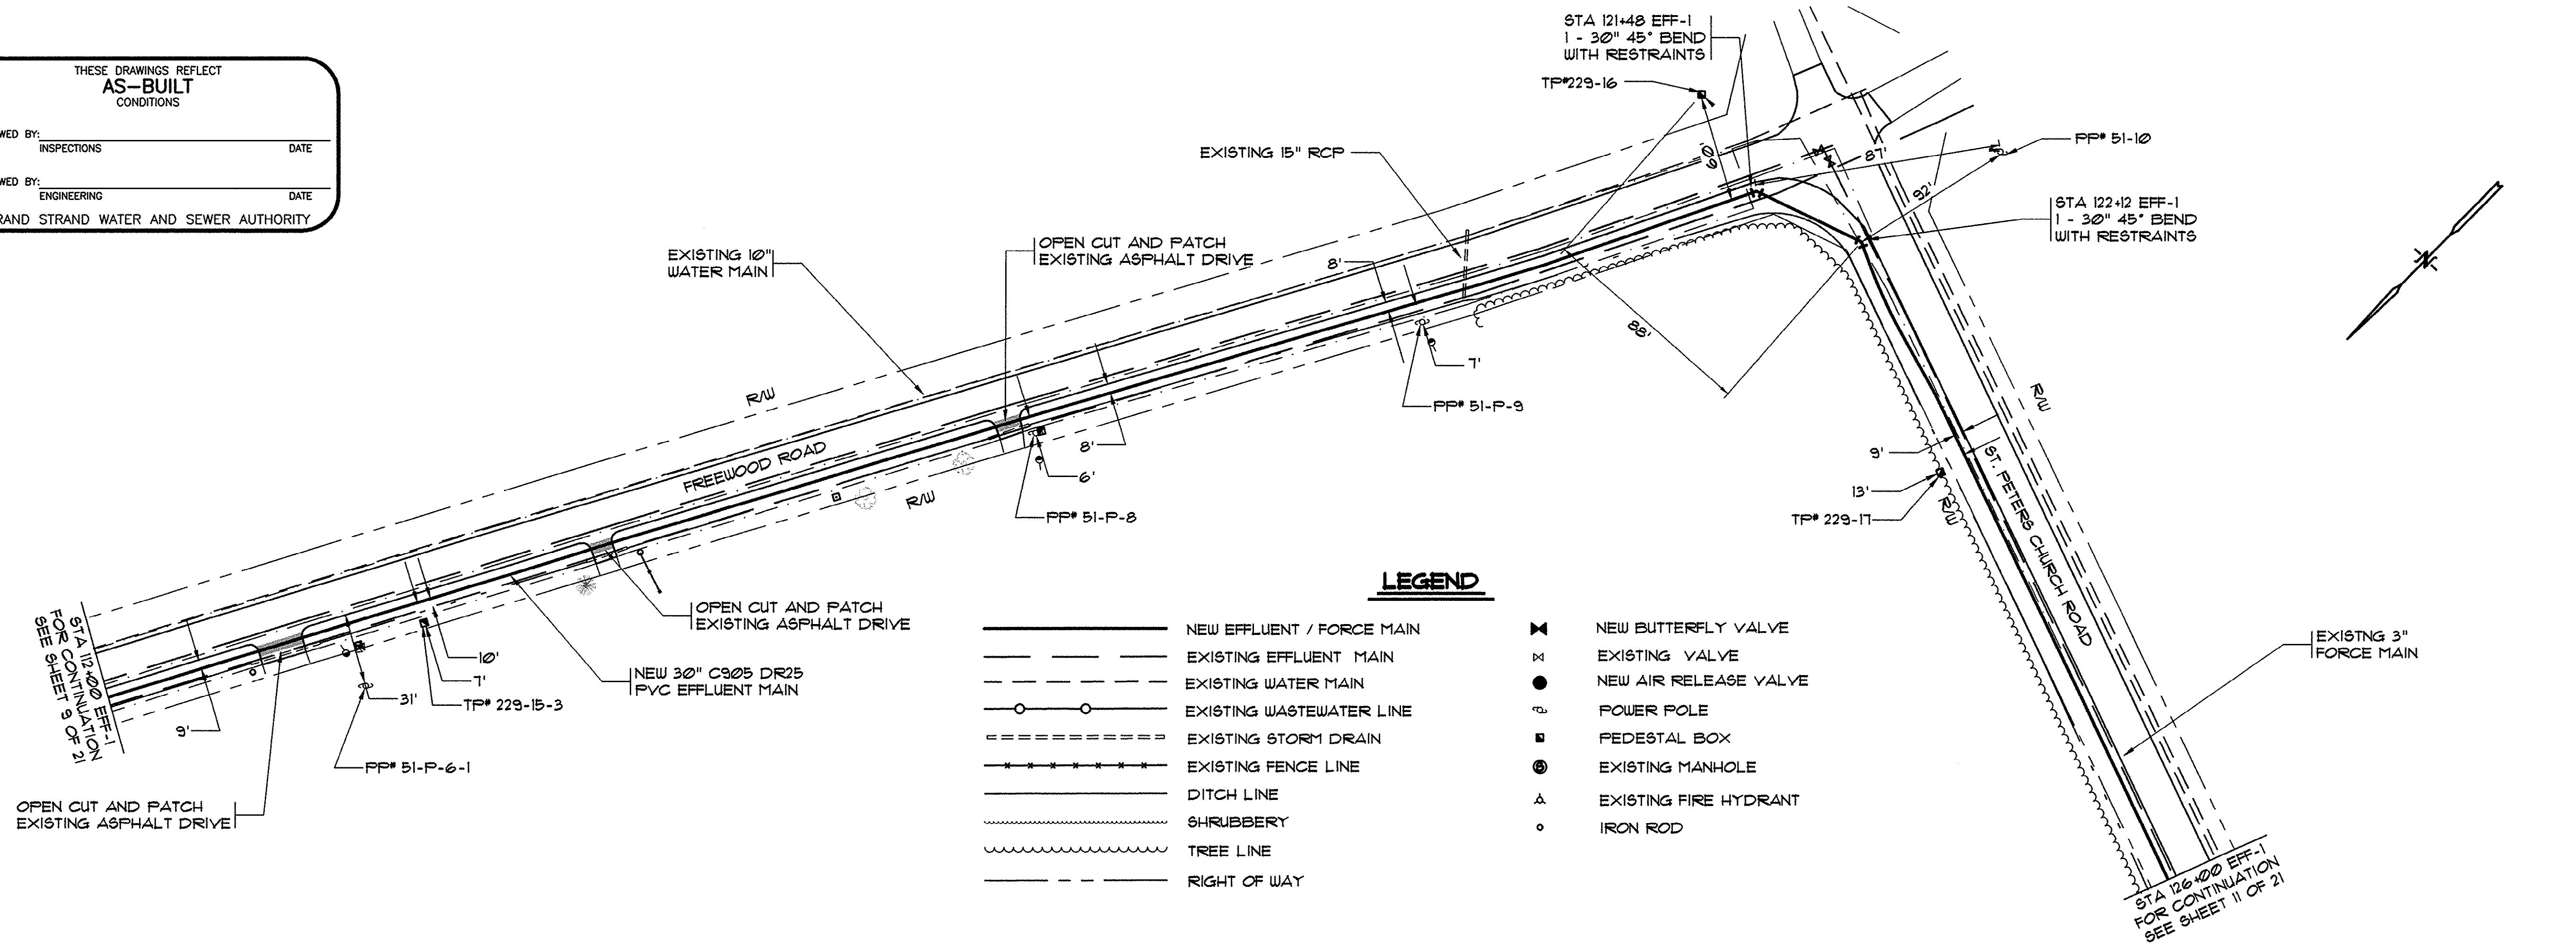


- LEGEND**
- | | | | |
|-------|---------------------------|---|-----------------------|
| — | NEW EFFLUENT / FORCE MAIN | ✕ | NEW BUTTERFLY VALVE |
| - - - | EXISTING EFFLUENT MAIN | ⊞ | EXISTING VALVE |
| - - - | EXISTING WATER MAIN | ● | NEW AIR RELEASE VALVE |
| - - - | EXISTING WASTEWATER LINE | ⊙ | POWER POLE |
| - - - | EXISTING STORM DRAIN | ■ | PEDESTAL BOX |
| - - - | EXISTING FENCE LINE | ⊗ | EXISTING MANHOLE |
| - - - | DITCH LINE | △ | EXISTING FIRE HYDRANT |
| - - - | SHRUBBERY | ○ | IRON ROD |
| - - - | TREE LINE | | |
| - - - | RIGHT OF WAY | | |

EFFLUENT-MAIN-1

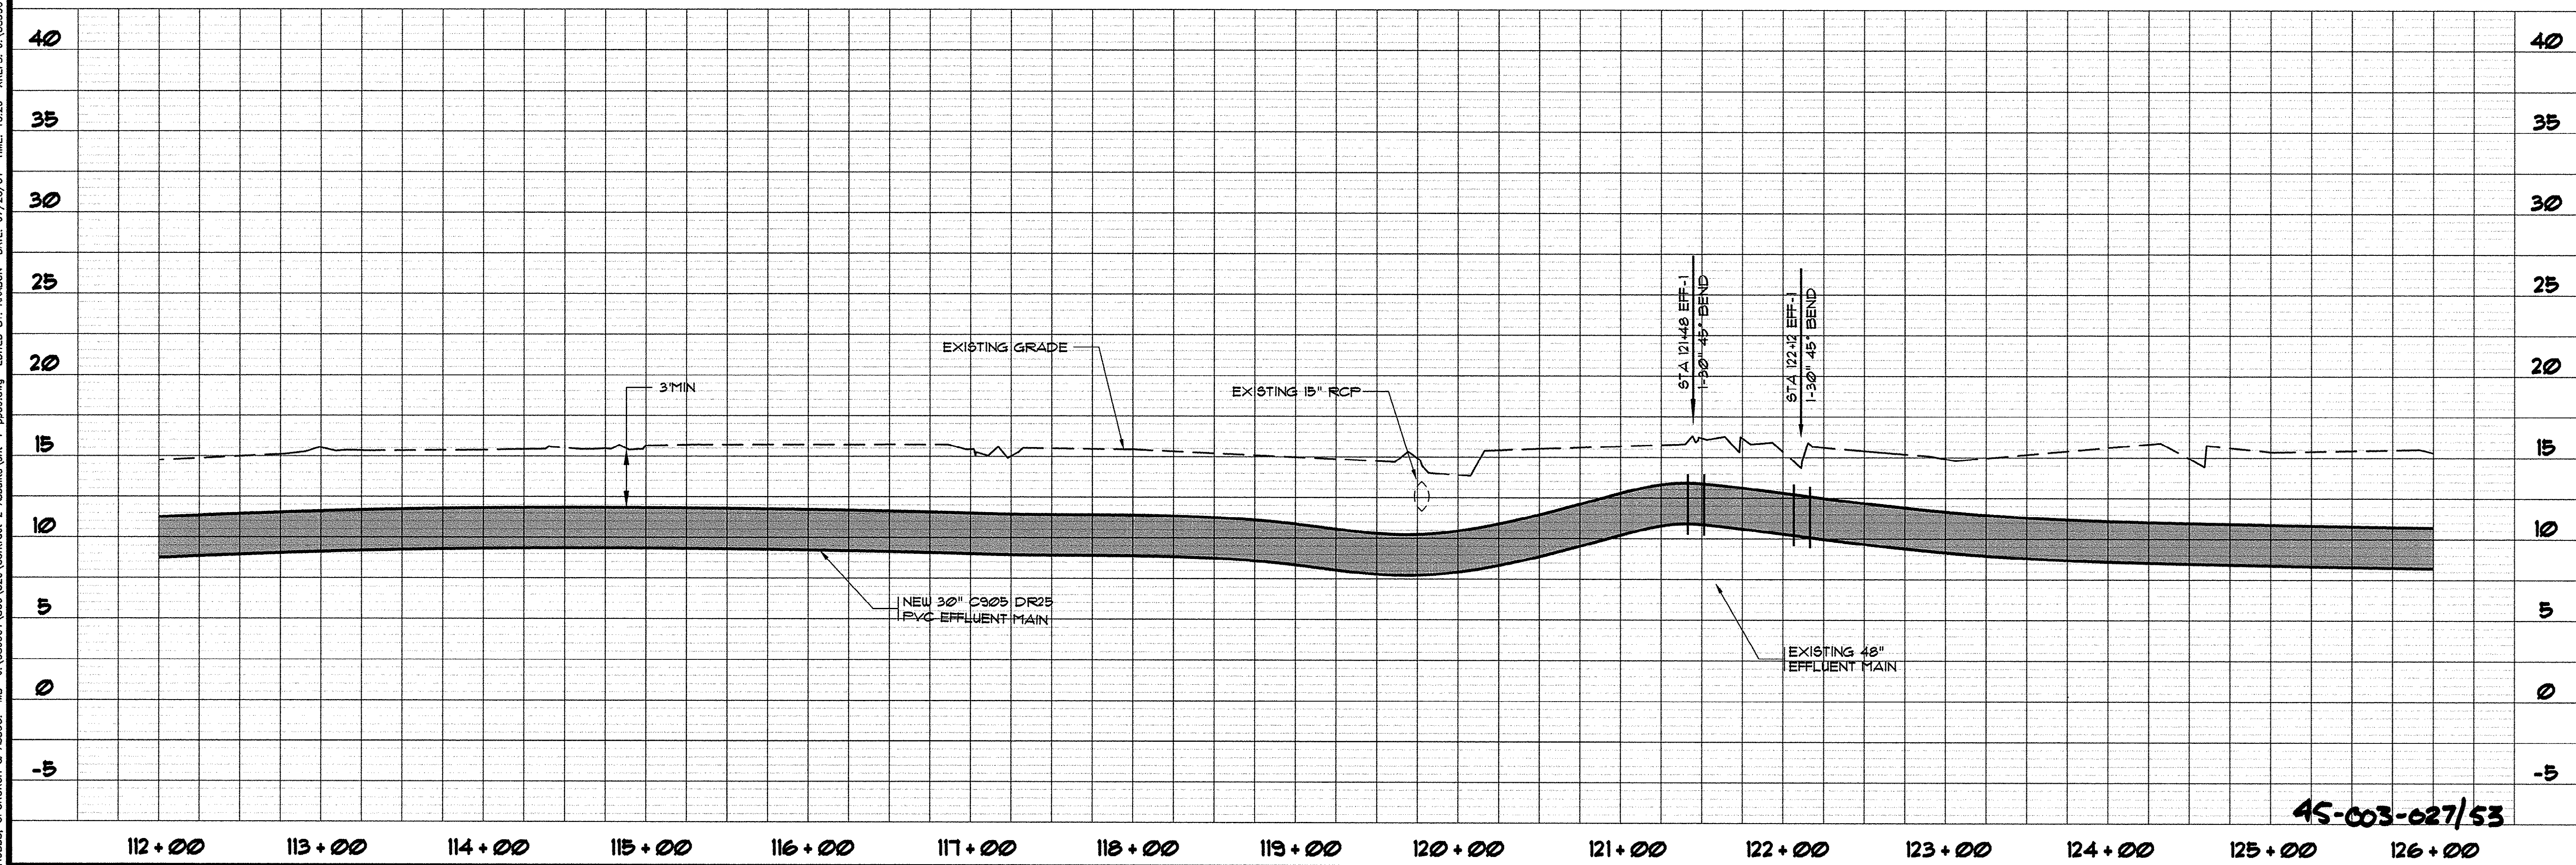

45-003-027/53

REVISIONS		DATE	BY
SYMBOL	DESCRIPTION	9/7/99	KLM
	ADDITIONAL OPEN CUT AND PATCH	12/8/00	ARM
	AS-BUILT	7/20/01	CAR
	AS-BUILT		
	AS-BUILT		
	AS-BUILT		
	AS-BUILT		

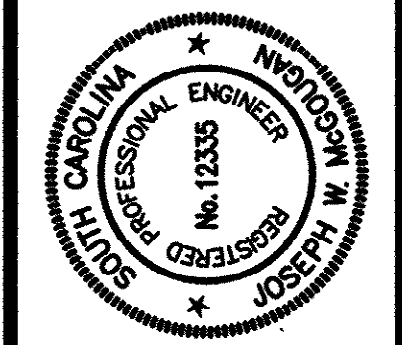

HOBBES, UPCHURCH & ASSOCIATES, PA
CONSULTING ENGINEERS
MYRTLE BEACH, SOUTH CAROLINA 29577


PLAN AND PROFILE
EFFLUENT MAIN 1

TIP-TOP TREE FARM
EFFLUENT LAND
APPLICATION PROJECT
GRAND STRAND WATER
AND SEWER AUTHORITY

DATE:	MAR. 1999
DESIGNED:	WDL
DRAWN:	KLM
CHECKED:	WDL
SCALE:	AS SHOWN

SHEET NO.
EFF-10
OF 21

HOBBES, UPCHURCH & ASSOC. MB J:\GS9901\800\820\Contract 2 Asubilla\sh-1-pp10.dwg EDITED BY: ARABON DATE: 07/20/01 TIME: 13:37 XREFS: J:\GS9901\800\810\points.dwg Layout: Layout1

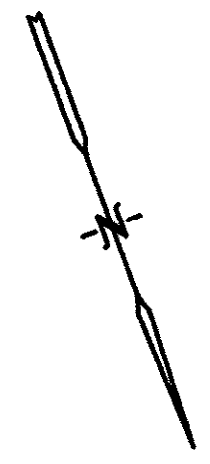


- LEGEND**
- | | | | |
|---------------|---------------------------|---|-----------------------|
| — | NEW EFFLUENT / FORCE MAIN | ✕ | NEW BUTTERFLY VALVE |
| - - - | EXISTING EFFLUENT MAIN | ✕ | EXISTING VALVE |
| - - - | EXISTING WATER MAIN | ● | NEW AIR RELEASE VALVE |
| ○ | EXISTING WASTEWATER LINE | ⊙ | POWER POLE |
| ===== | EXISTING STORM DRAIN | ■ | PEDESTAL BOX |
| - * - * - * - | EXISTING FENCE LINE | ⊙ | EXISTING MANHOLE |
| — | DITCH LINE | △ | EXISTING FIRE HYDRANT |
| ~~~~~ | SHRUBBERY | ○ | IRON ROD |
| ~~~~~ | TREE LINE | | |
| - - - | RIGHT OF WAY | | |

THESE DRAWINGS REFLECT
AS-BUILT
CONDITIONS



REVIEWED BY: _____ DATE: _____
INSPECTIONS

REVIEWED BY: _____ DATE: _____
ENGINEERING

GRAND STRAND WATER AND SEWER AUTHORITY

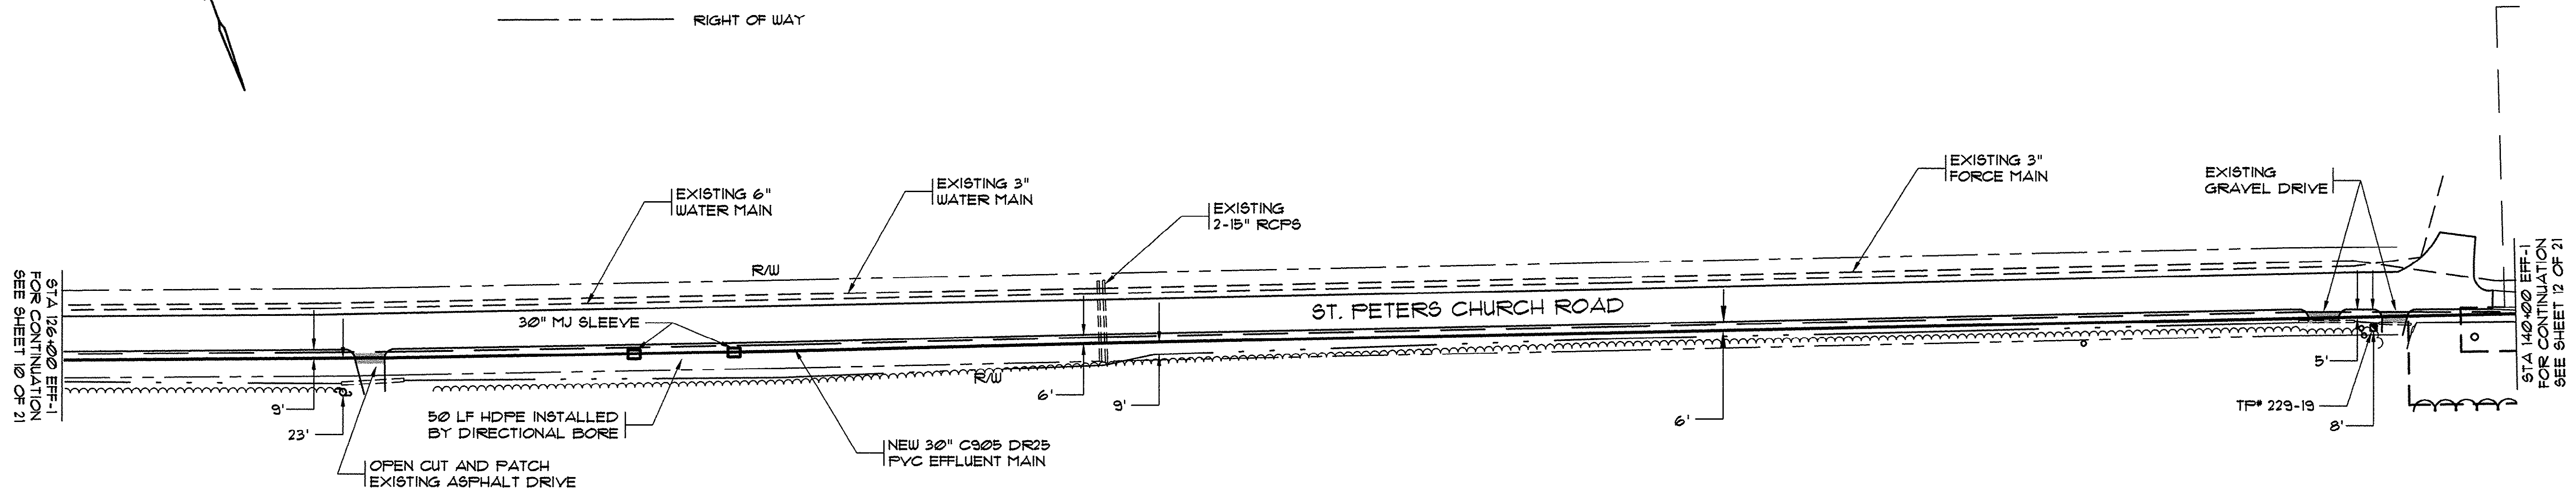


EFFLUENT-MAIN-1

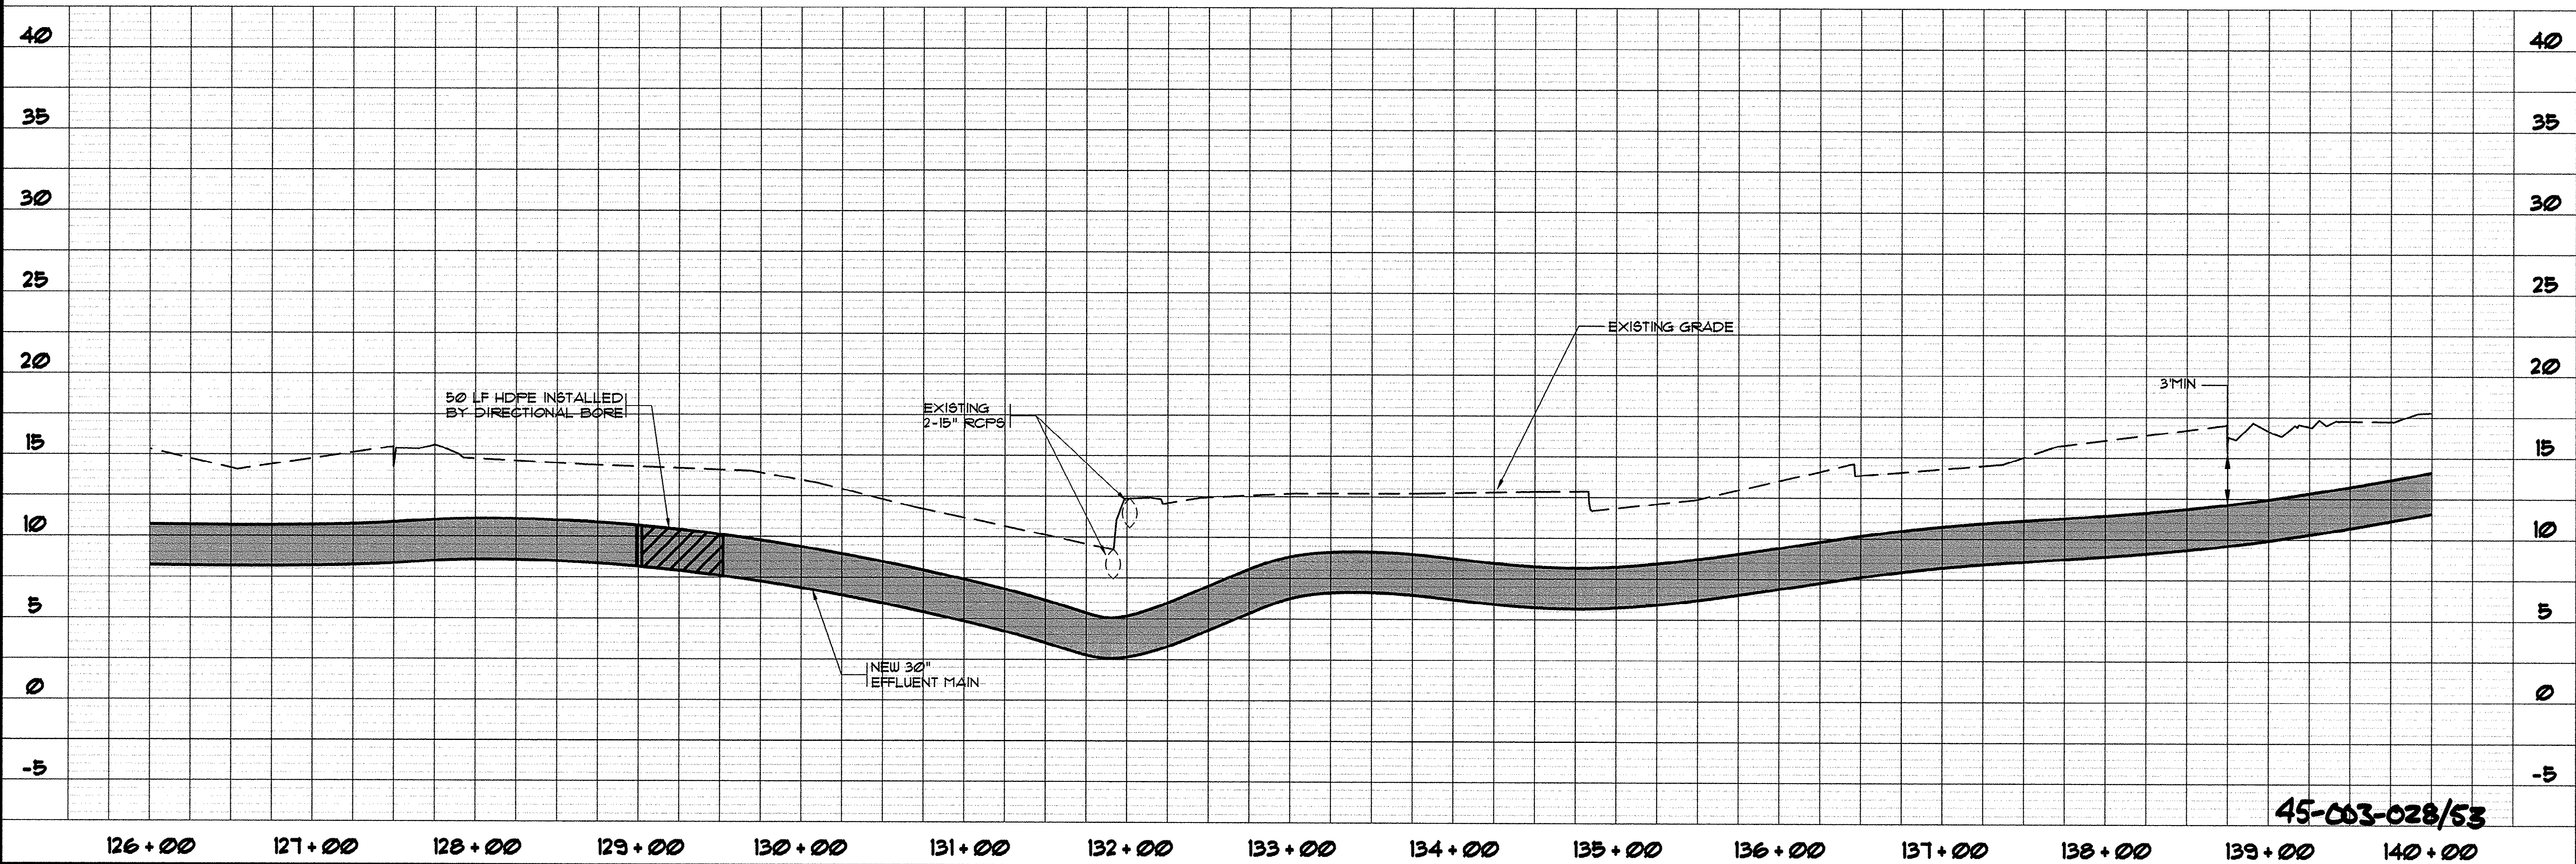 

45-003-028/53

REVISIONS		DATE	BY
DESCRIPTION	AS-BUILT	12/8/00	ARM
AS-BUILT	AS-BUILT	7/20/01	CAR
SYMBOL			

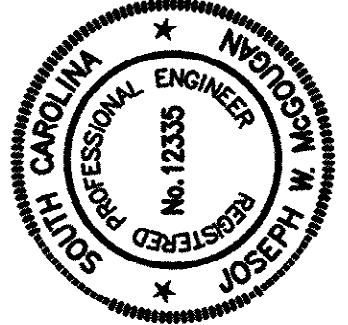

HOBBES, UPCHURCH & ASSOCIATES, PA
CONSULTING ENGINEERS
MYRTLE BEACH, SOUTH CAROLINA 29577

PLAN AND PROFILE
EFFLUENT MAIN 1

TIP-TOP TREE FARM
EFFLUENT LAND
APPLICATION PROJECT
GRAND STRAND WATER
AND SEWER AUTHORITY

DATE: MAR. 1999

DESIGNED: WDL

DRAWN: KLM

CHECKED: WDL


SCALE: AS SHOWN

SHEET NO.

EFF-11

OF 21

HOBBBS, UPCHURCH & ASSOC. MB J:\GS9901\800\820\Contract 2 Asubulka sh-1-1-pa11.dwg EDITED BY: ARABON DATE: 07/20/01 TIME: 13:39 XREFS: J:\GS9901\800\810\points.dwg Layout: Layout1

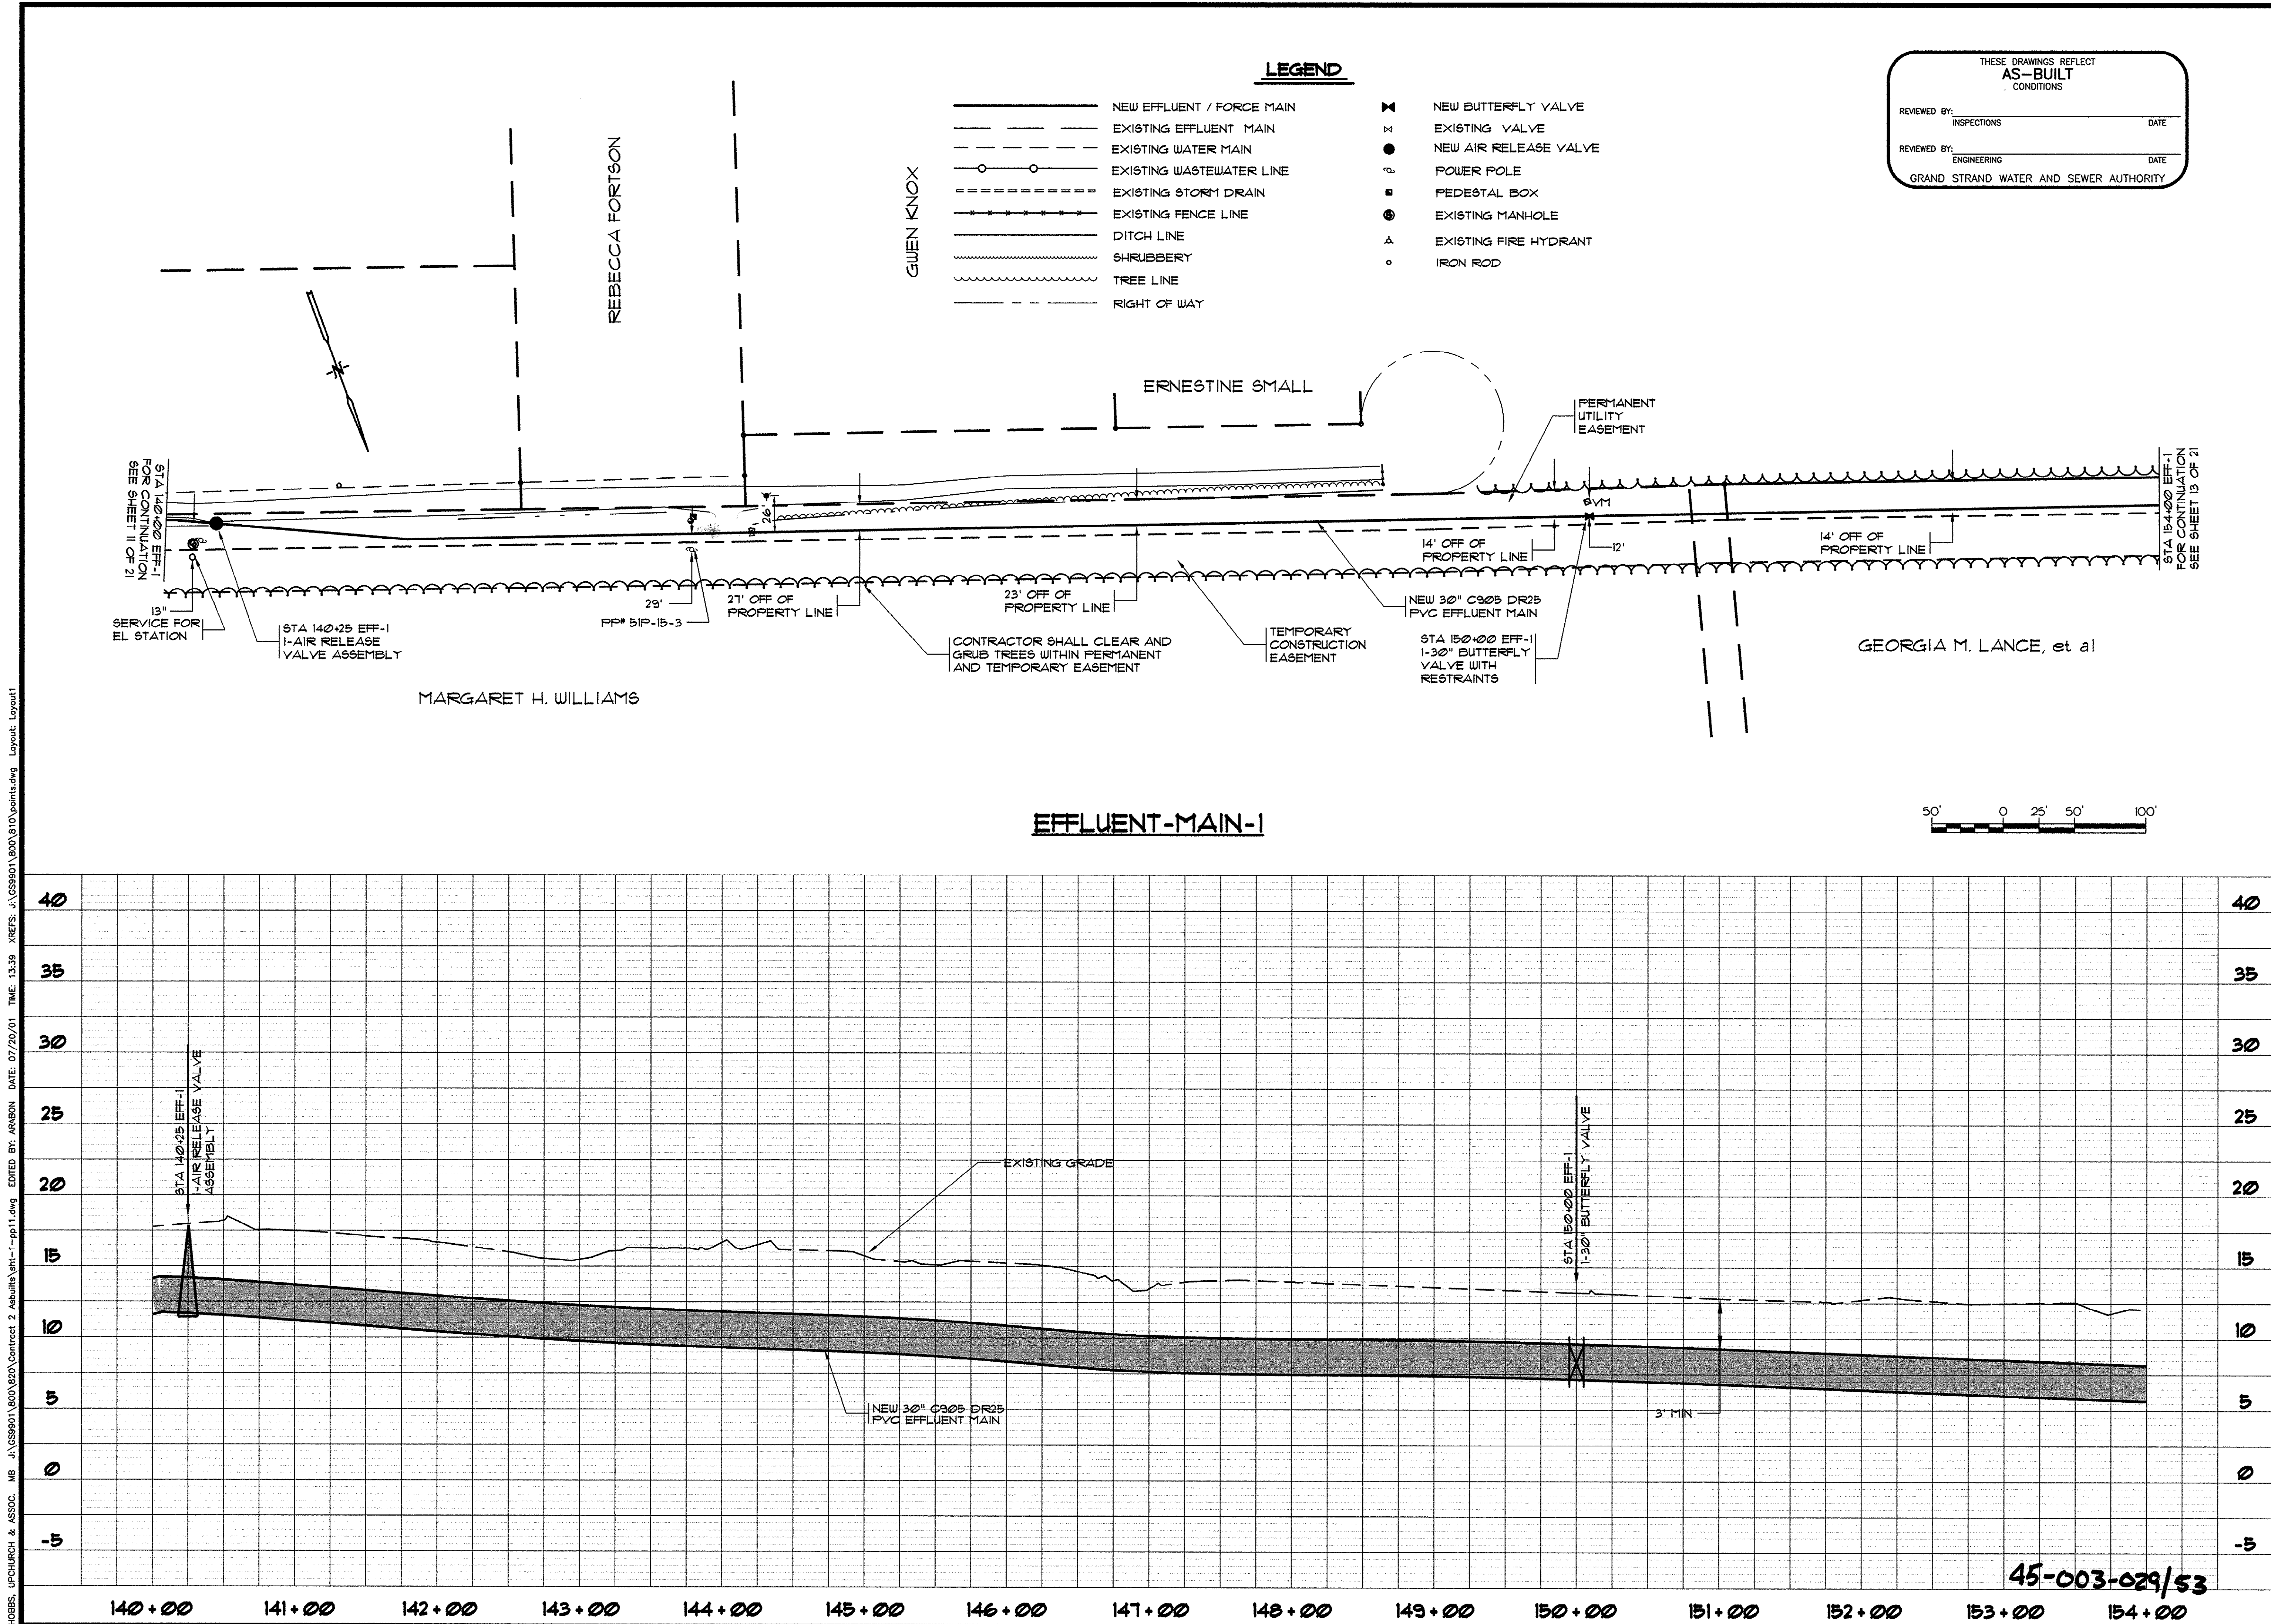

SYL	DESCRIPTION	DATE	BY
	AS-BUILT	12/8/00	ARM
	AS-BUILT	7/20/01	CAR

REVISIONS

REGISTERED PROFESSIONAL ENGINEER
No. 12335
JOSEPH M. HOBBS

HOBBBS, UPCHURCH & ASSOCIATES P.A.
CONSULTING ENGINEERS
MYRTLE BEACH, SOUTH CAROLINA 29577

**PLAN AND PROFILE
EFFLUENT MAIN 1**

**TIP-TOP TREE FARM
EFFLUENT LAND
APPLICATION PROJECT**
GRAND STRAND WATER
AND SEWER AUTHORITY

DATE: MAR. 1999

DESIGNED: WDL

DRAWN: KLM

CHECKED: WDL

SCALE: AS SHOWN

SHEET NO.


EFF-12

OF: 21

HOBBS, UPCHURCH & ASSOC. MB J:\GS9901\800\220\Contract 2 Asbuilt\shl-1-pp12.dwg EDITED BY: ARABON DATE: 07/20/01 TIME: 14:03 XREFS: J:\GS9901\800\810\points.dwg Layout: Layout1

LEGEND

	NEW EFFLUENT / FORCE MAIN		NEW BUTTERFLY VALVE
	EXISTING EFFLUENT MAIN		EXISTING VALVE
	EXISTING WATER MAIN		NEW AIR RELEASE VALVE
	EXISTING WASTEWATER LINE		POWER POLE
	EXISTING STORM DRAIN		PEDESTAL BOX
	EXISTING FENCE LINE		EXISTING MANHOLE
	DITCH LINE		EXISTING FIRE HYDRANT
	SHRUBBERY		IRON ROD
	TREE LINE		
	RIGHT OF WAY		

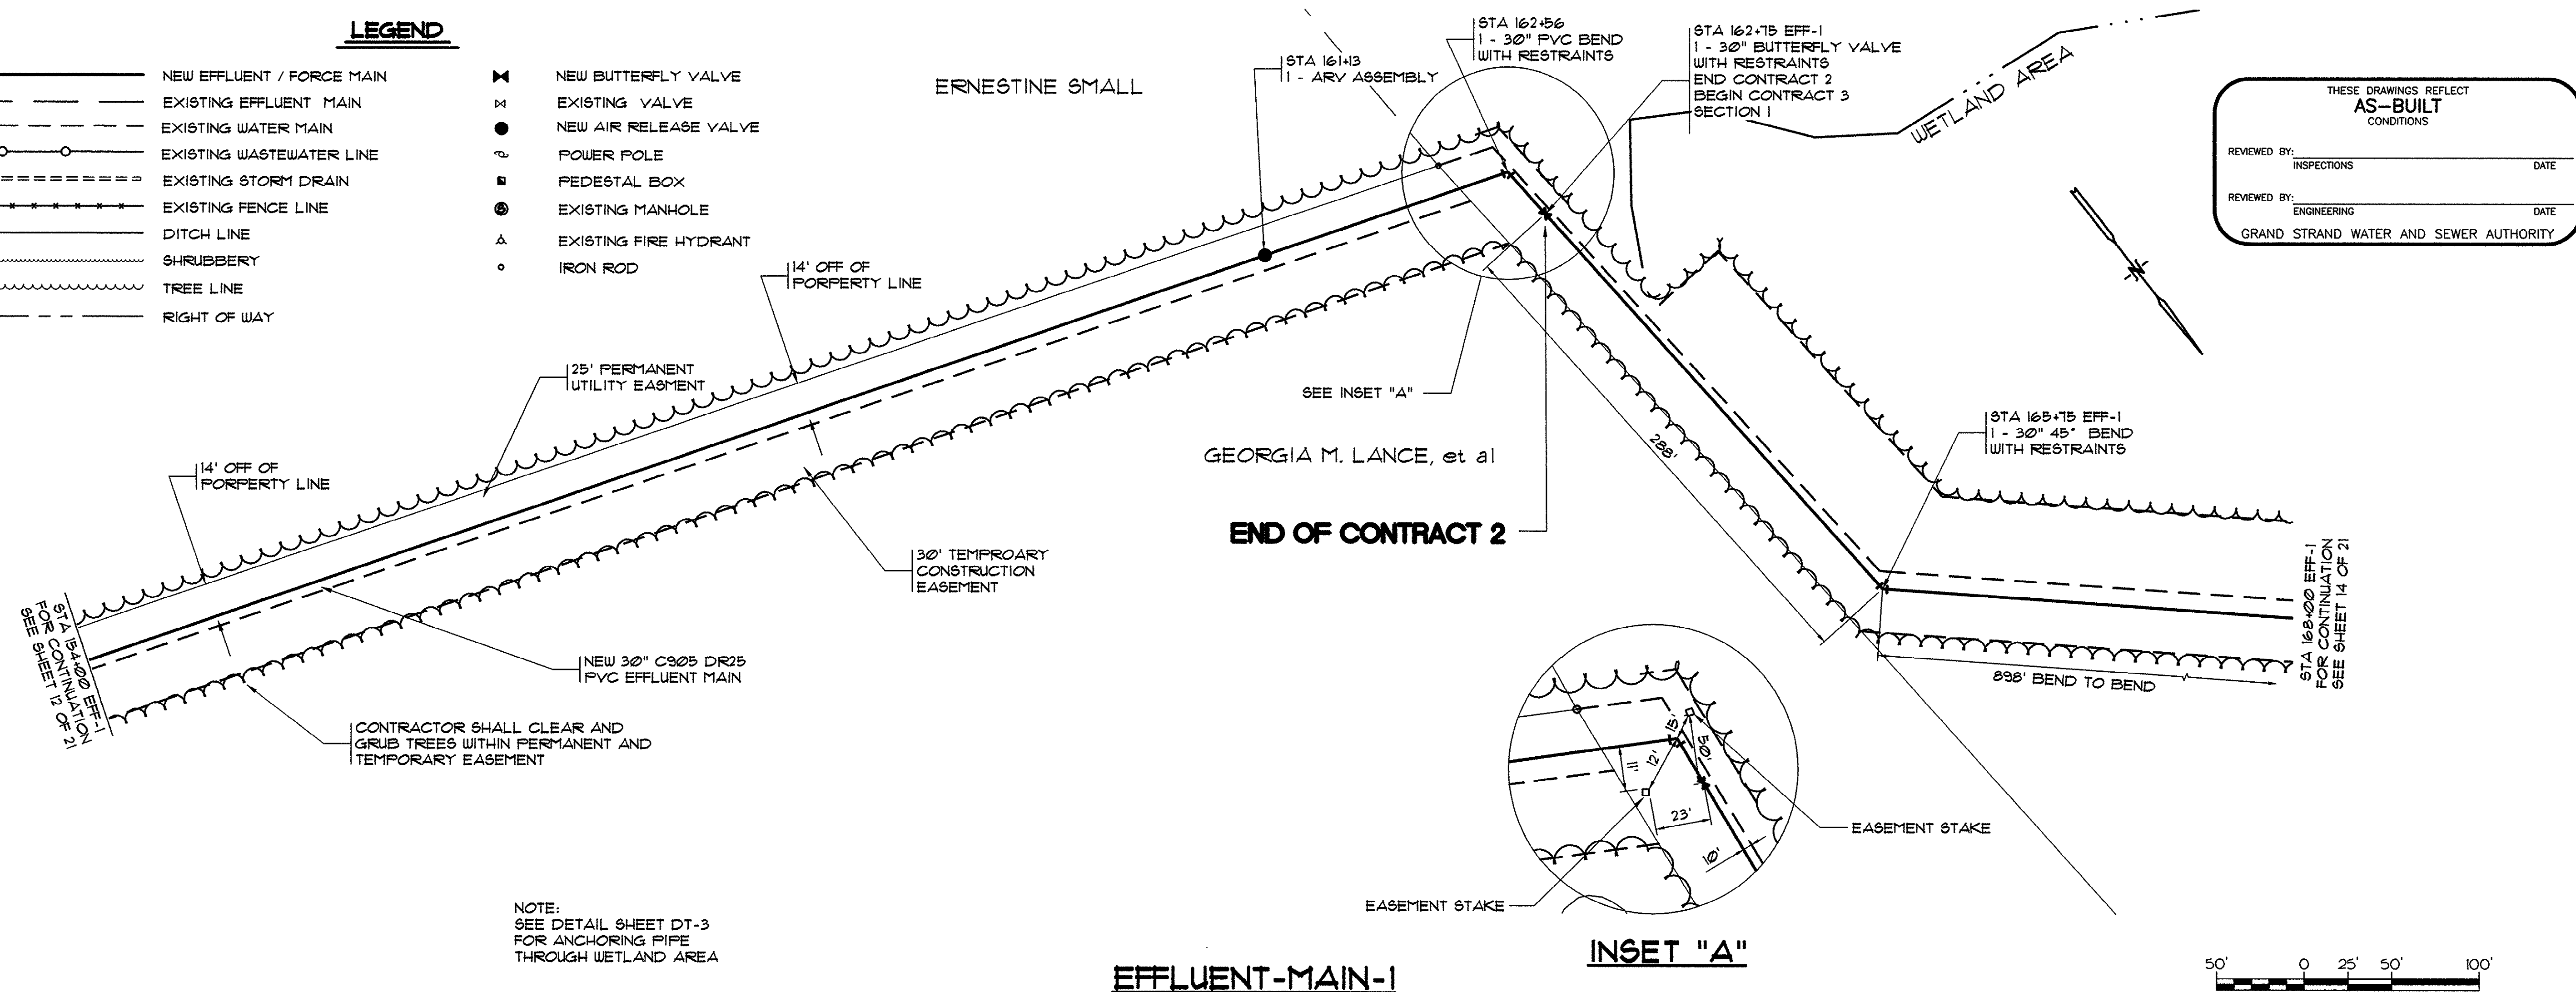


THESE DRAWINGS REFLECT
AS-BUILT
CONDITIONS

REVIEWED BY: _____ DATE: _____
INSPECTIONS

REVIEWED BY: _____ DATE: _____
ENGINEERING

GRAND STRAND WATER AND SEWER AUTHORITY

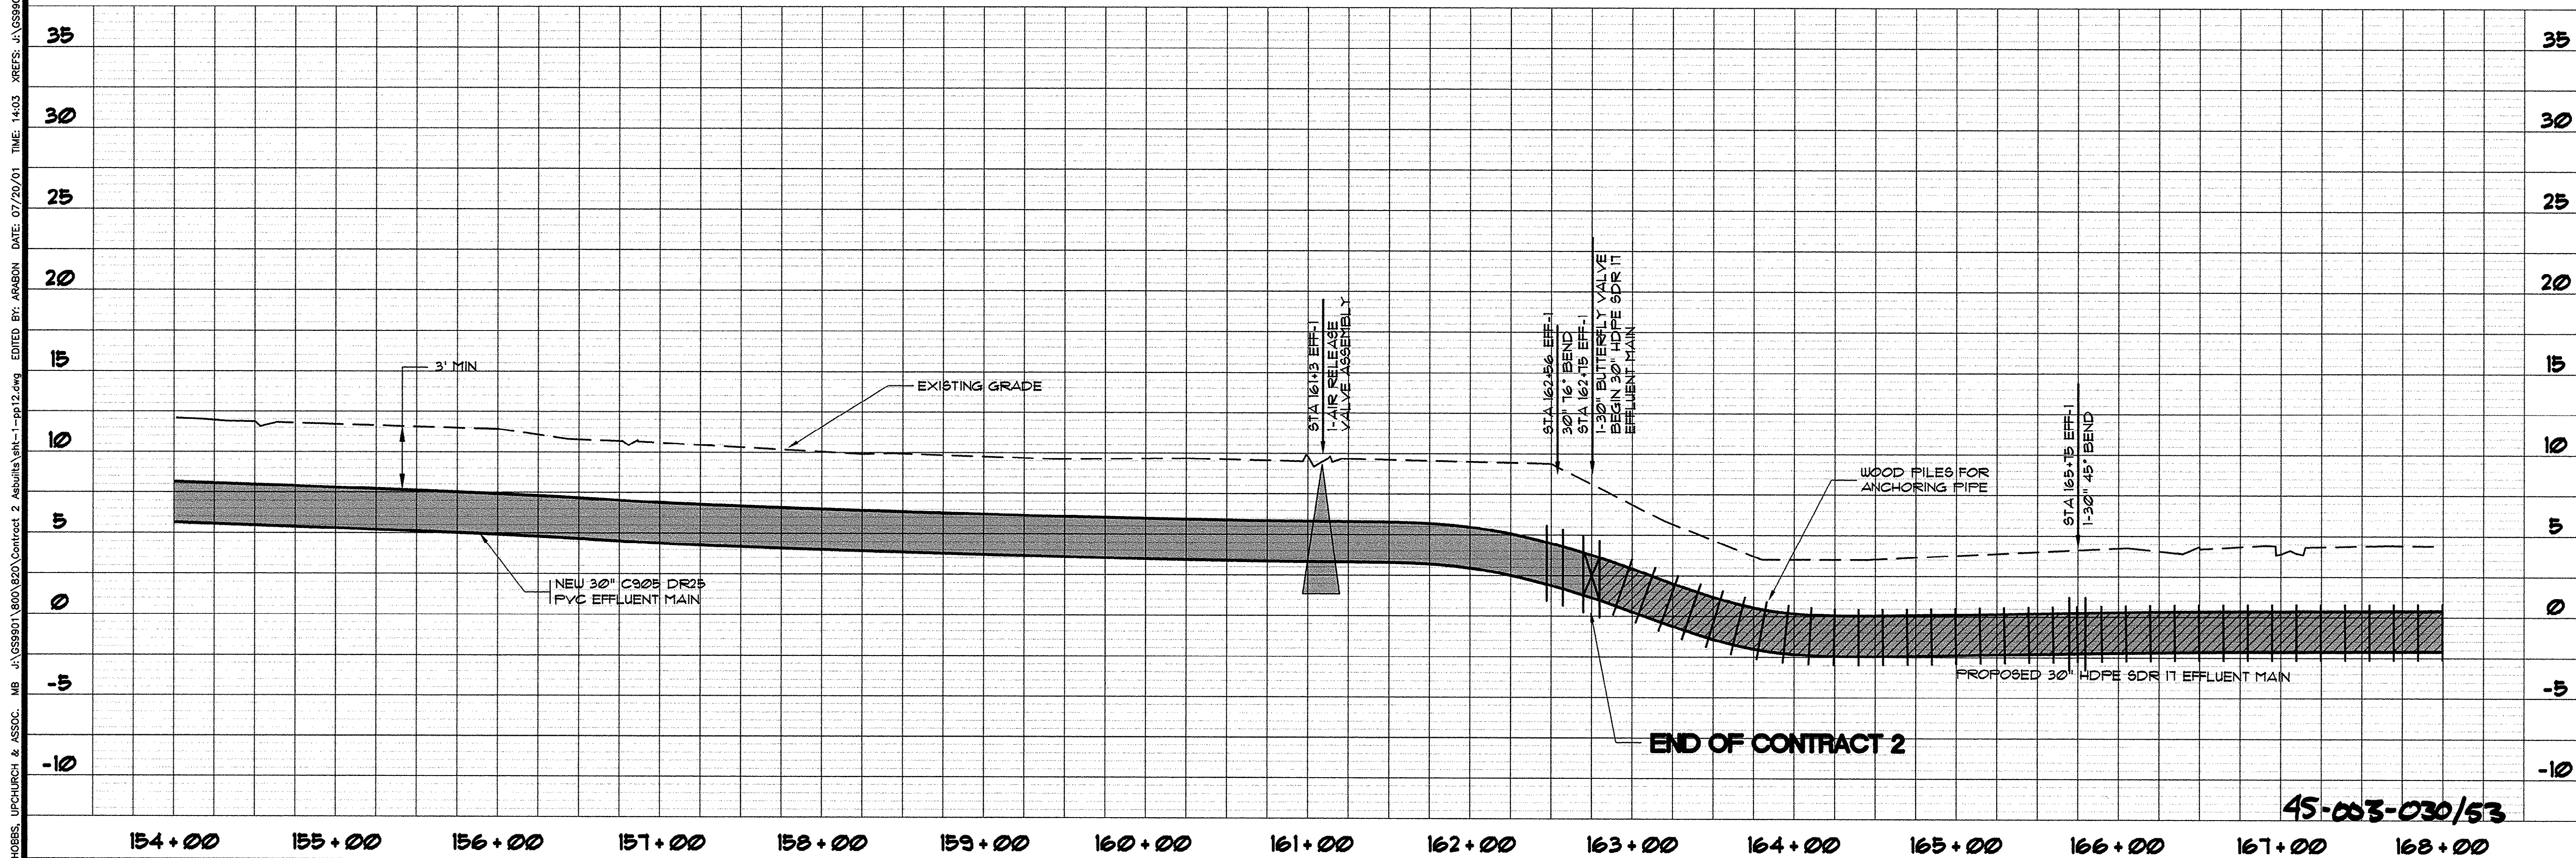

DATE	BY
9/8/99	KLM
12/6/00	ARM
7/20/01	CAR

REVISIONS

SYMBOL	DESCRIPTION	DATE
	PIPE ANCHORING NOTE	
	AS-BUILT	
	AS-BUILT	

PROFESSIONAL ENGINEER
SOUTH CAROLINA
No. 12335
REGISTERED
HOBBS, UPCHURCH & ASSOCIATES, P.A.
CONSULTING ENGINEERS
MYRTLE BEACH, SOUTH CAROLINA 29577



**TIP-TOP TREE FARM
EFFLUENT LAND
APPLICATION PROJECT**
GRAND STRAND WATER
AND SEWER AUTHORITY

PLAN AND PROFILE
EFFLUENT MAIN 1

DATE: MAR. 1999
DESIGNED: WDL
DRAWN: KLM
CHECKED: WDL
SCALE: AS SHOWN

SHEET NO.
EFF-13
21

HOBBS, UPCHURCH & ASSOC. INC. J:\CS9901\800\820\Contract 2\submittal\1-1-pp13.dwg EDITED BY: A9ABON DATE: 07/23/01 TIME: 08:41 XREFS: J:\CS9901\800\810\points.dwg Layout: Layout1

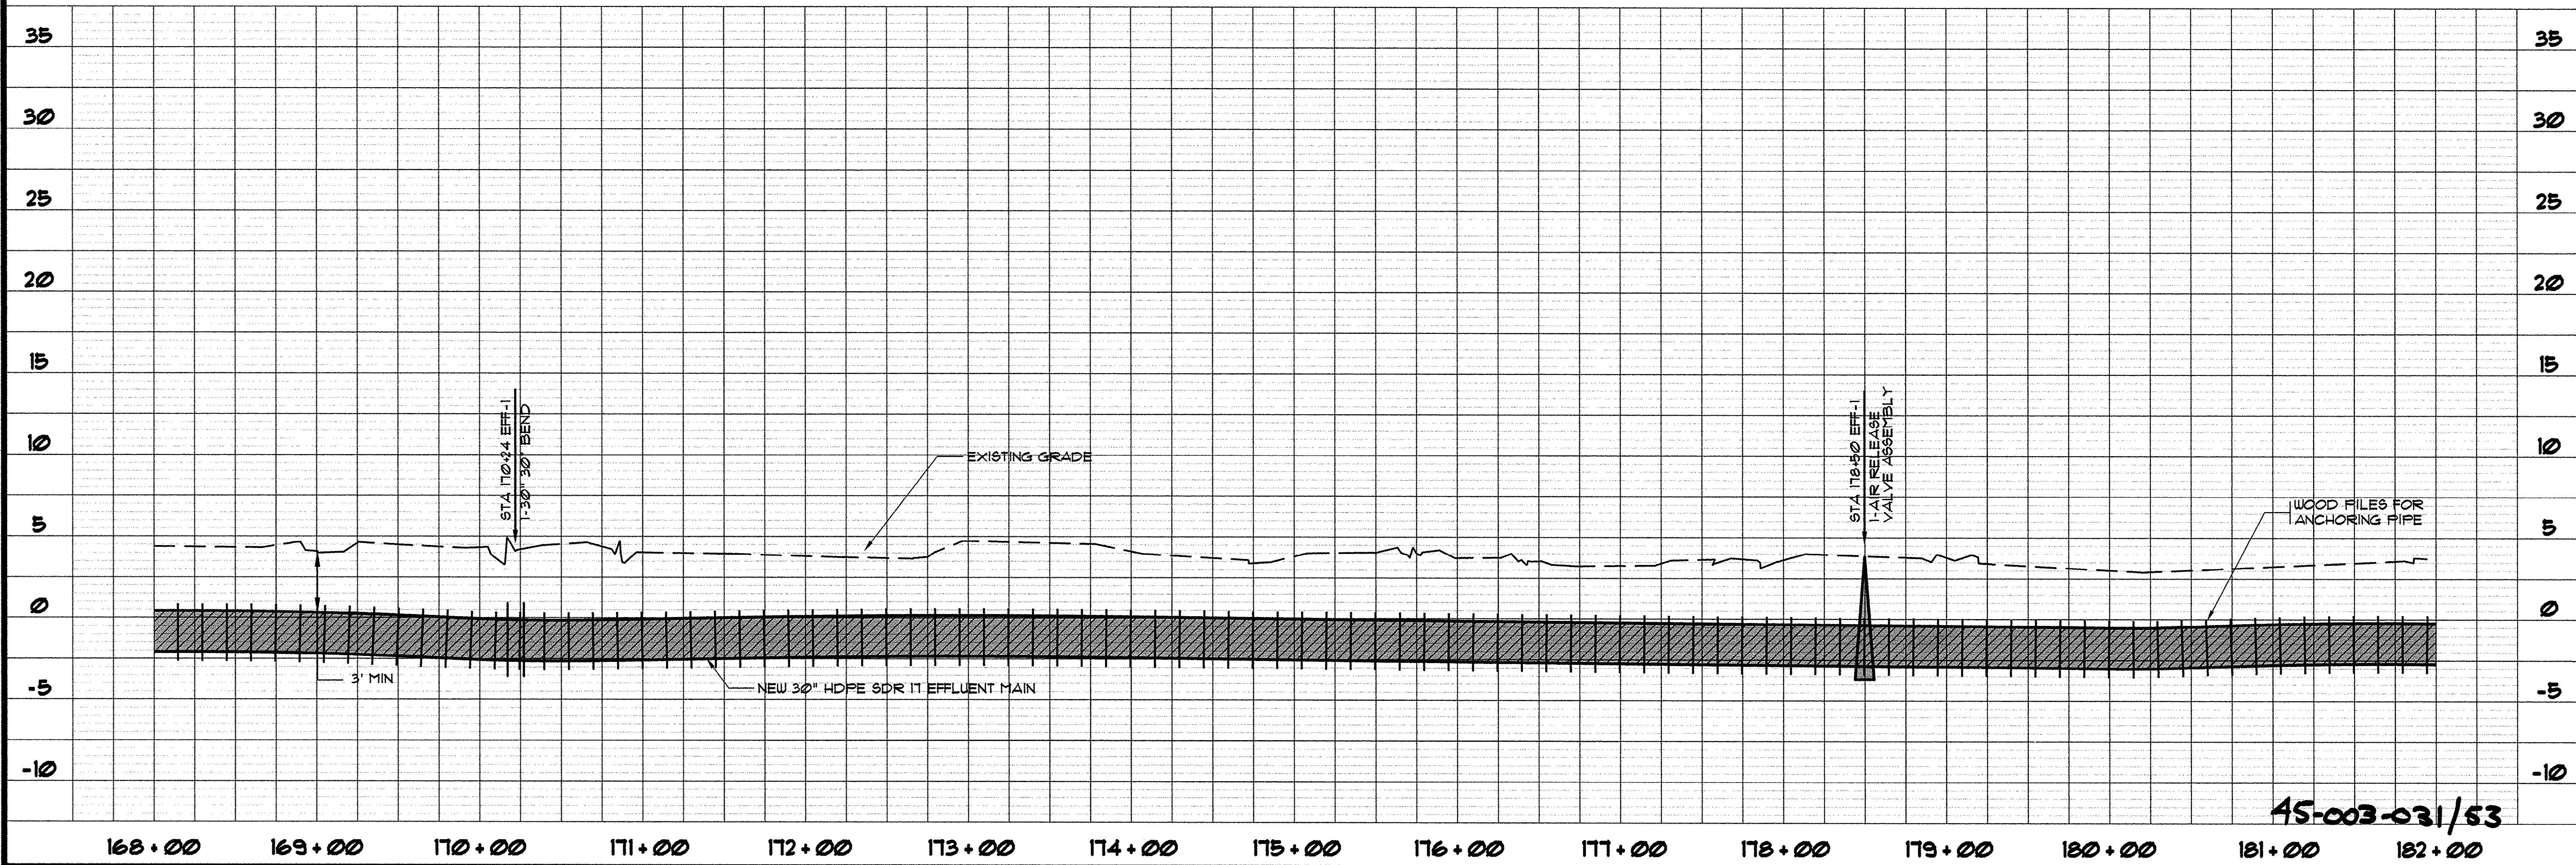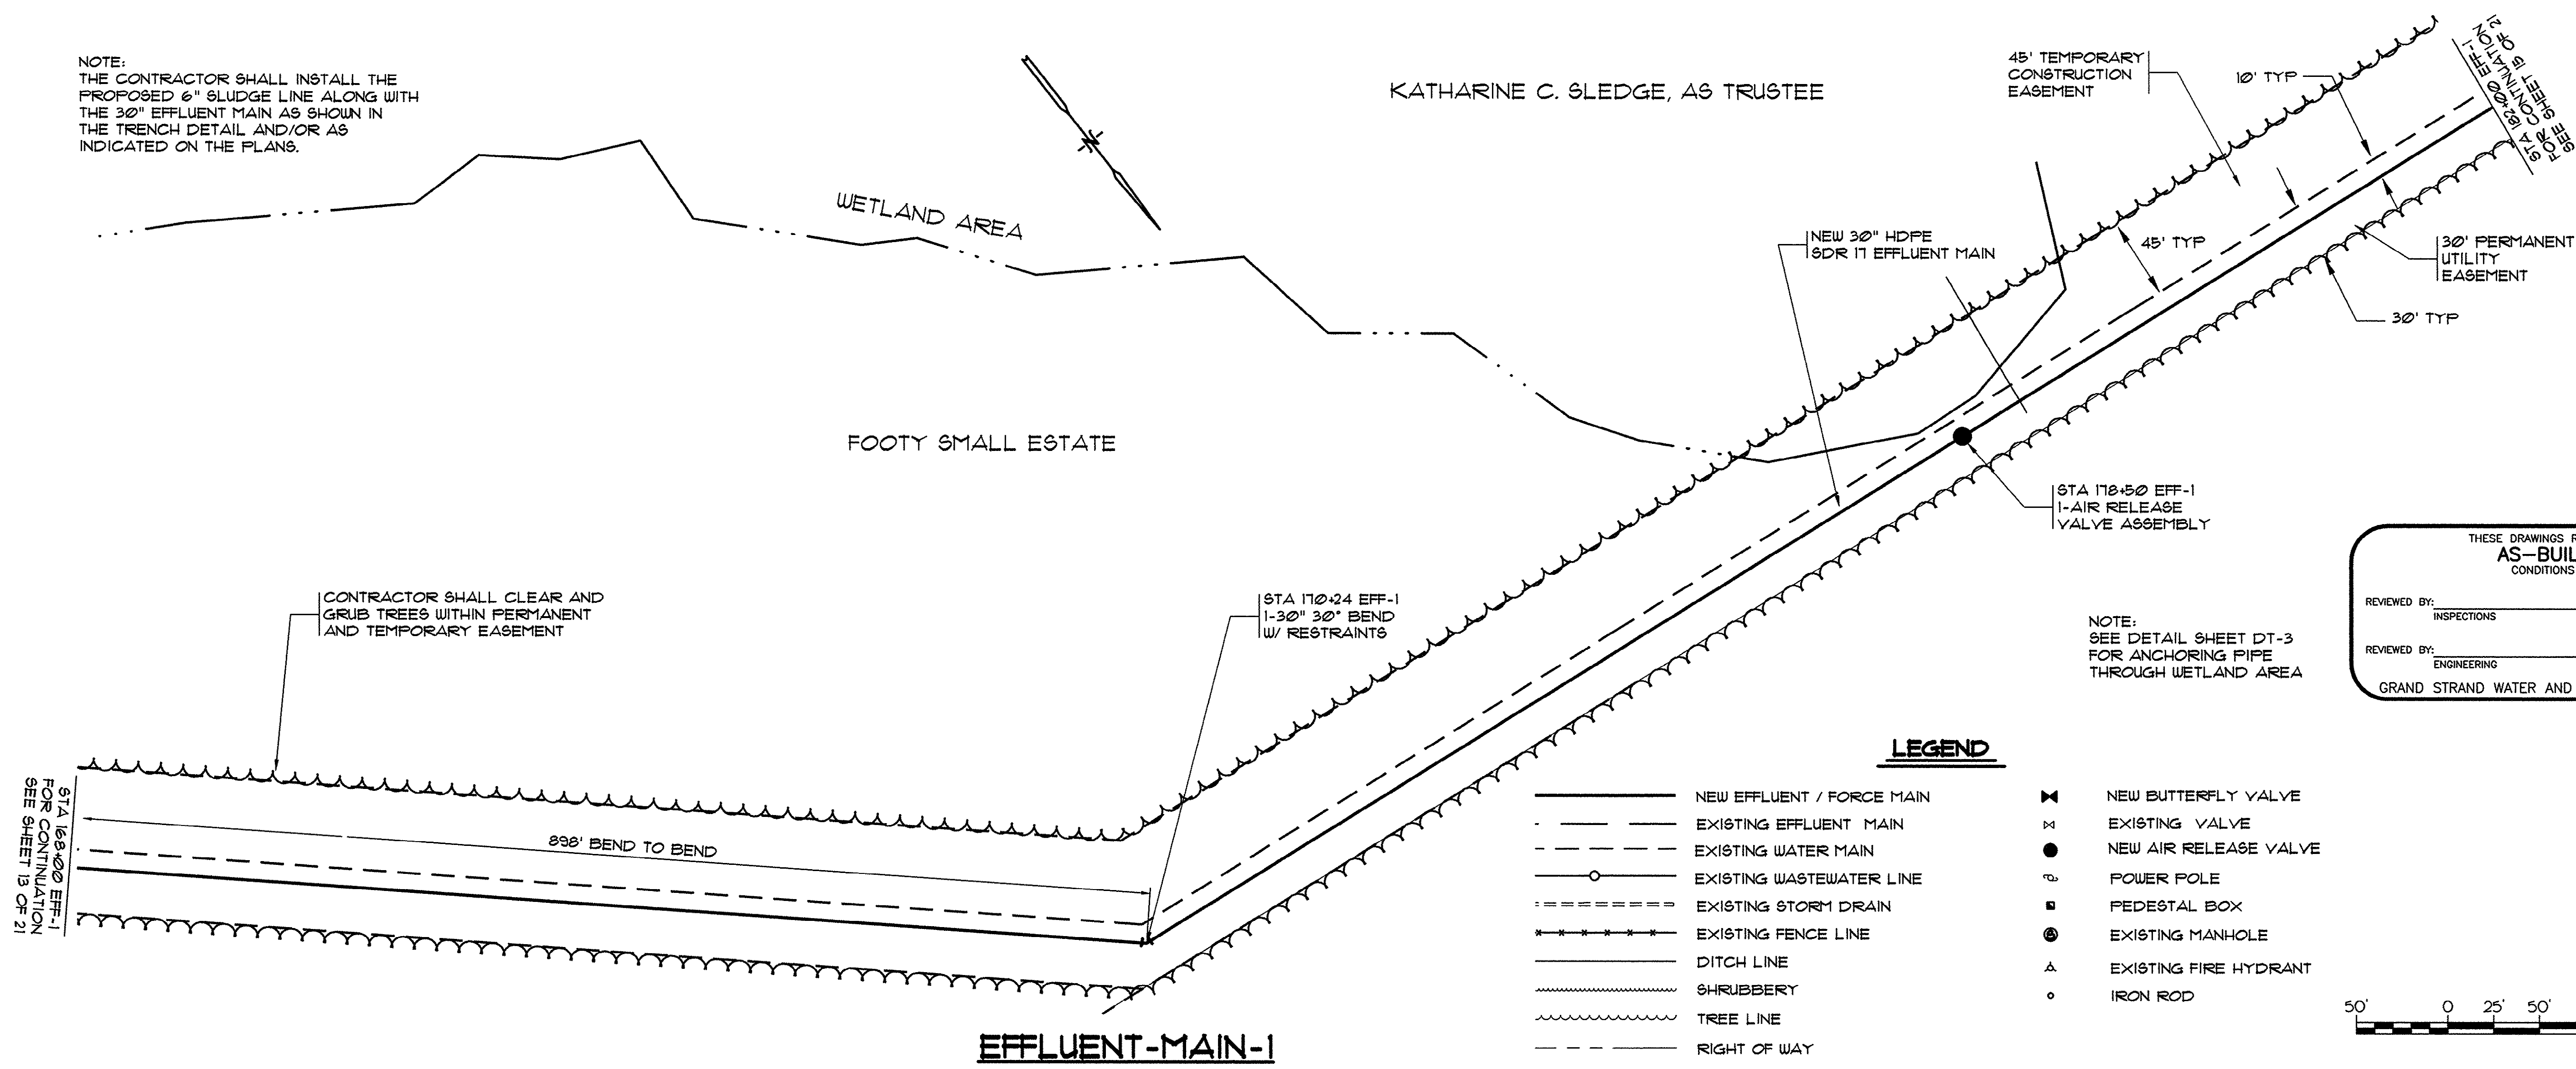


HOBBS, UPCHURCH & ASSOC. MB J:\GS9901\820\Contract 2 Asubilla\plan-1-pp14.dwg EDITED BY: ARABON DATE: 07/20/01 TIME: 16:18 XREFS: J:\GS9901\820\810\prints.dwg Layout Layout

NOTE:
THE CONTRACTOR SHALL INSTALL THE
PROPOSED 6" SLUDGE LINE ALONG WITH
THE 30" EFFLUENT MAIN AS SHOWN IN
THE TRENCH DETAIL AND/OR AS
INDICATED ON THE PLANS.

THESE DRAWINGS REFLECT AS-BUILT CONDITIONS	
REVIEWED BY: _____	DATE: _____
INSPECTIONS	
REVIEWED BY: _____	DATE: _____
ENGINEERING	
GRAND STRAND WATER AND SEWER AUTHORITY	

KATHARINE C. SLEDGE, AS TRUSTEE


CONTRACTOR SHALL CLEAR AND
GRUB TREES WITHIN PERMANENT
AND TEMPORARY EASEMENT

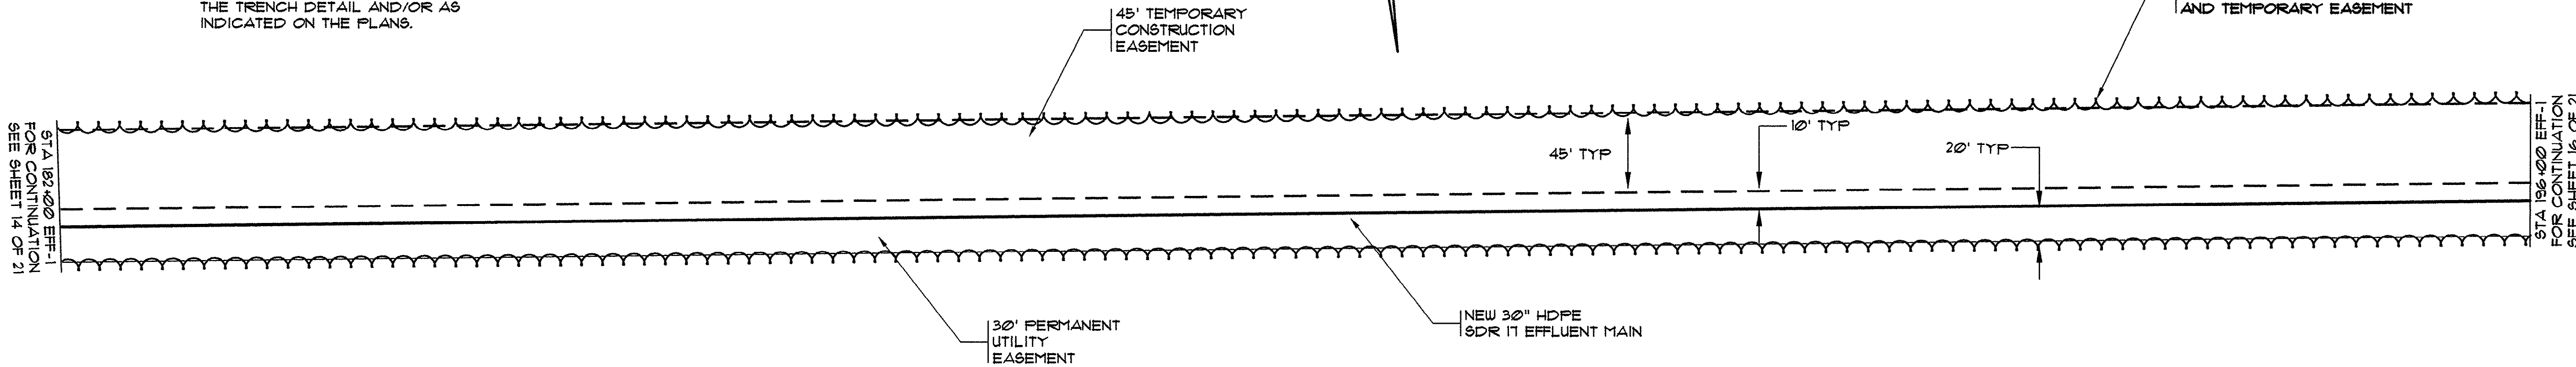


NOTE:
SEE DETAIL SHEET DT-3
FOR ANCHORING PIPE
THROUGH WETLAND AREA

LEGEND

- | | | | |
|---------------|---------------------------|---|-----------------------|
| — | NEW EFFLUENT / FORCE MAIN | ✕ | NEW BUTTERFLY VALVE |
| - - - | EXISTING EFFLUENT MAIN | ✕ | EXISTING VALVE |
| - - - | EXISTING WATER MAIN | ● | NEW AIR RELEASE VALVE |
| —○—○— | EXISTING WASTEWATER LINE | ⊙ | POWER POLE |
| ===== | EXISTING STORM DRAIN | ■ | PEDESTAL BOX |
| - * - * - * - | EXISTING FENCE LINE | ⊙ | EXISTING MANHOLE |
| — | DITCH LINE | △ | EXISTING FIRE HYDRANT |
| ~~~~~ | SHRUBBERY | ○ | IRON ROD |
| ~~~~~ | TREE LINE | | |
| - - - - - | RIGHT OF WAY | | |

 


EFFLUENT-MAIN-1

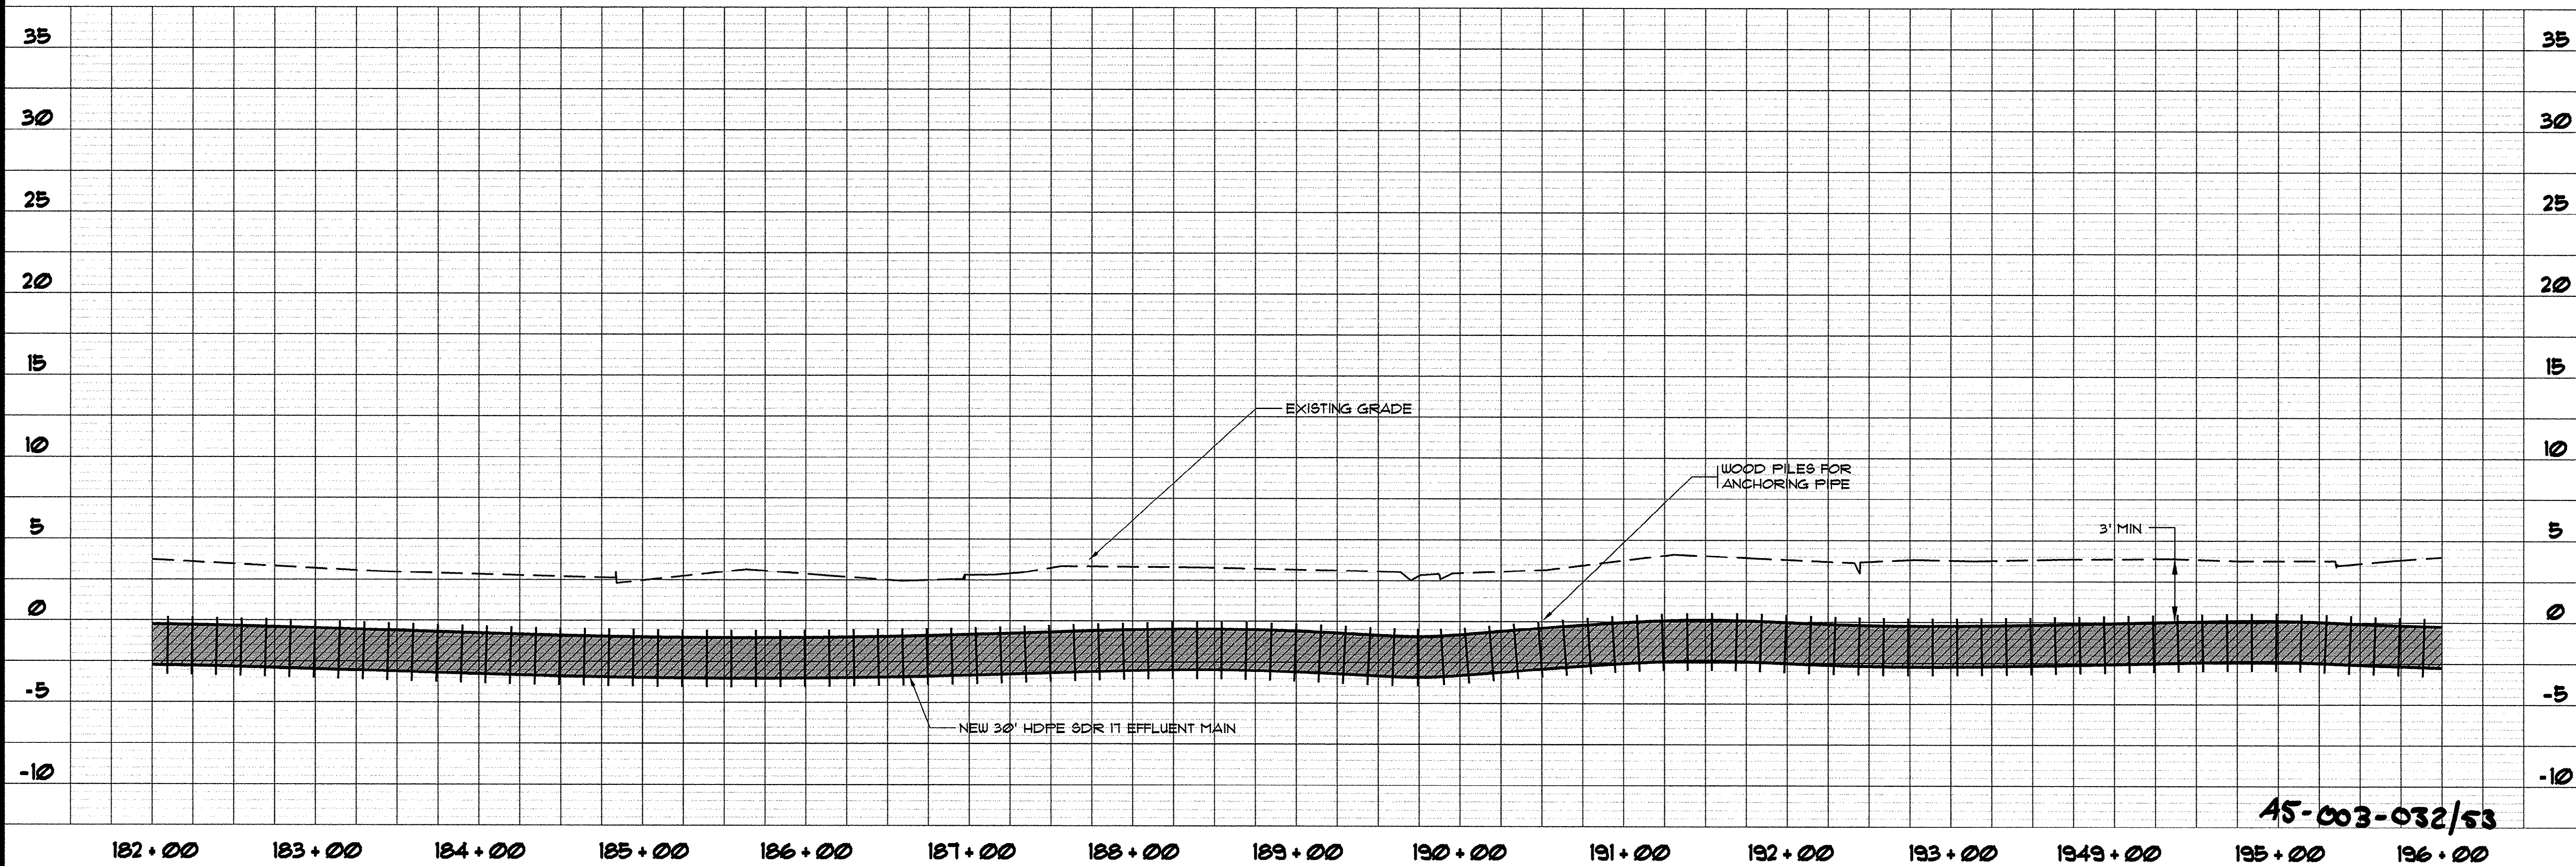

45-003-032/53

SYMBOL	DESCRIPTION	DATE	BY
	PIPE ANCHORING NOTE	9/9/99	KLM
	AS-BUILT	7/20/01	CAR

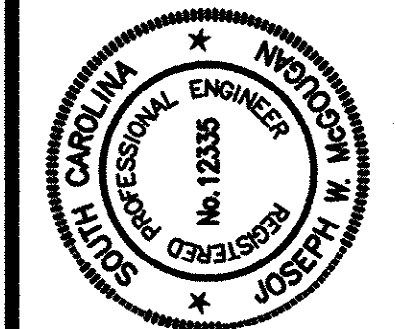

HOBBS, UPCHURCH & ASSOCIATES, P.A.
CONSULTING ENGINEERS
MYRTLE BEACH, SOUTH CAROLINA 29577



PLAN AND PROFILE
EFFLUENT MAIN 1

TIP-TOP TREE FARM
EFFLUENT LAND
APPLICATION PROJECT
GRAND STRAND WATER
AND SEWER AUTHORITY


DATE:	MAR. 1999
DESIGNED:	WDL
DRAWN:	KLM
CHECKED:	WDL
SCALE:	AS SHOWN

SHEET NO.
EFF-15
OF: 21

J:\GS9901\800\820\Contract 2 As-built\ah-1-pp15.dwg EDITED BY: ARABON DATE: 07/20/01 TIME: 16:21 XREFS: J:\GS9901\800\810\pains.dwg Layout: Layout1

NOTE:
THE CONTRACTOR SHALL INSTALL THE
PROPOSED 6" SLUDGE LINE ALONG WITH
THE 30" EFFLUENT MAIN AS SHOWN IN
THE TRENCH DETAIL AND/OR AS
INDICATED ON THE PLANS.

KATHARINE SLEDGE, AS TRUSTEE

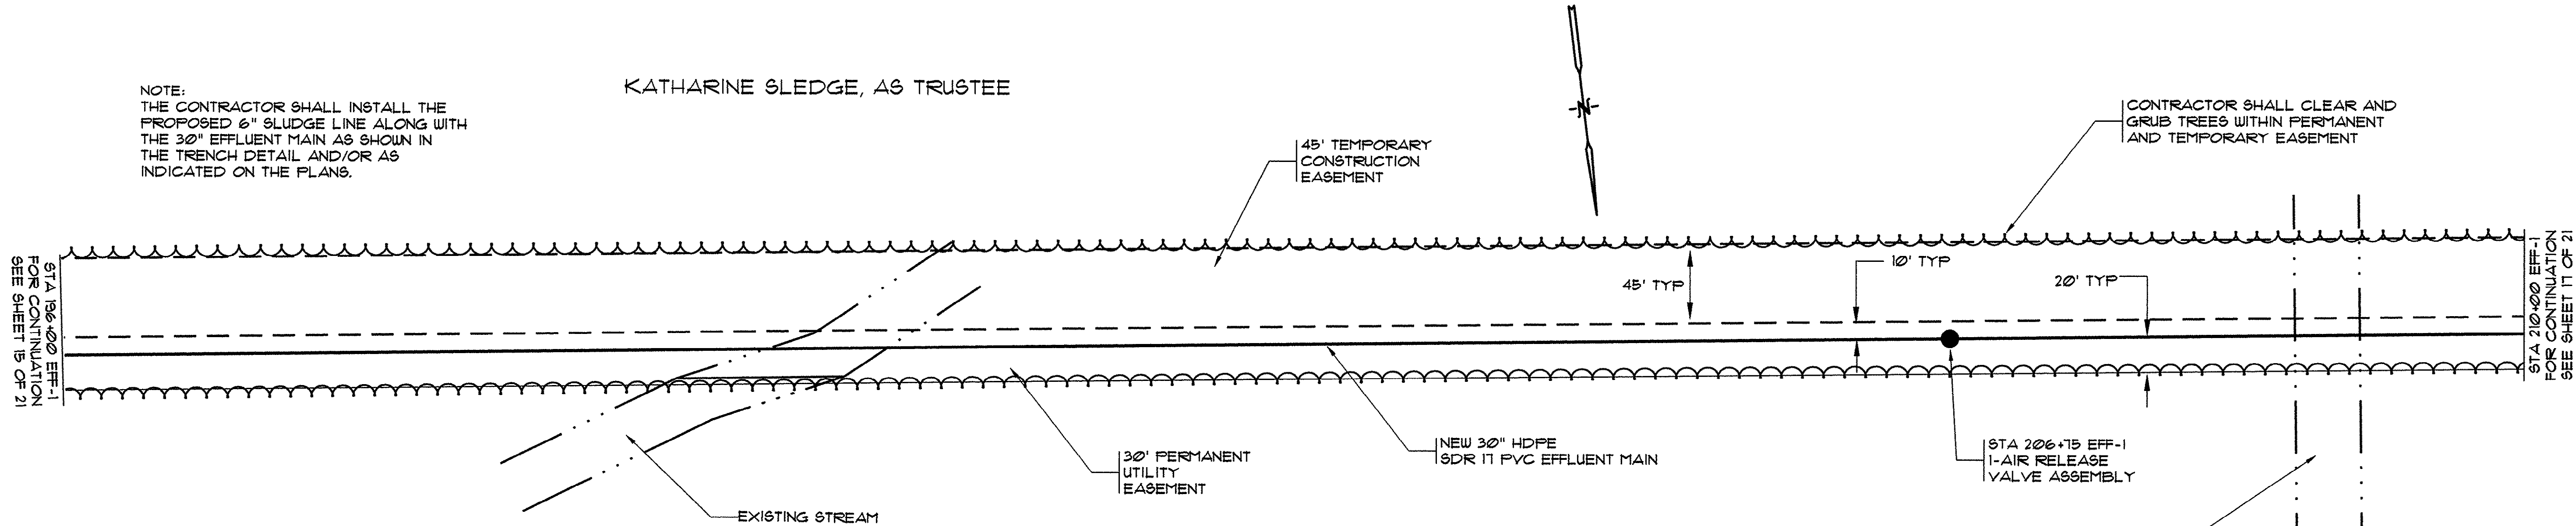


NOTE:
SEE DETAIL SHEET DT-3
FOR ANCHORING PIPE
THROUGH WETLAND AREA


THESE DRAWINGS REFLECT AS-BUILT CONDITIONS	
REVIEWED BY:	DATE
INSPECTIONS	
REVIEWED BY:	DATE
ENGINEERING	
GRAND STRAND WATER AND SEWER AUTHORITY	

FOOTY SMALL ESTATE

- LEGEND**
- | | | | |
|-----------|---------------------------|---|-----------------------|
| — | NEW EFFLUENT / FORCE MAIN | ✕ | NEW BUTTERFLY VALVE |
| - - - | EXISTING EFFLUENT MAIN | ✕ | EXISTING VALVE |
| - - - | EXISTING WATER MAIN | ● | NEW AIR RELEASE VALVE |
| -○- | EXISTING WASTEWATER LINE | ⋈ | POWER POLE |
| - - - - - | EXISTING STORM DRAIN | ■ | PEDESTAL BOX |
| - * * * * | EXISTING FENCE LINE | ⊙ | EXISTING MANHOLE |
| - - - - - | DITCH LINE | △ | EXISTING FIRE HYDRANT |
| ~~~~~ | SHRUBBERY | ○ | IRON ROD |
| ~~~~~ | TREE LINE | | |
| - - - - - | RIGHT OF WAY | | |

 

EFFLUENT-MAIN-1

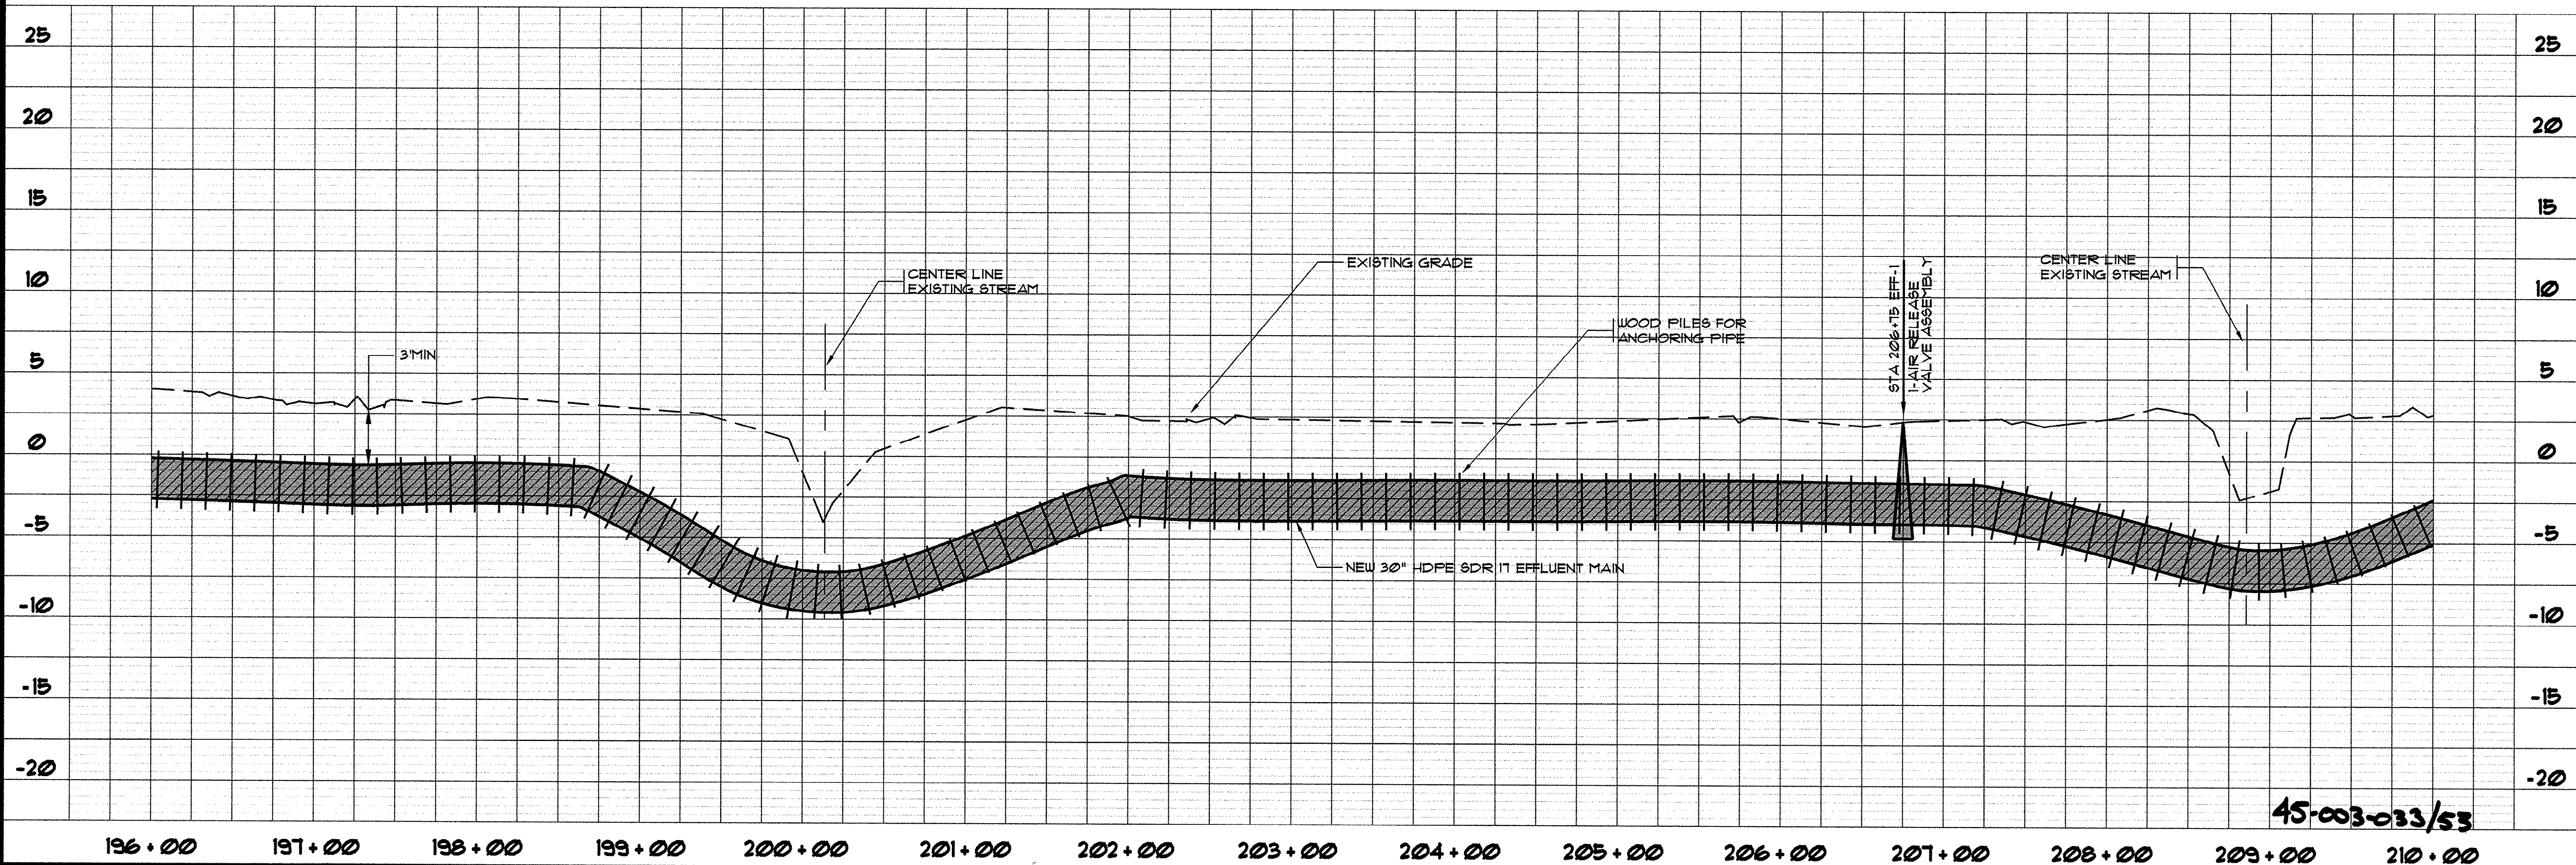

45-003-033/53

SYN.	DATE	BY
PIPE ANCHORING	9/8/99	KLM
AS-BUILT	7/20/01	CAR

REVISIONS

DESCRIPTION	DATE	BY
PIPE ANCHORING	9/8/99	KLM
AS-BUILT	7/20/01	CAR

HOBBBS, UPCHURCH & ASSOCIATES, P.A.
CONSULTING ENGINEERS
MYRTLE BEACH, SOUTH CAROLINA 29577

**PLAN AND PROFILE
EFFLUENT MAIN 1**

**TIP-TOP TREE FARM
EFFLUENT LAND
APPLICATION PROJECT**
GRAND STRAND WATER
AND SEWER AUTHORITY


DATE:	MAR. 1999
DESIGNED:	WDL
DRAWN:	KLM
CHECKED:	WDL
SCALE:	AS SHOWN

SHEET NO.

EFF-16

OF: 21

J:\GS9901\800\820\Contract 2 Asulita\eff-1-pp16.dwg EDITED BY: A2ABON DATE: 07/22/01 TIME: 09:08 XREFS: J:\GS9901\800\810\points.dwg Layout: layout1

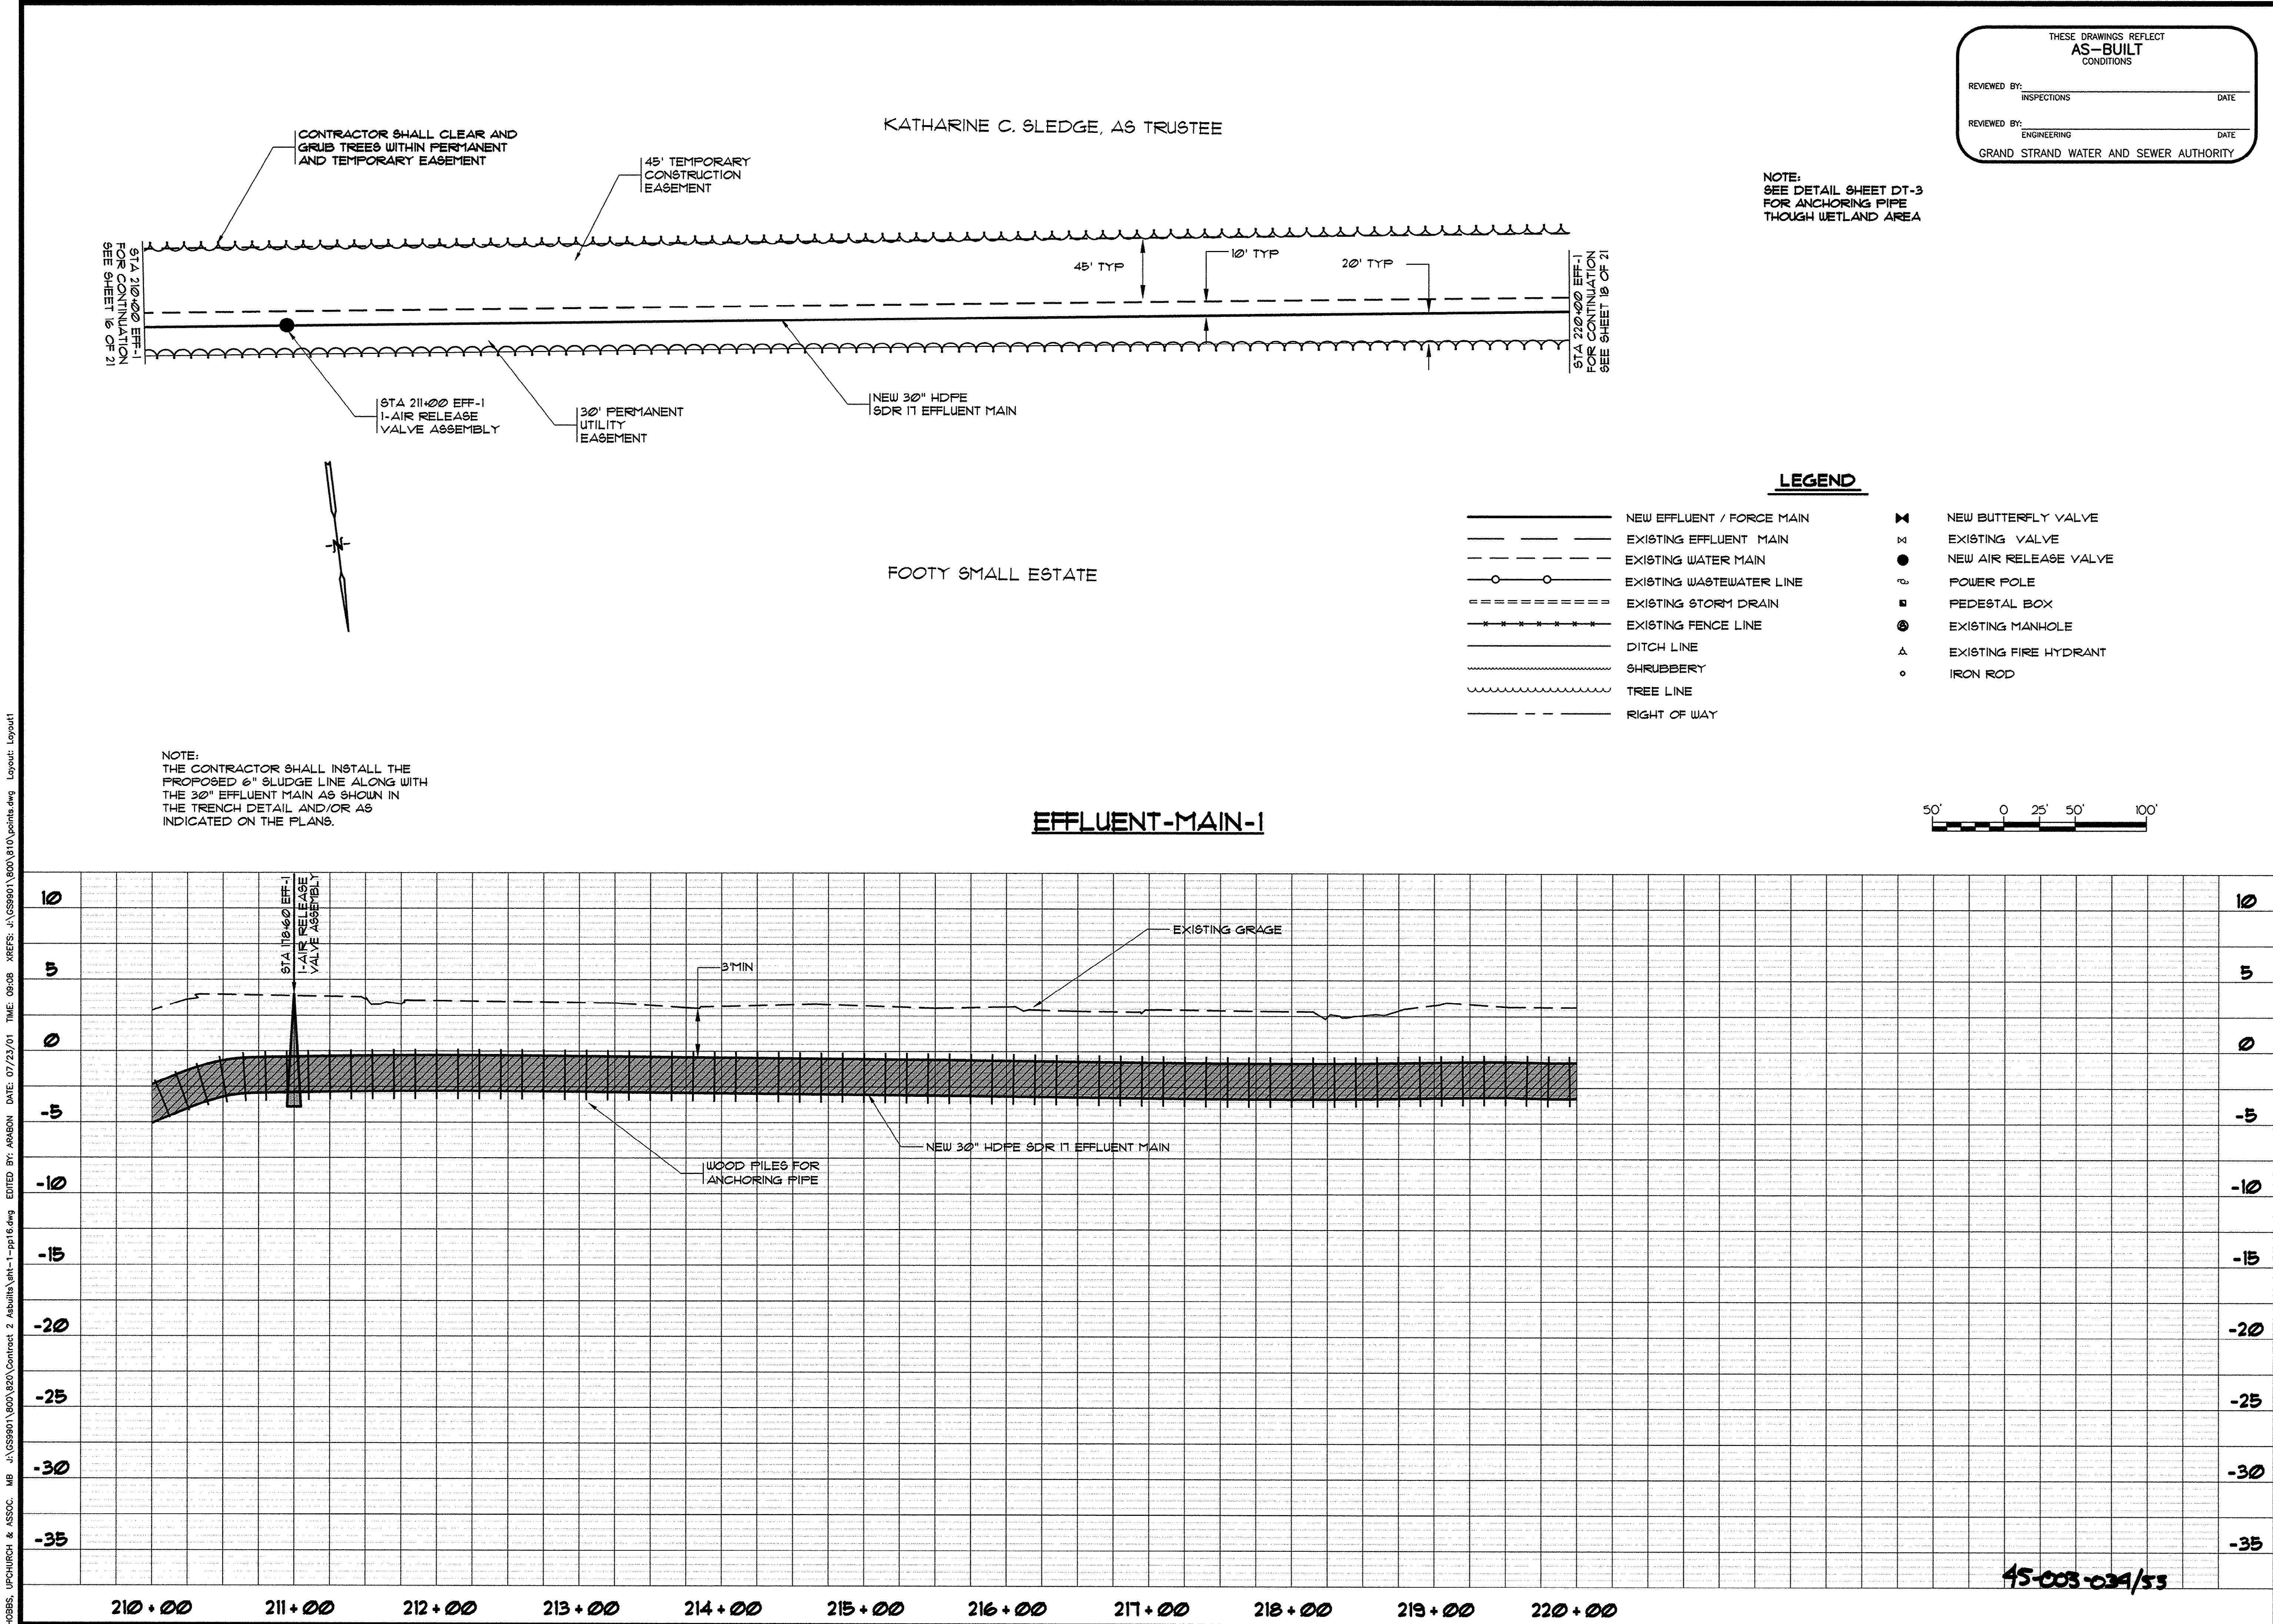


THESE DRAWINGS REFLECT
AS-BUILT
CONDITIONS

REVIEWED BY: _____ DATE: _____
INSPECTIONS

REVIEWED BY: _____ DATE: _____
ENGINEERING

GRAND STRAND WATER AND SEWER AUTHORITY

REV. NO.	DESCRIPTION	DATE	BY
1	PIPE ANCHORING NOTE	9/9/99	KLM
2	AS-BUILT	7/29/01	CAC

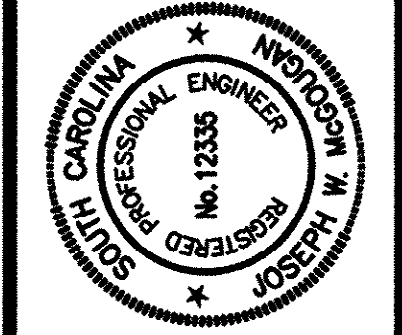

HOBBS, UPCHURCH & ASSOCIATES, P.A.
CONSULTING ENGINEERS
MYRTLE BEACH, SOUTH CAROLINA 29577

PLAN AND PROFILE
EFFLUENT MAIN 1

TIP-TOP TREE FARM
EFFLUENT LAND
APPLICATION PROJECT
GRAND STRAND WATER AND SEWER AUTHORITY

DATE: MAR. 1999
DESIGNED: WDL
DRAWN: KLM
CHECKED: WDL
SCALE: AS SHOWN

SHEET NO. **EFF-17**
OF 21

HOBBS, UPCHURCH & ASSOC. MB J:\GS9901\800\820\Contract 2 As-built\eff-1-pp17.dwg EDITED BY: APARON DATE: 07/20/01 TIME: 16:25 XREFS: J:\GS9901\800\810\plan.dwg Layout: Layout1

CONTRACTOR SHALL CLEAR AND GRUB TREES WITHIN PERMANENT AND TEMPORARY EASEMENT

STA 220+00 EFF-1
FOR CONTINUATION
SEE SHEET 17 OF 21

STA 221+00 EFF-1
END CONTRACT 3 SECTION 1
BEGIN CONTRACT 3 SECTION 2

STA 220+50 EFF-1
1-AIR RELEASE
VALVE ASSEMBLY

EDGE OF WACCAMAW
RIVER

NOTE:
SEE DETAIL SHEET DT-3
FOR ANCHORING PIPE
THROUGH WETLAND AREA

NOTE:
THE CONTRACTOR SHALL INSTALL THE
PROPOSED 6" SLUDGE LINE ALONG WITH
THE 30" EFFLUENT MAIN AS SHOWN IN
THE TRENCH DETAIL AND/OR AS
INDICATED ON THE PLANS.

STA 228+50 EFF-1
END SECTION 2 CONTRACT 3
BEGIN SECTION 3 CONTRACT 3

CLEAR AND GRUB
TREES AS NECESSARY
FOR INSTALLATION OF PIPE


STA 229+00 EFF-1
1-AIR RELEASE
VALVE ASSEMBLY

NEW 30" HDPE
SDR 11 EFFLUENT MAIN


STA 234+00 EFF-1
FOR CONTINUATION
SEE SHEET 18 OF 21

LEGEND

- | | | | |
|---------------|---------------------------|---|-----------------------|
| ————— | NEW EFFLUENT / FORCE MAIN | ✕ | NEW BUTTERFLY VALVE |
| — — — — — | EXISTING EFFLUENT MAIN | ✕ | EXISTING VALVE |
| — — — — — | EXISTING WATER MAIN | ● | NEW AIR RELEASE VALVE |
| — ○ — ○ — | EXISTING WASTEWATER LINE | ⌘ | POWER POLE |
| ===== | EXISTING STORM DRAIN | ■ | PEDESTAL BOX |
| - * - * - * - | EXISTING FENCE LINE | ⊙ | EXISTING MANHOLE |
| ————— | DITCH LINE | △ | EXISTING FIRE HYDRANT |
| ————— | SHRUBBERY | ○ | IRON ROD |
| ~~~~~ | TREE LINE | | |
| - - - - - | RIGHT OF WAY | | |

 

EFFLUENT-MAIN-1

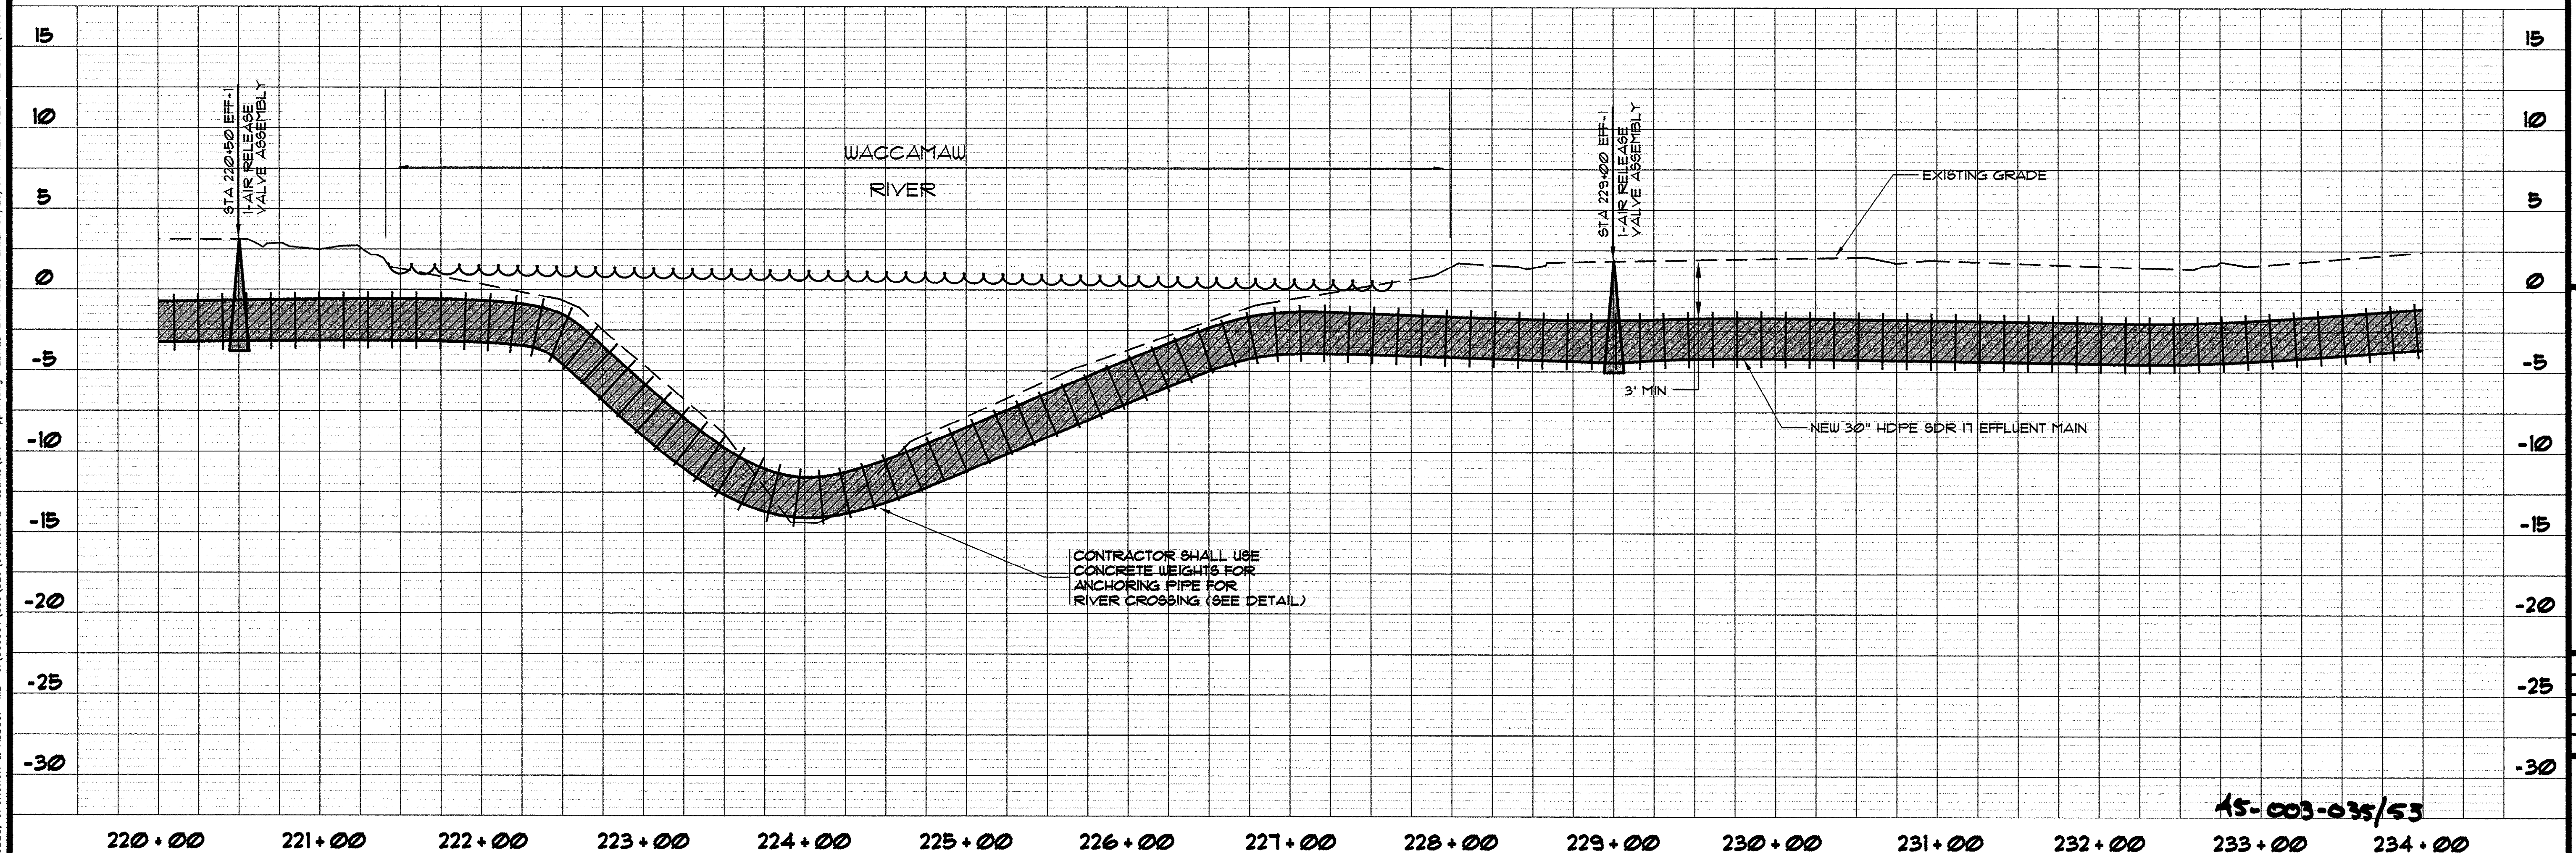

15-003-035/53


THESE DRAWINGS REFLECT
AS-BUILT
CONDITIONS

REVIEWED BY:	INSPECTIONS	DATE
REVIEWED BY:	ENGINEERING	DATE


GRAND STRAND WATER AND SEWER AUTHORITY

REVISIONS

SYMBOL	DESCRIPTION	DATE	BY
	PIPE ANCHORING NOTE	9/6/99	KLM
	BUTTERFLY VALVES DELETED	9/20/99	KLM
	AS-BUILT	7/20/01	CAR

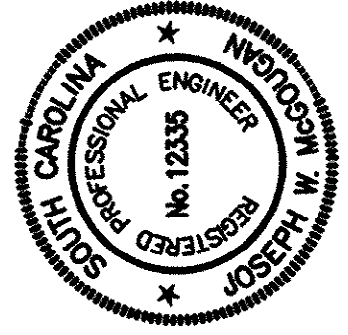

HOBBS, UPCHURCH & ASSOCIATES, P.A.
CONSULTING ENGINEERS
MYRTLE BEACH, SOUTH CAROLINA 29577

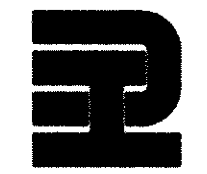

PLAN AND PROFILE
EFFLUENT MAIN 1

TIP-TOP TREE FARM
EFFLUENT LAND
APPLICATION PROJECT
GRAND STRAND WATER
AND SEWER AUTHORITY

DATE: MAR. 1999
DESIGNED: WDL
DRAWN: KLM
CHECKED: WDL
SCALE: AS SHOWN

SHEET NO.

EFF-18

OF 21

HOBBS, UPCHURCH & ASSOC. MB J:\CS9901\800\820\Contract 2\Adm\18\SRF-1-PP18.dwg EDITED BY: ARABON DATE: 07/20/01 TIME: 16:27 XREFS: J:\CS9901\800\810\points.dwg Layout: Layout1

STA 234+00 EFF-1
FOR CONTINUATION
SEE SHEET 18 OF 21

CLEAR AND GRUB
TREES AS NECESSARY FOR
INSTALLATION OF PIPE

EDGE OF SWAMP

NEW 30" HDPE
SDR 11 EFFLUENT MAIN

STA 245+15 EFF-1
END 30" HDPE SDR 11
BEGIN 30" C905 DR25
END SECTION 3 CONTRACT 3
BEGIN CONTRACT 5
1-30" BUTTERFLY VALVE
WITH RESTRAINTS

STA 248+00 EFF-1
FOR CONTINUATION
SEE SHEET 20 OF 21


NOTE:
SEE DETAIL SHEET DT-3
FOR ANCHORING PIPE
THROUGH WETLAND AREA

NOTE:
THE CONTRACTOR SHALL INSTALL THE
PROPOSED 6" SLUDGE LINE ALONG WITH
THE 30" EFFLUENT MAIN AS SHOWN IN
THE TRENCH DETAIL AND/OR AS
INDICATED ON THE PLANS.

LEGEND

—	NEW EFFLUENT / FORCE MAIN	✕	NEW BUTTERFLY VALVE
- - -	EXISTING EFFLUENT MAIN	✕	EXISTING VALVE
- - -	EXISTING WATER MAIN	●	NEW AIR RELEASE VALVE
○ — ○	EXISTING WASTEWATER LINE	⌘	POWER POLE
=====	EXISTING STORM DRAIN	■	PEDESTAL BOX
- * * * *	EXISTING FENCE LINE	⊙	EXISTING MANHOLE
- - -	DITCH LINE	△	EXISTING FIRE HYDRANT
~~~~~	SHRUBBERY	○	IRON ROD
~~~~~	TREE LINE		
- - -	RIGHT OF WAY		


EFFLUENT-MAIN-1

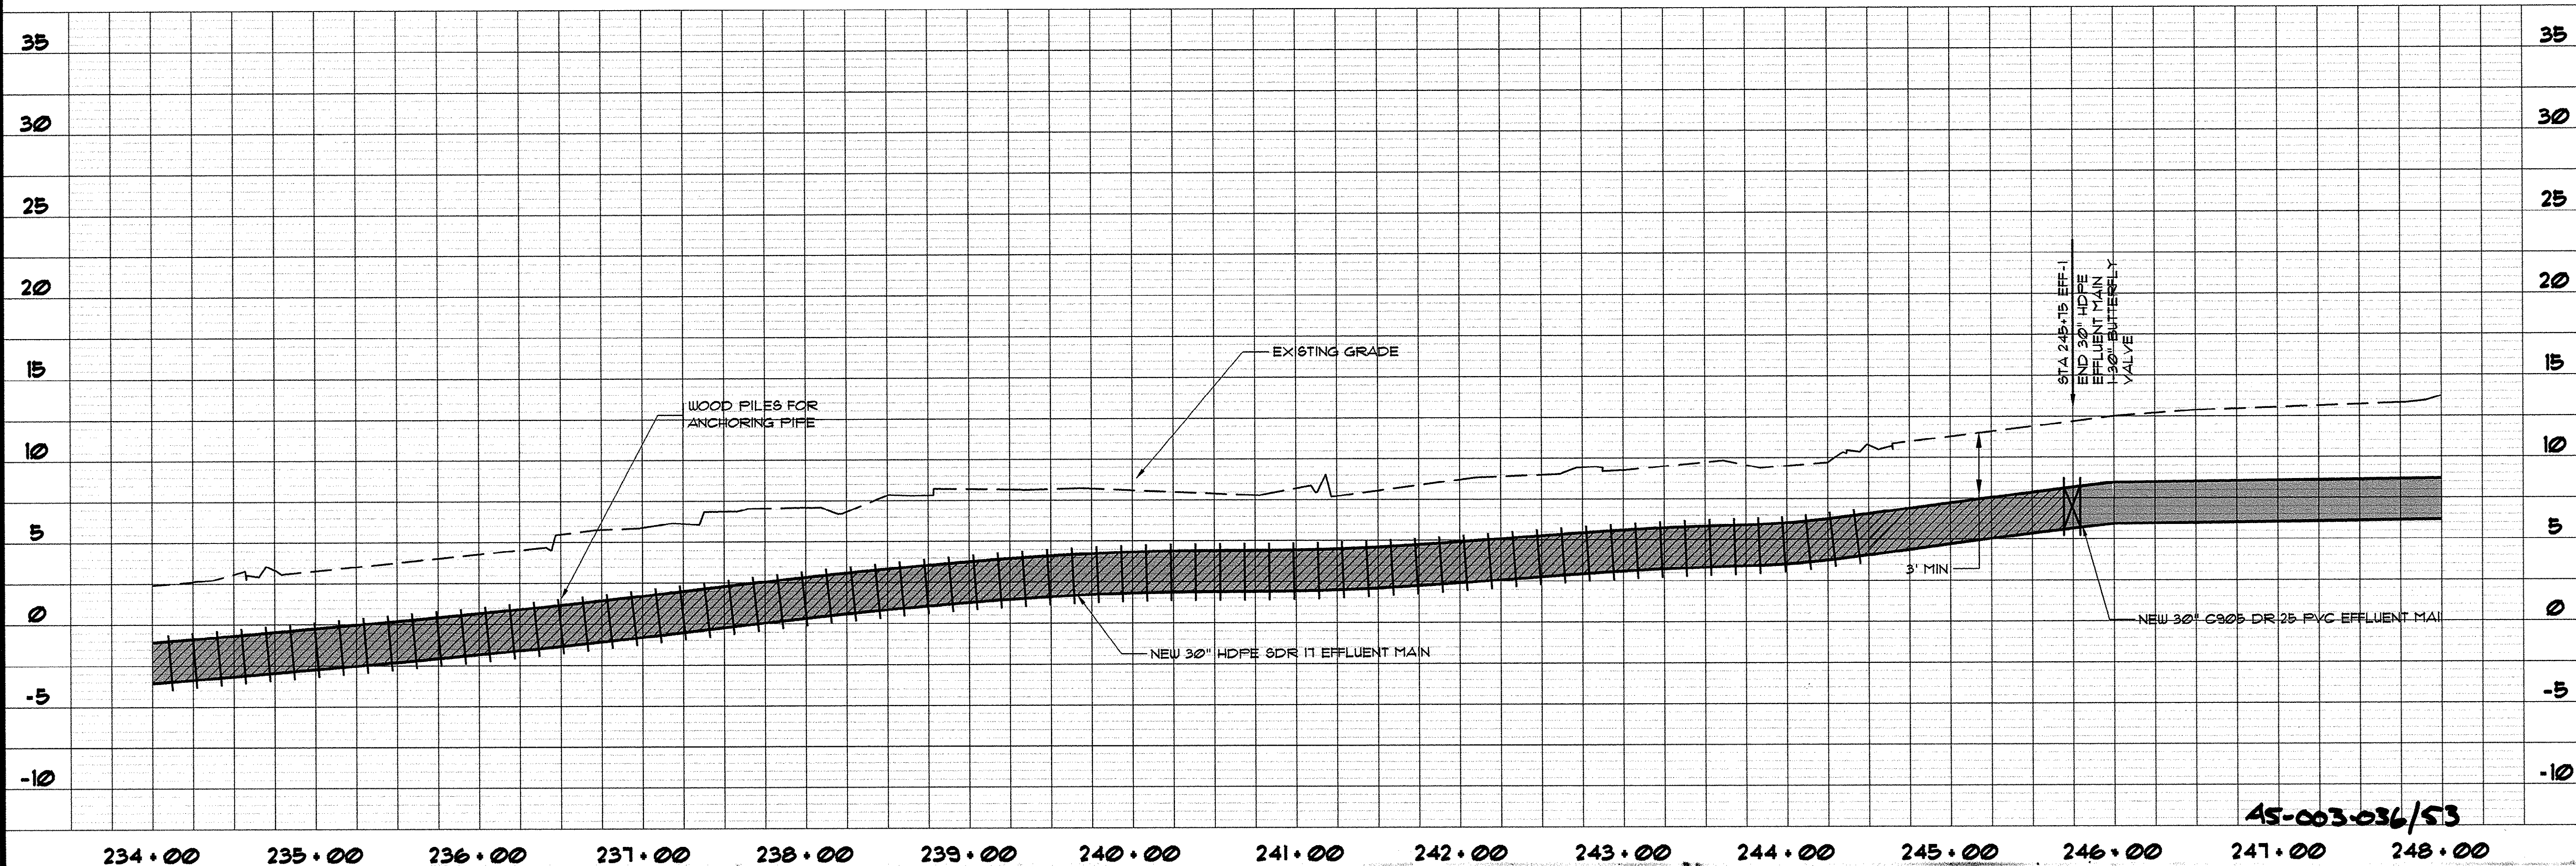


AS-003-036/S3

THESE DRAWINGS REFLECT AS-BUILT CONDITIONS	
REVIEWED BY: _____	DATE: _____
INSPECTIONS	
REVIEWED BY: _____	DATE: _____
ENGINEERING	
GRAND STRAND WATER AND SEWER AUTHORITY	

REVISIONS			
SYMBOL	DESCRIPTION	DATE	BY
	PIPE ANCHORING NOTE	9/8/99	KLM
	CONTRACT SECTION CHANGES	9/20/99	KLM
	AS-BUILT	7/20/01	CAR

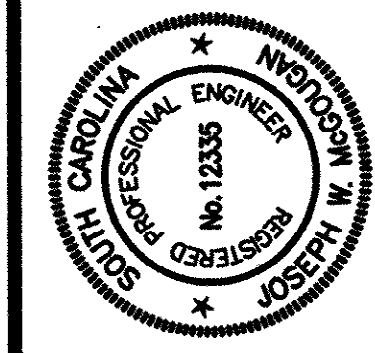

HOBBS, UPCHURCH & ASSOCIATES, P.A.
CONSULTING ENGINEERS
MYRTLE BEACH, SOUTH CAROLINA 29577

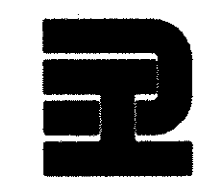

PLAN AND PROFILE
EFFLUENT MAIN 1

TIP-TOP TREE FARM
EFFLUENT LAND
APPLICATION PROJECT
GRAND STRAND WATER
AND SEWER AUTHORITY


DATE:	MAR. 1999
DESIGNED:	WDL
DRAWN:	KLM
CHECKED:	WDL
SCALE:	AS SHOWN

SHEET NO.


EFF-19

21

HOBBS, UPCHURCH & ASSOC. MB \\GSS901\800\820\Contract 2 Asbuilt\shl--ppt18.dwg EDITED BY: APABON DATE: 08/28/01 TIME: 13:18 XREFS: \\GSS901\800\810\pointa.dwg Layout: Layout1

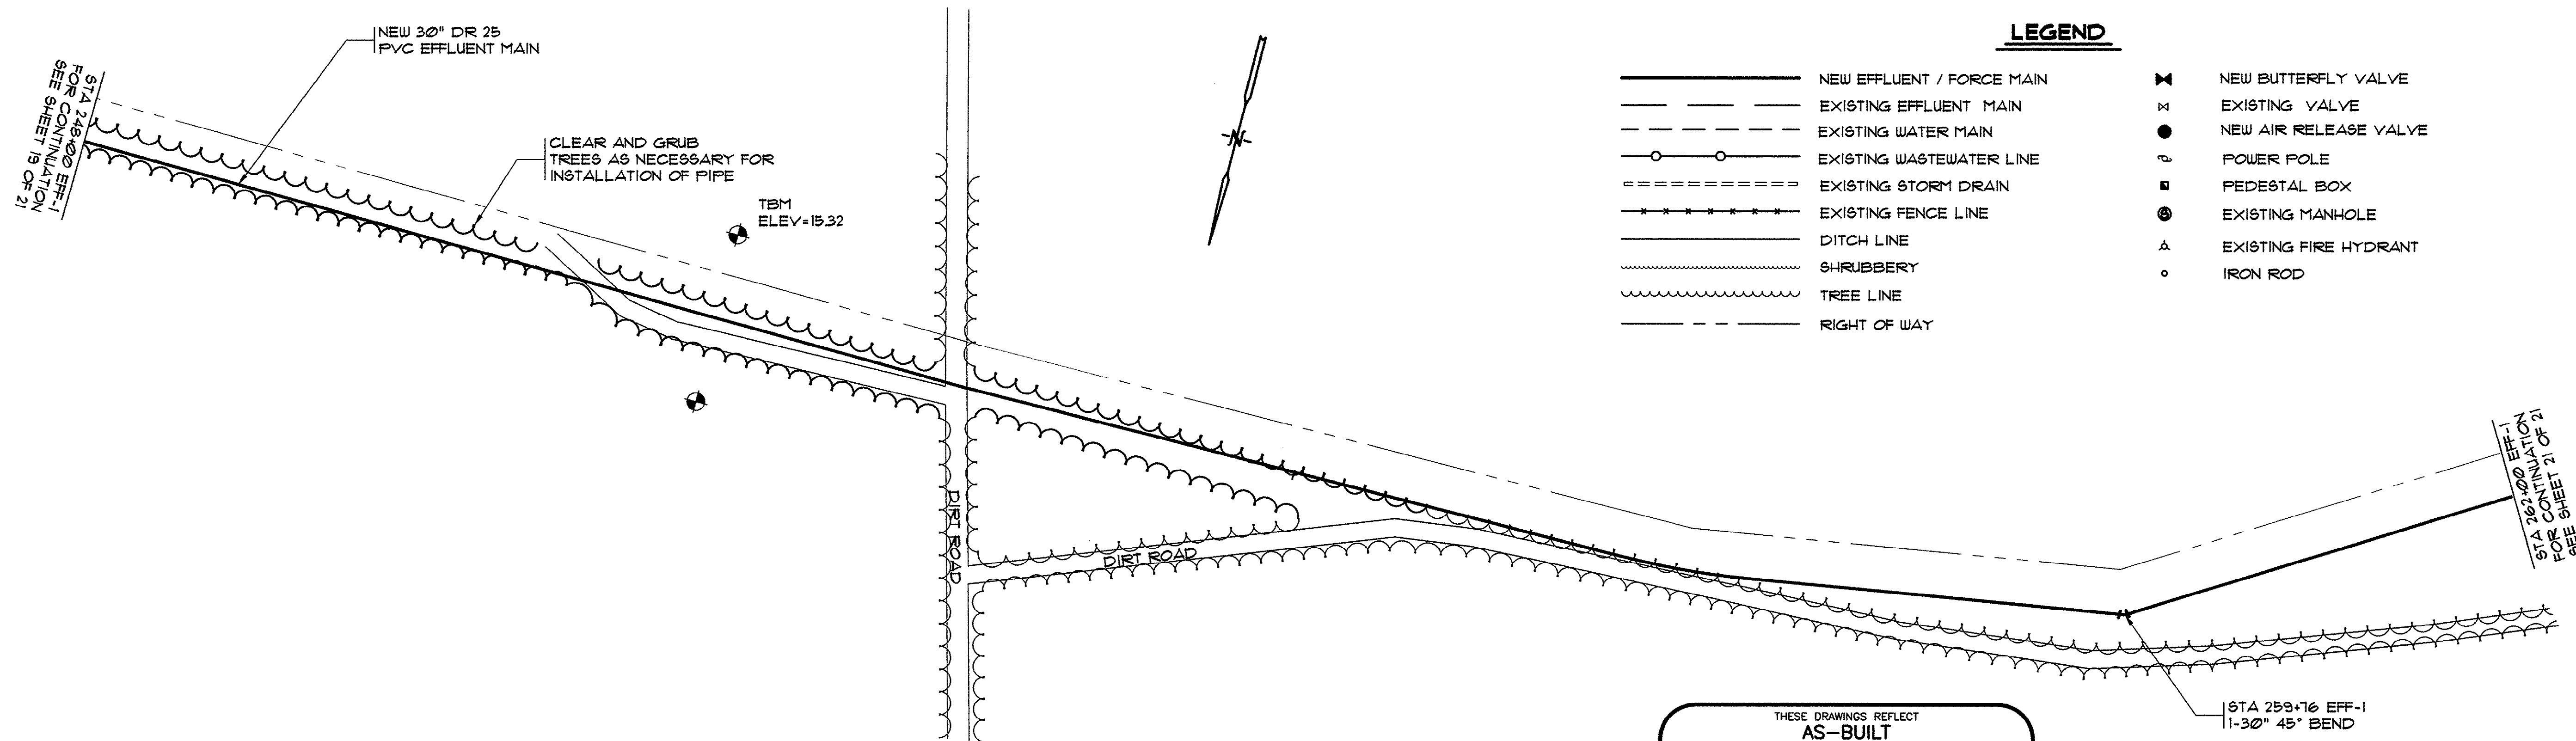


EFFLUENT-MAIN-1

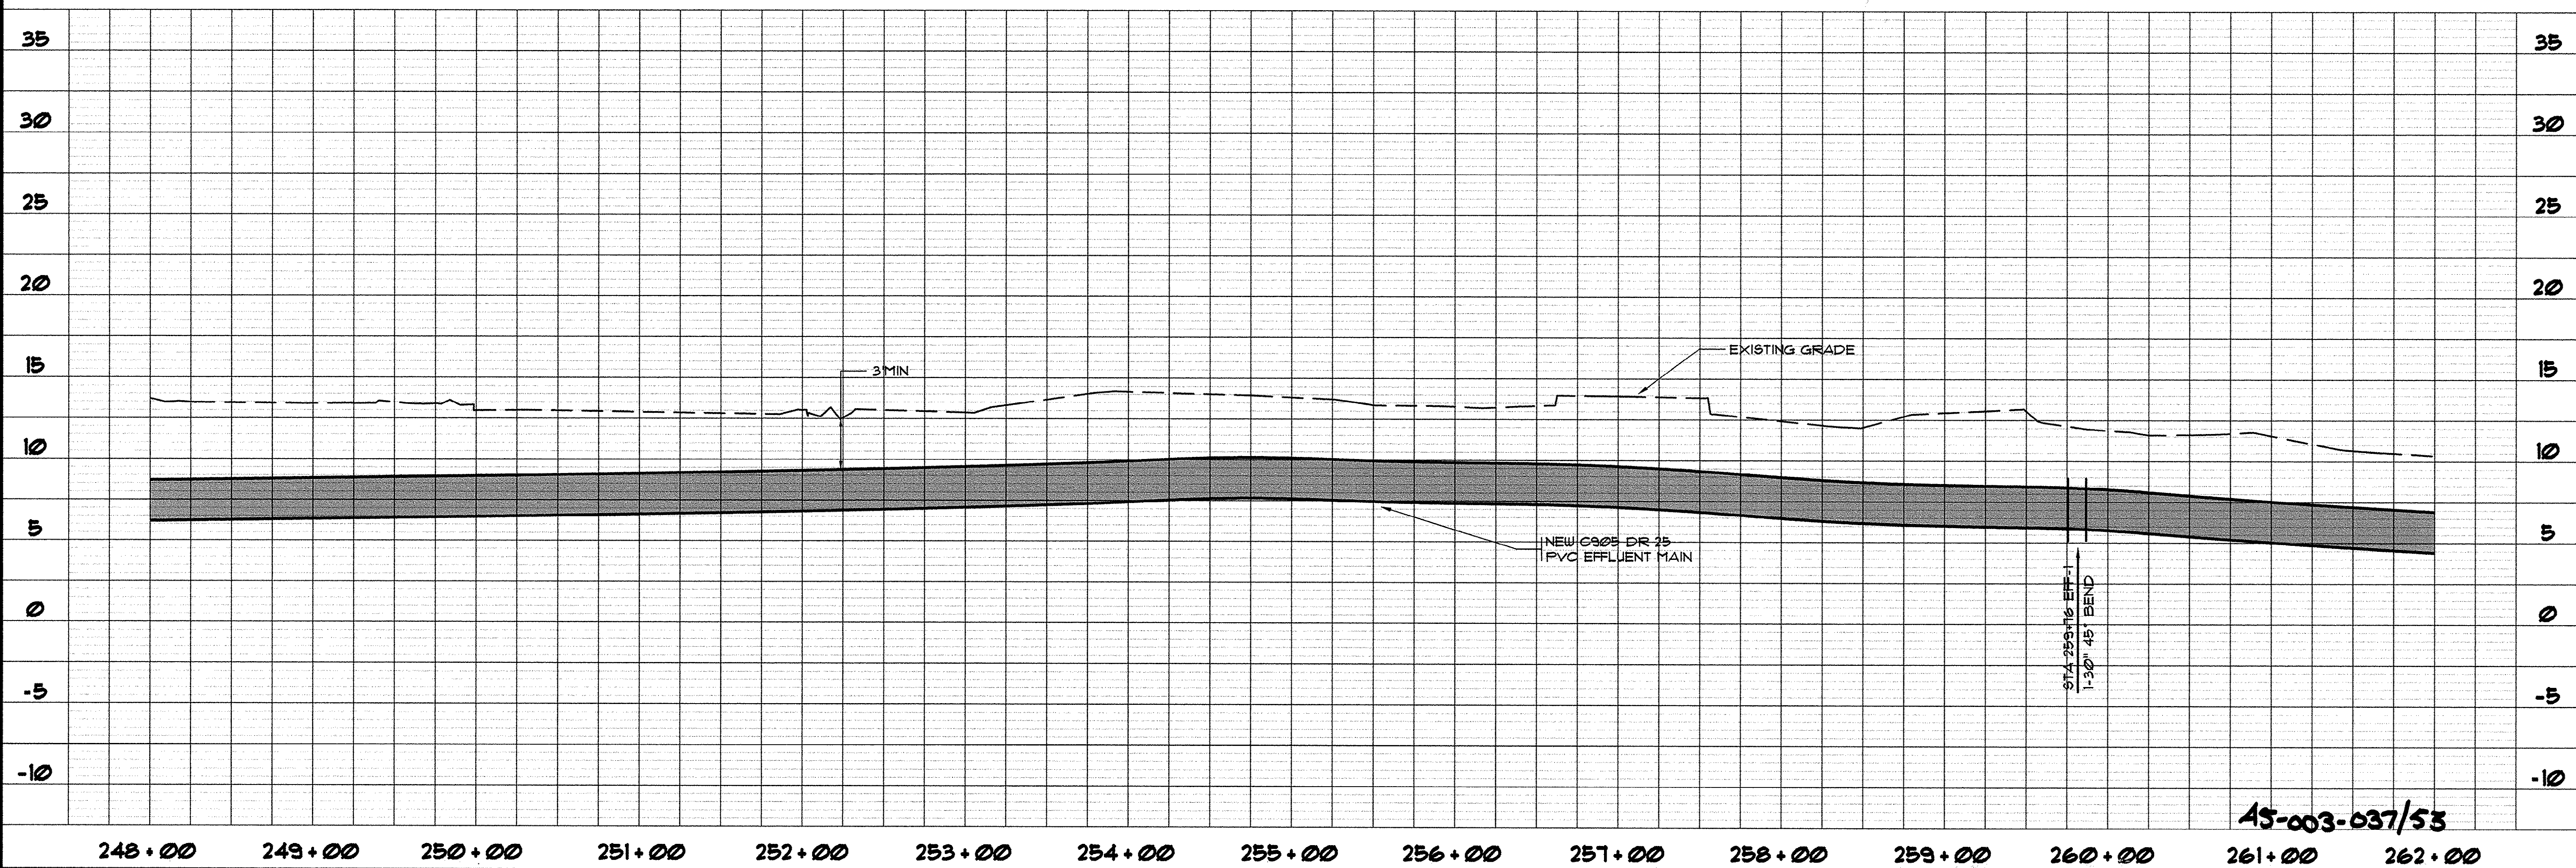

45-003-037/53

REVISIONS		DATE	BY
SYM.	DESCRIPTION		
	AS-BUILT	8/01/01	CAR

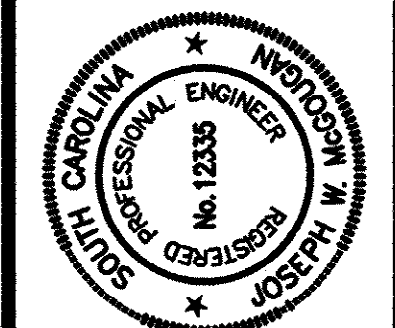

HOBBS, UPCHURCH & ASSOCIATES, P.A.
CONSULTING ENGINEERS
MYRTLE BEACH, SOUTH CAROLINA 29577




PLAN AND PROFILE
EFFLUENT MAIN 1



TIP-TOP TREE FARM
EFFLUENT LAND
APPLICATION PROJECT
GRAND STRAND WATER
AND SEWER AUTHORITY

DATE:	MAR. 1999
DESIGNED:	WDL
DRAWN:	KLM
CHECKED:	WDL
SCALE:	AS SHOWN
SHEET NO.	EFF-20
OF	21

HOBBS, UPCHURCH & ASSOC. MB J:\G99901\800\220\Contract 2 Asbuilt\eff-1-pp20.dwg EDITED BY: ARABON DATE: 08/26/01 TIME: 14:55 XREFS: J:\G99901\800\910\points.dwg Layout: Layout1

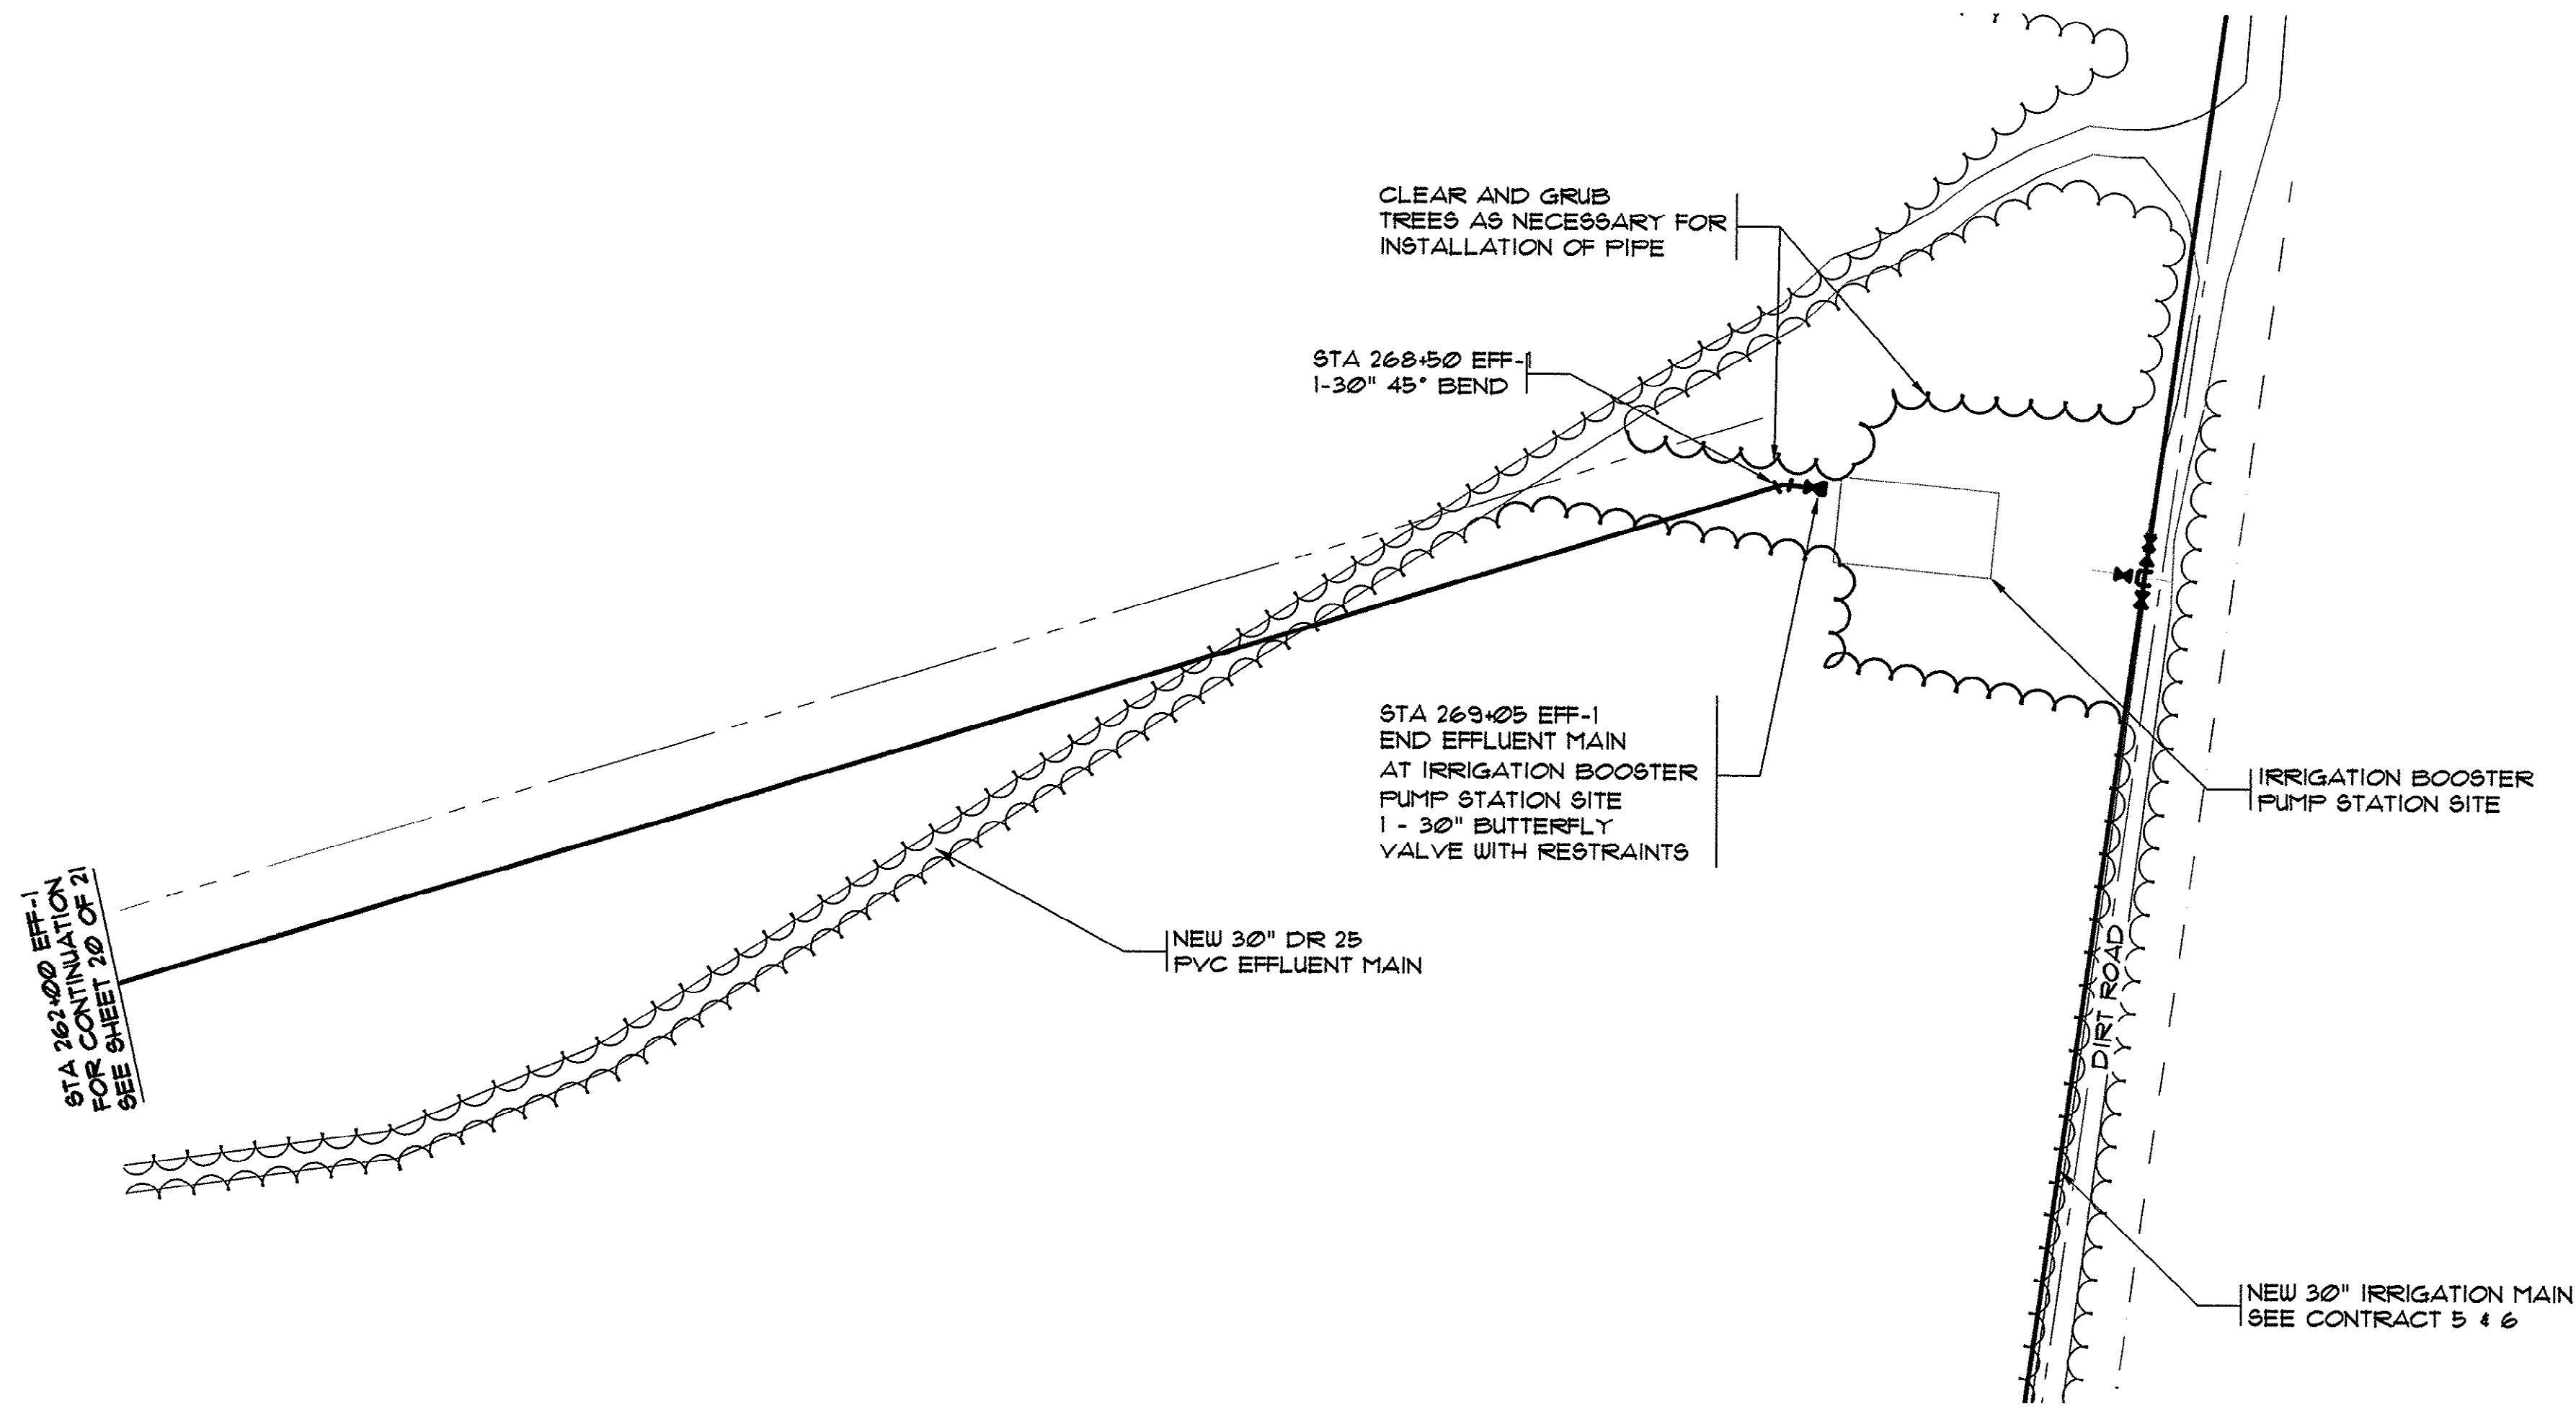

EFFLUENT-MAIN-1

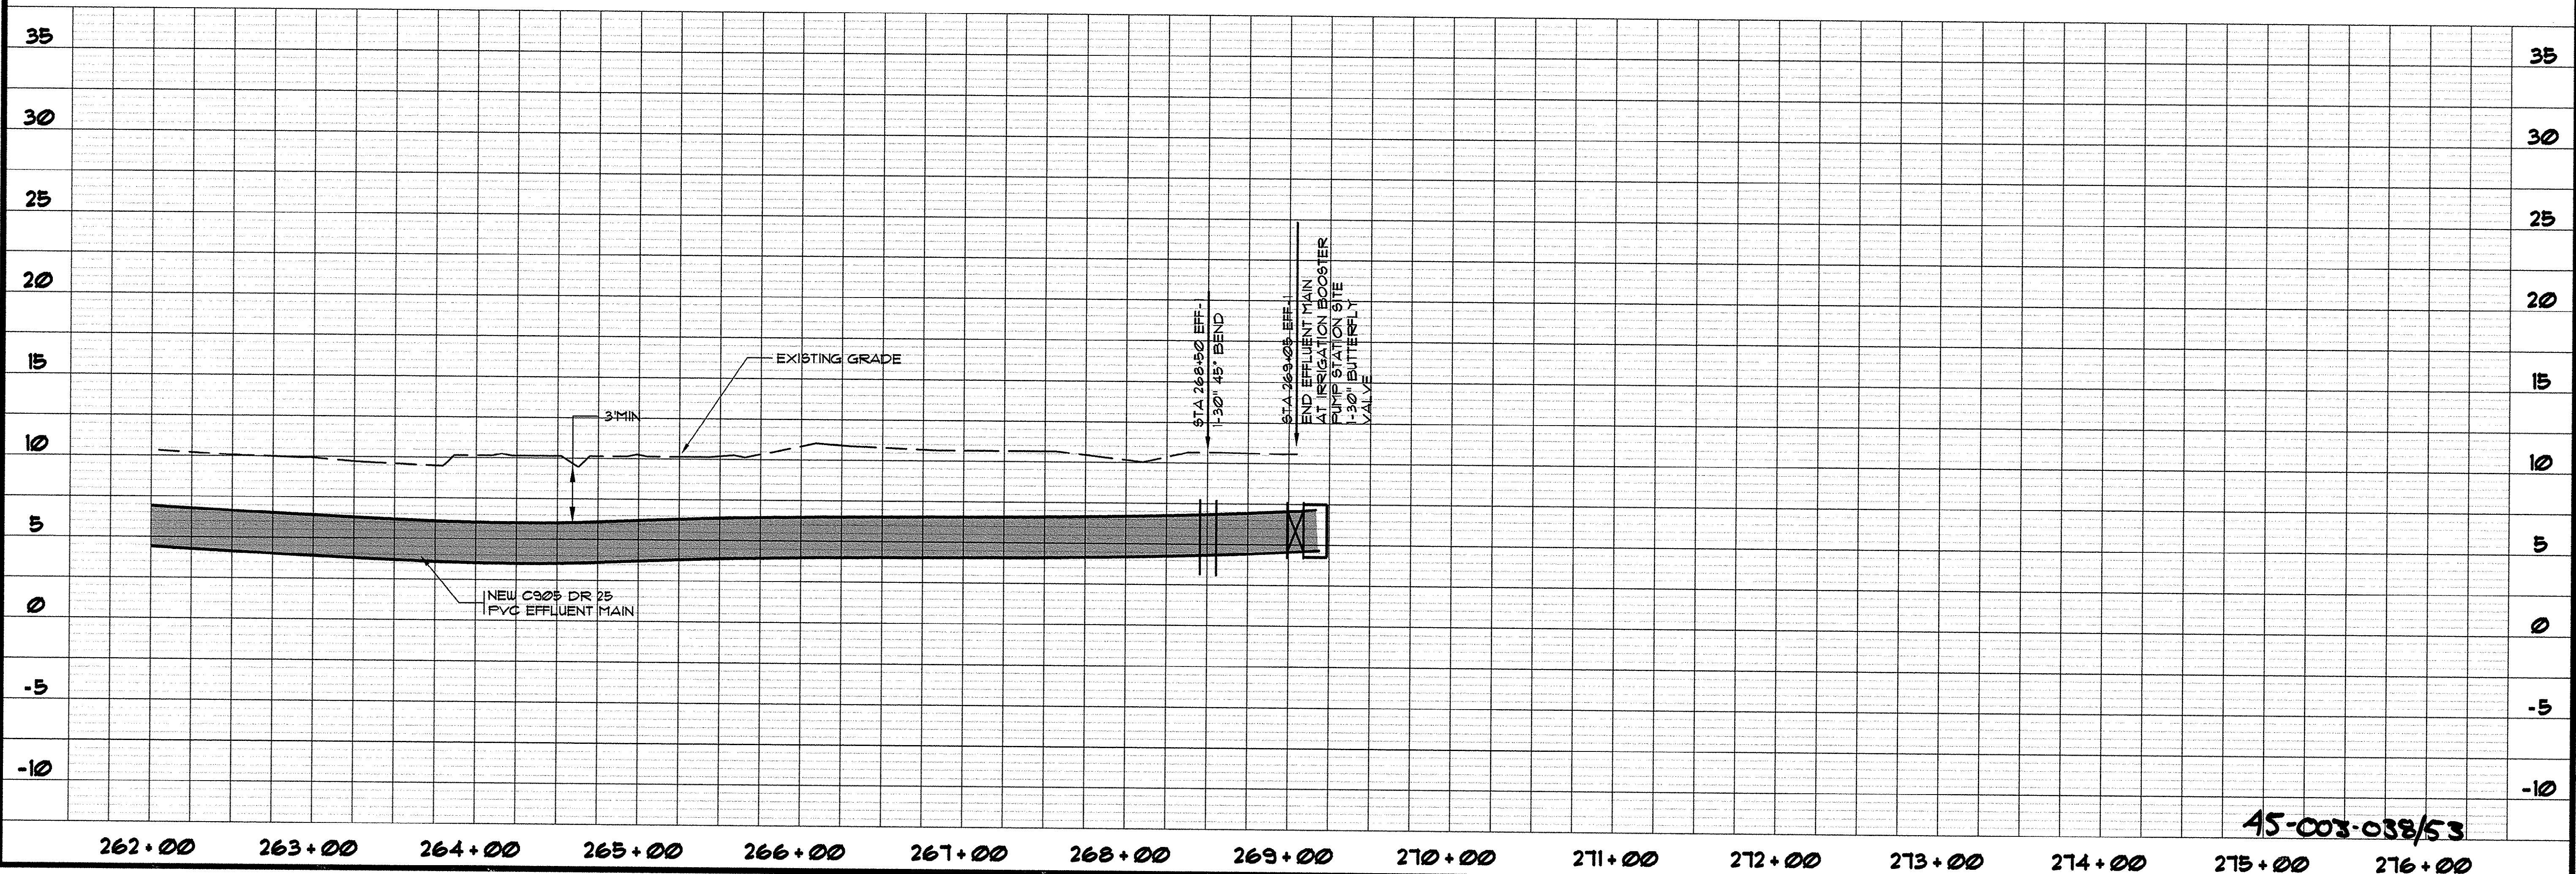 


THESE DRAWINGS REFLECT
AS-BUILT
CONDITIONS

REVIEWED BY: _____ DATE: _____
INSPECTIONS


REVIEWED BY: _____ DATE: _____
ENGINEERING

GRAND STRAND WATER AND SEWER AUTHORITY

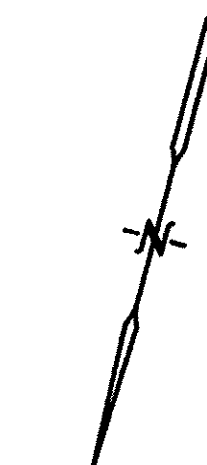

- LEGEND**
- | | | | |
|---------------|---------------------------|---|-----------------------|
| — | NEW EFFLUENT / FORCE MAIN | ⋈ | NEW BUTTERFLY VALVE |
| - - - | EXISTING EFFLUENT MAIN | ⋈ | EXISTING VALVE |
| - - - | EXISTING WATER MAIN | ● | NEW AIR RELEASE VALVE |
| - ○ - | EXISTING WASTEWATER LINE | ⋈ | POWER POLE |
| - - - - - | EXISTING STORM DRAIN | ⋈ | PEDESTAL BOX |
| - x - x - x - | EXISTING FENCE LINE | ⋈ | EXISTING MANHOLE |
| - - - | DITCH LINE | ⋈ | EXISTING FIRE HYDRANT |
| - - - | SHRUBBERY | ○ | IRON ROD |
| - - - | TREE LINE | | |
| - - - | RIGHT OF WAY | | |

SYN.	DESCRIPTION	DATE	BY
	AS-BUILT	8/07/01	CAR

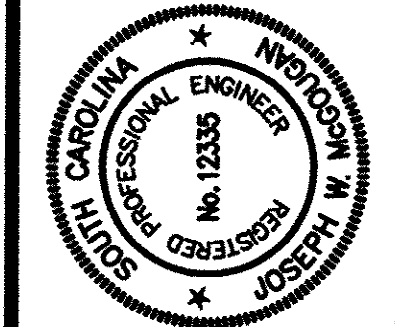

HOBBS, UPCHURCH & ASSOCIATES, P.A.
CONSULTING ENGINEERS
MYRTLE BEACH, SOUTH CAROLINA 29577

PLAN AND PROFILE
EFFLUENT MAIN 1

TIP-TOP TREE FARM
EFFLUENT LAND
APPLICATION PROJECT
GRAND STRAND WATER
AND SEWER AUTHORITY


DATE: MAR. 1999
DESIGNED: WDL
DRAWN: KLM
CHECKED: WDL
SCALE: AS SHOWN

SHEET NO. **EFF-21**

OF 21


45-003-038/53

HOBBES, UPCHURCH & ASSOC. INC. J:\CS9901\800\820\Contract 2 details\DETAILS1.dwg EDITED BY: ABARON DATE: 08/01/01 TIME: 08:02 Layout: Model

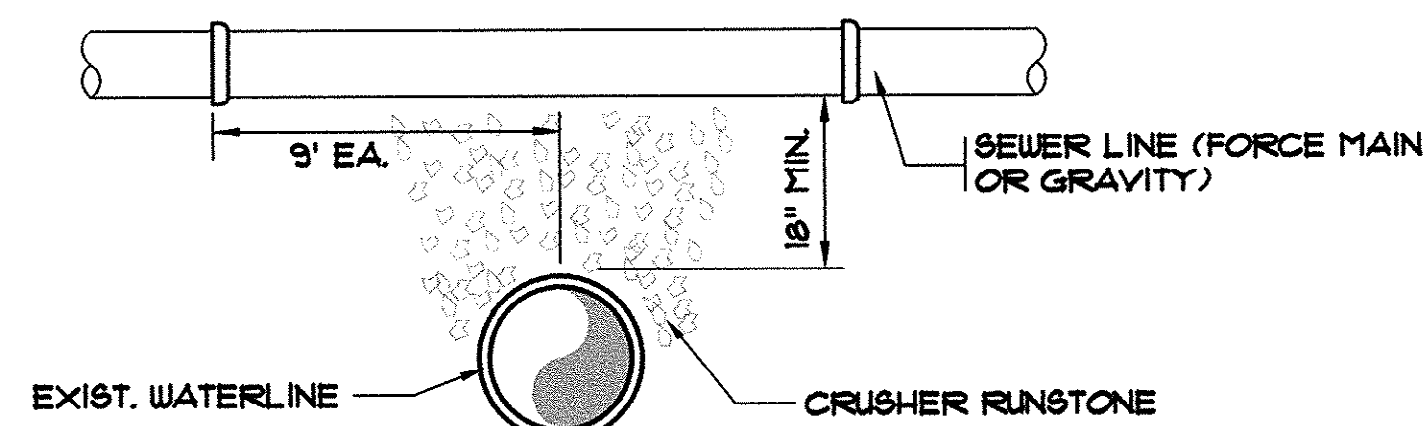


SEWERLINE OVER WATERLINE

NOTE:
D.I.P. MAYBE REQUIRED AT
OR SDR18 C900 PVC CROSSING.

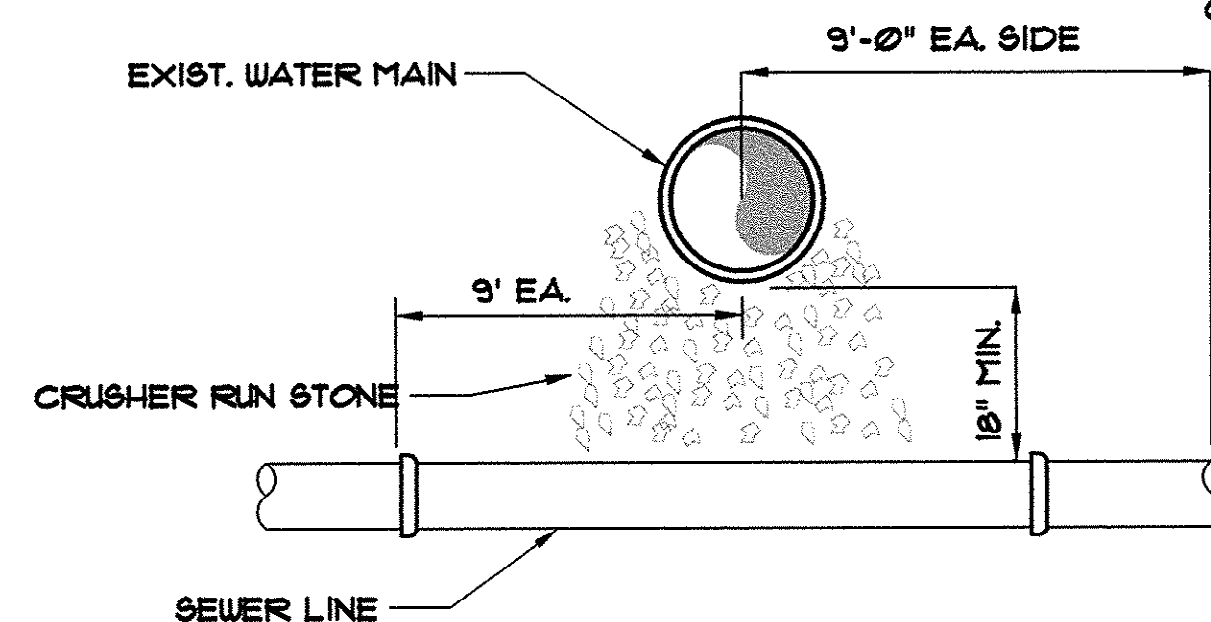



WATERLINE OVER SEWERLINE

WATERLINE CROSSING
N.T.S.

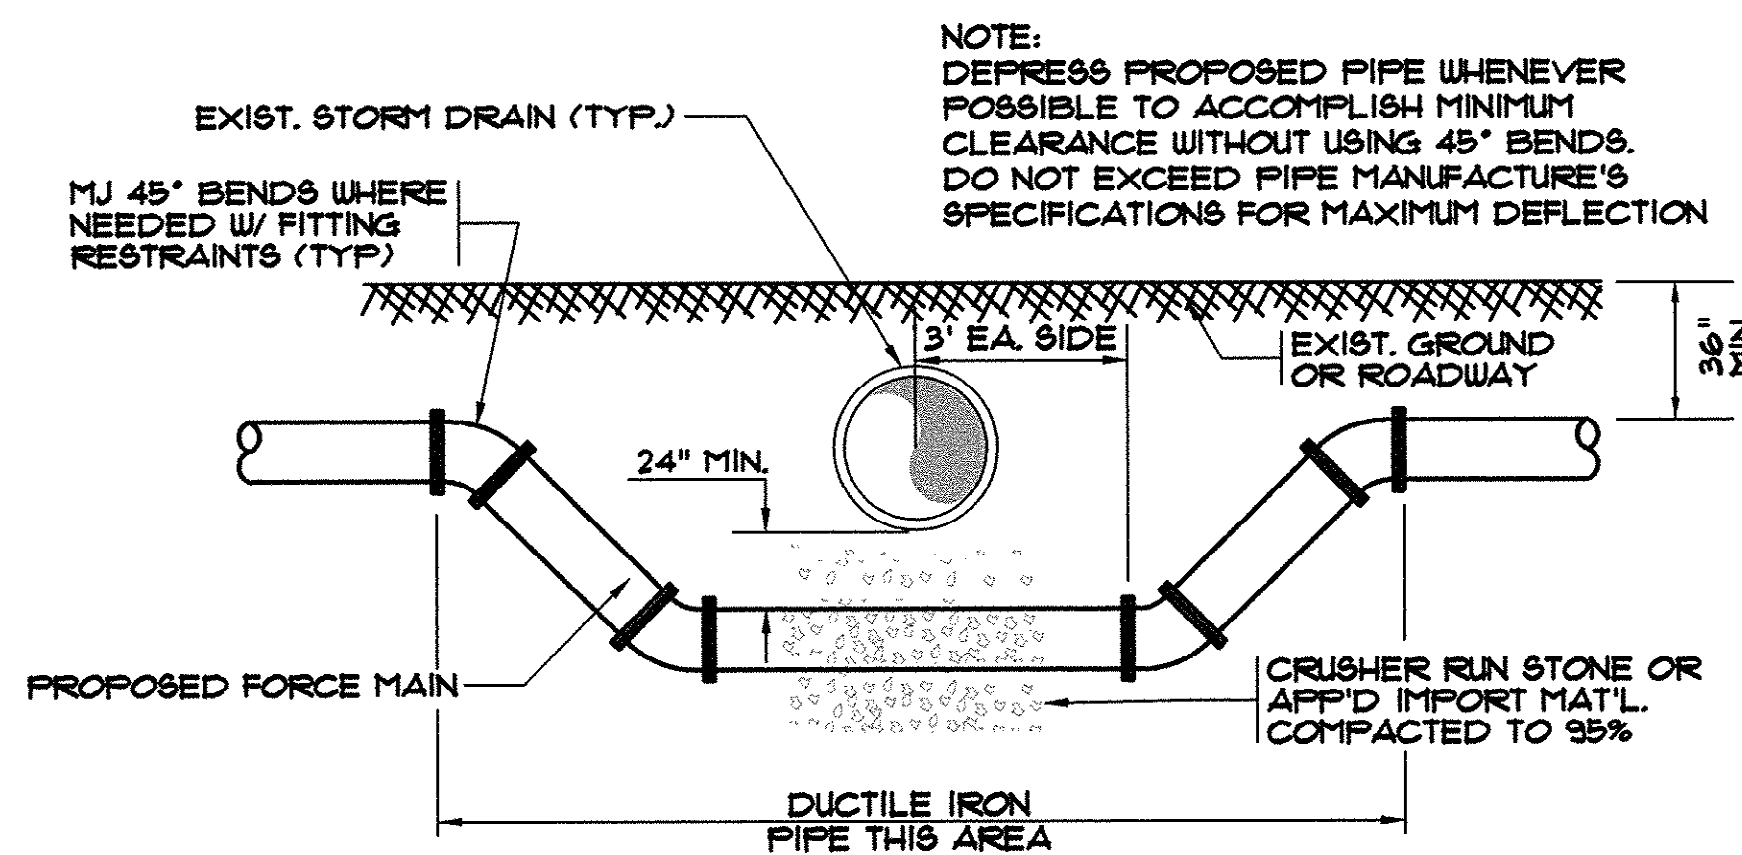

- NOTES:
- 1) IN CASES WHERE D.I.P. FORCEMAIN IS NEEDED AT STORM DRAIN, D.I.P. SECTION MUST BE AT A SUFFICIENT ELEVATION TO KEEP IT FULL AT ALL TIMES. IF SECTION OF FORCEMAIN CALLING FOR D.I.P. DOES NOT MEET THIS REQUIREMENT, THEN C900 SDR 18 PVC PIPE SHALL BE USED INSTEAD.
 - 2) DEPRESS FORCEMAIN WHENEVER POSSIBLE TO ACCOMPLISH CLEARANCE WITHOUT USE OF FITTINGS.
 - 3) SEWER FORCEMAIN MAY BE PLACED ABOVE STORM DRAIN IF THERE IS 12" MIN. CLEARANCE OF STORM DRAIN, 30" GROUND COVER ABOVE AND AROUND, AND IT MEETS REQUIREMENT OF NOTE 1.


STORM DRAIN CROSSING
N.T.S.

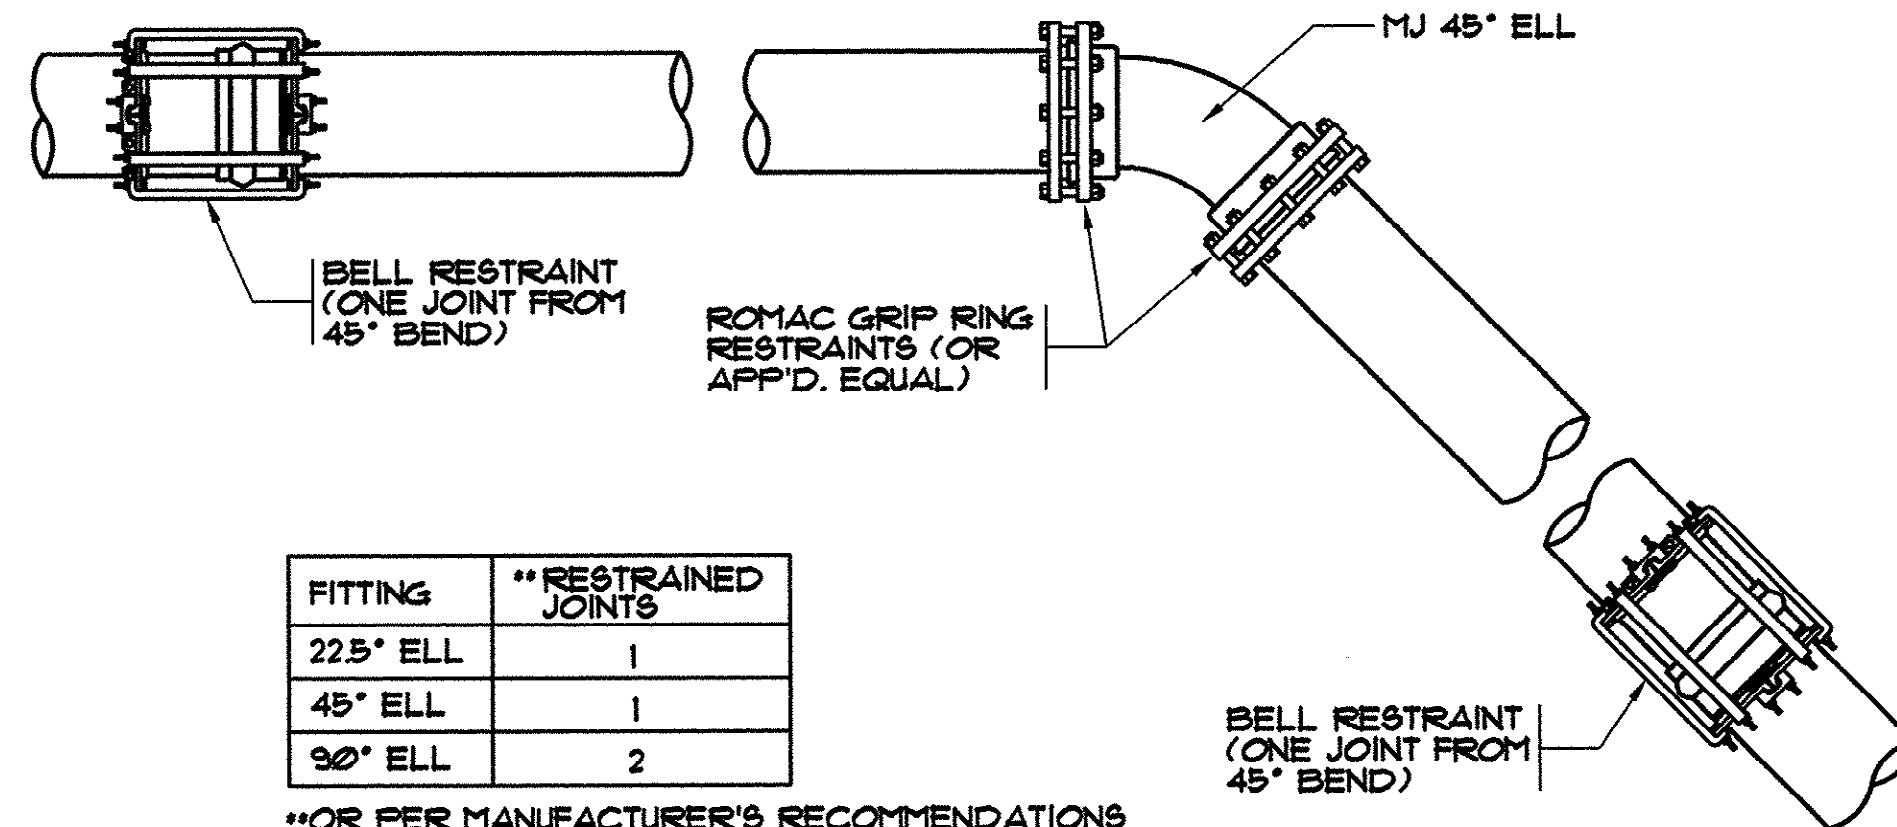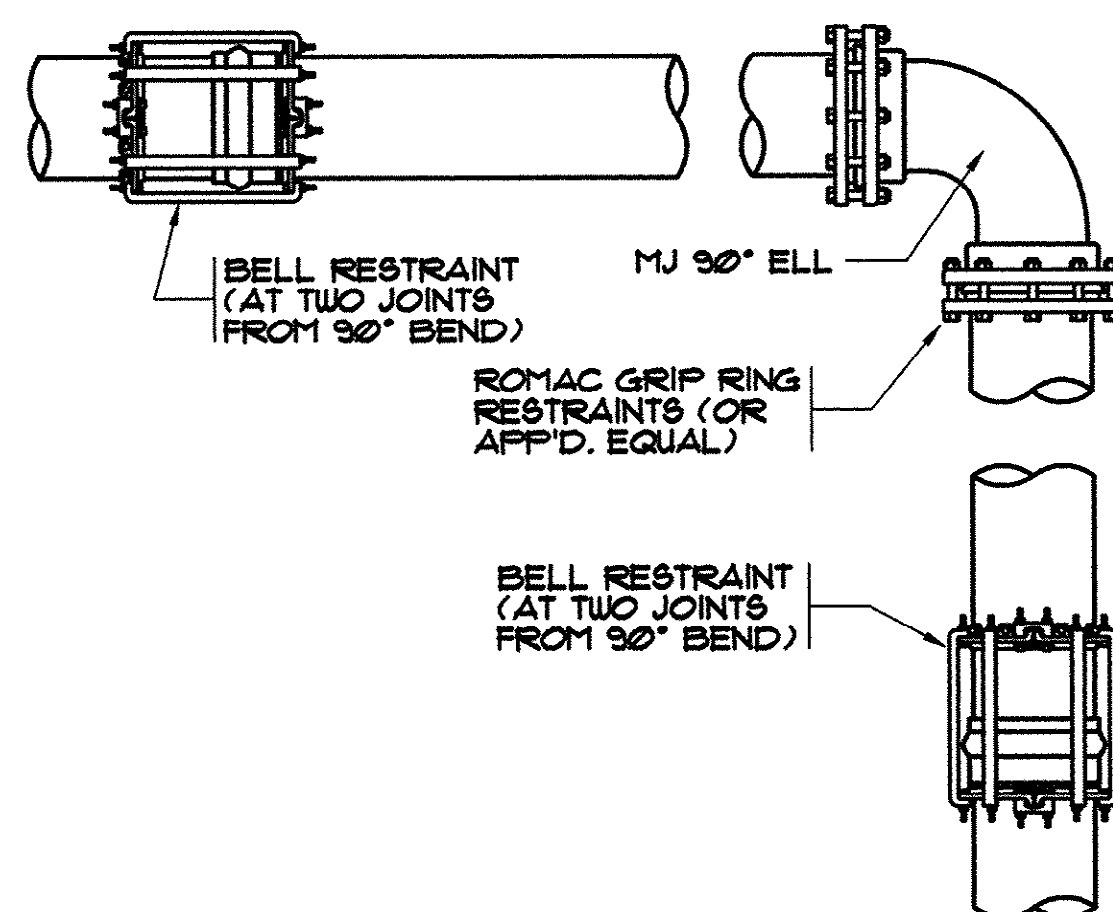


FITTING	**RESTRAINED JOINTS
22.5° ELL	1
45° ELL	1
90° ELL	2

**OR PER MANUFACTURER'S RECOMMENDATIONS

TYPICAL FITTING AND JOINT RESTRAINT
N.T.S.
(INCLUDES VALVES)

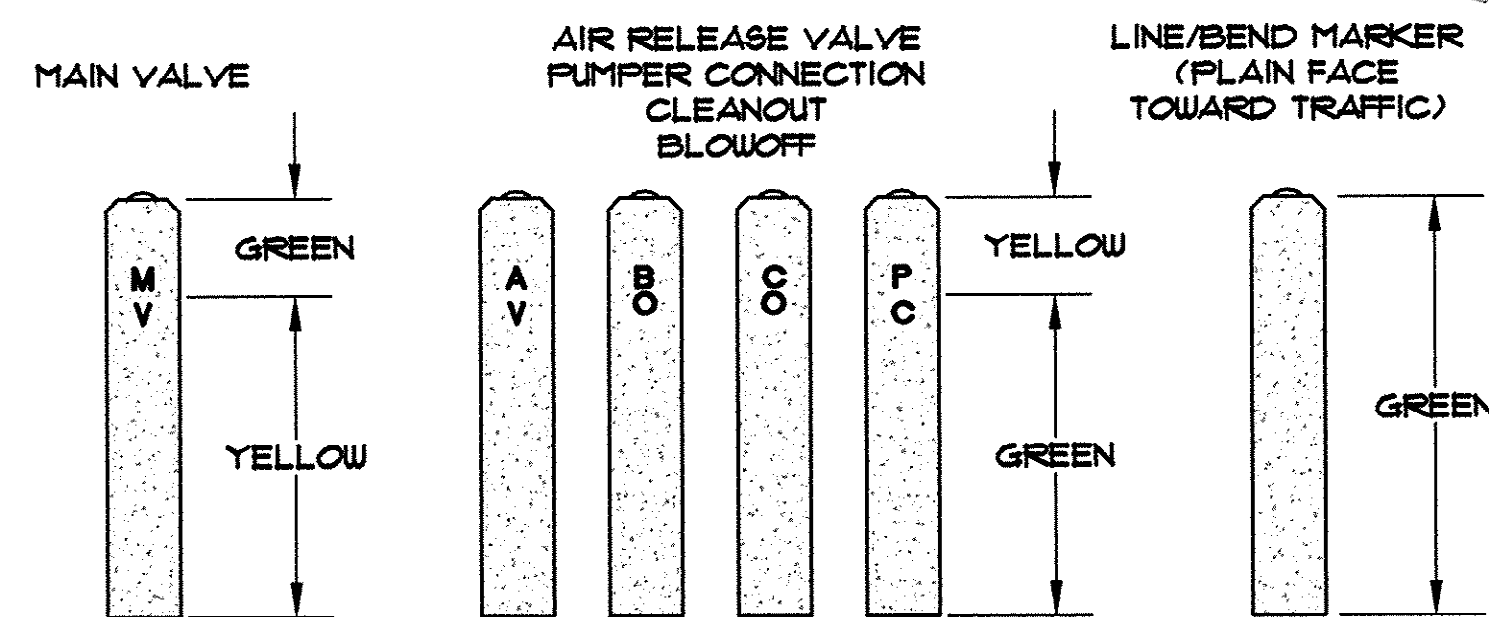


CONCRETE MARKER PAINT CODES

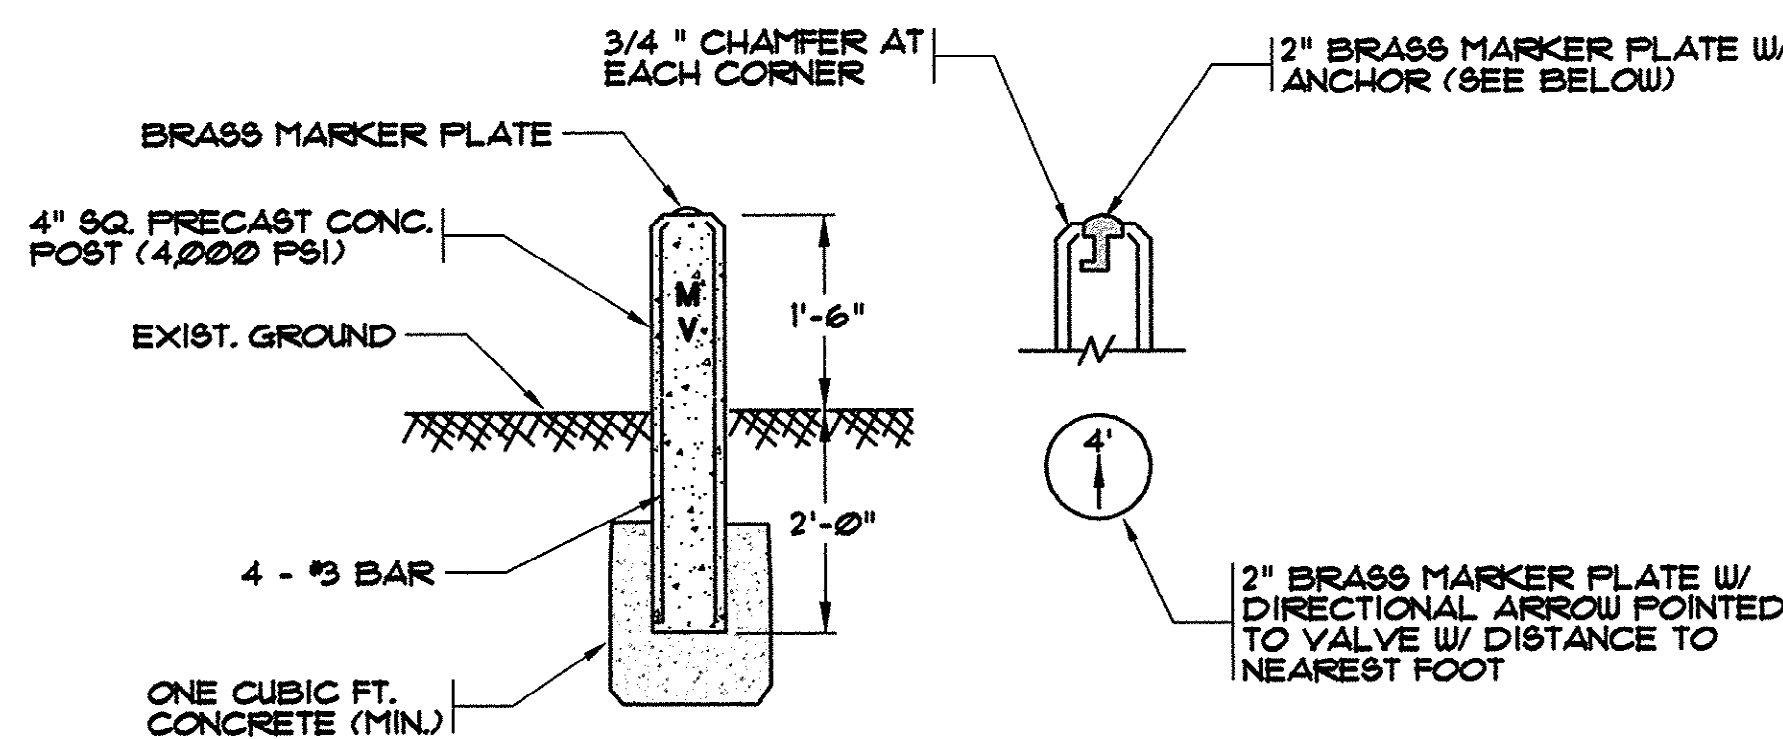

CONCRETE VALVE MARKER

(VALVE, ARV, BLOWOFF, CLEANOUT, PUMPER CONNECTION, BEND, PIPELINE)

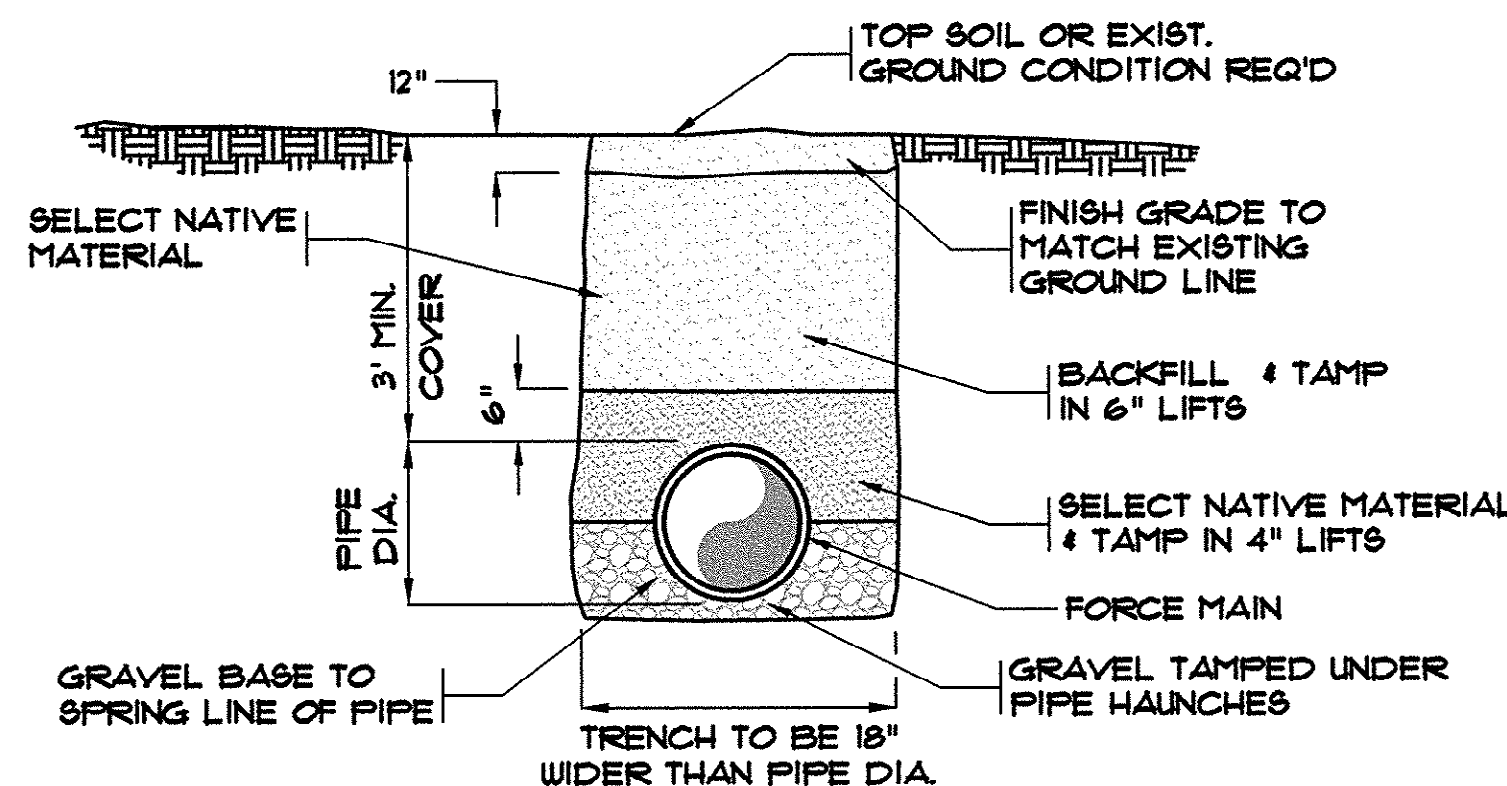


TYPICAL PIPE BEDDING DETAIL

THESE DRAWINGS REFLECT
AS-BUILT
CONDITIONS

REVIEWED BY: _____ DATE: _____
INSPECTIONS

REVIEWED BY: _____ DATE: _____
ENGINEERING


GRAND STRAND WATER AND SEWER AUTHORITY

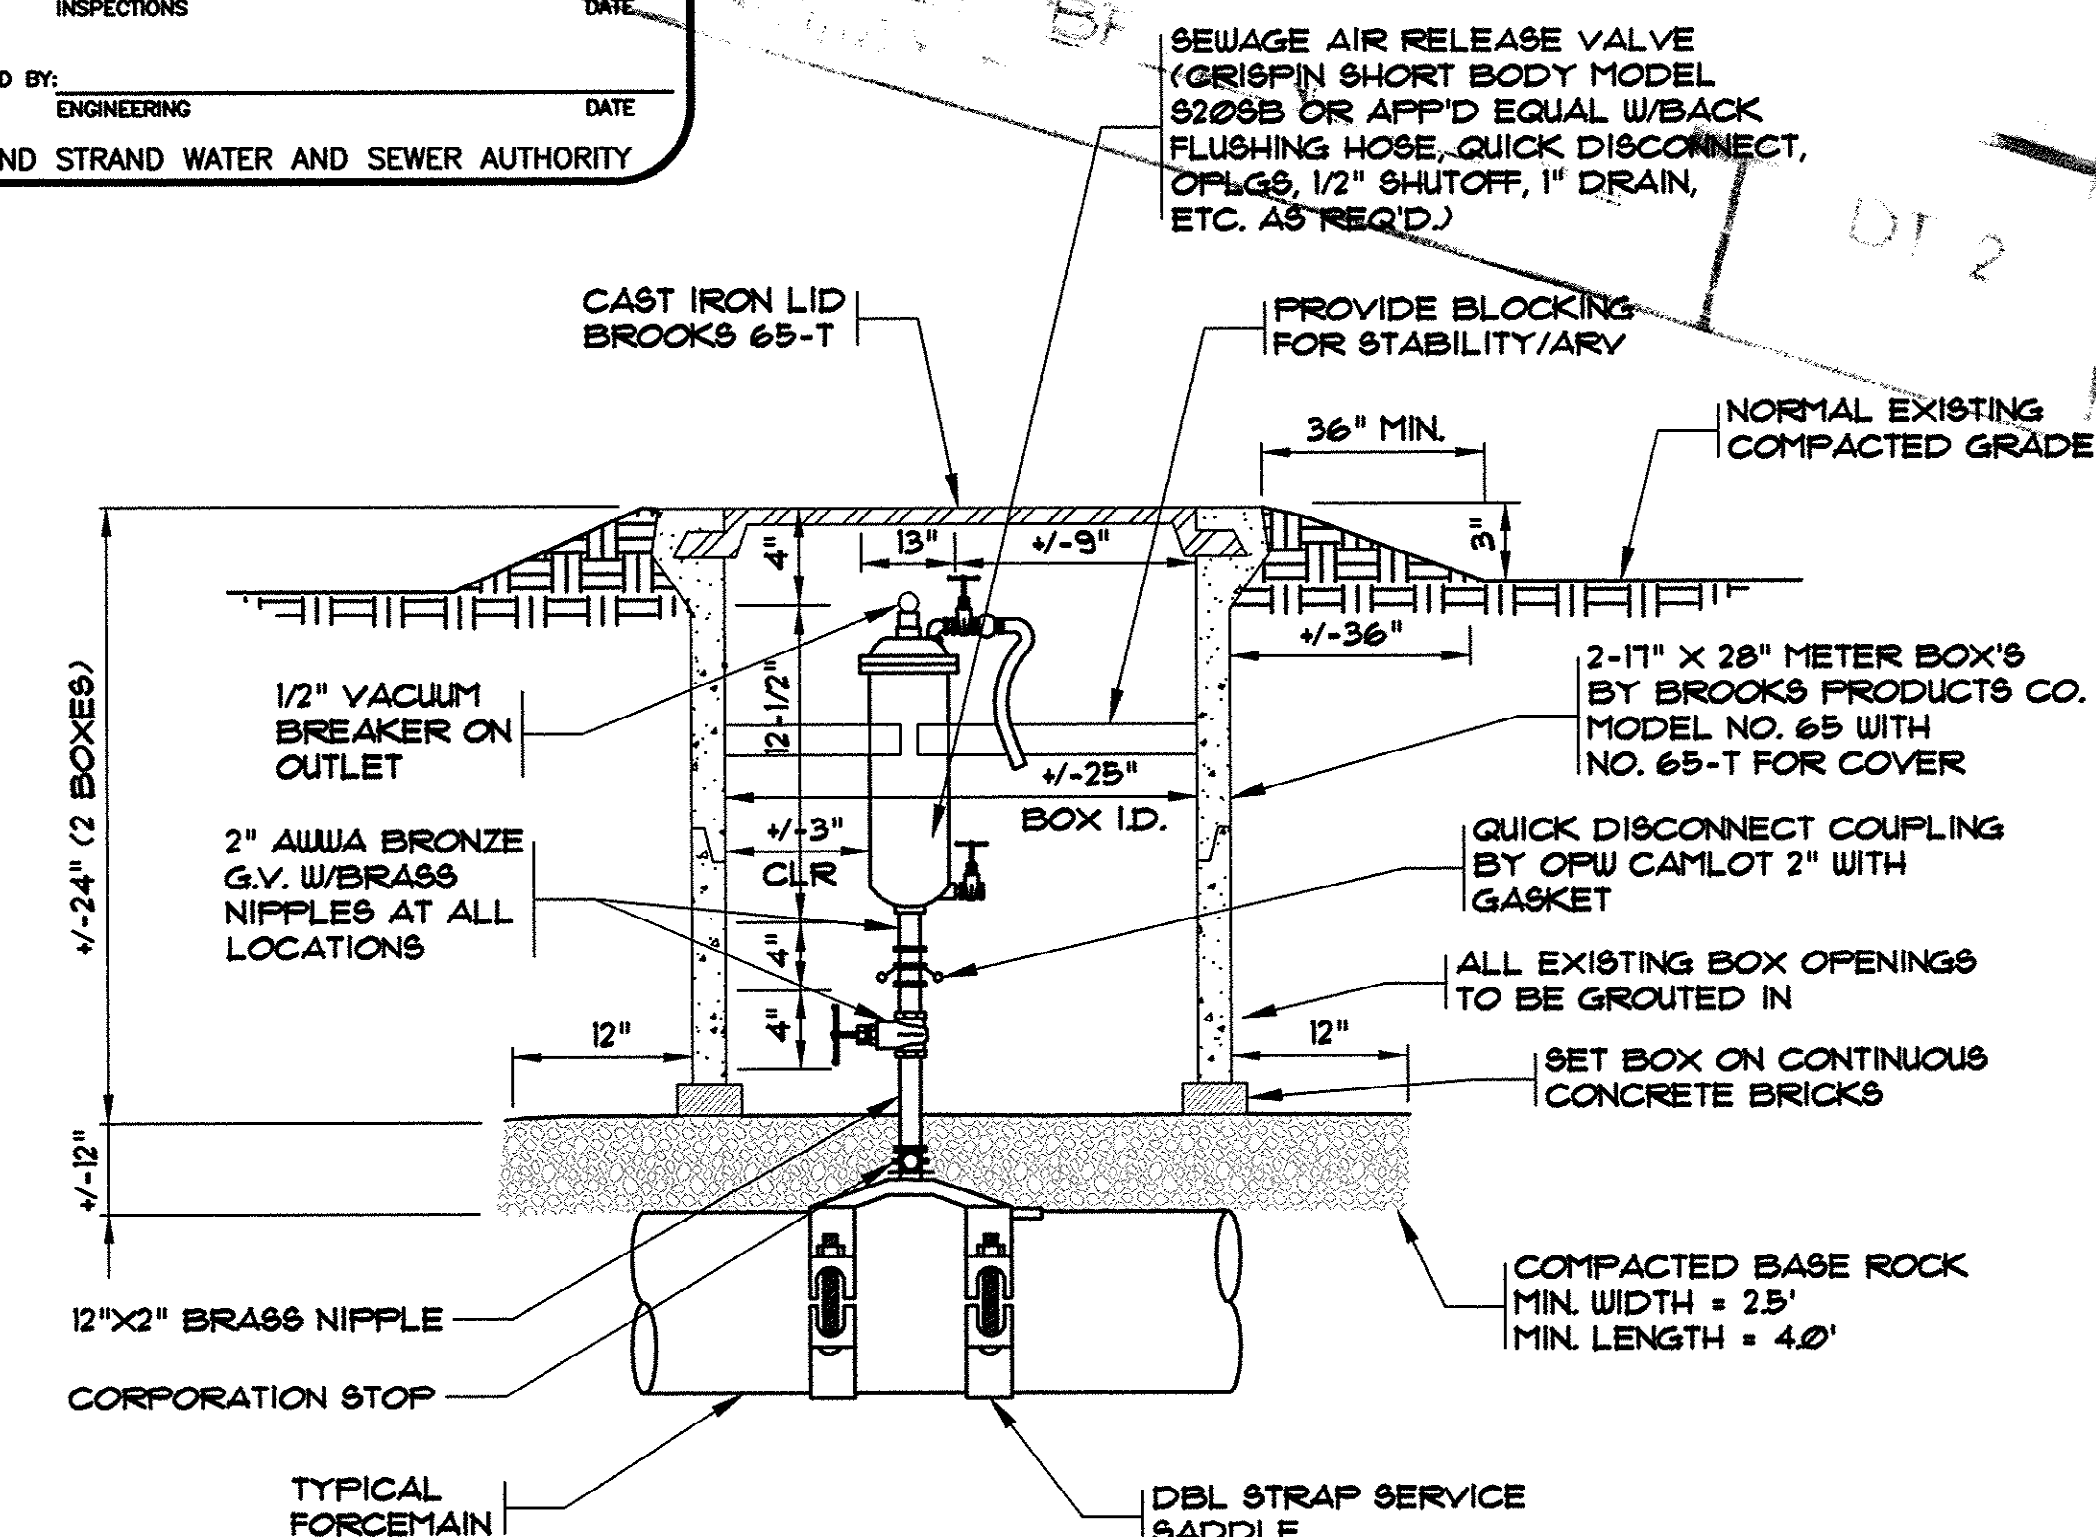

NOTES:

1. USE AN APPROVED JT. COMPOUND ON ALL THREADED CONNECTIONS.
2. ROTATION & LOCATION OF BOX SETTING TO BE APPROVED BY THE INSPECTOR PRIOR TO INSTALLATION.


TYPICAL SEWER AIR RELEASE VALVE ASSEMBLY

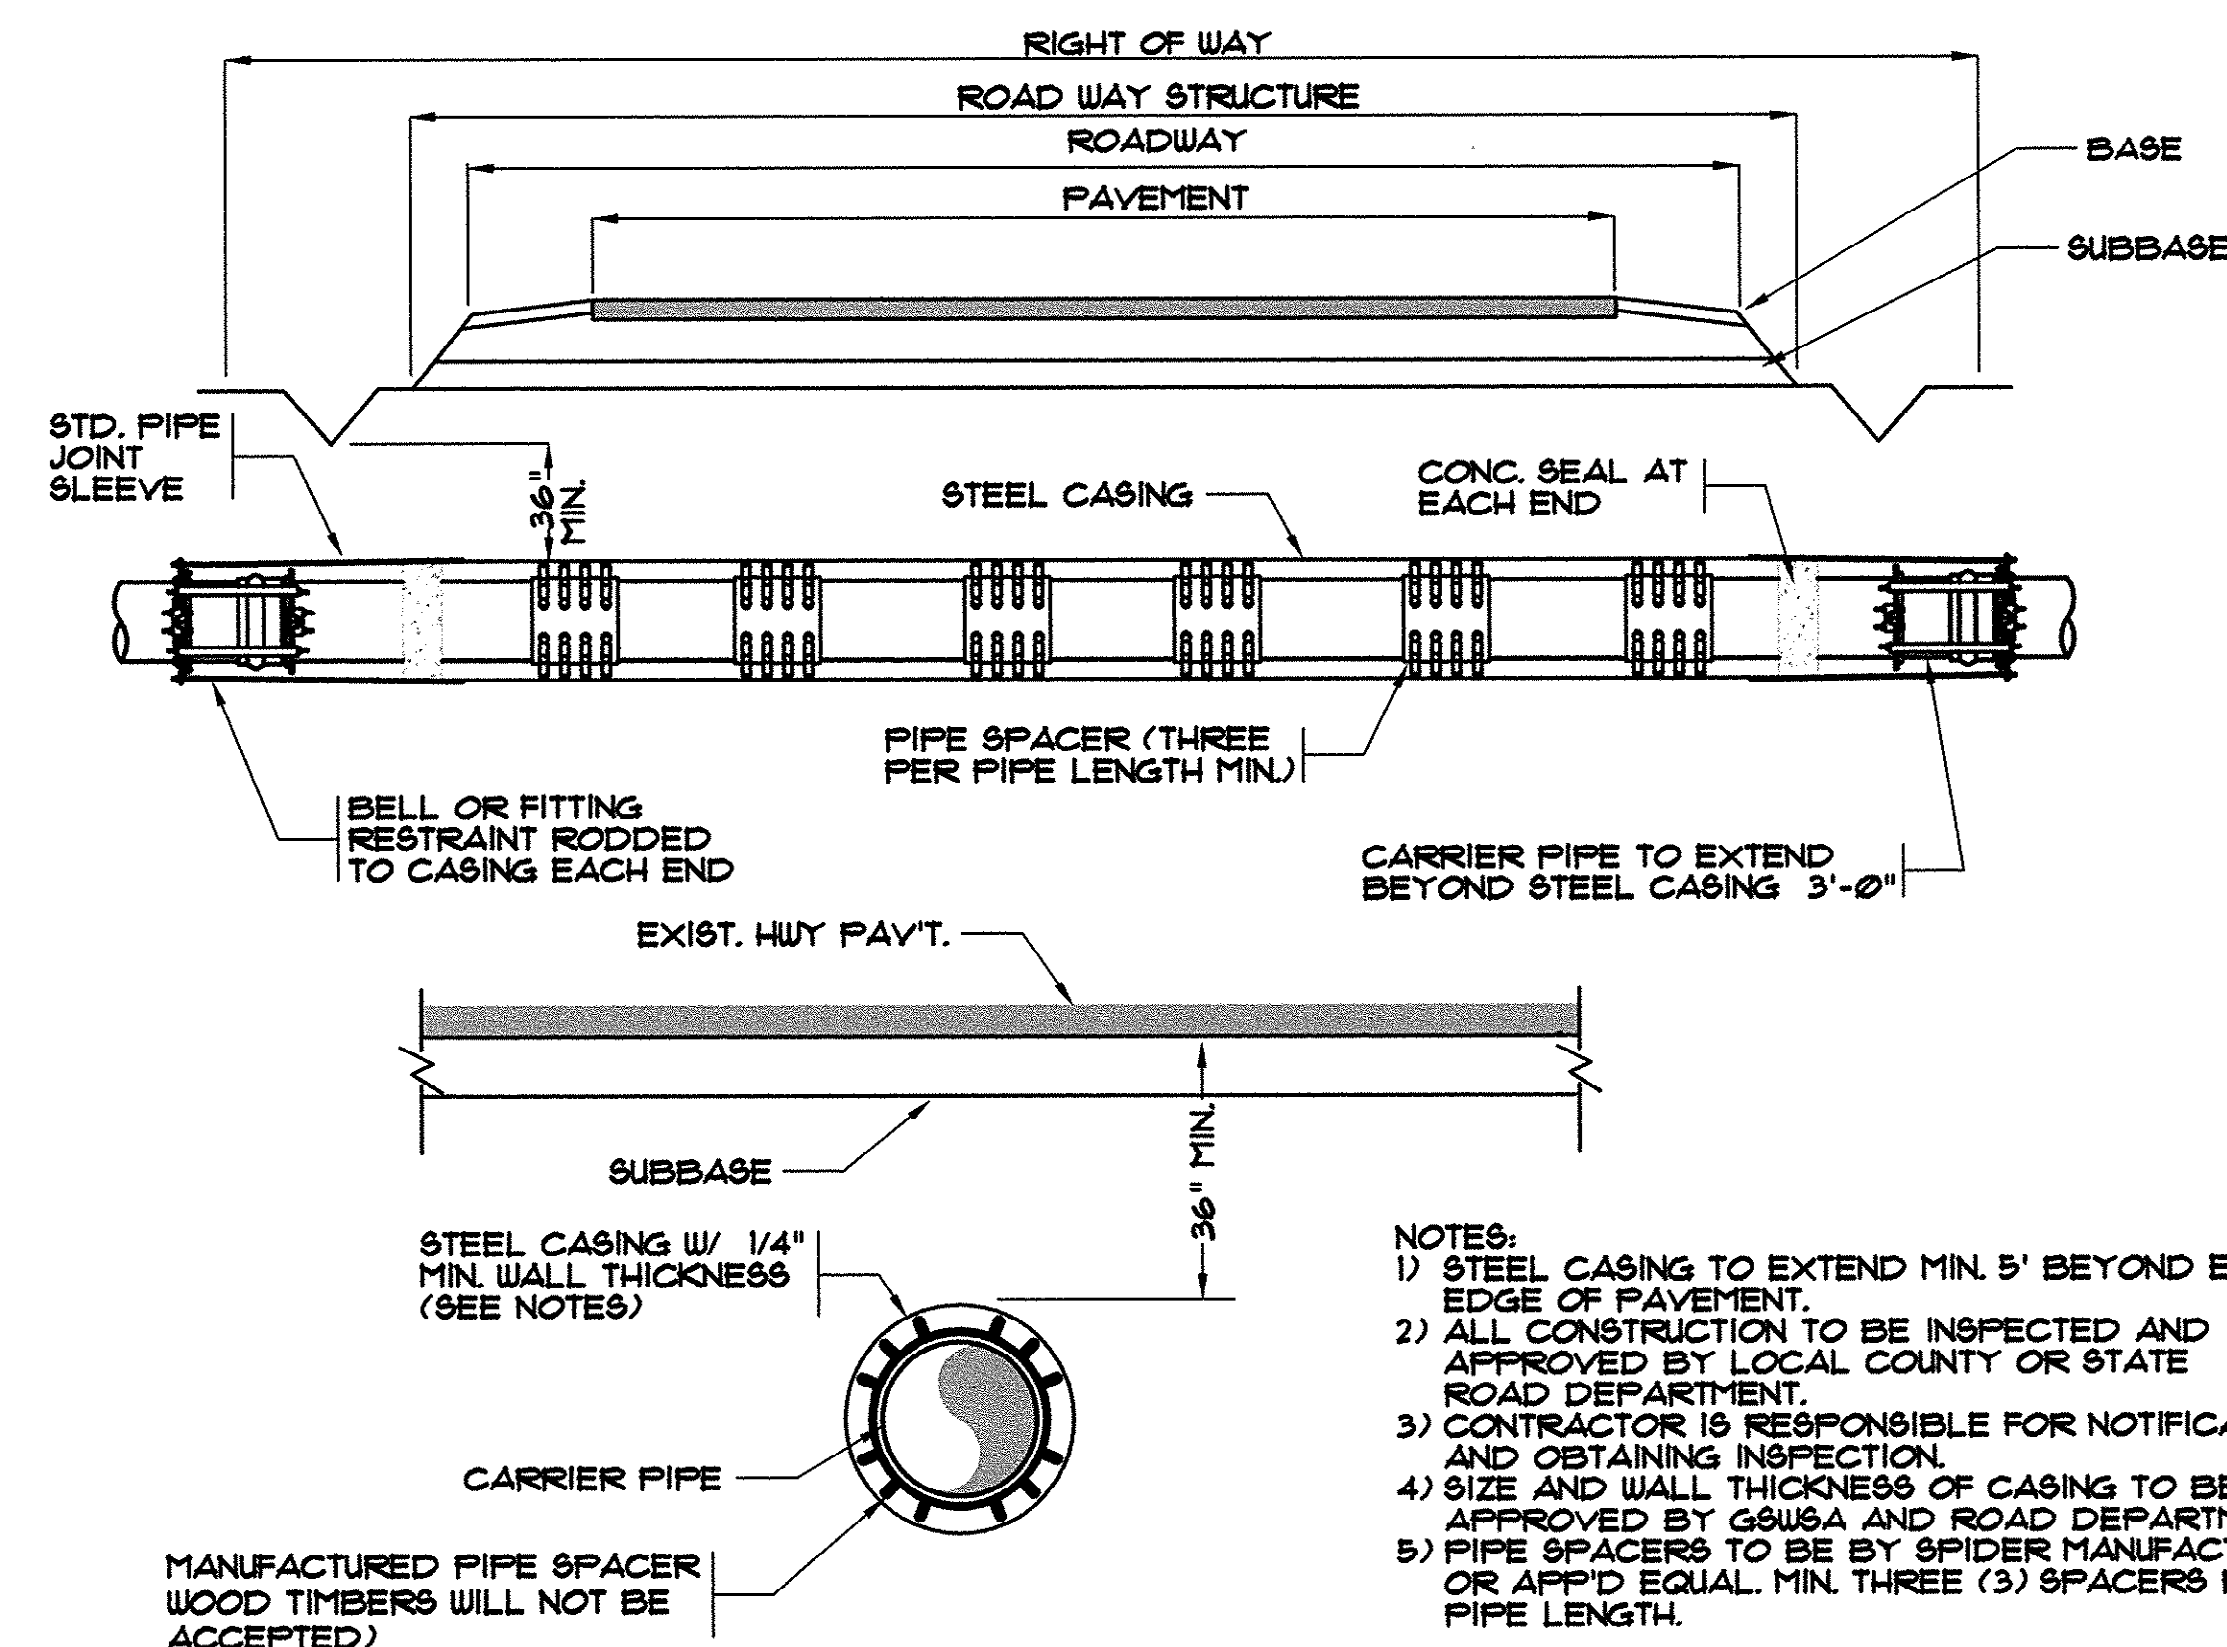

- NOTES:
- 1) STEEL CASING TO EXTEND MIN. 5' BEYOND EACH EDGE OF PAVEMENT.
 - 2) ALL CONSTRUCTION TO BE INSPECTED AND APPROVED BY LOCAL COUNTY OR STATE ROAD DEPARTMENT.
 - 3) CONTRACTOR IS RESPONSIBLE FOR NOTIFICATION AND OBTAINING INSPECTION.
 - 4) SIZE AND WALL THICKNESS OF CASING TO BE APPROVED BY GSW&A AND ROAD DEPARTMENT.
 - 5) PIPE SPACERS TO BE BY SPIDER MANUFACTURING OR APP'D EQUAL. MIN. THREE (3) SPACERS PER PIPE LENGTH.

TYPICAL ROADWAY BORE & JACK
N.T.S.

REVISIONS	DATE	BY
DESCRIPTION	10/5/00	CAR
SYM.	AS-BUILT	
	8/5/01	

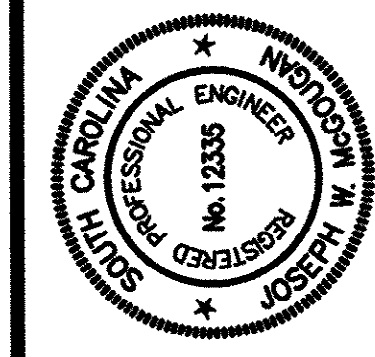

HOBBES, UPCHURCH & ASSOCIATES, P.A.
CONSULTING ENGINEERS
MYRTLE BEACH, SOUTH CAROLINA 29577



MISCELLANEOUS
DETAILS

TIP-TOP TREE FARM
EFFLUENT LAND
APPLICATION PROJECT
GRAND STRAND WATER
AND SEWER AUTHORITY


DATE:	MAR. 1999
DESIGNED:	WDL
DRAWN:	KLM
CHECKED:	WDL
SCALE:	AS SHOWN

SHEET NO.

DT-1

5


45-003-039/53

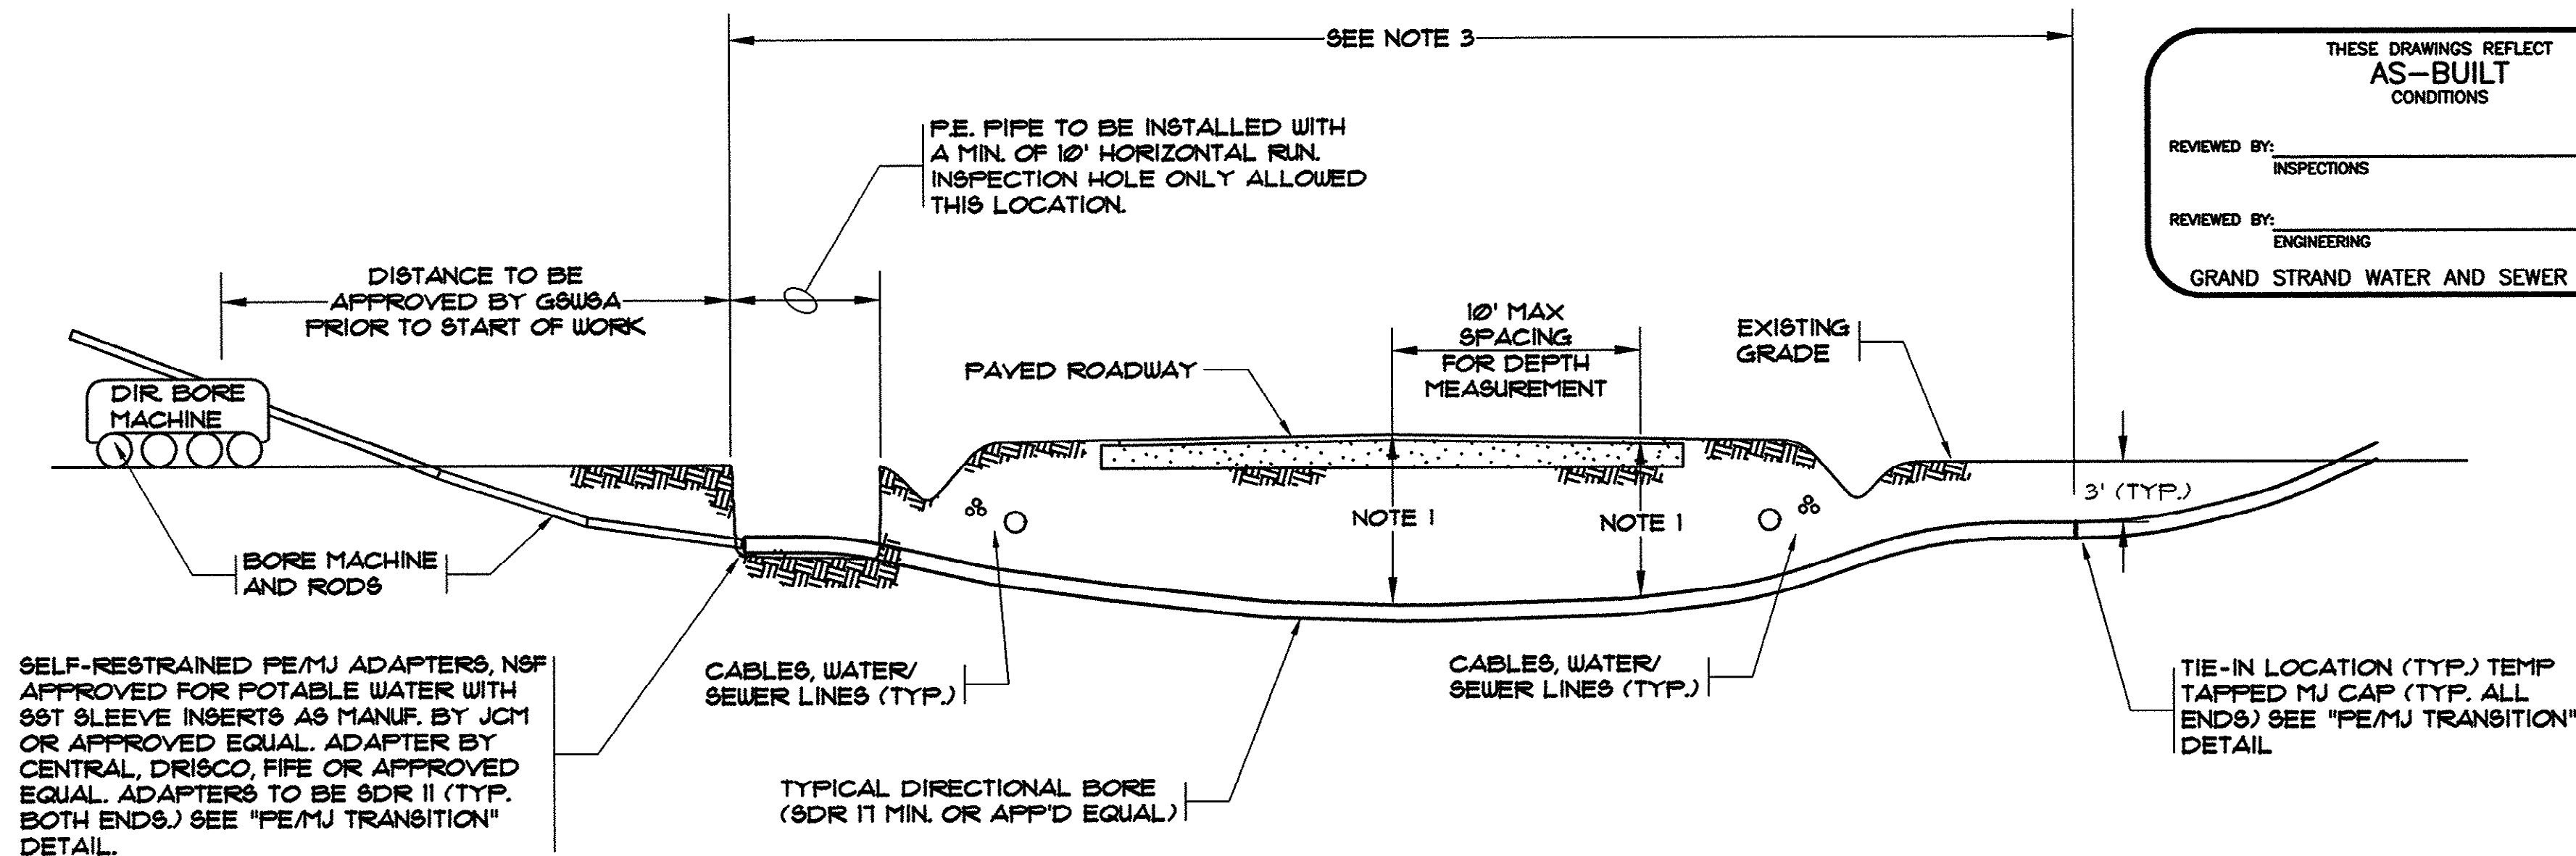

- NOTES:
1. A PROFILE AND PLAN SHALL BE PROVIDED FROM ENTRY TO EXIT FOR EACH DIRECTIONAL BORE SECTION BY THE DIRECTIONAL BORE CONTRACTOR.
 2. ALL BORE SECTIONS SHALL BE HYDROSTATICALLY TESTED PER GWSA STANDARDS UPON COMPLETION OF INSTALLATION AND PRIOR TO CONNECTION TO THE MAIN PROJECT WATER/SEWER LINE.
 3. LENGTH OF CROSSING, LOCATION OF INSPECTION/OBSERVATION EXCAVATION, NUMBER OF P.E. PIPE JOINTS, LOCATION OF BORE MACHINE, AUGER ENTRANCE LOCATION, AND TIE-IN POINTS ARE TO BE APPROVED BY GWSA PRIOR TO ANY START OF WORK OR ORDERING OF MATERIALS.
 4. THIS DETAIL IS ALSO APPLICABLE TO STREAMS, WETLANDS, LARGE STORM DRAINS, AND SIMILAR APPLICATIONS FOR DIRECTIONAL BORE WITH POLY-ETHYLENE PIPE.
 5. THE BORE DEVELOPED FOR THE LEAD IN END OF THE PIPE SHALL BE KEPT AT A MINIMUM DIAMETER FOR THE PIPE INSTALLATION. THE LEAD IN END SHALL BE PULLED THROUGH WITHOUT THE M.J. FLANGE ATTACHED FOR LARGER THAN 6" PIPE INSTALLATIONS. THE M.J. FLANGE FOR SAID LEAD IN END SHALL BE INSTALLED AFTER THE PIPE INSTALLATION WITH THE USE OF A SPLIT M.J. FLANGE PER THE DETAIL ON THIS DRAWING.


TYPICAL ROADWAY DIRECTIONAL BORE FOR POLYETHYLENE (PE) PIPE

N.T.S.

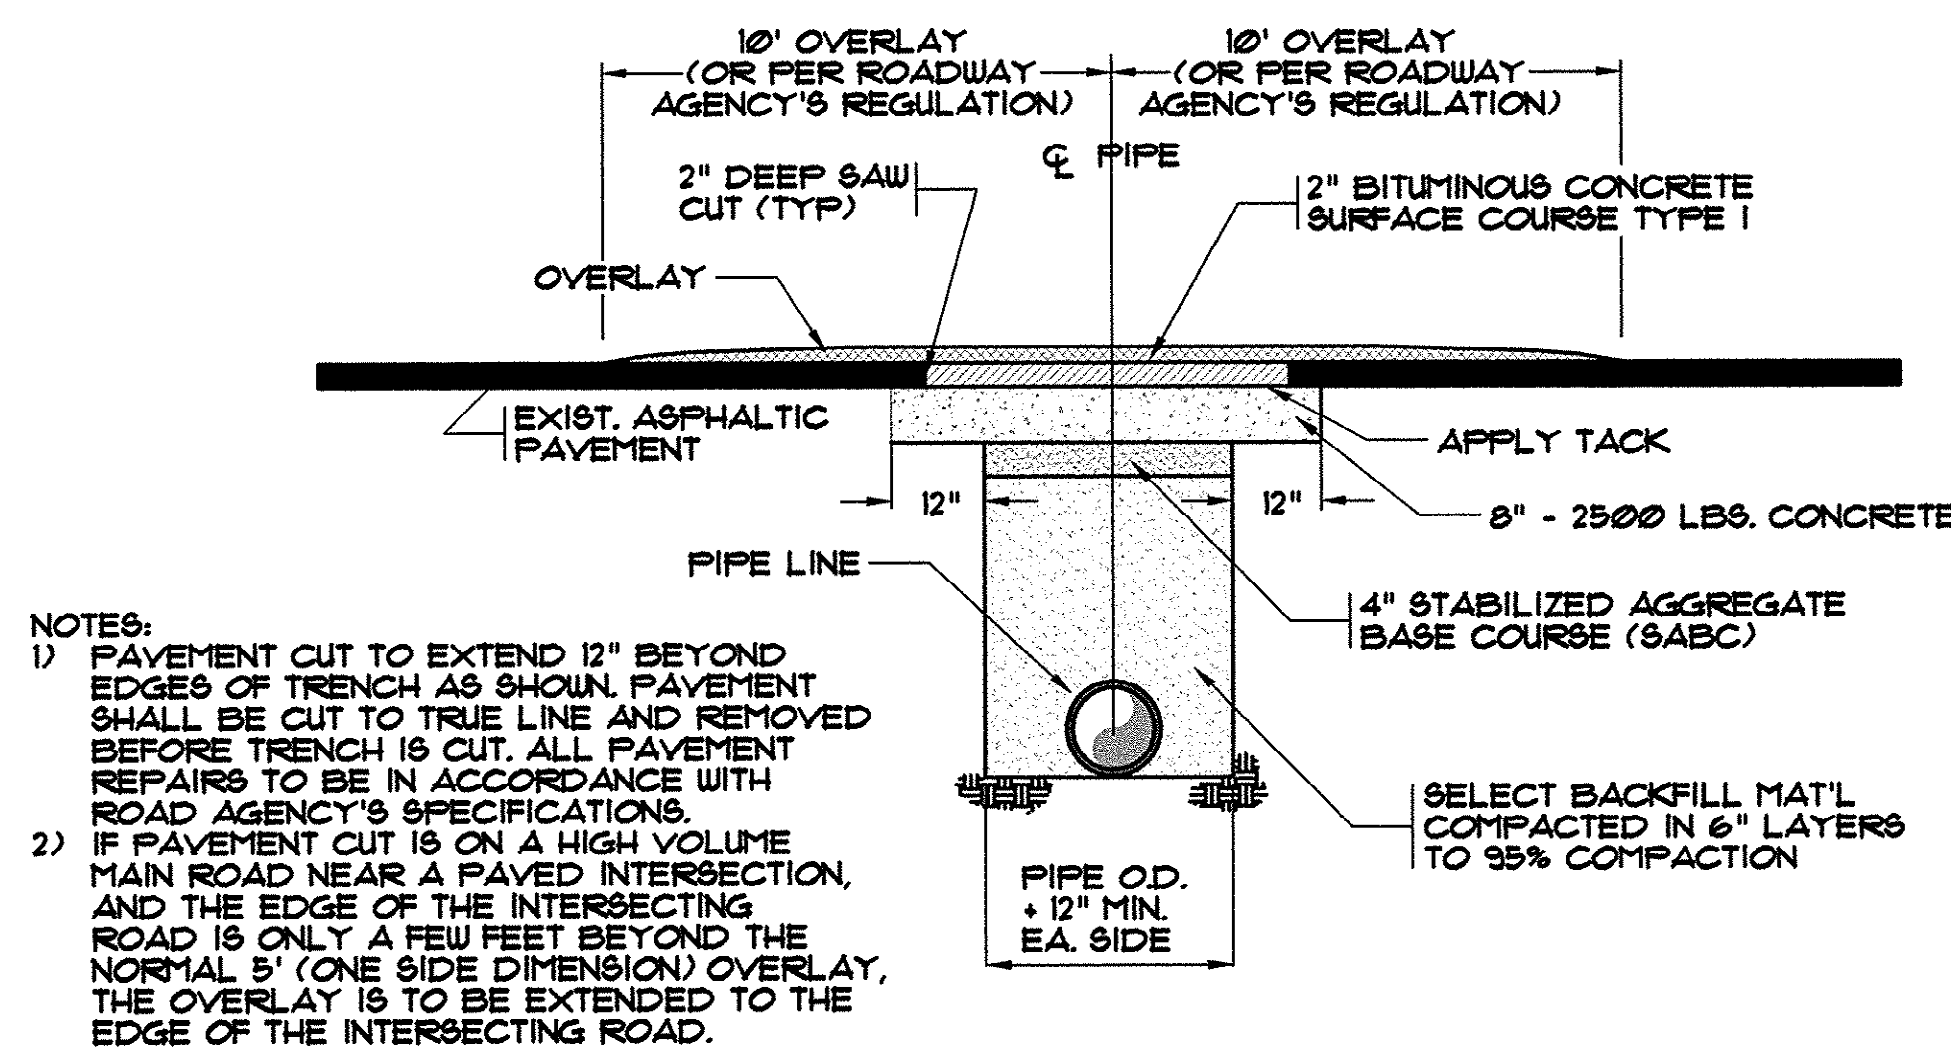


OPEN CUT REPAIR FOR HIGH VOLUME ASPHALT PAVEMENT

N.T.S.

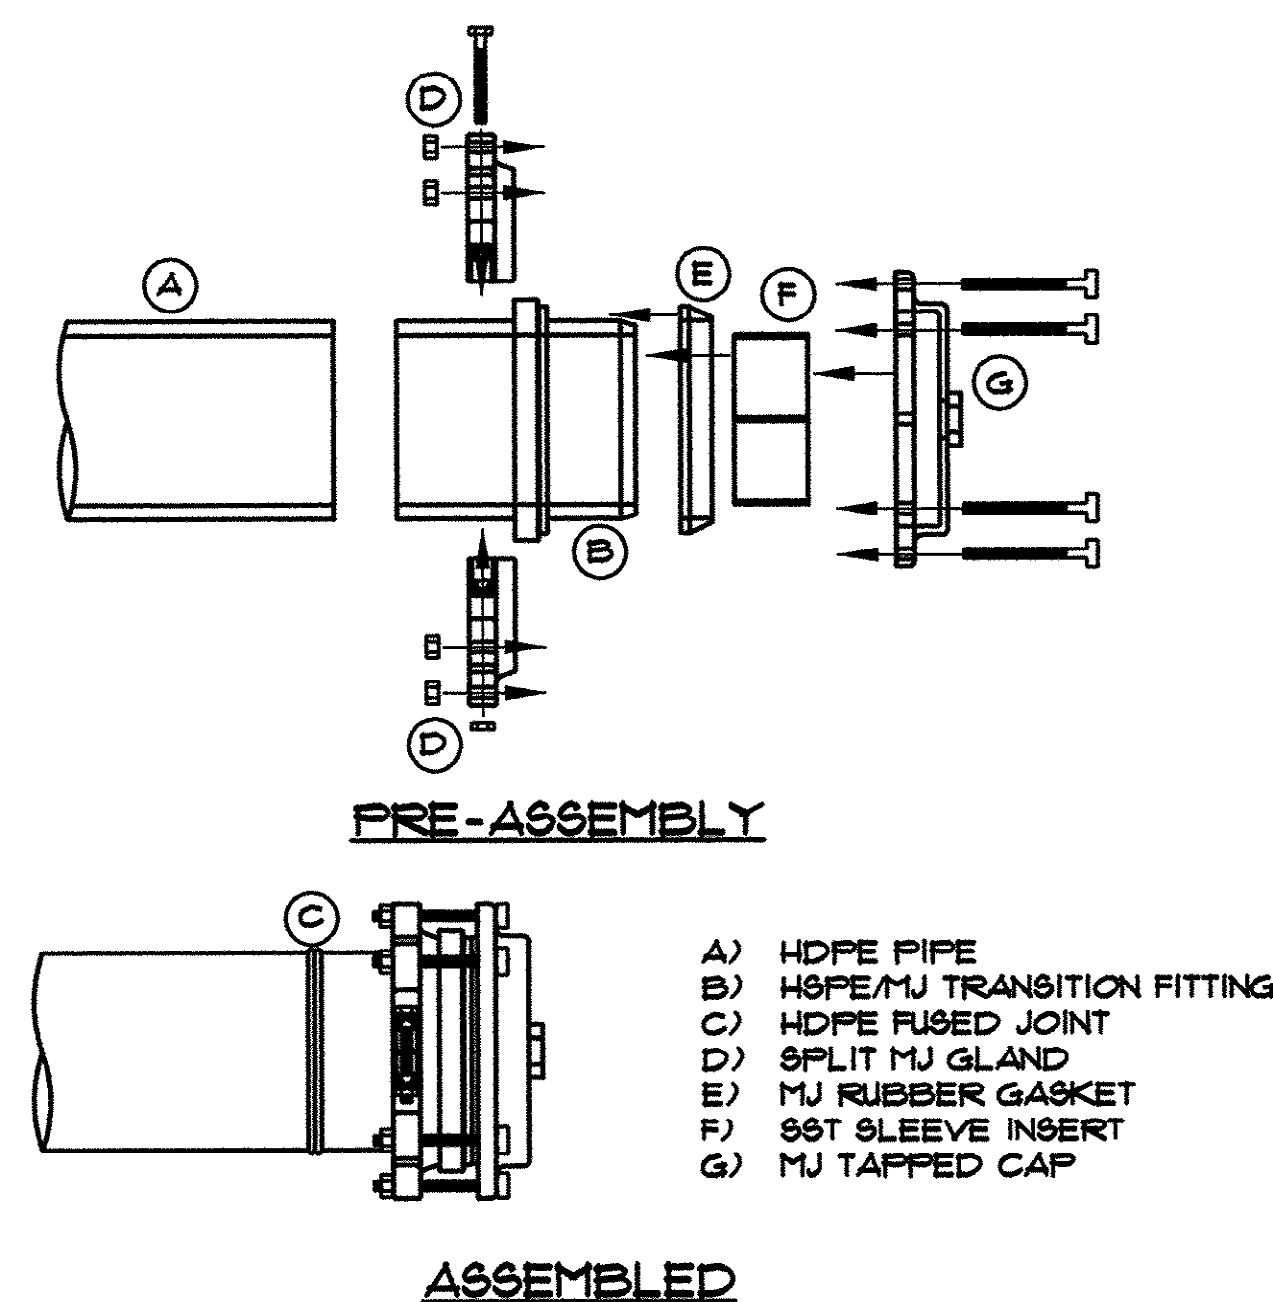


PE/MJ TRANSITION ASSEMBLY

N.T.S.

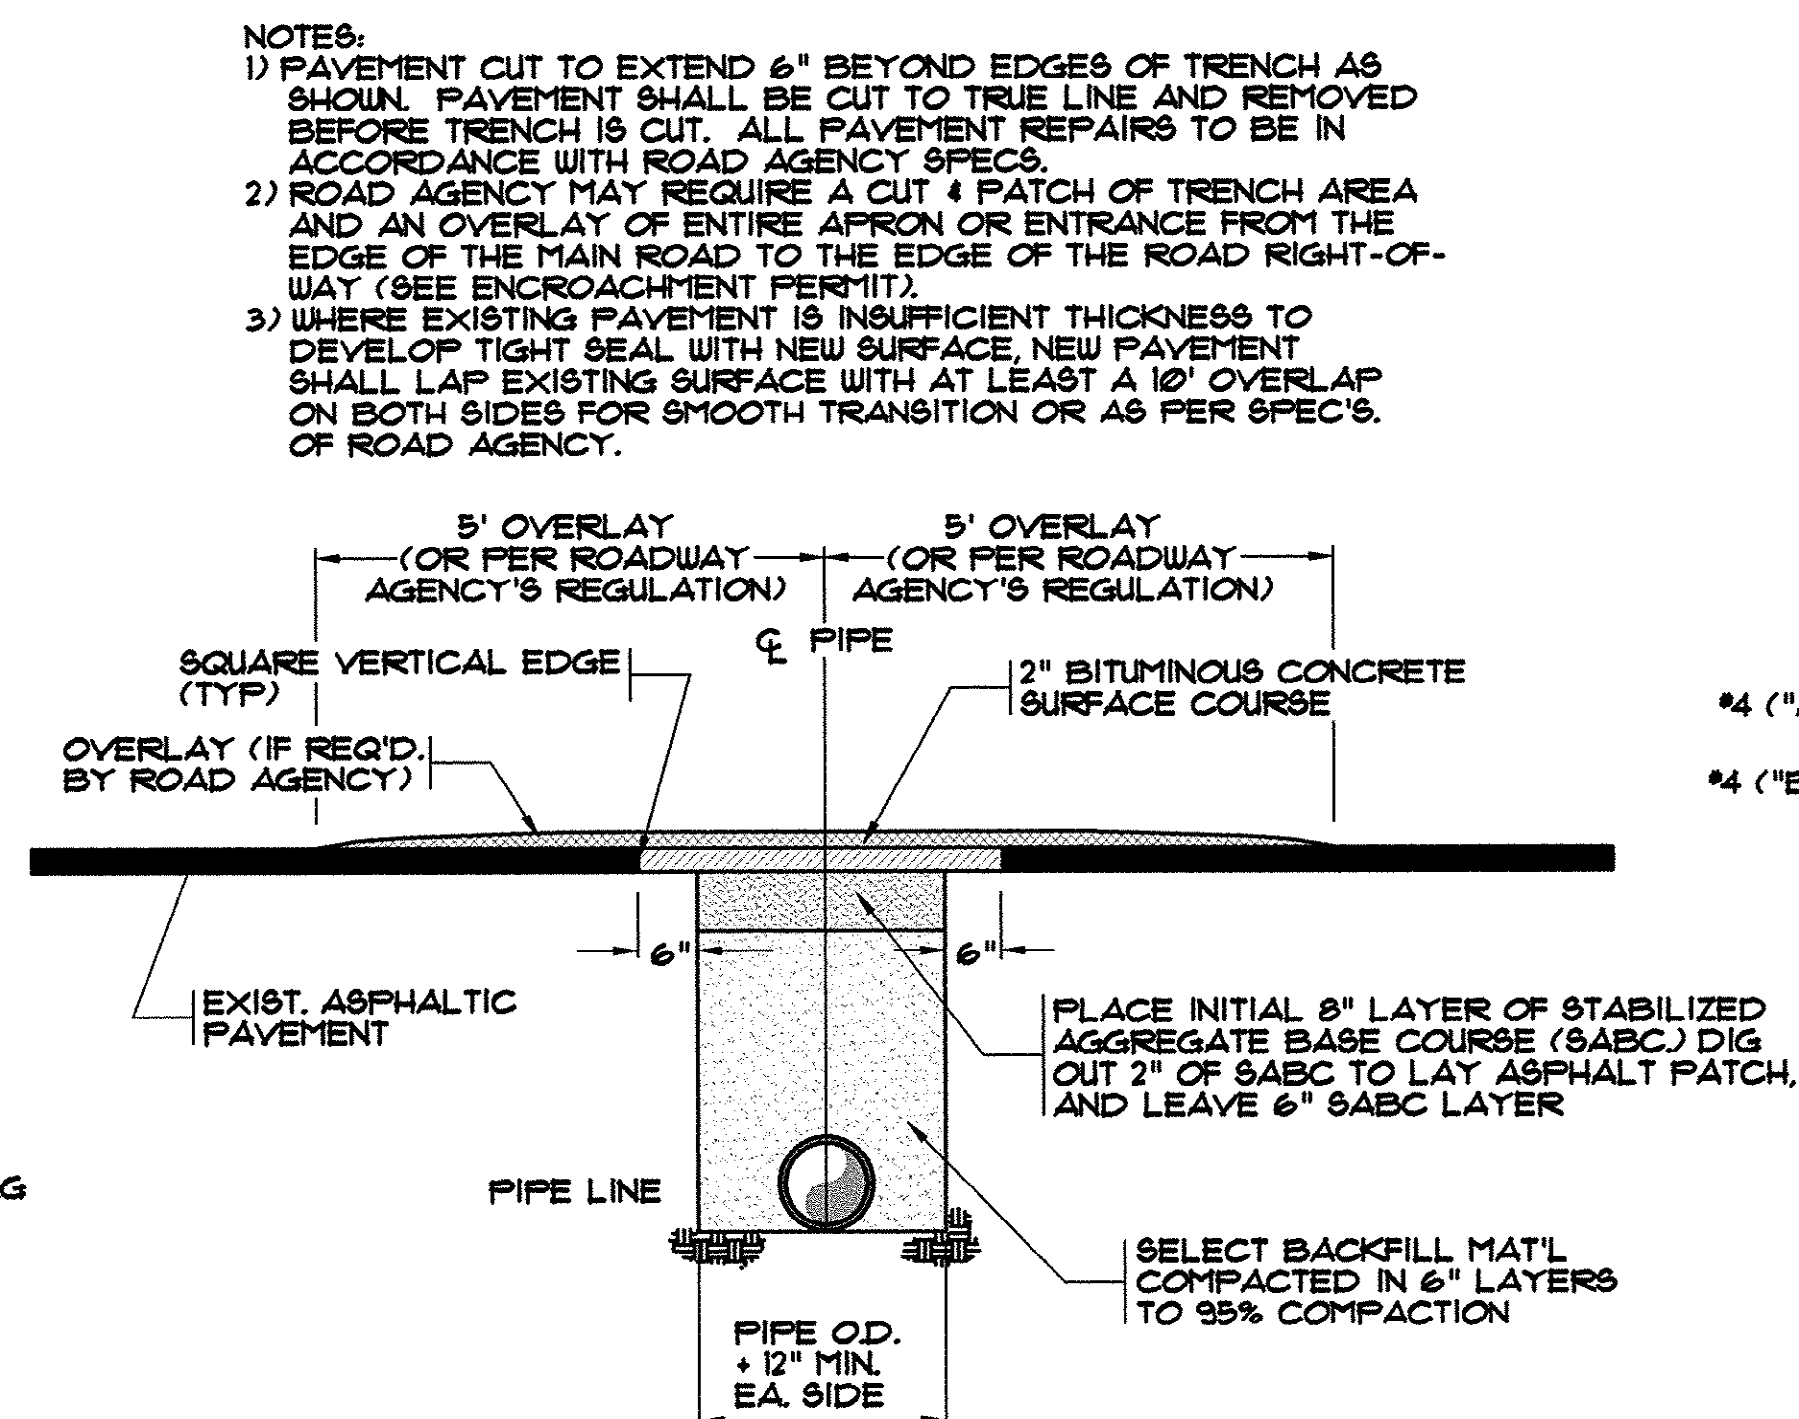


OPEN CUT REPAIR FOR LOW VOLUME ASPHALT PAVEMENT

N.T.S.

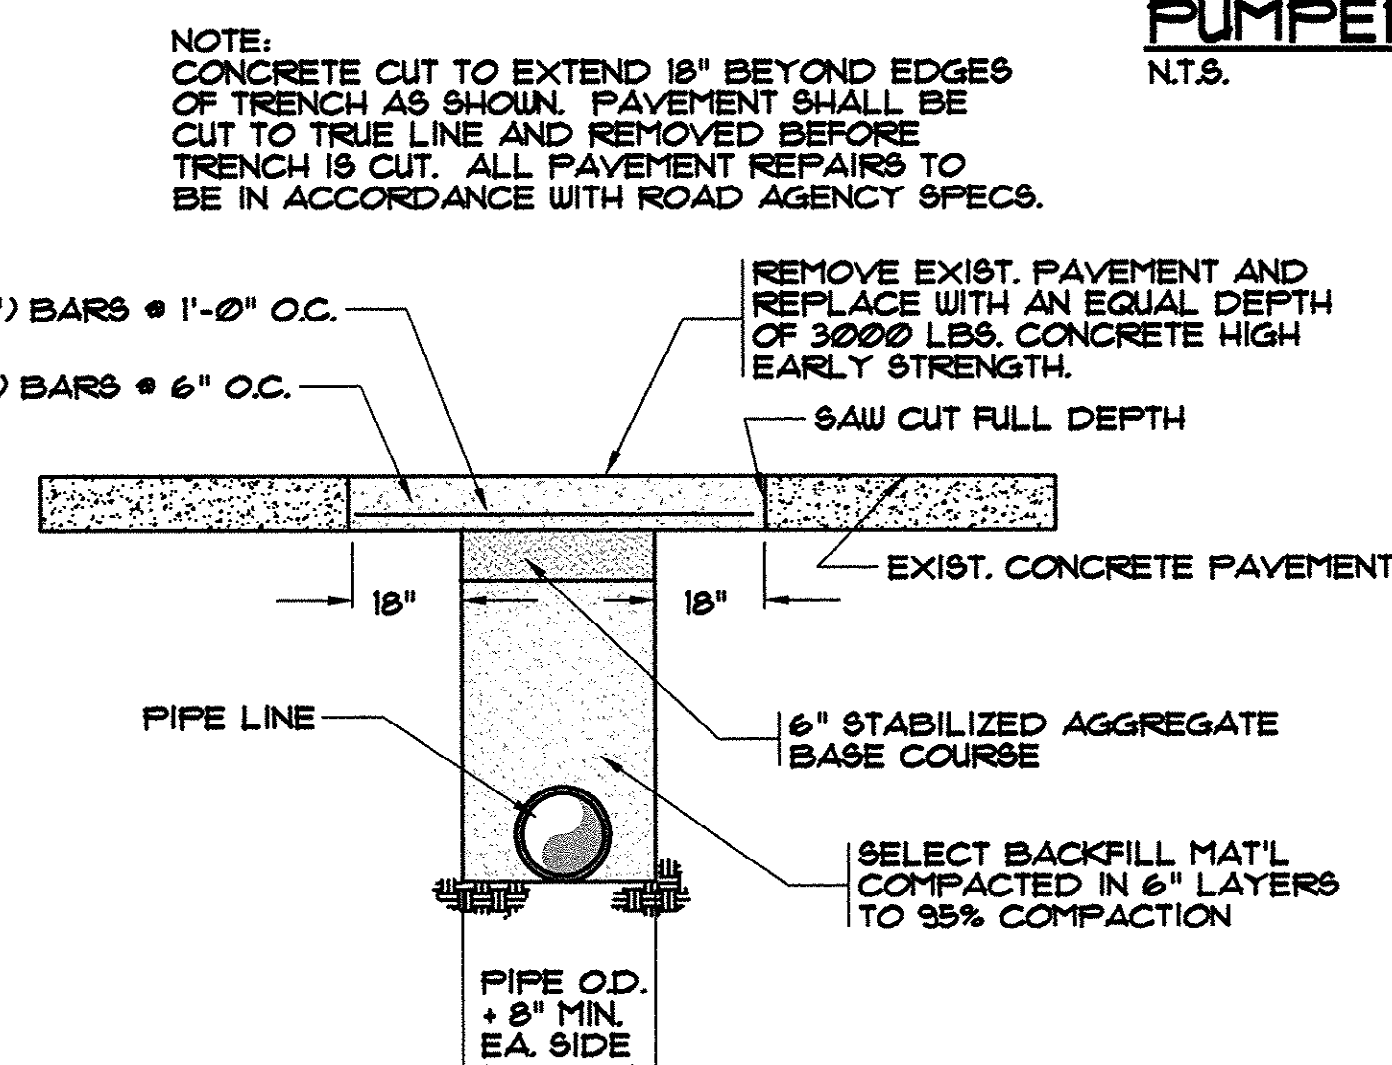


OPEN CUT REPAIR FOR CONCRETE PAVEMENT

N.T.S.

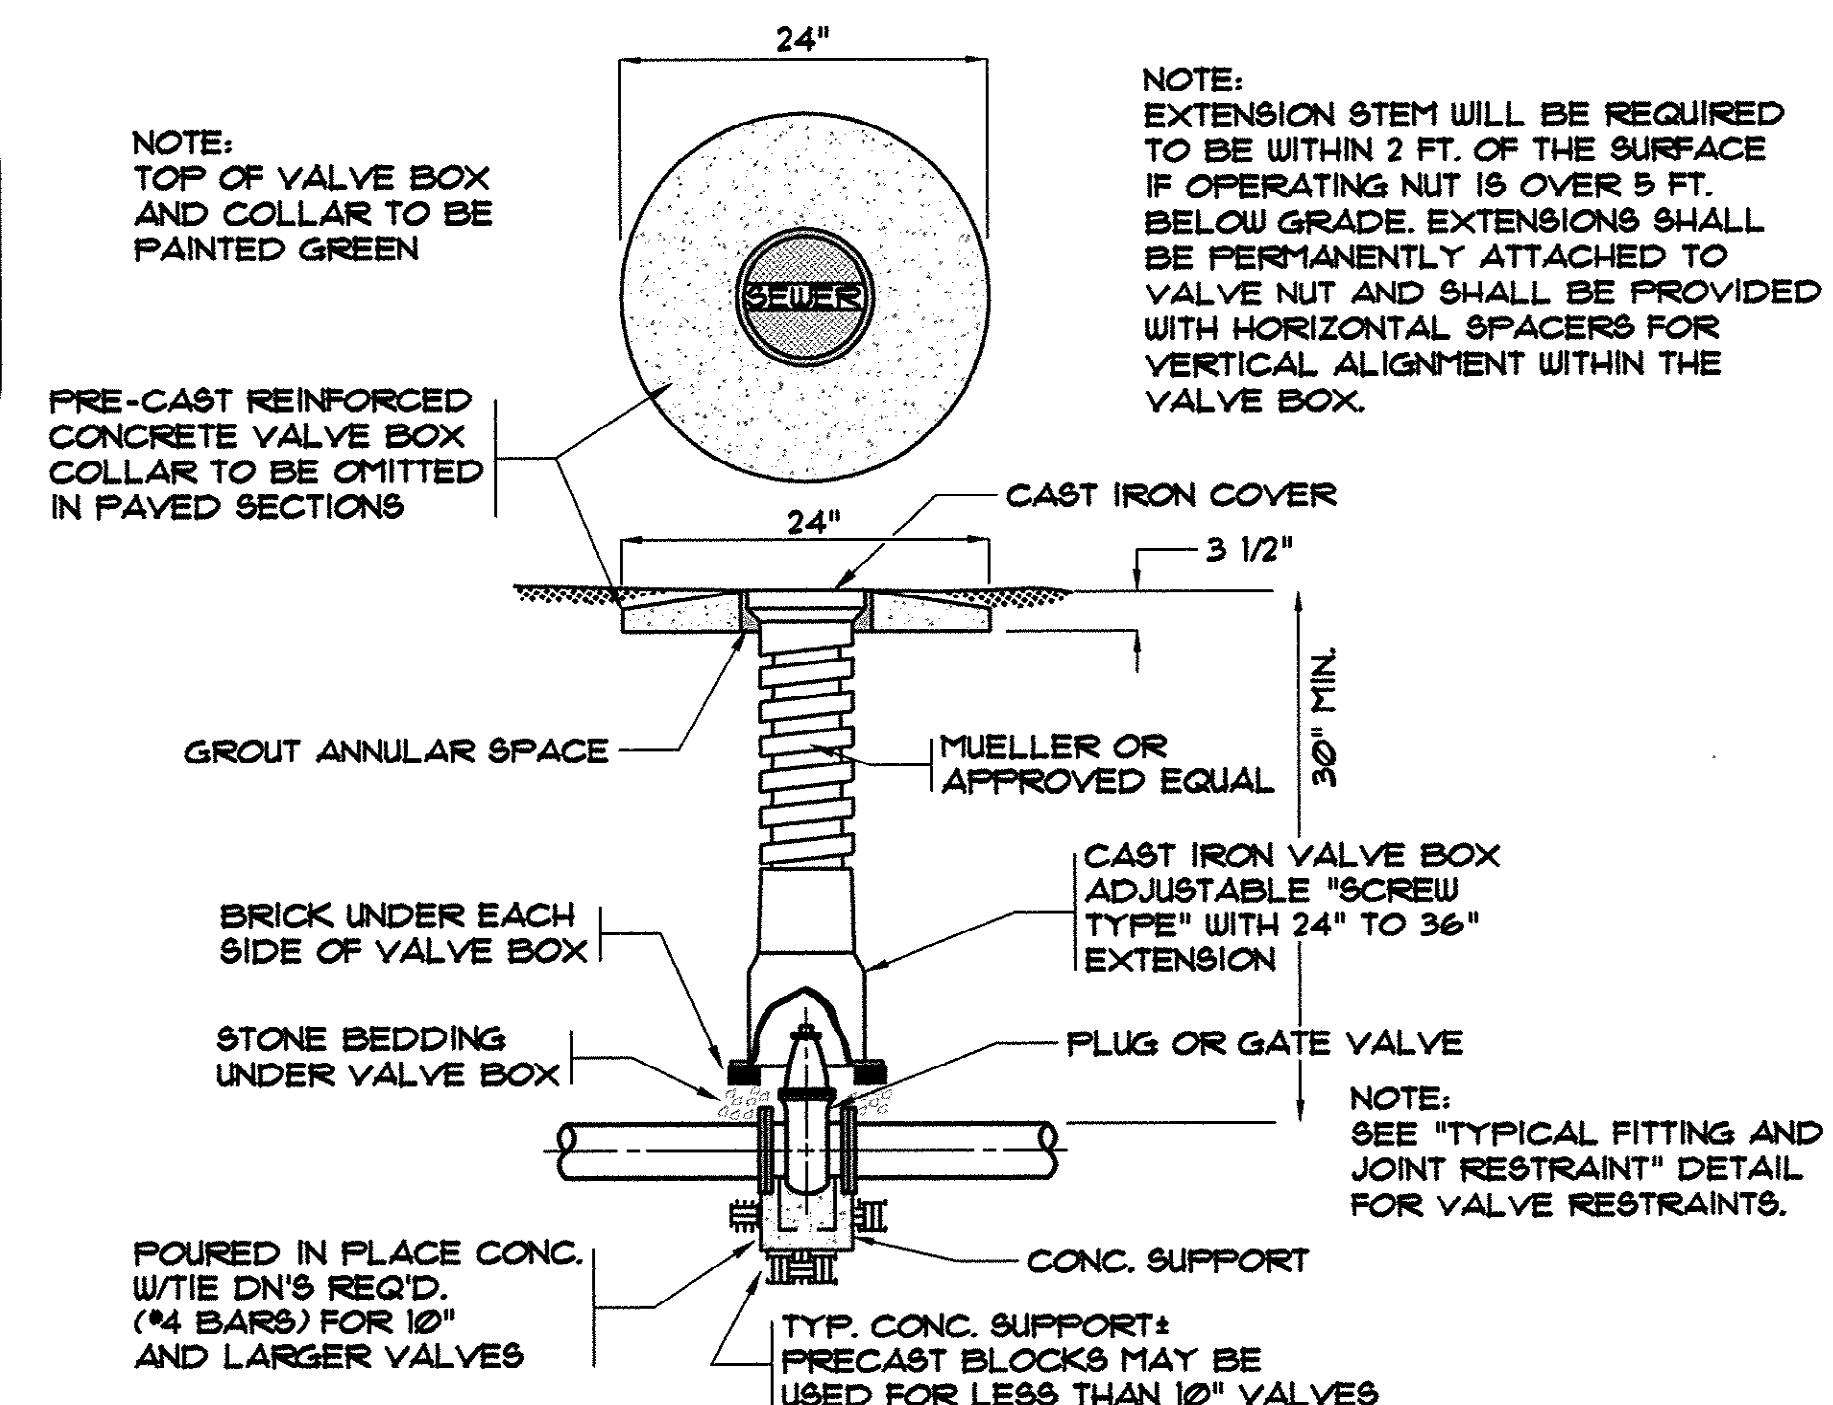


TYPICAL VALVE AND VALVE BOX

N.T.S.

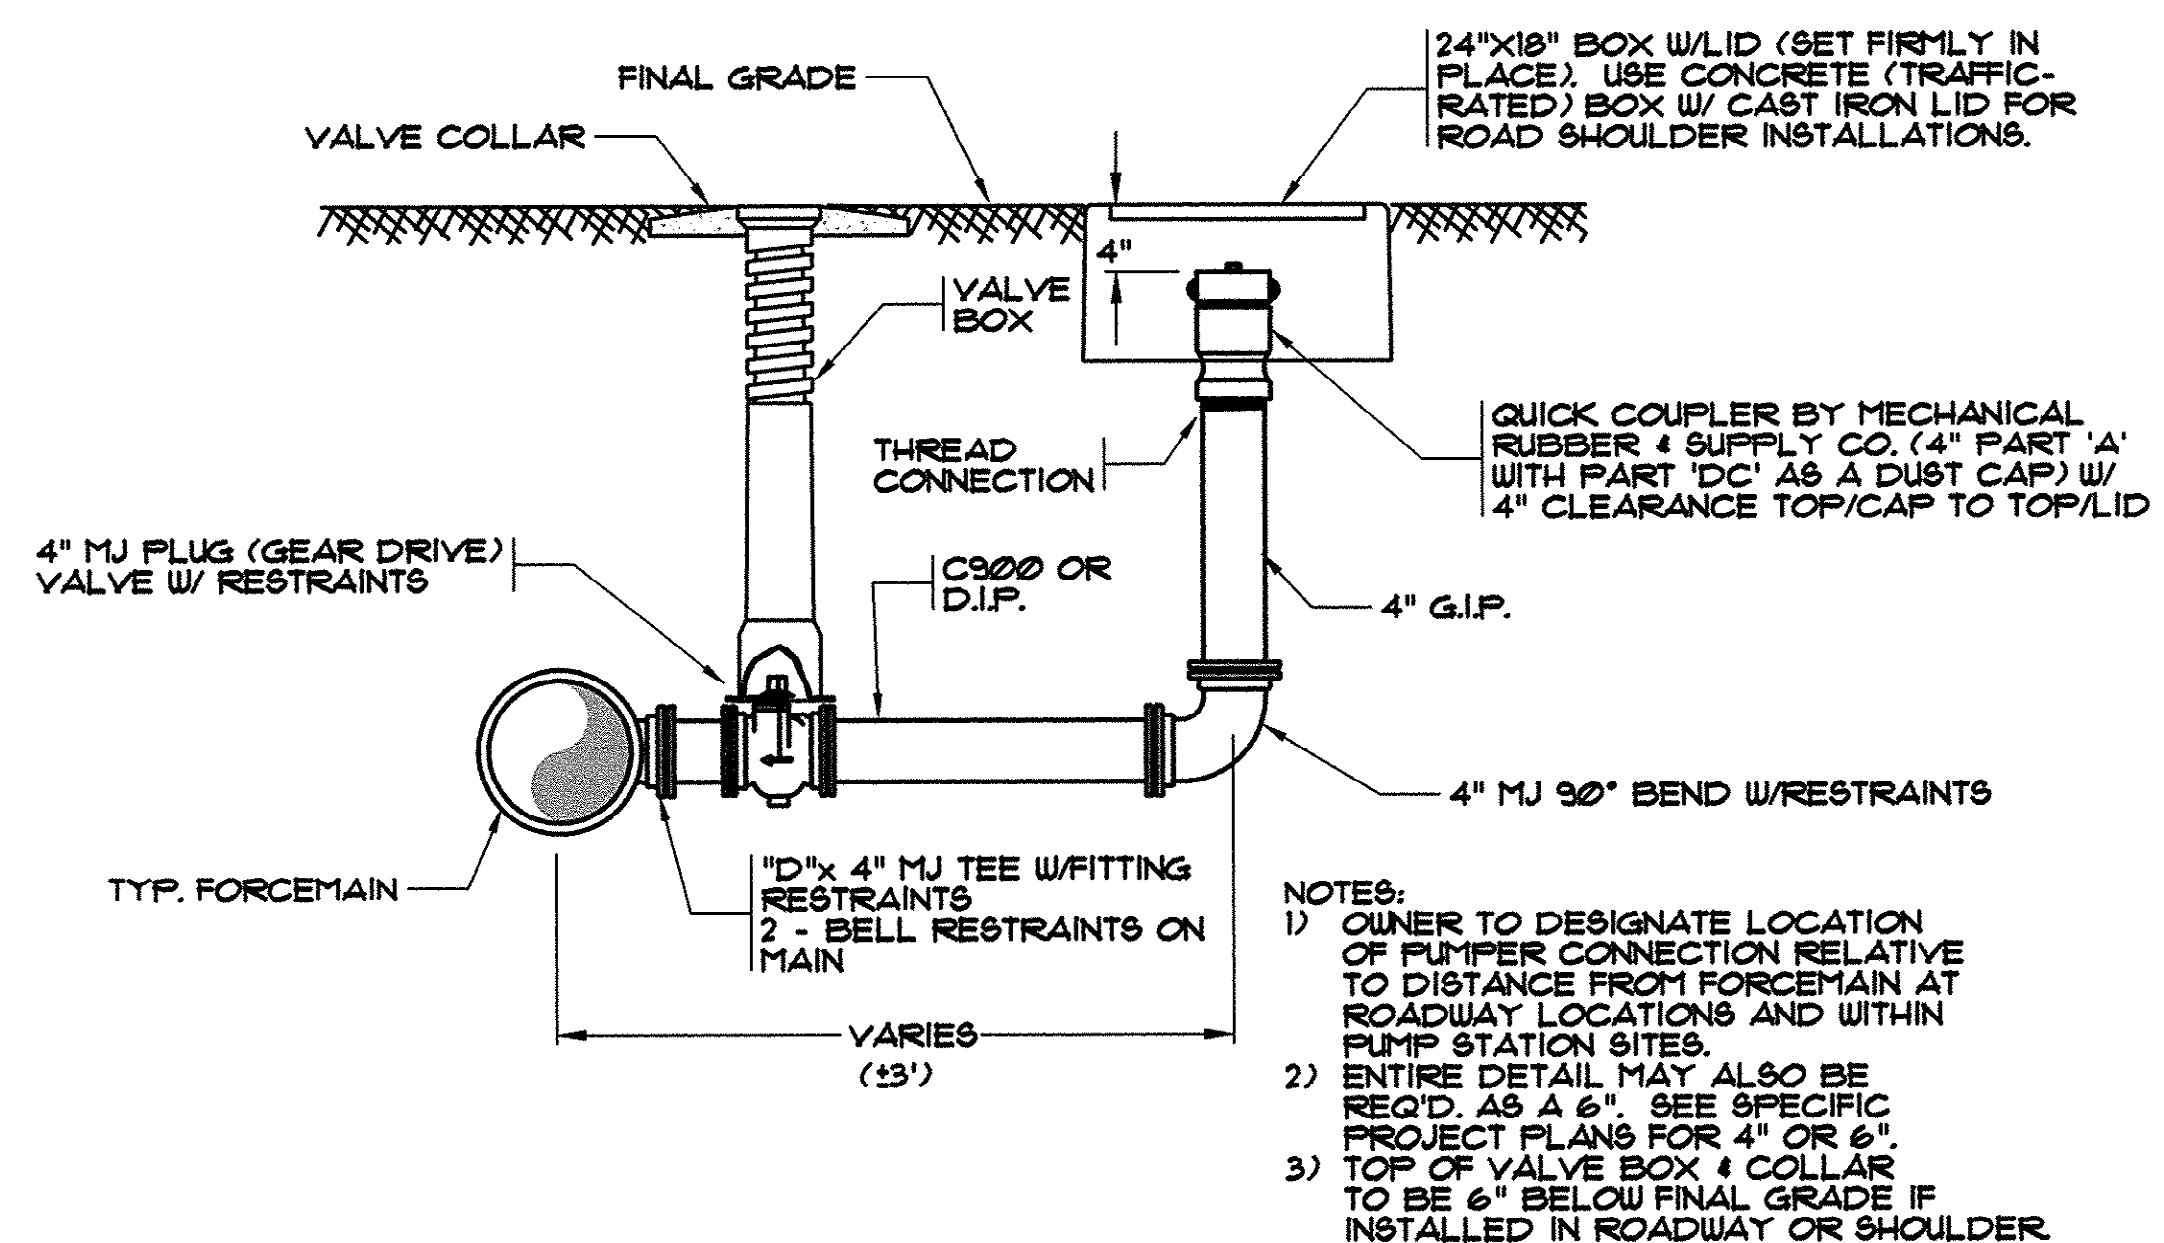

PUMPER CONNECTION DETAIL

N.T.S.

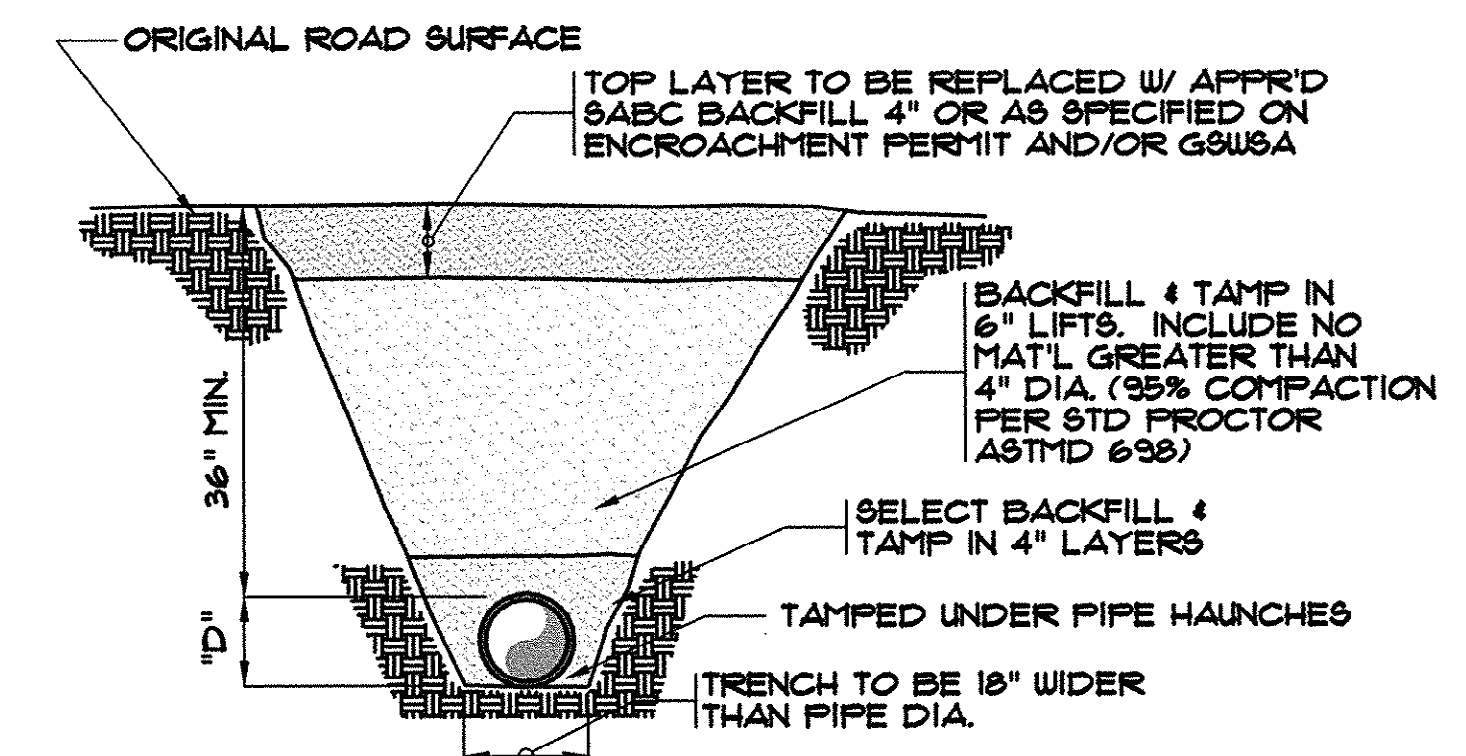


UNPAVED ROADWAY BEDDING DETAIL

N.T.S.

45-003-040/53

DATE	BY	REVISIONS
6/6/97	BEB	DESCRIPTION
10/27/00	AS-BUILT	GWSA REVISIONS
8/01/01	CAR	AS-BUILT

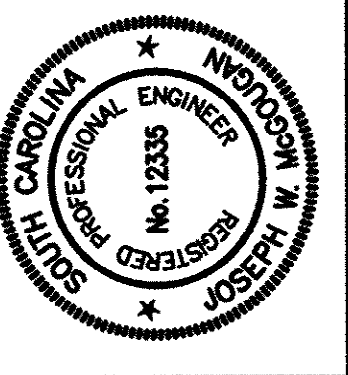

HOBBBS, UPCHURCH & ASSOCIATES, PA.
CONSULTING ENGINEERS
MYRTLE BEACH, SOUTH CAROLINA 29577



MISCELLANEOUS
DETAILS


TIP-TOP TREE FARM
EFFLUENT LAND
APPLICATION PROJECT
GRAND STRAND WATER
AND SEWER AUTHORITY

DATE:	MAR. 1999
DESIGNED:	WDL
DRAWN:	KLM
CHECKED:	WDL
SCALE:	AS SHOWN
SHEET NO.	

DT-2



5

HOBBS, UPCHURCH & ASSOC. MB J:\GS9901\8001\820\Contract 2\asubills\w_xing1.dwg EDITED BY: ARABON DATE: 07/23/01 TIME: 09:52 Layout: Model


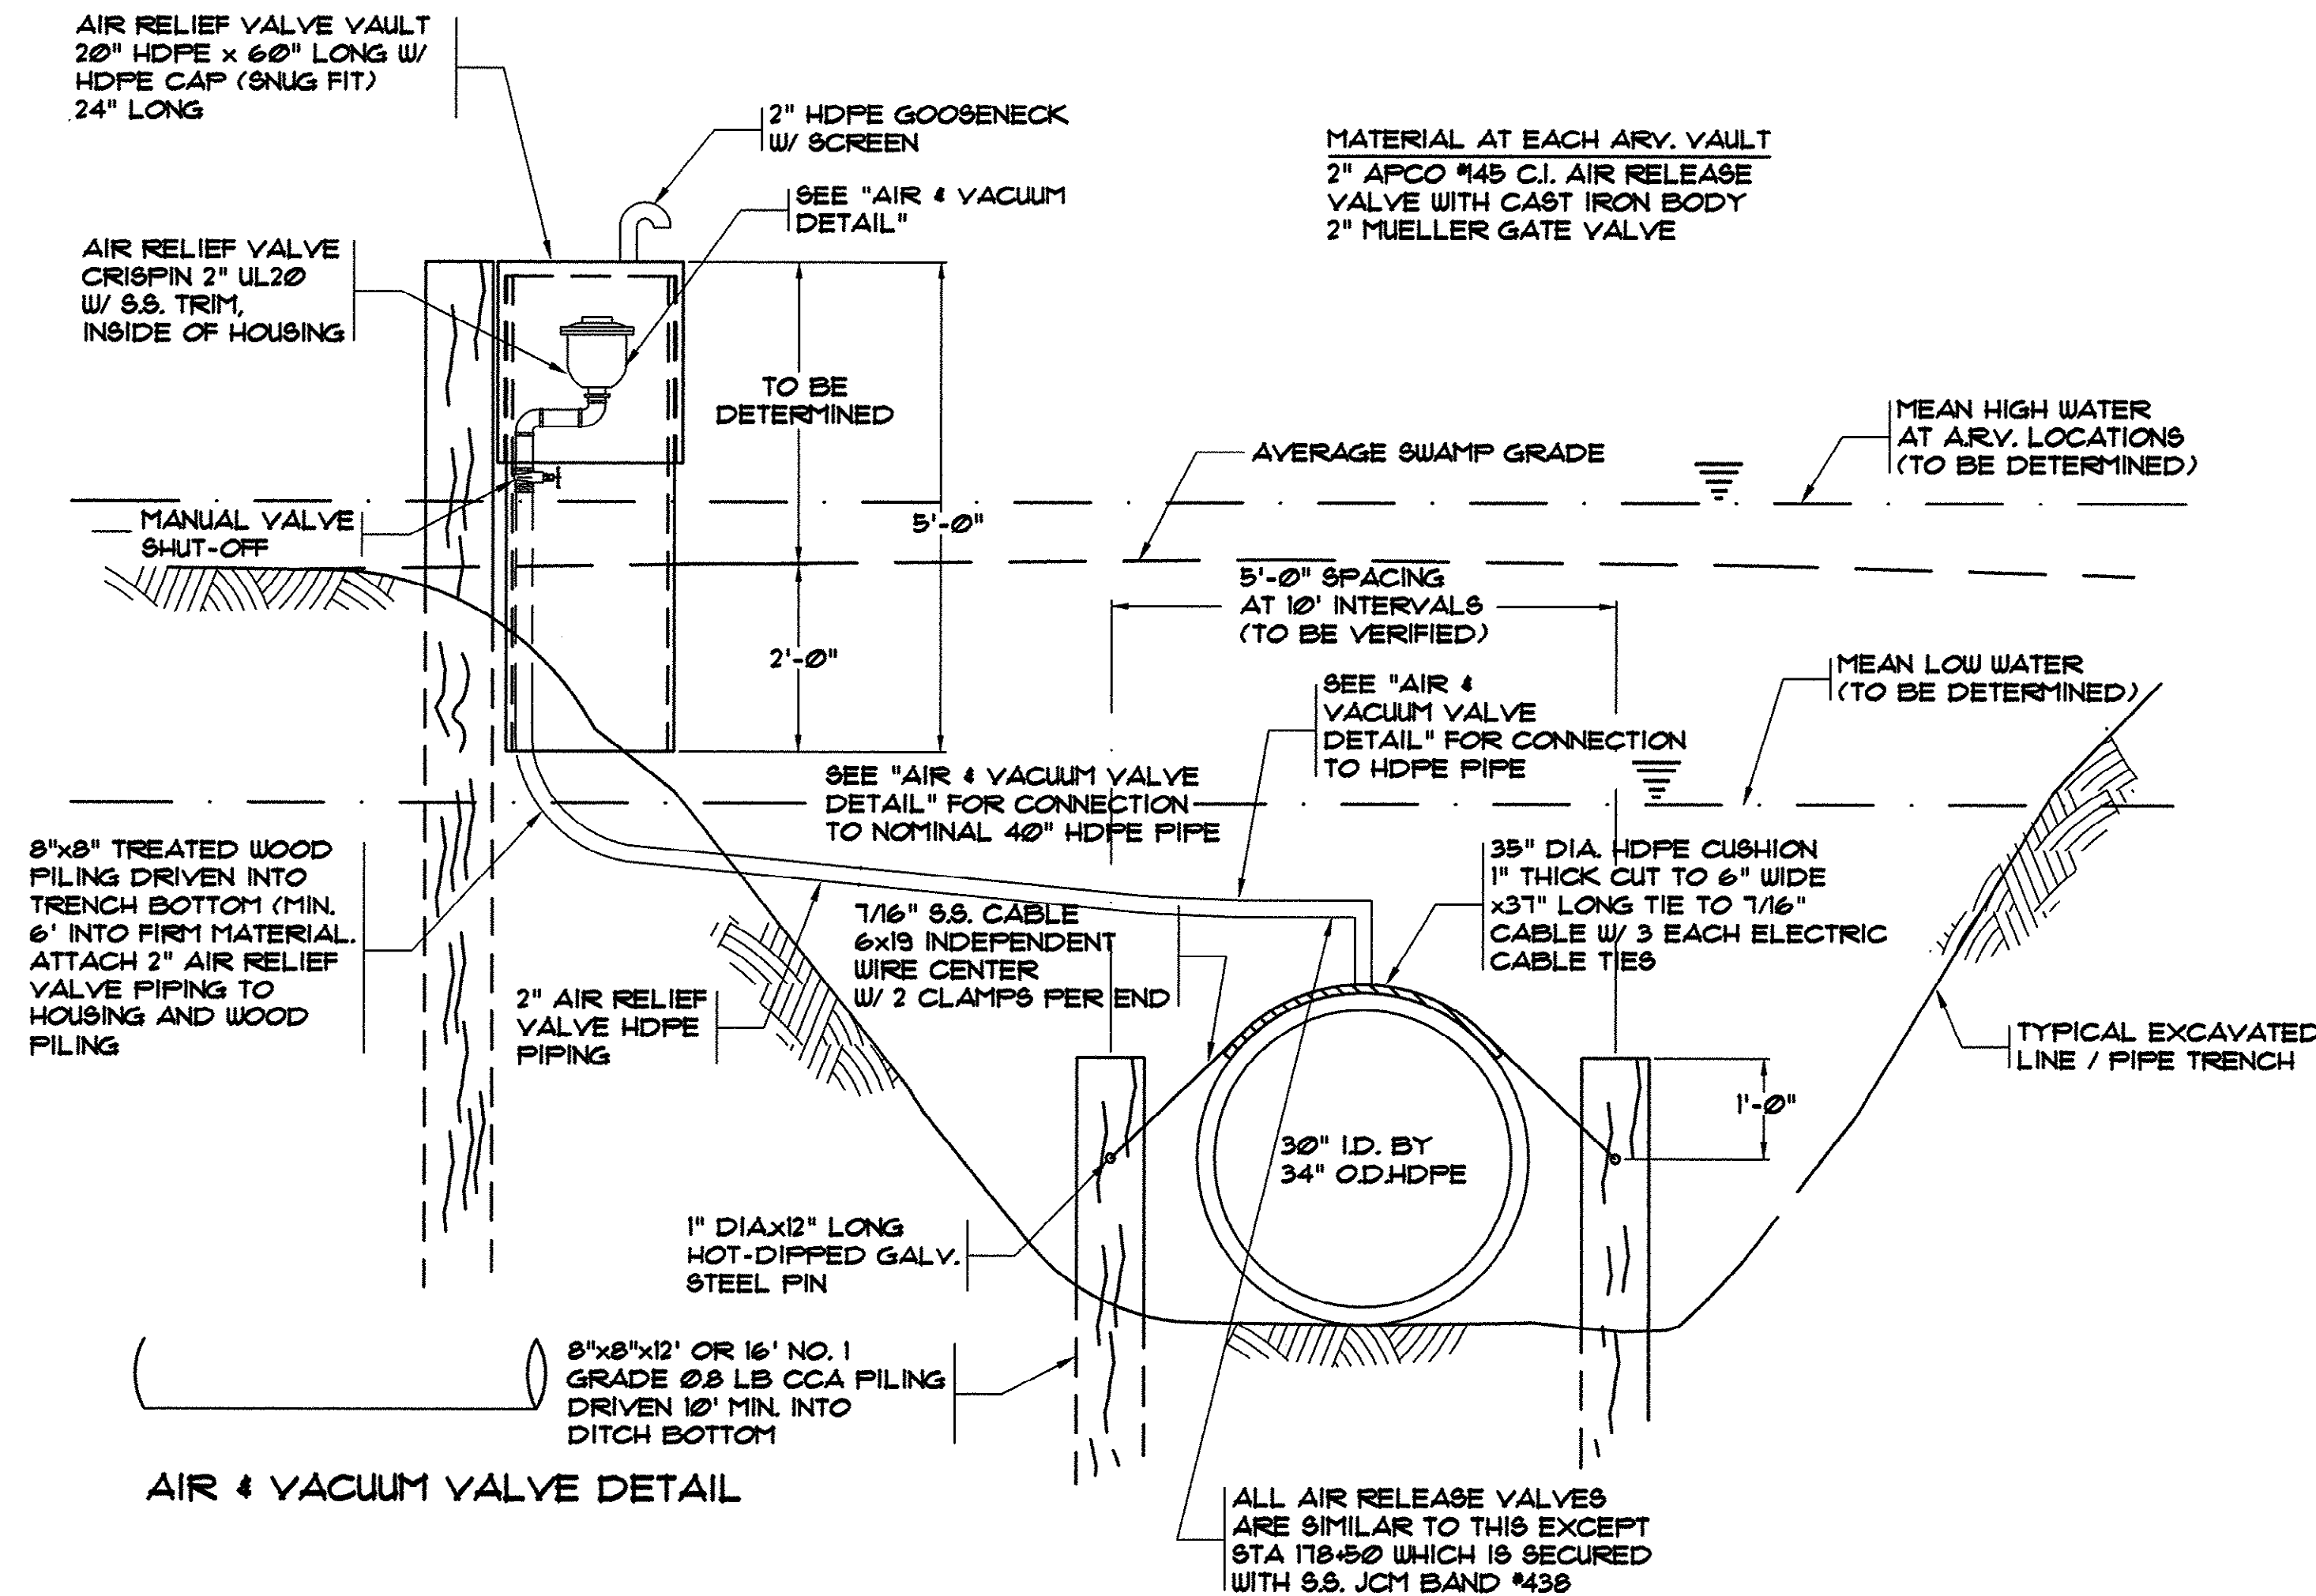


TIE-DOWN & AIR VACUUM RELEASE VAULT DETAIL


SCALE: 3/4" = 1'-0"

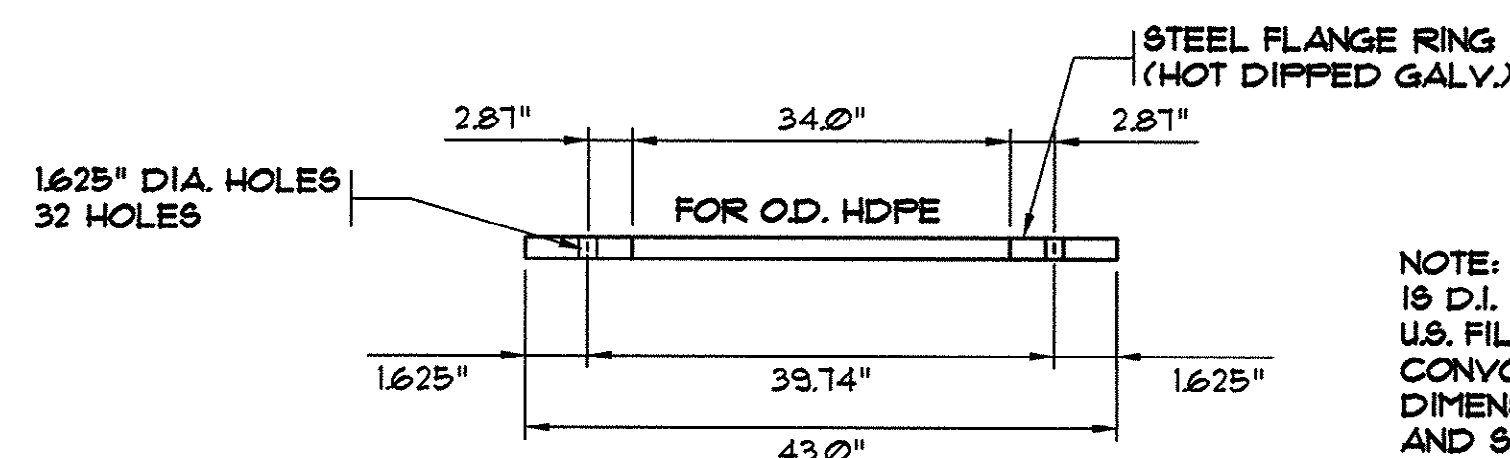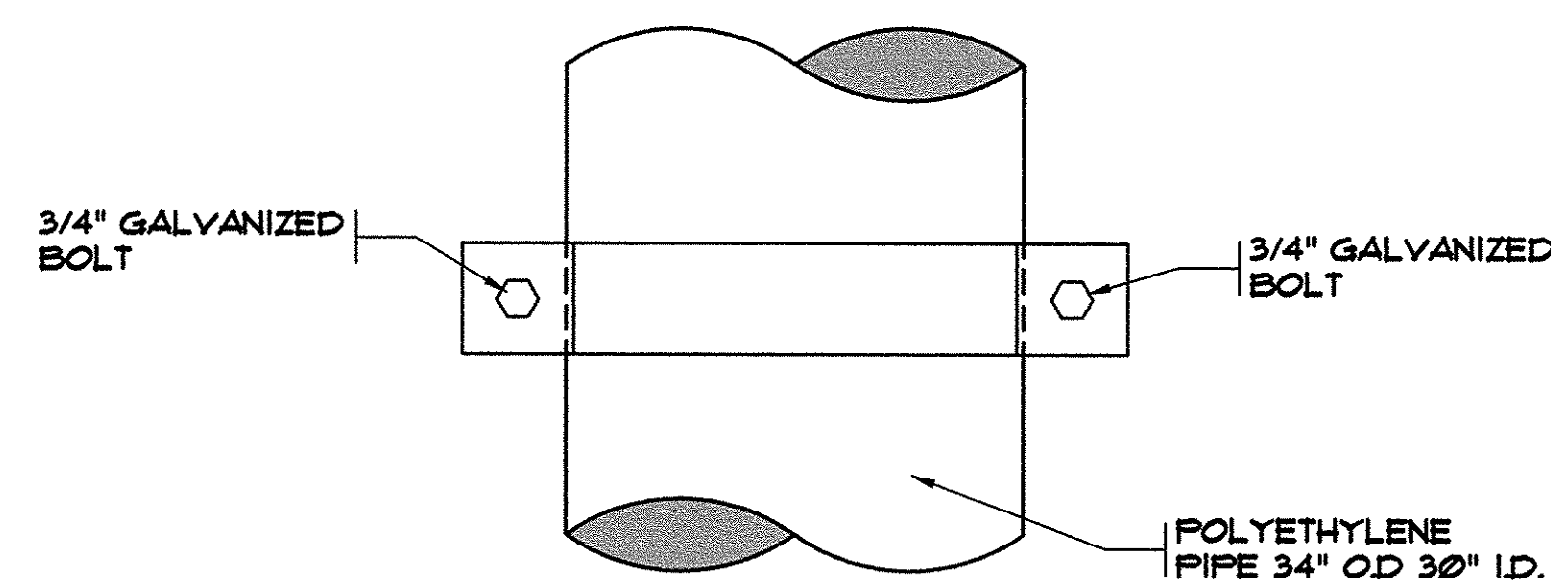

NOTE: ALTERNATE TO G.I. FLANGE
IS D.I. BACK UP PER
U.S. FILTER/DRISCO PIPE
CONVULGATED TYPE.
DIMENSIONS ARE APPROX. ONLY
AND SHALL BE VERIFIED THRU
SUBMITTAL APPROVALS

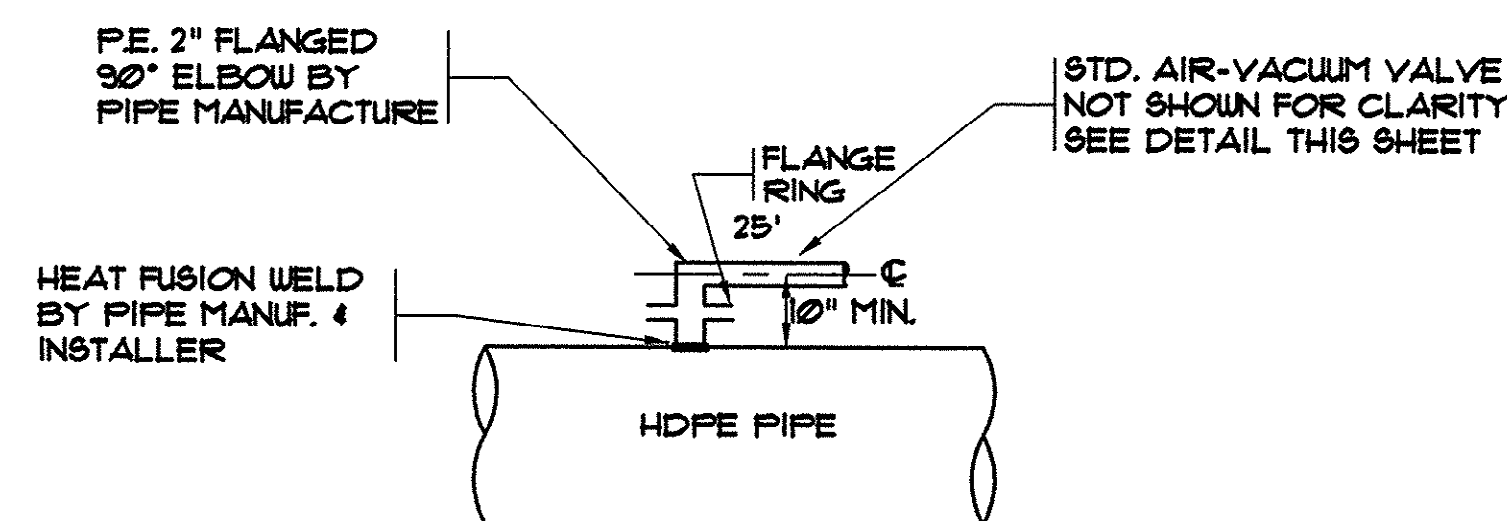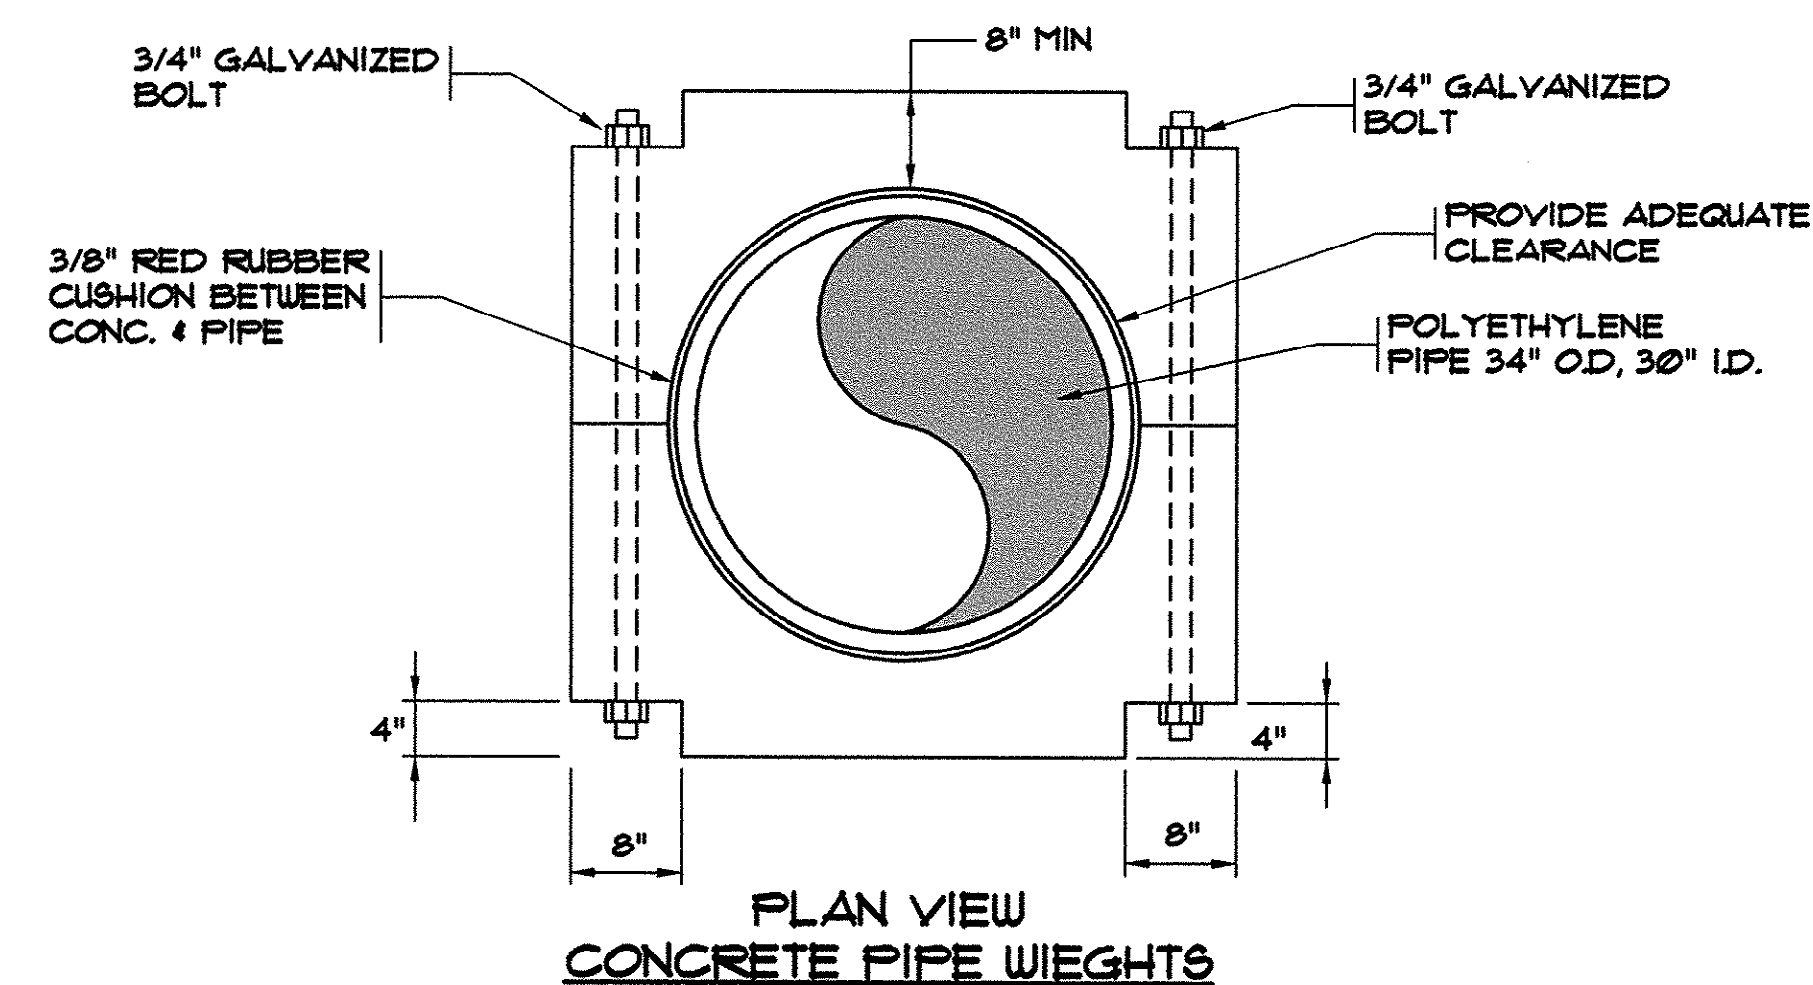


THESE DRAWINGS REFLECT AS-BUILT CONDITIONS	
REVIEWED BY:	DATE
INSPECTIONS	
REVIEWED BY:	DATE
ENGINEERING	
GRAND STRAND WATER AND SEWER AUTHORITY	

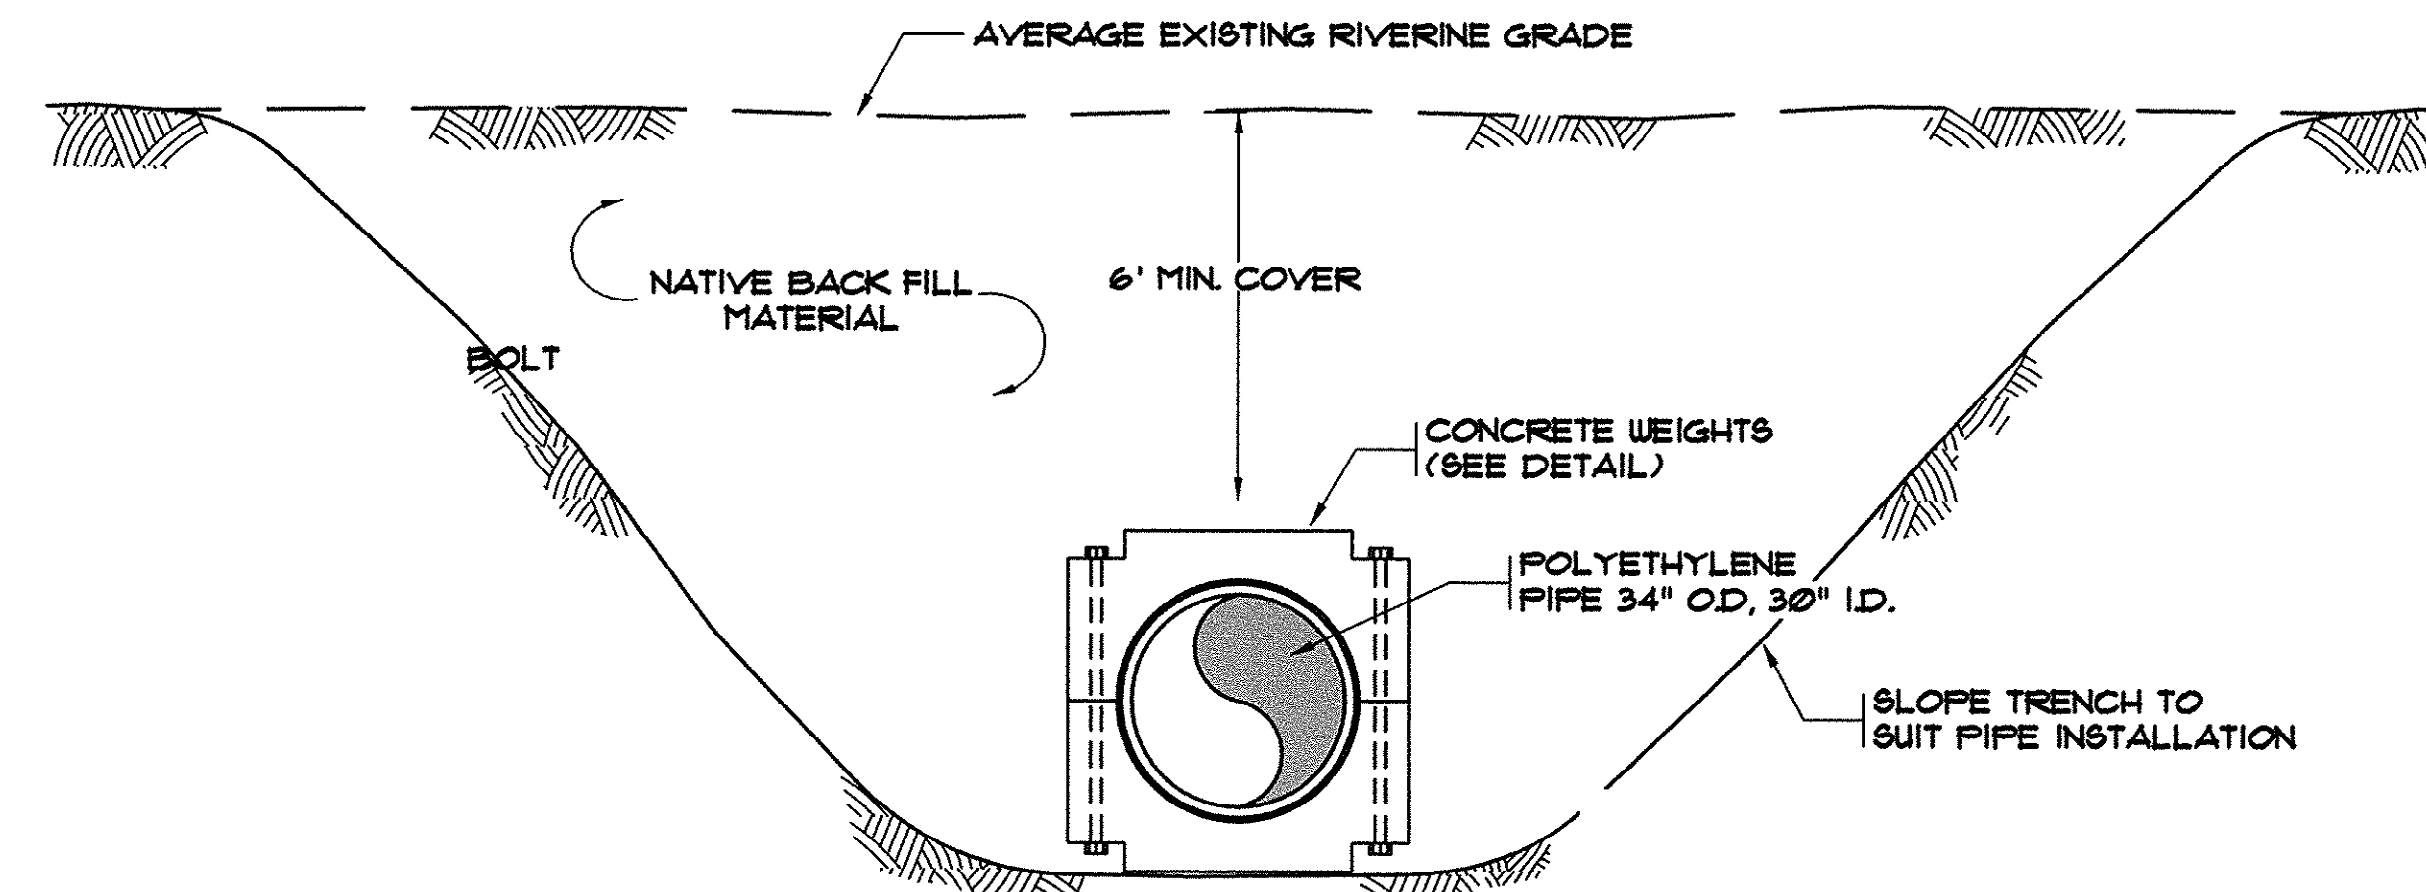


NOTES:


- WOOD PIPE TIE-DOWNS
TO BE USED IN ALL AREAS
WHERE CONCRETE WEIGHTS
ARE NOT BEING INSTALLED
THROUGH MARSH AREAS
- CONTRACTOR IS TO PROVIDE
ENGINEERING SUBMITTALS
FOR APPROVAL FOR ALL
PROPOSED WOOD PIPE
TIE-DOWNS, INCLUDING
CALCULATIONS FOR SIZE
AND SPACING. SEE
CONTRACT 3 REQUIREMENTS.

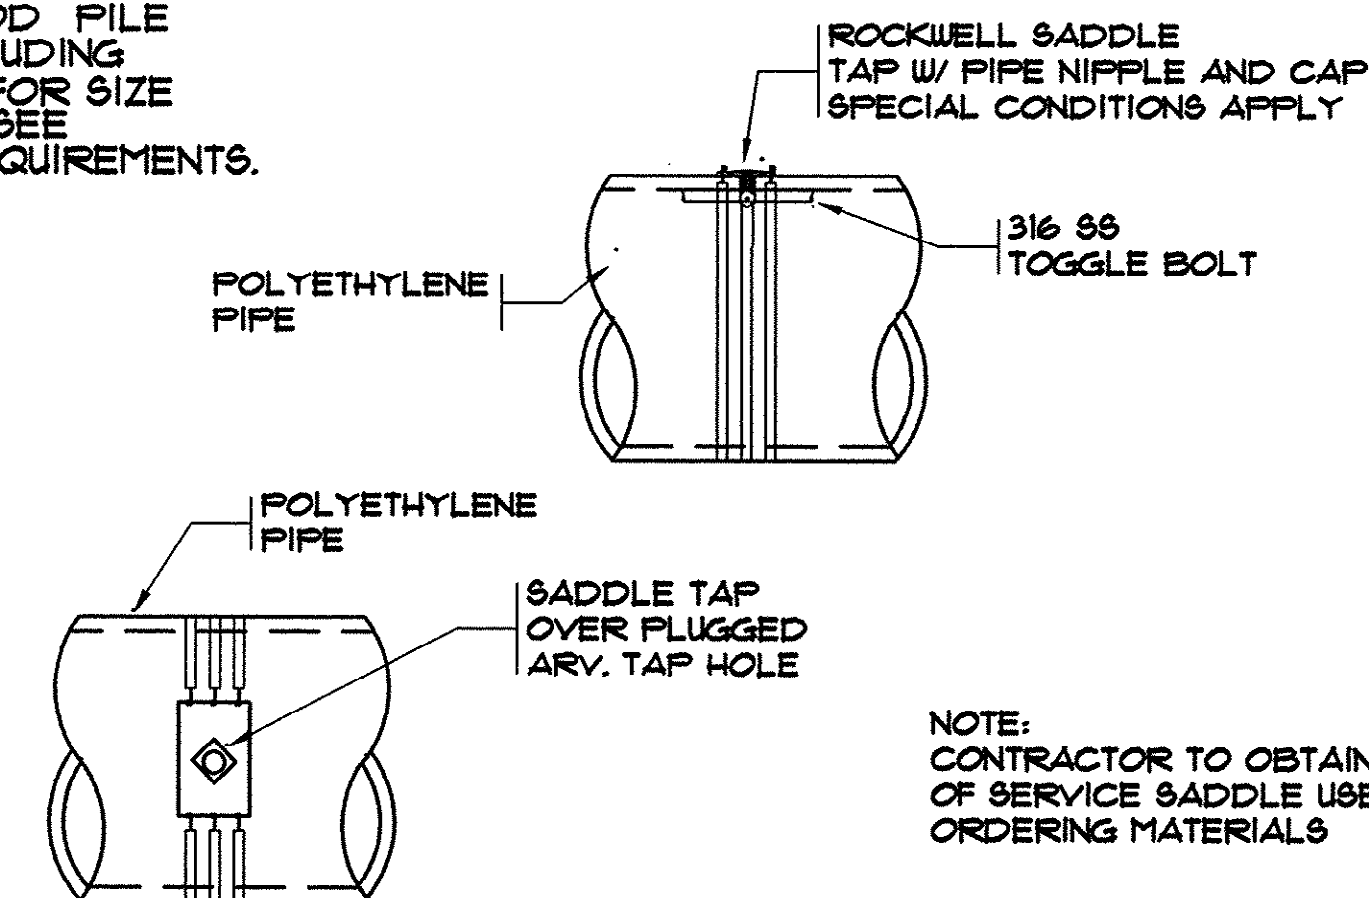

- NOTE:
- APPROXIMATE LENGTH OF PIPE
REQUIRING CONCRETE WEIGHTS
IS 150 FEET. WEIGHTS FOR
RIVER AND SOME CREEK AREAS
TO BE USED.
 - CONTRACTOR IS TO PROVIDE
ENGINEERING SUBMITTALS FOR
APPROVAL ALL PROPOSED CONC.
ANCHOR MANUFACTURING DETAILS
INCLUDING CALCULATIONS
DETERMINING SIZE & SPACING FOR
CONCRETE ANCHORS. SEE
CONTRACT 3 REQUIREMENTS.

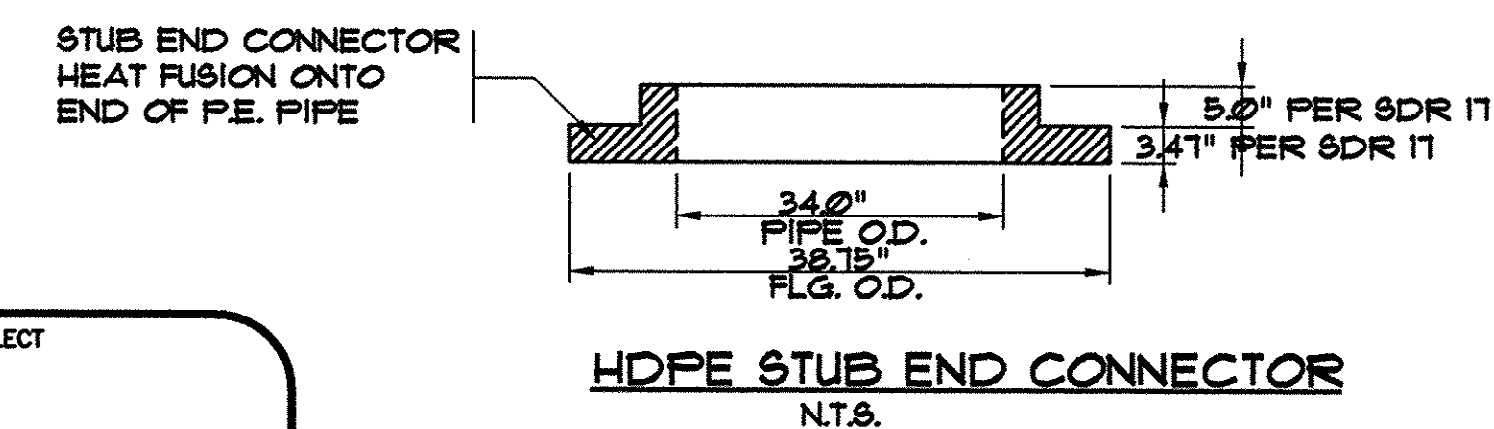

SYN.	DESCRIPTION	DATE	BY
6"	SLOPE LINE SHOWN	10/5/00	AS-BUILT
	AS-BUILT	7/23/01	CAR

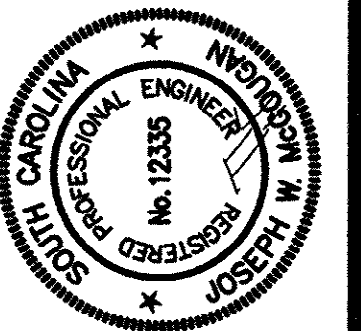

HOBBS, UPCHURCH & ASSOCIATES, P.A.
CONSULTING ENGINEERS
MYRTLE BEACH, SOUTH CAROLINA 29577



MISCELLANEOUS
DETAILS

TIP-TOP TREE FARM
EFFLUENT LAND
APPLICATION PROJECT
GRAND STRAND WATER
AND SEWER AUTHORITY

DATE:	MAR. 1999
DESIGNED:	WDL
DRAWN:	KLM
CHECKED:	WDL
SCALE:	AS SHOWN

SHEET NO.

DT-3

OF: 5

45-003/040/53




(NOT TO SCALE)



TIP-TOP TREE FARM EFFLUENT LAND APPLICATION PROJECT

5


MB J:\GS9901\800\820\Contract 2\submittals\DETAILS.dwg EDITED BY: ARABON DATE: 08/01/01 TIME: 08:06 Layout: Model

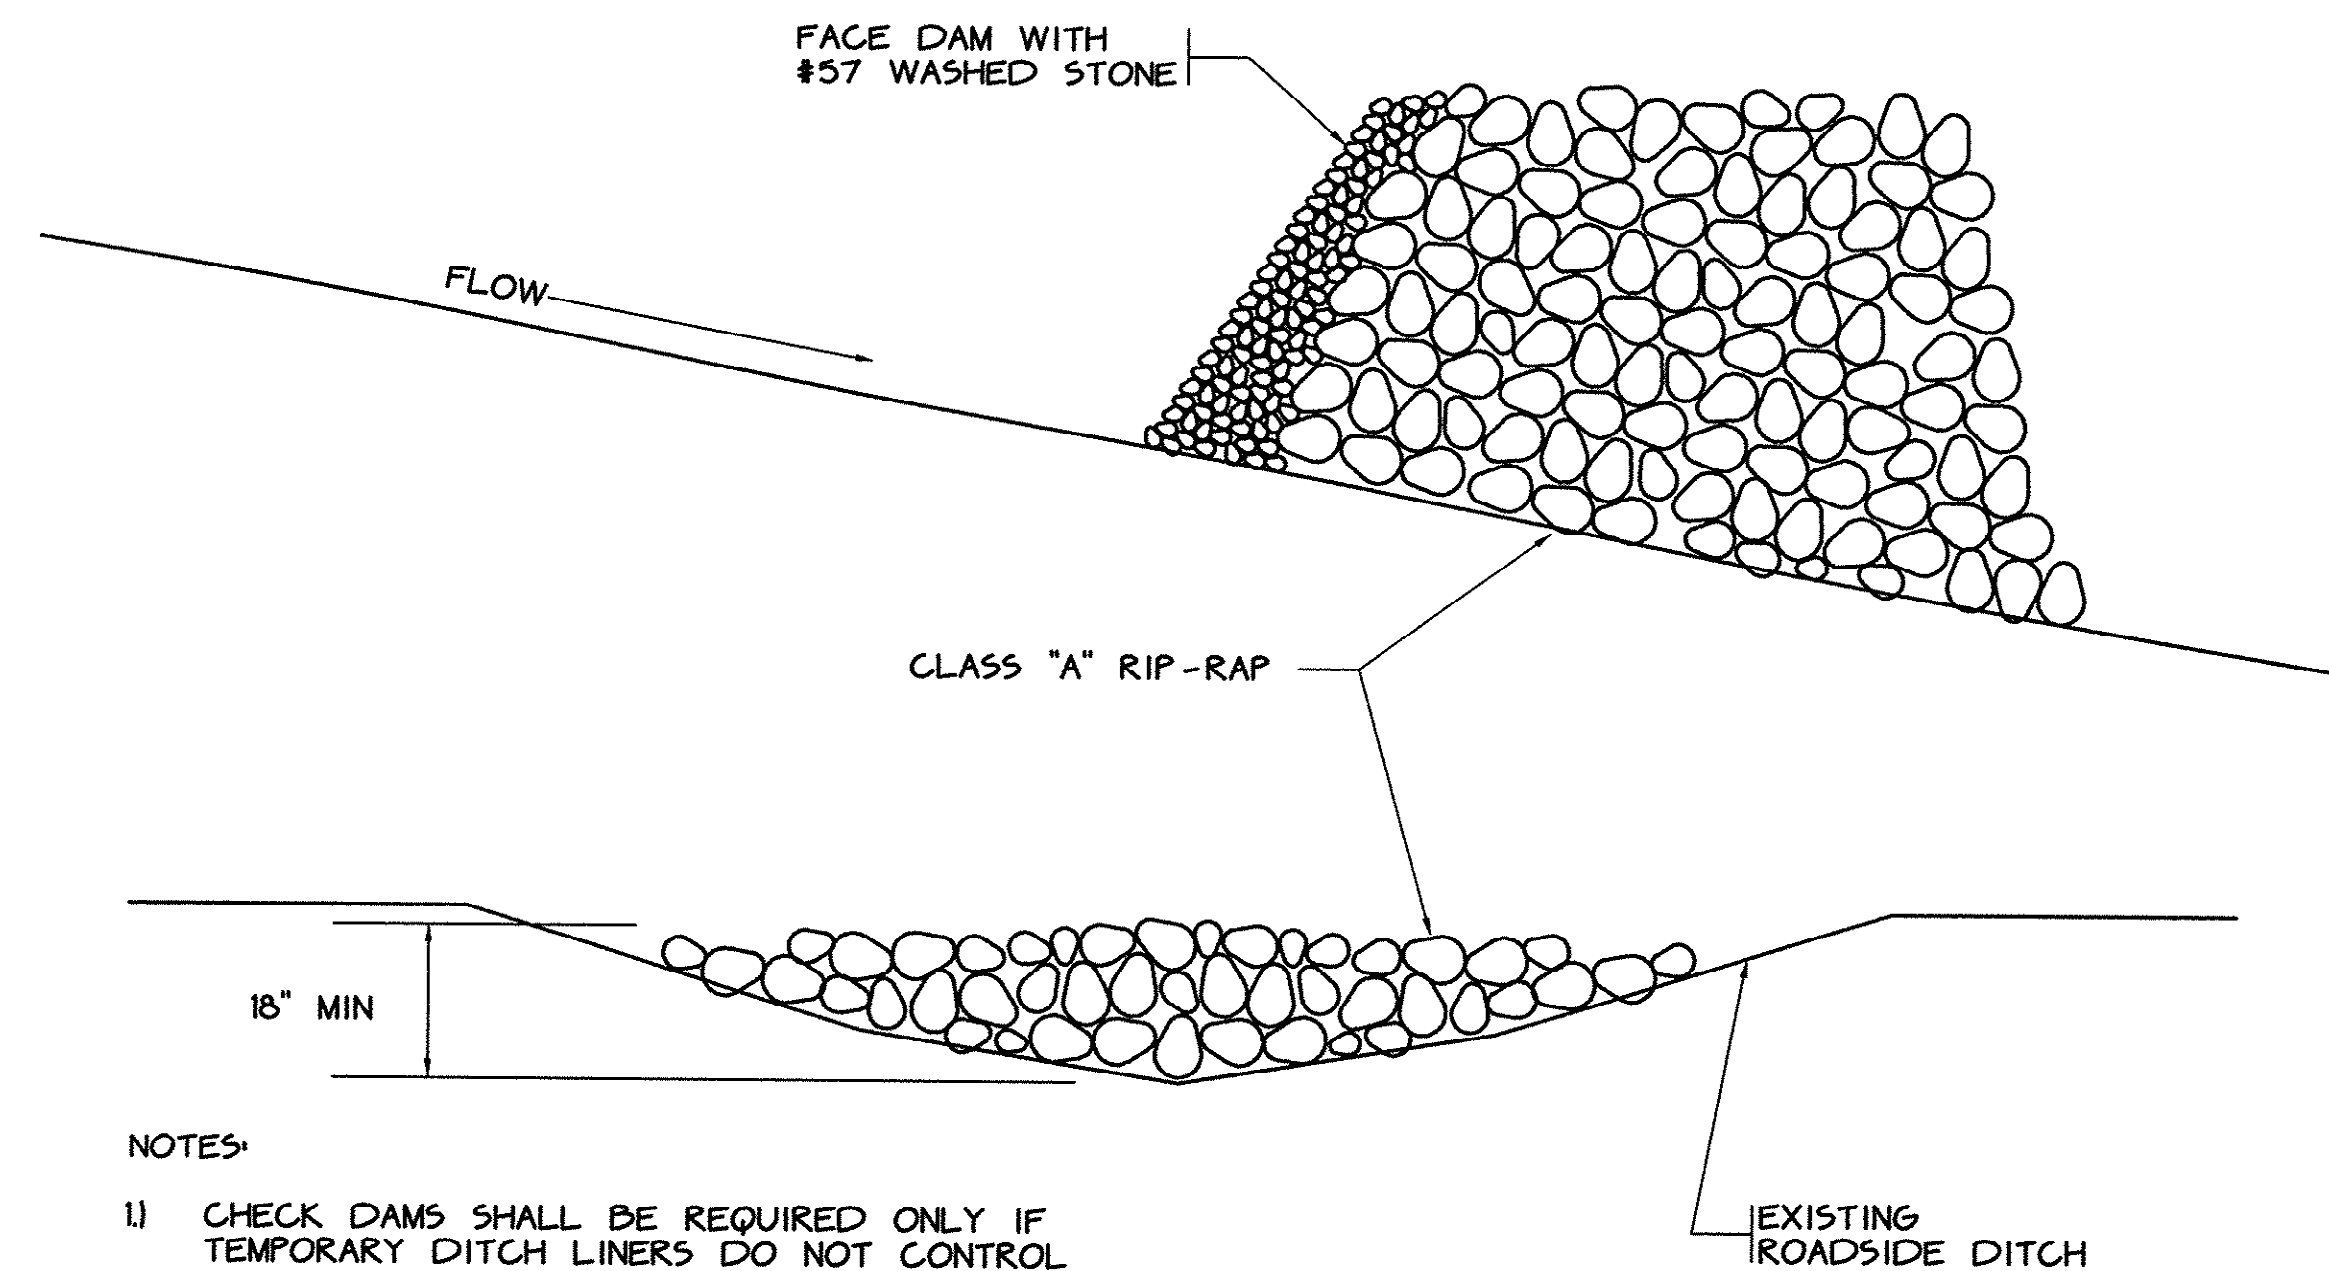

- NOTES:
- 1) CHECK DAMS SHALL BE REQUIRED ONLY IF TEMPORARY DITCH LINERS DO NOT CONTROL EROSION OR AS DIRECTED BY THE ENGINEER.
 - 2) CONTRACTOR SHALL REMOVE SEDIMENT ACCUMULATED BEHIND THE DAM TO PREVENT DAMAGE TO CHANNEL VEGETATION.
 - 3) CONTRACTOR SHALL REMOVE ROCK CHECK DAMS AFTER PERMANENT VEGETATION HAS BEEN ESTABLISHED.


TEMPORARY GRAVEL CHECK DAM DETAIL

SCALE: N.T.S.

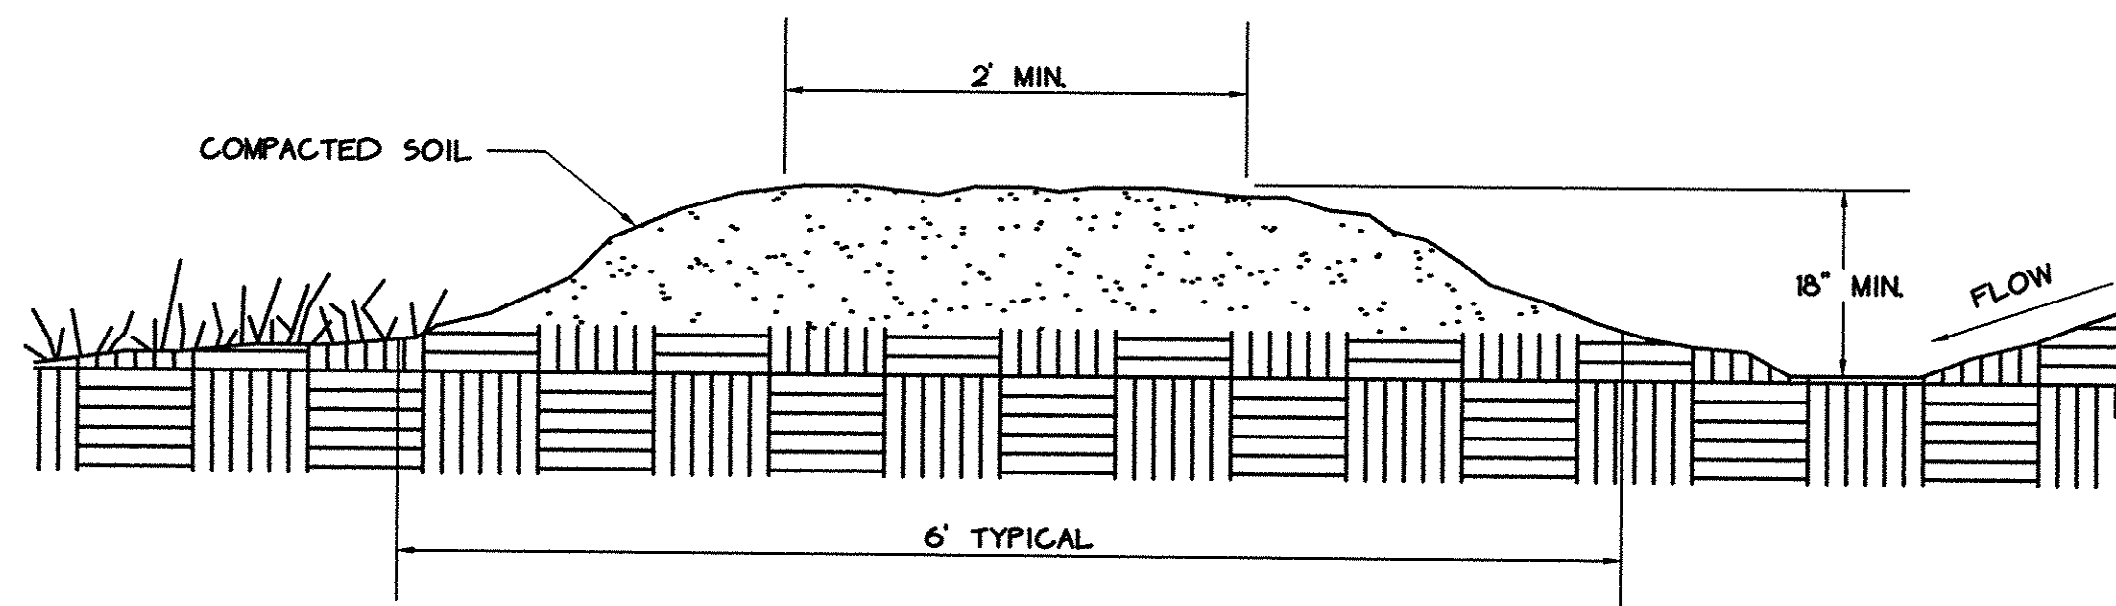


TEMPORARY EARTHEN DIVERSION DIKE

SCALE: N.T.S.

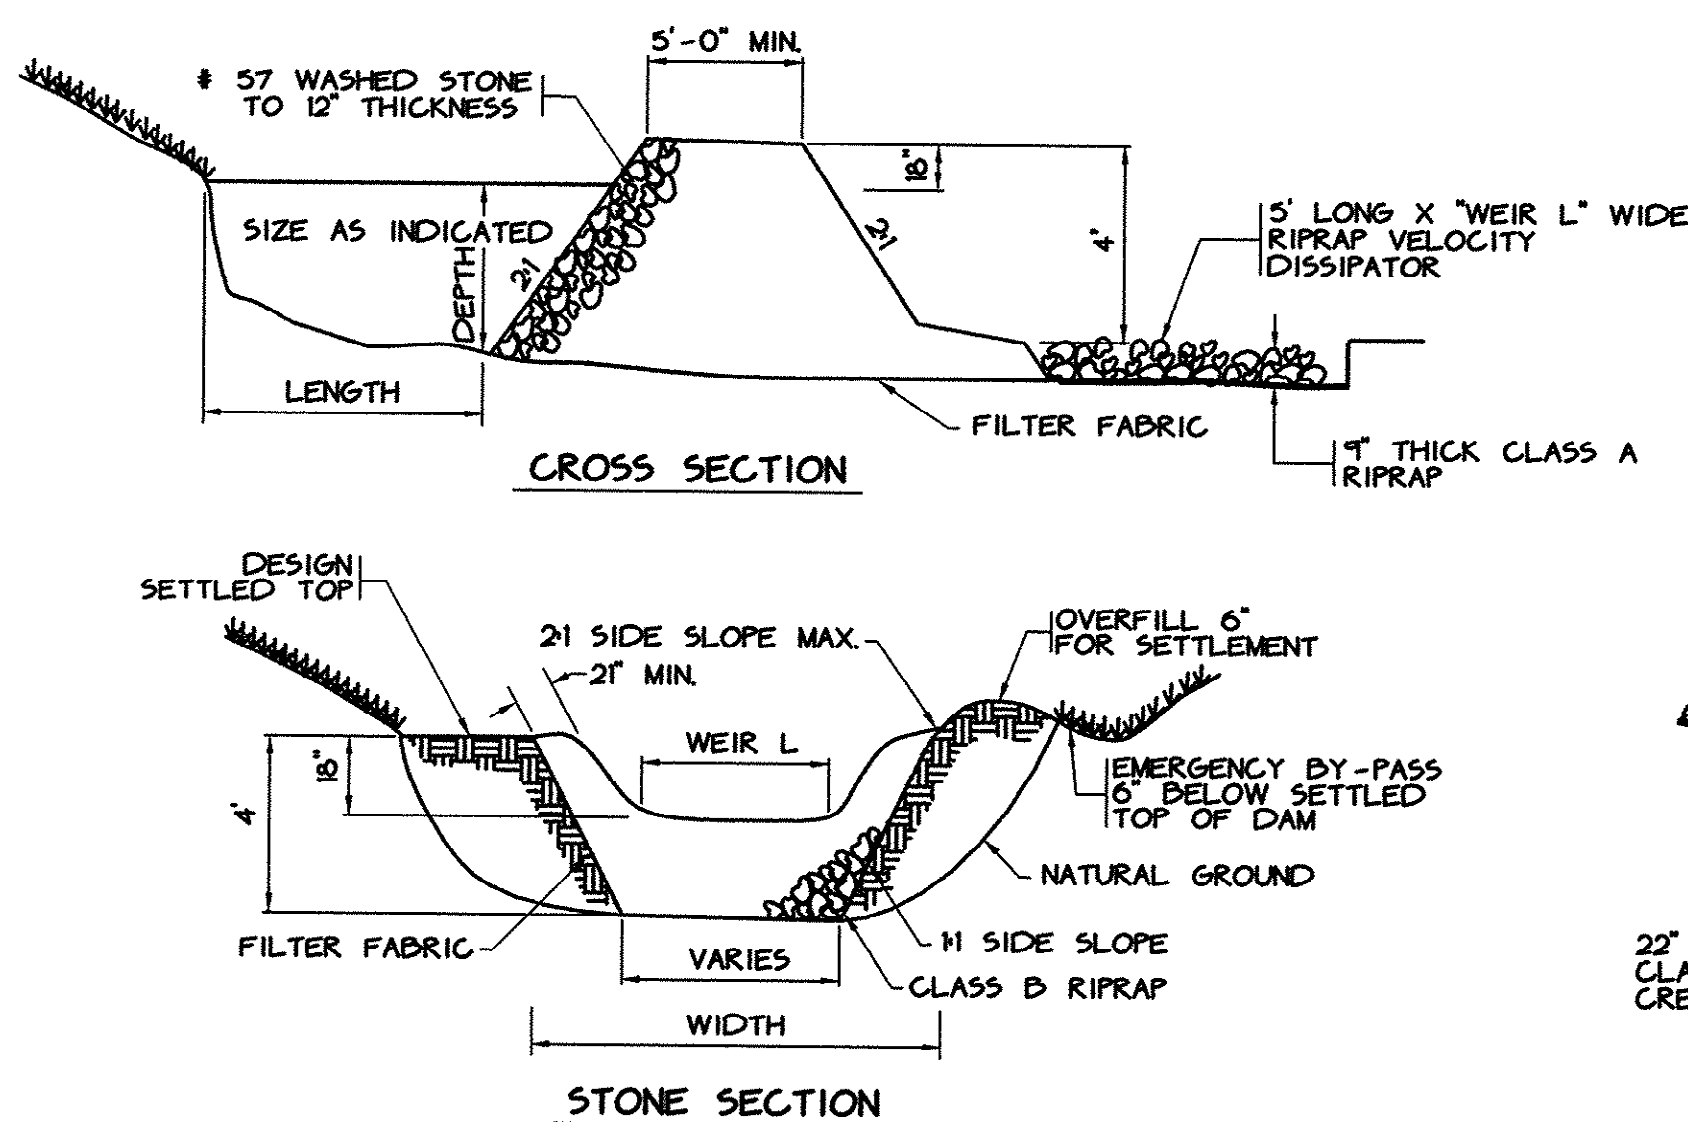



TEMPORARY SEDIMENT TRAP DETAIL

N.T.S.

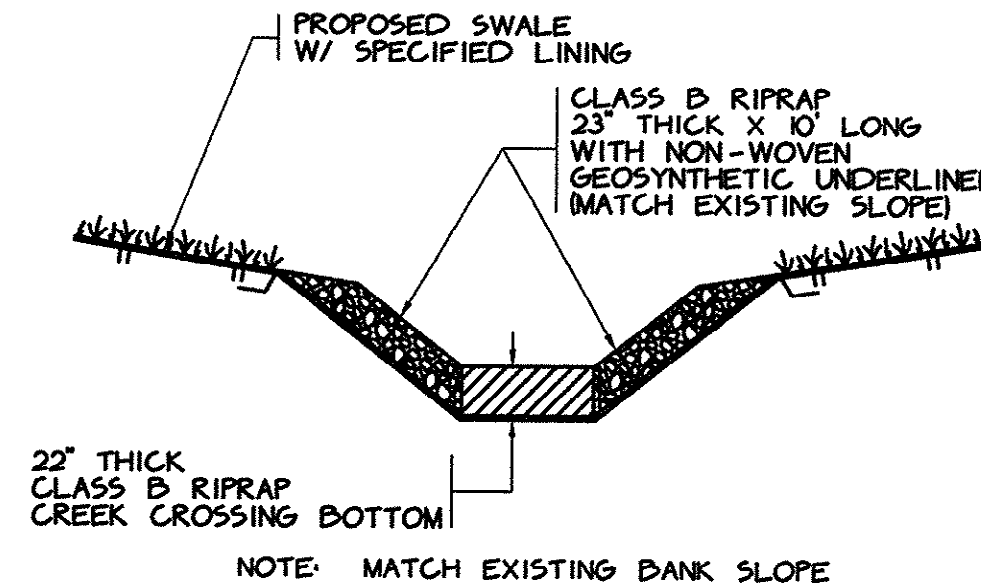


CREEK CROSSING W/ RIPRAP SLOPE PROTECTION DETAIL


N.T.S.

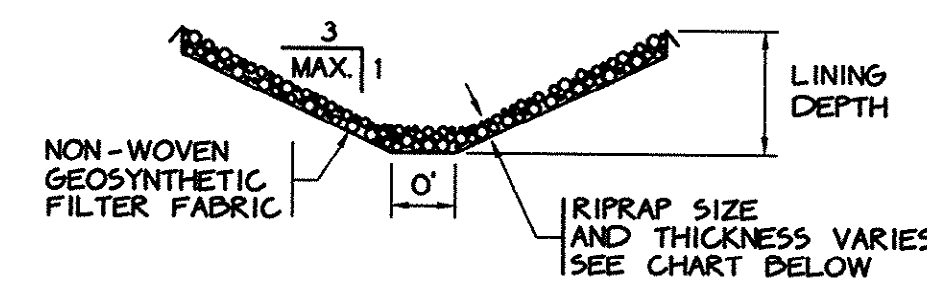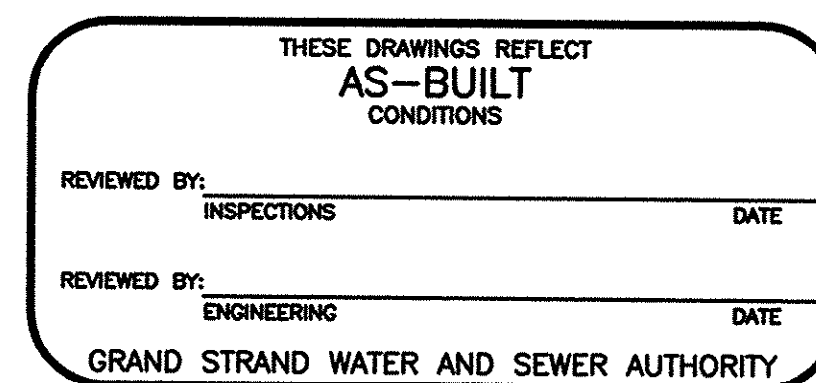

RIPRAP SWALE

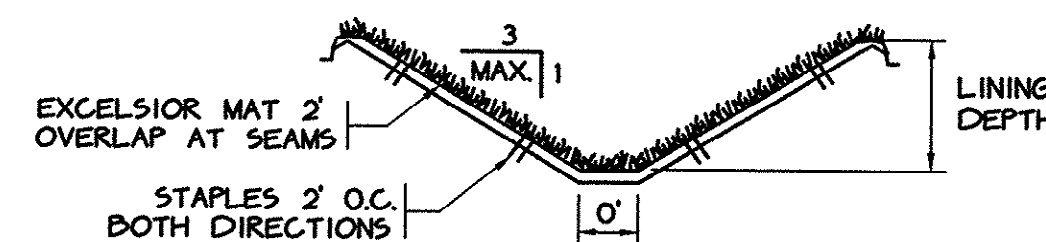


EXCELSIOR MAT SWALE

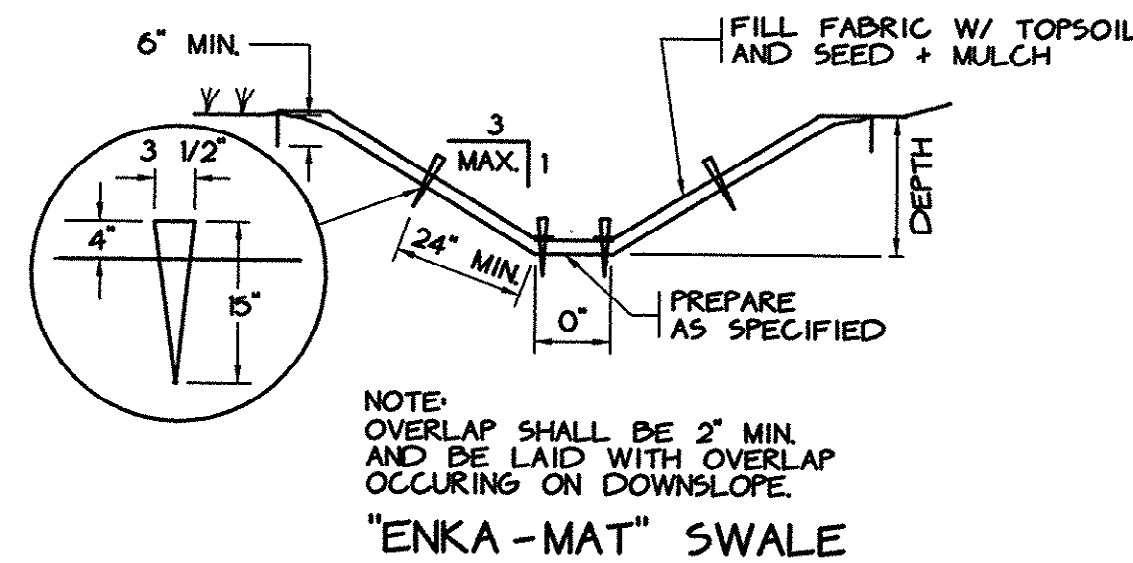


SWALE DETAIL

N.T.S.

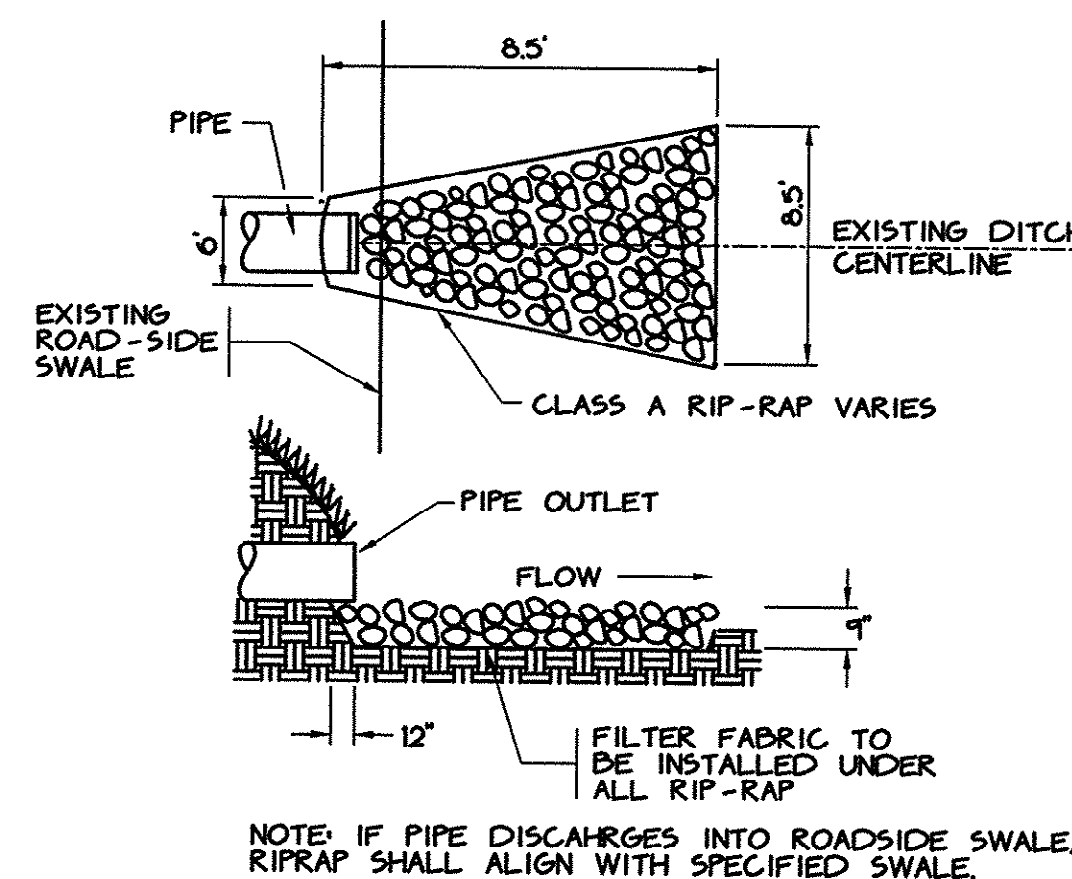

DITCH CROSSING DETAIL

N.T.S.

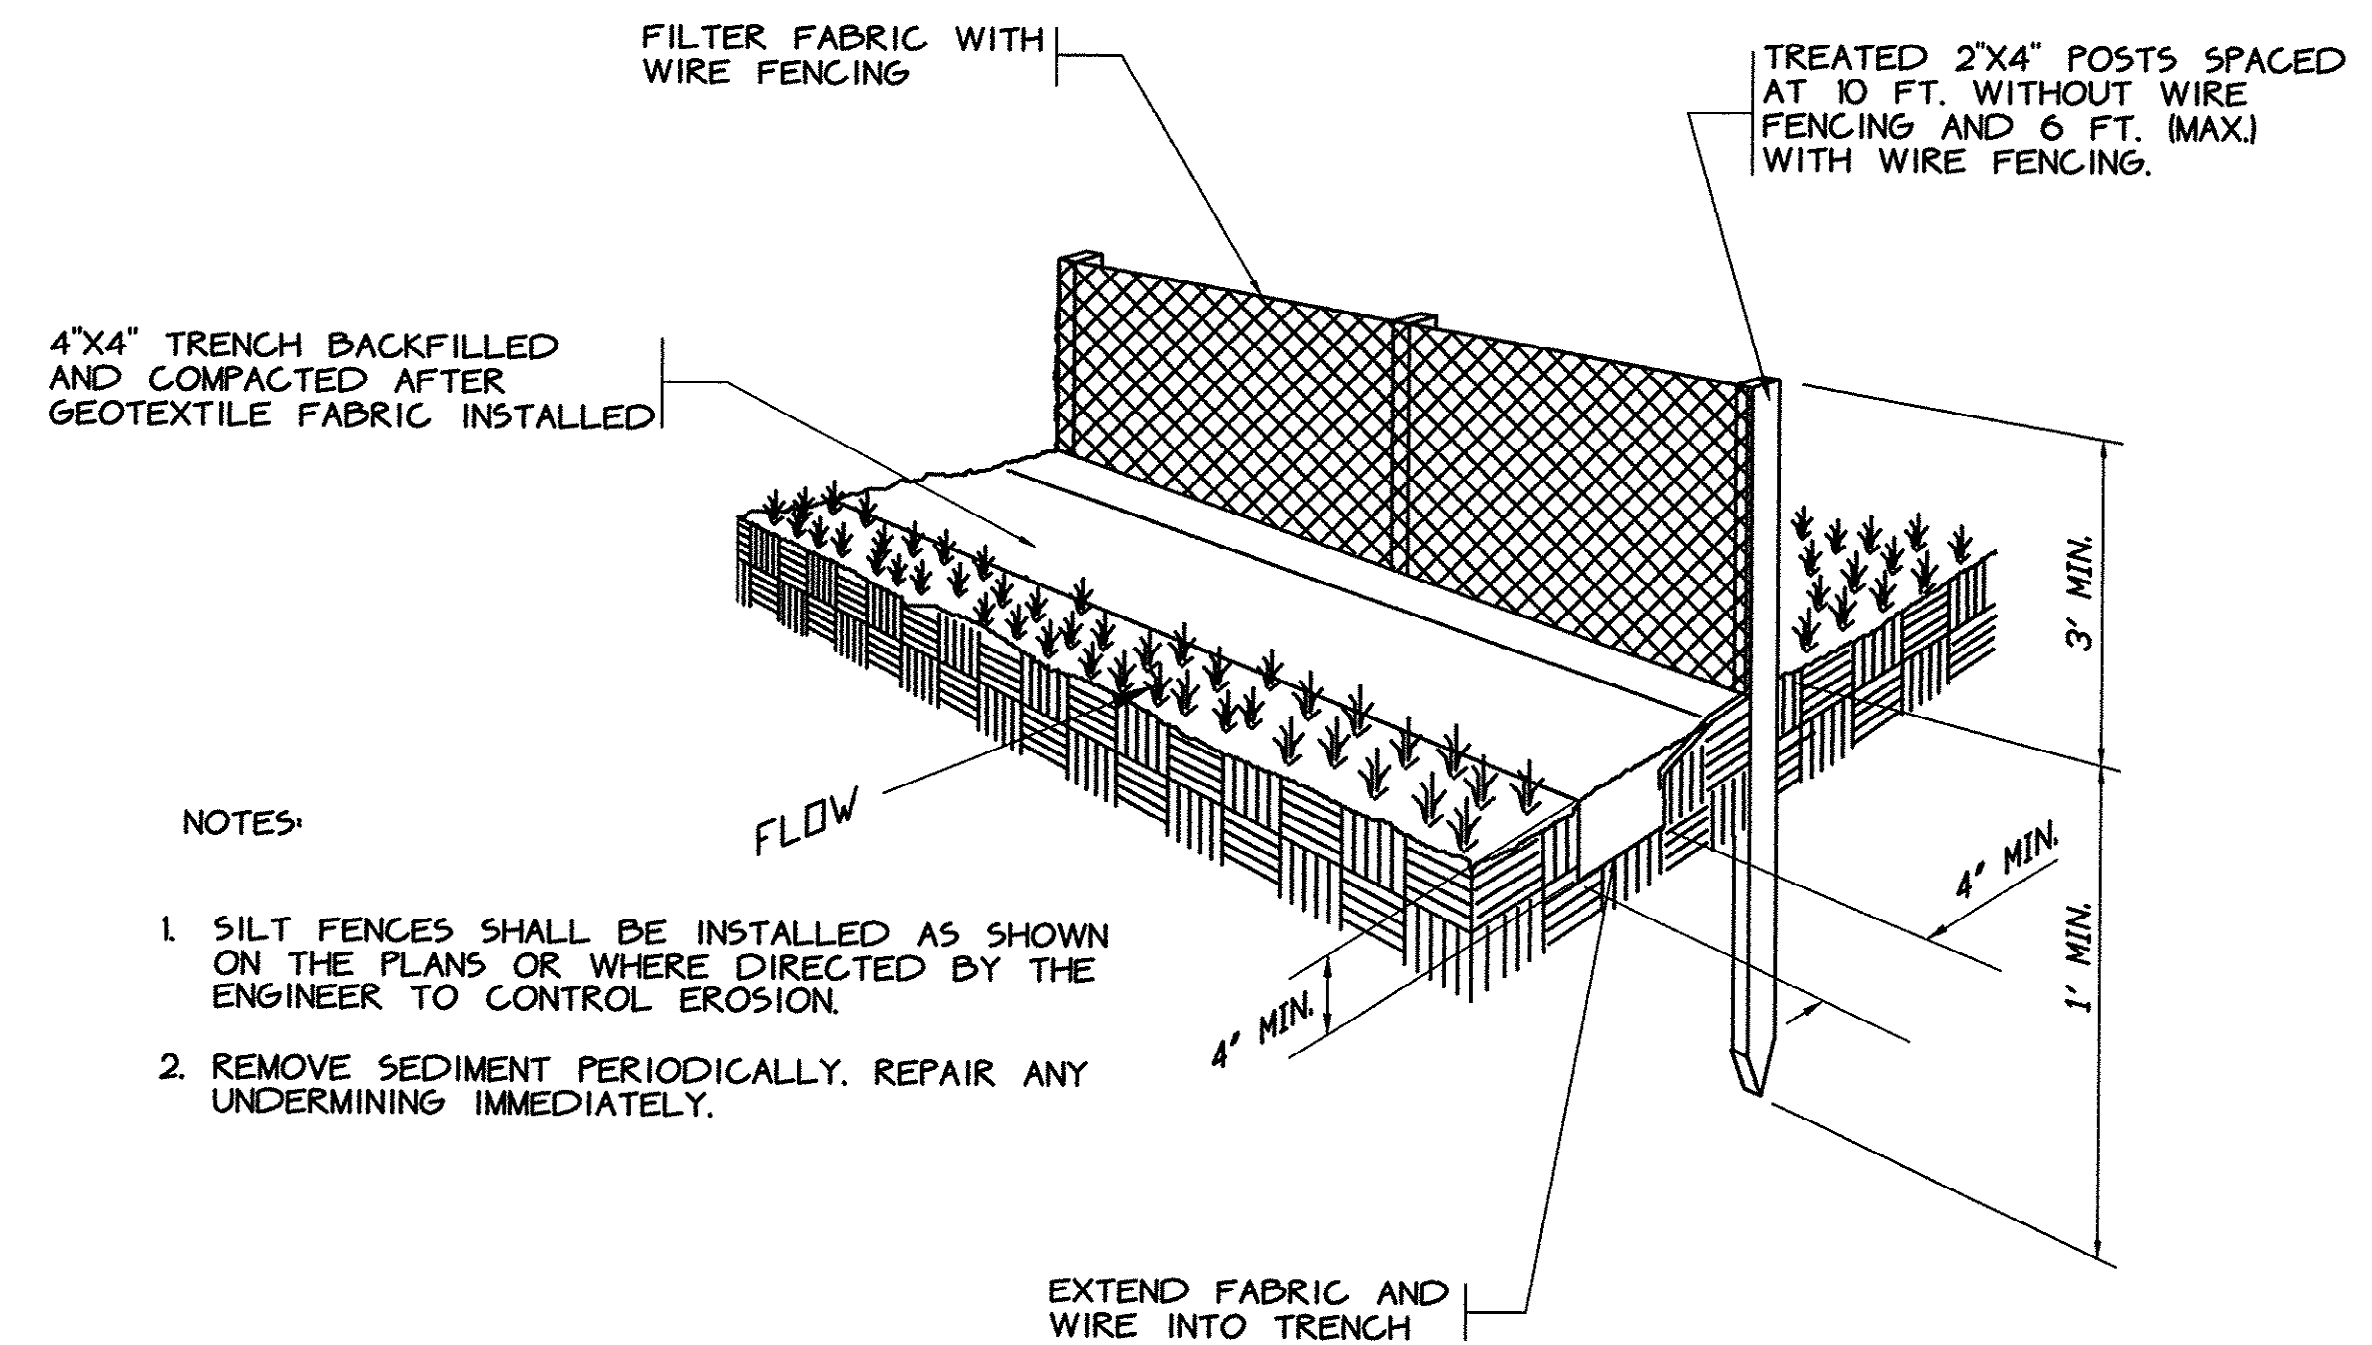


TEMPORARY SILT FENCE DETAIL

SCALE: N.T.S.

EROSION AND SEDIMENT CONTROL NOTES:

1. UNLESS OTHERWISE INDICATED, ALL VEGETATION AND STRUCTURAL EROSION AND SEDIMENT CONTROL PRACTICES WILL BE CONSTRUCTED AND MAINTAINED ACCORDING TO MINIMUM STANDARDS AND SPECIFICATIONS OF THE EROSION + SEDIMENT CONTROL PLANNING + DESIGN MANUAL + ACCORDING TO THE SPECIFICATIONS.
2. ALL HARD SURFACE PUBLIC ROADS SHALL BE CLEAN AT THE END OF EACH WORK DAY. PROVIDE TEMPORARY CONSTRUCTION ENTRANCES AT THE LOCATIONS SHOWN ON THE PLANS OR AS OTHERWISE NECESSARY.
3. THE LOCATION OF ALL EROSION AND SEDIMENT CONTROL MEASURES ARE APPROXIMATE. THESE DEVICES SHALL BE LOCATED TO ACHIEVE MAXIMUM BENEFIT. IF DURING CONSTRUCTION THESE DEVICES ARE NOT SUFFICIENT TO ADEQUATELY CONTROL EROSION AND SEDIMENTATION, ADDITIONAL EROSION CONTROL DEVICES SHALL BE INSTALLED AS DIRECTED BY THE ENGINEER.
4. ALL TEMPORARY EROSION AND SEDIMENT CONTROL MEASURES SHALL BE REMOVED AND DISPOSED OF WITHIN 30 DAYS AFTER FINAL SITE STABILIZATION.
5. CONTRACTOR SHALL TAKE ALL STEPS NECESSARY TO PREVENT SEDIMENT (GENERATED BY CONSTRUCTION OR EROSION) FROM ENTERING STREAMS. CONSTRUCTION VEHICLES WILL NOT BE ALLOWED IN FLOWING STREAM CHANNELS OR TO DAMAGE THEIR BANKS. TEMPORARY STREAM CROSSINGS SHALL BE INSTALLED IN ALL FLOWING STREAMS WHICH WILL HAVE CONSTRUCTION TRAFFIC CROSSING THEM.
6. STOCKPILING OF EXCESS MATERIALS IN WETLAND AREAS IS NOT ALLOWED.
7. IN GENERAL, ALL EROSION AND SEDIMENT CONTROL MEASURES SHALL BE CHECKED AFTER EACH RAINFALL OR WEEKLY, WHICHEVER IS MORE FREQUENT (AT LEAST DAILY DURING PERIODS OF PROLONGED RAINFALL). CONTRACTOR SHALL CLEAN AND REPAIR ACCORDINGLY.
8. ALL WORK PERFORMED SHALL BE IN COMPLIANCE WITH GSWA STORM WATER POLLUTION PREVENTION PLAN.

SYMBOL	DATE	BY
AS-BUILT	10/5/00	WDL
AS-BUILT	9/01/01	WDL

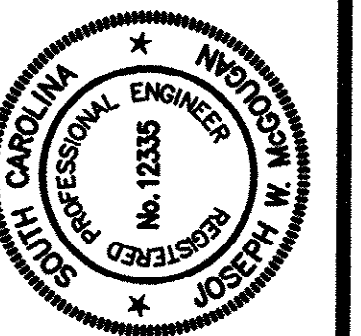

HOBBS, UPCHURCH & ASSOCIATES, P.A.
CONSULTING ENGINEERS
WATTLE BEACH, SOUTH CAROLINA 29577



EROSION CONTROL
DETAILS

TIP-TOP TREE FARM
EFFLUENT LAND
APPLICATION PROJECT
GRAND STRAND WATER
AND SEWER AUTHORITY

DATE:	MAR. 1999
DESIGNED:	WDL
DRAWN:	KLM
CHECKED:	WDL
SCALE:	AS SHOWN

SHEET NO.

DT-5


5

45-003-042/53

J:\GS9901\800\820\ELECT\E1.dwg EDITED BY: ARABON DATE: 08/29/01 TIME: 11:29 XREFS: J:\GS9901\800\825\ELECT\Y-TITLE.dwg Layout: Model

HEATING AND VENTILATION SCHEDULE FOR IRRIGATION PUMP STATION

TYPE	DESCRIPTION
VF-2 VF-3	FAN CFM SHALL BE 7,000, STATIC PRESSURE = 0.375 W.C., 860 RPM, 3/4 HORSEPOWER, 460 VOLTS, 3 PHASE, WITH WALL MOUNTING COLLAR, GRAVITY BACK DRAFT DAMPER AND MOTOR SIDE FAN GUARD. FAN SHALL BE GREENHECK MODEL SPE-1H30-7 OR APPROVED EQUAL. DAMPER SIZE - 32" x 32", WALL OPENING REQUIRED 39 3/4" x 39 3/4" INTAKE LOUVERS: (2) 48" x 48" WITH MOTOR OPERATED DAMPERS EXHAUST LOUVERS: (2) 48" x 48" WITH GRAVITY DAMPERS
EUH-1 EUH-2	ELECTRIC UNIT HEATER HEATERS SHALL BE RATED 17,100 BTU/HR, 5 KW AT 480 VOLTS, 3 PHASE. FAN PANEL SHALL HAVE AN AIR VOLUME OF 420 CFM AND SHALL BE RATED 480 VOLTS, 3 PHASE. THE HEATER SHALL BE BOTH MOISTURE AND CORROSION RESISTANT AND CAPABLE OF BEING HOSED DOWN. ELEMENTS SHALL BE LONG LIFE MODEL FIN TUBES WITH STAINLESS STEEL THREADED FITTINGS. MOTOR SHALL BE TOTALLY ENCLOSED, PERMANENTLY LUBRICATED BALL BEARING TYPE AND EPOXY PAINTED WITH ONE COAT OF ZINC CHROMATE PRIMER AND TWO COATS OF CORROSION RESISTANT PAINT. UNIT SHALL BE COMPLETELY SELF-CONTAINED WITH BUILT-IN CONTACTORS. OVER-TEMPERATURE CUT-OUT AND ADJUSTABLE THERMOSTAT WITH TEMPERATURE RANGE OF 40°-100°F. CEILING MOUNT 9'-0" ABOVE FINISHED FLOOR. MARKEL MODEL P3P5105CAIN OR APPROVED EQUAL.
	LOUVERS ALUMINUM COMBINATION WALL LOUVERS WITH DRAINABLE BLADES. FRONT STATIONARY BLADES: 37 1/2" ANGLE, 0.081" BLADE THICKNESS, 4 1/2" BLADE SPACING. REAR ADJUSTABLE BLADES: 0.140" BLADE THICKNESS, VINYL BLADE EDGE SEALS, BIRDSCREEN, MOTORIZED DAMPERS INTERLOCKED TO VENT. FAN, 120V, 60 HZ. SIZE: 3'-4" x 3'-0" DEEP RUSKIN OR APPROVED EQUAL.
AC-1 AC-2 AC-3	AC UNIT COOLING CAPACITY - 14,800 BTUH, EER-9.0, 230V, 1-PHASE, ELECTRIC HEAT CAPACITY - 12,900 BTUH, FUSE SIZE 30A. CARRIER GYA3153 OR APPROVED EQUAL

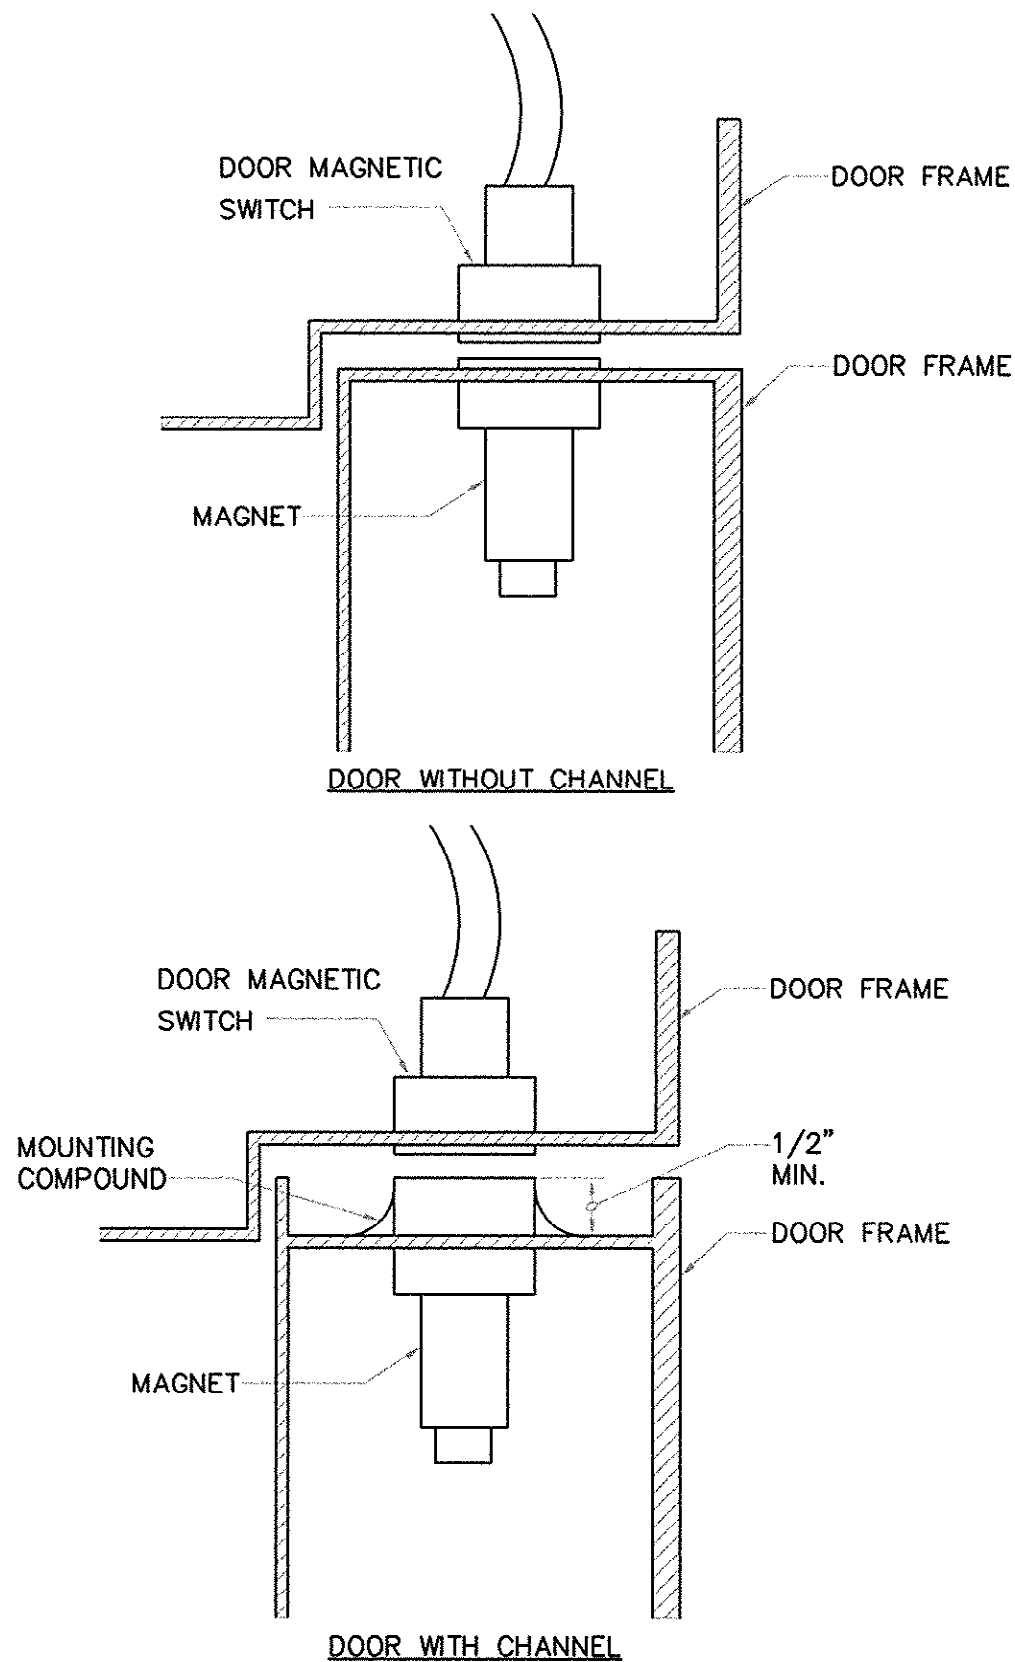

TYPICAL "MS" MOUNTING

NOT TO SCALE

NOTES:

- USE SWITCHES FROM SENTROL, WIDE GAP TYPE, OR APPROVED EQUAL.

ELECTRICAL DRAWING LIST

E1	SYMBOL SCHEDULE, EQUIPMENT SCHEDULES AND DETAILS
E2	PUMP STATION - ONE LINE POWER DIAGRAM
E3	PUMP STATION ELECTRICAL PLAN
E4	PUMP STATION - ELECTRICAL PLAN
E5	SCHWARTZ WWTP ELECTRICAL SITE PLAN
E6	SCHWARTZ WWTP POWER RISER DIAGRAM
E7	SCHWARTZ WWTP EFFLUENT CONTROL STRUCTURE ELECTRICAL WORK
E8	SCHWARTZ WWTP DEEP BED SAND FILTERS ELECTRICAL WORK
E9	HEADER BUILDING ELECTRICAL PLANS AND DETAILS
E10	MISCELLANEOUS DETAILS

ELECTRICAL SYMBOL SCHEDULE

SYMBOL	DESCRIPTION
	CONDUIT CONCEALED IN OR ABOVE CEILING: IN OVERHEAD SLAB; OR IN WALL
	CONDUIT CONCEALED IN OR BELOW FLOOR: BELOW GRADE: OR IN WALL
	CONDUIT RUN EXPOSED AS HIGH AS POSSIBLE
	IF SHOWN, CROSS LINES INDICATE NUMBER OF CURRENT CARRYING CONDUCTORS. EQUIPMENT GROUNDING CONDUCTORS ARE GENERALLY NOT INCLUDED IN THE QUANTITY INDICATED.
	#1/0 THHW/THWN COPPER - 24" BELOW GRADE
	HOME RUN TO PANEL - WITH PANEL AND CIRCUIT DESIGNATION.
	CONDUIT STUB-IN WITH CONNECTION TO EQUIPMENT
	JUNCTION OR PULL BOX. SIZE PER N.E.C.
	WATER TIGHT BOX WITH FUSES FOR POWER CONNECTION TO INSTRUMENTATION REFER TO TYPICAL DETAIL ON SHEET E9.
	FLUORESCENT FIXTURE, CEILING, WALL OR RECESS MOUNTED AS SCHEDULED DRAWN APPROXIMATELY TO SCALE
	WALL OUTLET - INCANDESCENT, COMPACT FLUORESCENT, OR HID FIXTURE AS SCHEDULED.
	POST-TOP AREA LIGHT FIXTURE - TYPE "SA"
	WALL MOUNTED, STANDBY BATTERY POWERED FIXTURE AS SCHEDULED - MOUNT 12" BELOW JOIST.
	SINGLE POLE SWITCH - 20A, 120-277V. MOUNT 46" AFF TO TOP AND 2" FROM STRIKE SIDE OF DOOR FRAME.
	THREE WAY SWITCH-20A, 120-277V, MOUNT 46" AFF AND 2" FROM STRIKE SIDE OF DOOR FRAME.
	BRANCH CIRCUIT OR DISTRIBUTION PANELBOARD, AS INDICATED
	CONTROL PANEL
	CONVENIENCE RECEPTACLE - MOUNT 18" AFF. NEMA 5-20R, DUPLEX
	CORROSION RESISTANT NEMA 5-20R OUTLET. HUBBELL #53CM22 WITH #52CM22 COVERPLATE. MOUNT 18" AFF.
	SPECIAL CONFIGURATION OUTLET - NEMA 6-30R CONFIGURATION MOUNT TO FIT AC UNIT.
	WALL TELEPHONE OUTLET, 54" AFF.
	NONFUSIBLE DISCONNECT SWITCH.
	FUSIBLE DISCONNECT SWITCH.
	ENCLOSED CIRCUIT BREAKER.
	C-FVNR WITH FUSIBLE DISCONNECT SWITCH. NUMERAL INDICATES RK-5 FUSE SIZE.
	THERMOSTAT, LINE VOLTAGE
	DRY TYPE TRANSFORMER - SINGLE PHASE, 480-120/240 VOLTS.
	DRY TYPE TRANSFORMER - THREE PHASE, 480-120/208 VOLTS.
	460 VOLT, 3 PHASE MOTOR - NUMERAL INDICATES HORSEPOWER.
	INDICATES GROUNDING ELECTRODE CONDUCTOR AS REQUIRED BY ARTICLES 250-66 OF THE NATIONAL ELECTRICAL CODE.
	SURGE ARRESTER
	GROUND ROD - 10' x 3/4" STAINLESS STEEL
	FIRE ALARM CONTROL PANEL
	CEILING MOUNTED SMOKE DETECTOR, PHOTOELECTRIC TYPE
	CEILING MOUNTED COMBINATION RATE-OF-RISE/FIXED TEMPERATURE FIRE DETECTOR
	FIRE ALARM COMBINATION ADA CHIME/STROBE APPLIANCE - MOUNT 6'-8" AFF, FROM BOTTOM OF APPLIANCE, OR 0'-6" BELOW CEILING, WHICHEVER IS LESS.
	STROBE LIGHT
	END OF LINE DEVICE

ELECTRICAL SYMBOL SCHEDULE

SYMBOL	DESCRIPTION
A	AMPERE
AFF	ABOVE FINISHED FLOOR - MEASURED FROM FLOOR TO CENTER OF DEVICE, EXCEPT AS OTHERWISE SPECIFICALLY NOTED.
ATS	AUTOMATIC TRANSFER SWITCH
C	CONDUIT
C-FVNR	COMBINATION FVNR AND FUSED SWITCH
C-RVNR	RVNR AND FUSED SWITCH OR CIRCUIT BREAKER
F	FUSE
FCP	FILTER CONTROL PANEL
FVNR	FULL VOLTAGE NON-REVERSIBLE MAGNETIC MOTOR STARTER
G	GROUND
HH	HANDHOLE - SEE DETAILS ON SHEET E10.
MCB	MAIN CIRCUIT BREAKER
MCM	Kcmil (THOUSAND CIRCULAR MILS)
NEC	NATIONAL ELECTRICAL CODE
N	NEUTRAL
NC	NORMALLY CLOSED
NO	NORMALLY OPEN
P	POLE
PH	PHASE
RMC	RIGID SCHEDULE 40 METAL CONDUIT
RTU	REMOTE TERMINAL DATA UNIT - PROVIDE PVX COATING AS REQUIRED BY SPEC SECTION 16110.
RVNR	REDUCED VOLTAGE NON-REVERSIBLE AUTOTRANSFORMER, CLOSED TRANSITION, MAGNETIC STARTER.
SC	BELDEN #83702, TWO-CONDUCTOR, 16 GAUGE SHIELDED CABLE, TEFLON JACKETED, SUITABLE FOR USE IN WET LOCATIONS.
SCIR	SHORT CIRCUIT INTERRUPTING RATING
SO	SPACE ONLY (WITH PROVISIONS FOR FUTURE OVERCURRENT PROTECTIVE DEVICE)
VFD	VARIABLE FREQUENCY DRIVE CONTROLLER WITH DISCONNECT SWITCH.
WP	INDICATES DEVICE TO HAVE WEATHERPROOF COVER
WT	WATERTIGHT NEMA 4X, GASKETED OUTLET BOX OR PULL BOX, AS APPLICABLE.
MS	DOOR SECURITY MAGNETIC SWITCH. SENTROL 1078 SERIES WITH CLOSED CONTACTS. WHEN DOOR IS CLOSED, SEE DETAILS THIS SHEET. WIRE TOGETHER WITH 2#14, 1/2" C. TO RTU IN PUMP STATION.
RS	ROLL UP DOOR MONITORING SWITCH. MICRO SWITCH BLZN SERIES ENCLOSED SWITCH WITH STRAIGHT PLUNGER OR ROLLER ARM ACTUATOR AS REQUIRED. MOUNT AT FLOOR ON INSIDE OF FRAME. SWITCH TO BE 'CLOSED' WHEN DOOR IS CLOSED.
RTU	CONTROLS AND TELEMETRY PANEL BY OTHERS. RUN CONDUCTORS AND CABLES, AS SHOWN ON THE DRAWINGS, TO PANEL FOR CONNECTION BY OTHERS. TAG EACH TO INDICATE DEVICE OR EQUIPMENT SERVED.
FMT	FLOWMETER TRANSMITTER - SEE TYPICAL CONNECTION ON SHEET E9.
PMT	PRESSURE METER TRANSMITTER. SEE TYPICAL CONNECTION ON SHEET E3.
NO	NORMALLY OPEN AUXILIARY CONTACT
NC	NORMALLY CLOSED AUXILIARY CONTACT
SV	SOLENOID VALVE
SV	BUTTERFLY VALVE PNEUMATIC TYPE, ELECTRICALLY ASSISTED.
MAG	MAG METER. SEE TYPICAL CONNECTION ON SHEET E3
HO	ON-OFF SWITCH. CONTROL STATION.

THESE DRAWINGS REFLECT
AS-BUILT
CONDITIONS

REVIEWED BY: _____ DATE _____
INSPECTIONS

REVIEWED BY: _____ DATE _____
ENGINEERING

GRAND STRAND WATER AND SEWER AUTHORITY

LIGHTING FIXTURE SCHEDULE

FIXTURE TYPE	MANUFACTURER & CATALOG INFORMATION	LAMPS			BALLAST			TOTAL WATTS	DESCRIPTION
		QTY.	TYPE	WATTS	QTY.	TYPE	WATTS		
A	LITHONIA DM240 OR EQUAL	2	F32T8	32	1	ELECTRONIC	58	58	TOTALLY ENCLOSED CORROSION RESISTANT
AA	LITHONIA DM240 OR EQUAL	2	F32T8	32	1	ELECTRONIC	74	74	TOTALLY ENCLOSED CORROSION RESISTANT
B	LITHONIA TWL 705120-PE1 OR EQUAL	1	HPS	70	1	HRHPF	90	90	OUTDOOR WEATHERPROOF FIXTURE WITH POLYCARBONATE LENS, PE SWITCH
E	LITHONIA ELUX-N-H OR EQUAL	2	HALOGEN	8	-	-	-	16	EMERGENCY BATTERY LIGHT WITH 90-MINUTE NICKEL-CADMIUM BATTERY PACK.
SA	GE #P15S2A-2-A-M-S-3-GR-U WITH POLE # ARTA 163S5.OASNA OR EQUAL	2	HPS	150	1	AUTOREG.	170	170	HPS POST-TOP FIXTURE, 16-FOOT, ROUND, 0.188 THICK ALUMINUM POLE, HANDHOLE, P.E. COIL SWITCH. SEE DETAIL ON SHEET E-10.

CONTROL SEQUENCE

HEATING:

EUH-1, EUH-2
EUH-1 SHALL CYCLE FAN AND HEAT AS REQUIRED TO MAINTAIN SETPOINT OF THEIR BUILT-IN THERMOSTATS. SET AT 65°F.


VENTILATION:

VF-1, VF-2, VF-3
FAN SHALL HAVE ITS OWN WALL-MOUNTED THERMOSTAT. THE SETTING FOR VF-1 SHALL BE 80°F. WHEN THE FAN STARTS THE MOTOR OPERATED DAMPER IN THE INTAKE LOUVER SHALL OPEN.

GENERAL NOTES

- THE ELECTRICAL CONTRACTOR SHALL COORDINATE THE LOCATION, EXACT CONFIGURATION AND REQUIREMENTS OF INSTRUMENTS AND EQUIPMENT BEING FURNISHED UNDER OTHER SECTIONS OF SPECIFICATIONS.
- ALL CIRCUITS RATED 115 VOLTS OR HIGHER SHALL BE PROVIDED WITH SEPARATE EQUIPMENT GROUNDING CONDUCTORS BONDED TO ALL ENCLOSURES AND BOXES ASSOCIATED WITH THE CIRCUIT.
- PVC CONDUIT IS NOT PERMITTED FOR SIGNAL (INSTRUMENTATION) CIRCUITS RUN OUTSIDE OF BUILDING - USE RMC CONDUIT.
- RMC INSTALLED UNDERGROUND IN DIRECT CONTACT WITH EARTH OR EXPOSED TO WEATHER, OR IN CHLORINE BUILDING SHALL BE PVC COATED.

TYPICAL PANEL DIAGRAM

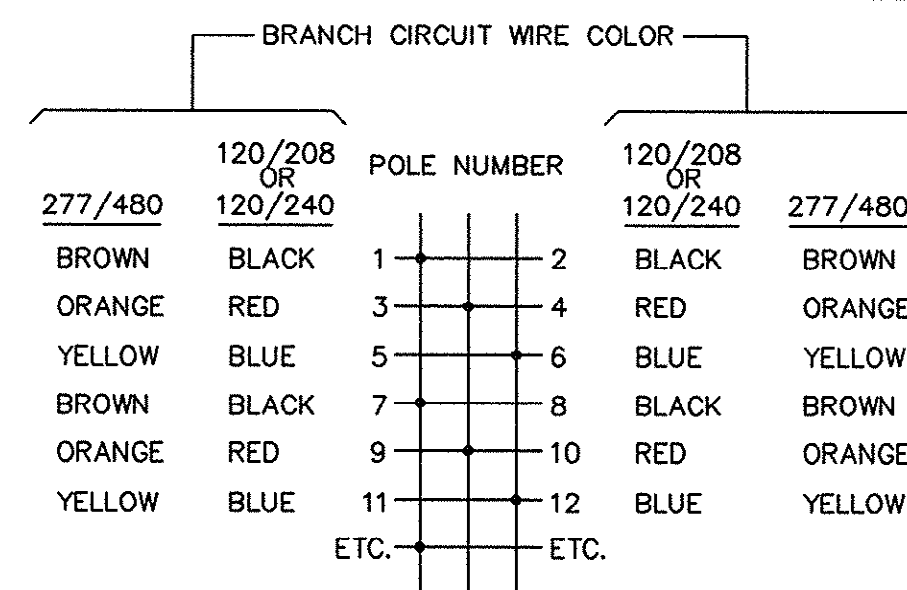

NEUTRAL

120/240 OR 120/208 VOLTS - WHITE

277/480 VOLTS - WHITE WITH IDENTIFIABLE COLOR STRIPE (NOT GREEN). IF NOT AVAILABLE AT TIME OF INSTALLATION, CLEAR USE OF GRAY WITH ELECTRICAL INSPECTOR.

GROUND WIRE SHALL BE GREEN FOR ALL VOLTAGES.

CIRCUITING LEGEND

HOMERUNS TO PANELBOARDS ARE SHOWN AS POLES RATHER THAN CIRCUITS. SIMILARLY, PANEL SCHEDULES LIST POLES RATHER THAN CIRCUITS, BUT INDICATE WHICH POLES ARE COMMON TRIP FORMING TWO AND THREE POLE CIRCUITS. HOMERUN DESIGNATIONS INDICATE PANELBOARD AND POLES TO WHICH PHASE WIRES ARE TO BE CONNECTED. NUMBER OF ARROWS INDICATE NUMBER OF CIRCUITS INVOLVED. CROSS HATCHES, SHOWN ONLY WHEN THE NUMBER OF POLES EXCEEDS THE NUMBER OF CIRCUITS, INDICATE THE NUMBER OF WIRES. FOR EXAMPLE:

SYMBOL	NO. OF POLES	CIRCUITS	PHASE WIRES	NEUTRAL
LP-1	1	1	1	1
LP-1, 3	2	1	2	0
LP-1, 3, 5	3	1	3	0
LP-1, 3, 5	3	1	3	1
LP-5, 7	2	2	2	1
LP-5, 7, 9	3	3	3	1

FEEDERS:

NO. () INDICATES QUANTITY OF CONDUITS AND CONDUCTORS IN PARALLEL. SEE NEC 250-122, 250-95, 300-20 AND 310-4 FOR SPECIAL REQUIREMENTS. EXAMPLE: 3(3 #3/0, 1 #1/0 N, 1 1G, 2 1/2" C) REQUIRES THREE 2 1/2" CONDUITS EACH HAVING THREE NO. 3/0 PHASE CONDUCTORS, ONE NO. 1/0 NEUTRAL CONDUCTOR AND ONE NO. 1 GROUNDING CONDUCTOR.

EQUIPMENT GROUNDING CONDUCTORS:

EQUIPMENT GROUNDING CONDUCTORS ARE GENERALLY NOT SHOWN ON CIRCUITING PLANS BUT SHALL BE PROVIDED IN THE SIZES AS SCHEDULED ON N.E.C. TABLE 250-122 ON ALL CIRCUITS.

SYMBOL SCHEDULE,
EQUIPMENT SCHEDULE
AND DETAILS

TIP-TOP TREE FARM
EFFLUENT LAND
APPLICATION PROJECT
GRAND STRAND WATER
AND SEWER AUTHORITY

DATE: SEPTEMBER 8, 1999

DESIGNED: DL

DRAWN: D.B.M.

CHECKED: DL

SCALE: AS SHOWN


SHEET NO.

E1

OF: 10

45-003-048/53

J:\G59901\800\920\ELECT\AS-BUILT\X-TITLE.dwg XREFS: J:\G59901\800\920\ELECT\X-TITLE.dwg LAYOUT: Model DATE: 08/29/01 TIME: 11:31 EDITED BY: ARABON

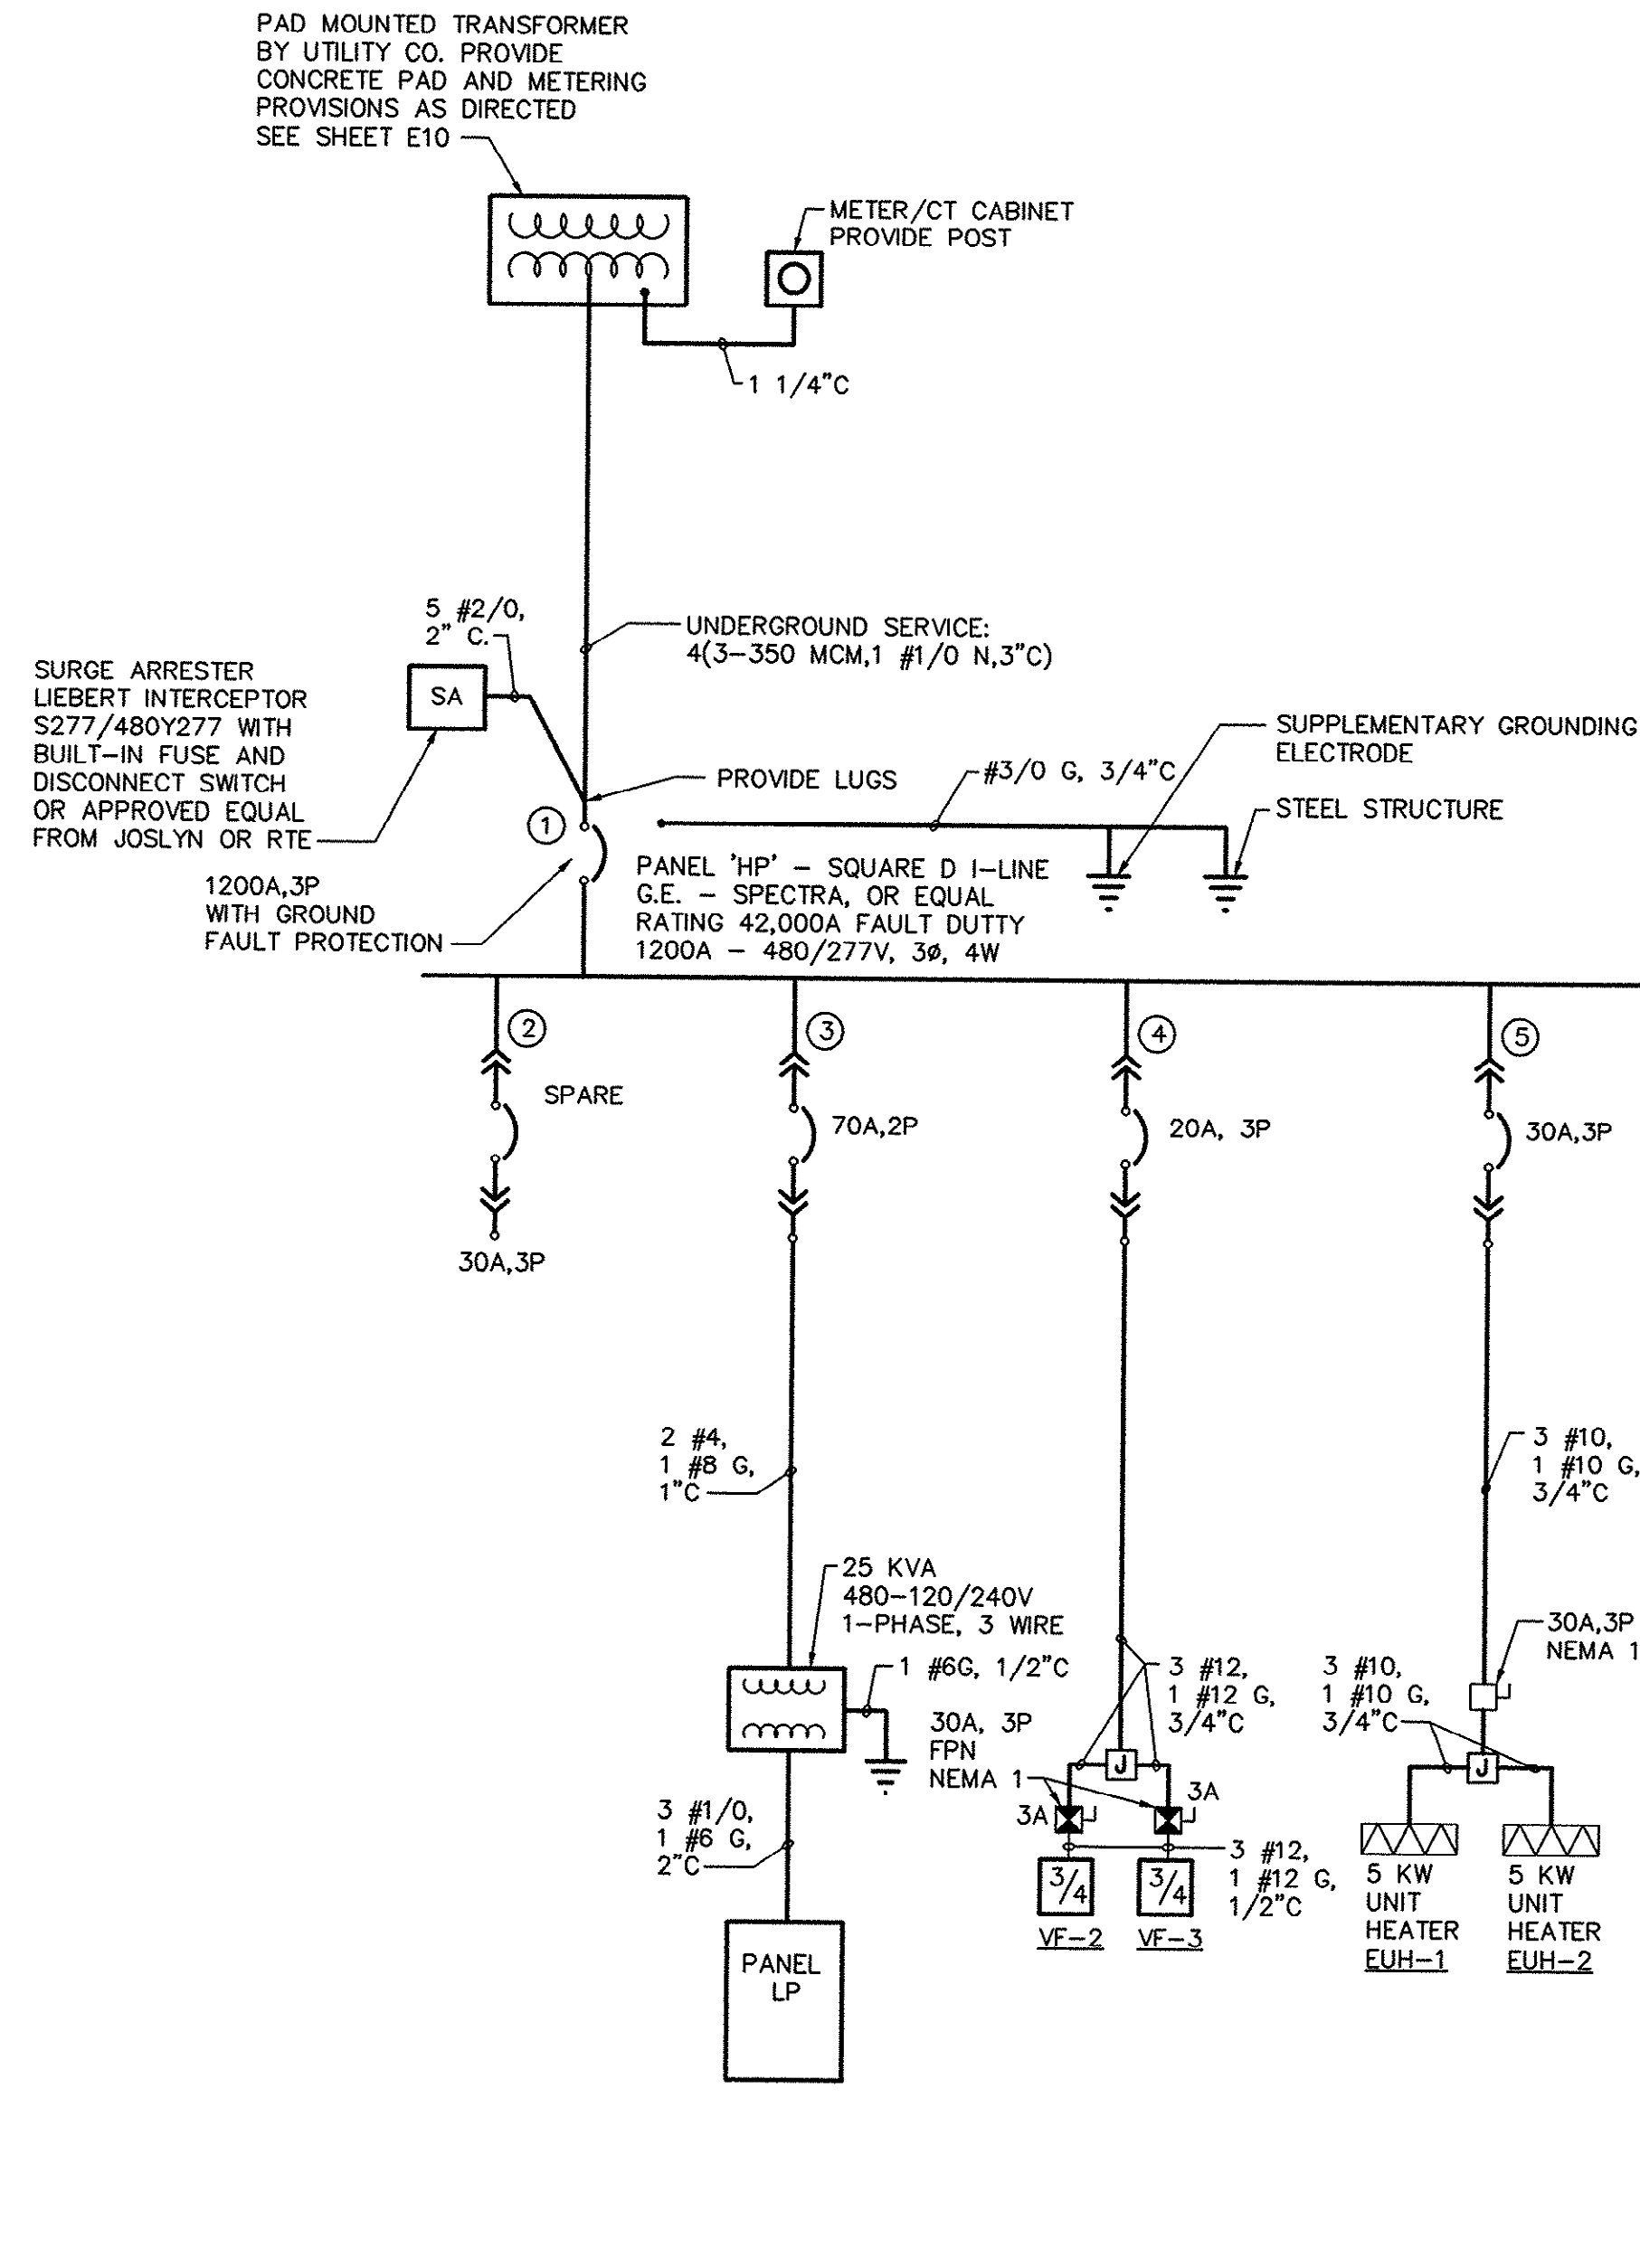

ONE-LINE POWER RISER DIAGRAM

NOT TO SCALE

NOTE:

- BREAKERS FOR PUMPS SHALL HAVE PROVISIONS FOR PAD LOCKING IN "OFF" POSITION. ALSO, PROVIDE AUXILIARY 5A, 120V CONTACT ON EACH CIRCUIT BREAKER TO OPEN WHEN BREAKER IS IN OPEN POSITION.
- ALL BREAKERS SHALL BE PLUG-IN.


THESE DRAWINGS REFLECT
AS-BUILT
CONDITIONS

REVIEWED BY: _____ DATE: _____
INSPECTIONS

REVIEWED BY: _____ DATE: _____
ENGINEERING


GRAND STRAND WATER AND SEWER AUTHORITY

ONE-LINE POWER DIAGRAM

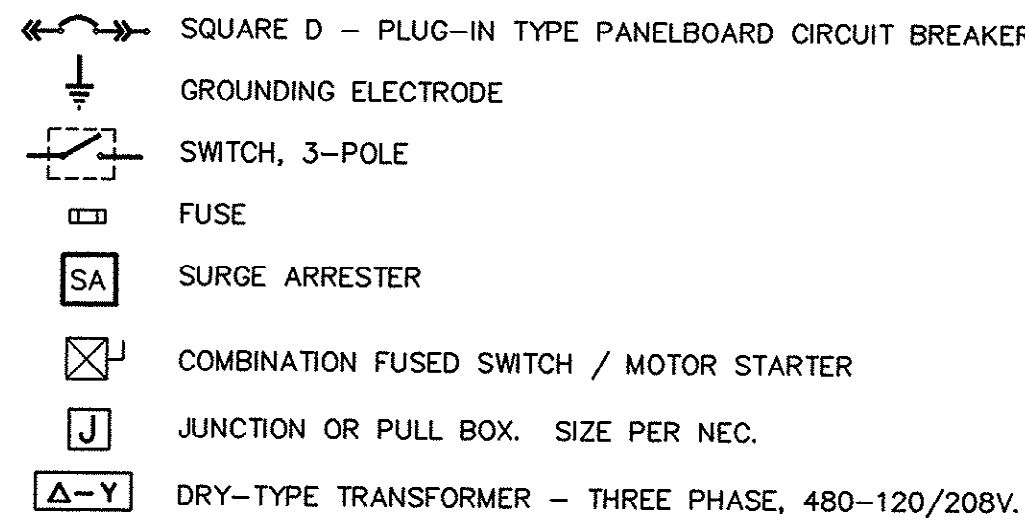

LOAD TABULATION

LIGHTING	1.3	KVA
A/C	1.7	KVA
HEATING	4.4	KVA
RECEPTACLES	1.6	KVA
PROCESS	442.8	KVA
TOTAL	451.8	KVA
FUTURE PUMPS	143.4	KVA
TOTAL + FUTURE PUMP	595.2	KVA
595.2 KVA @ 480V, 3Ø	747.7	A
+ 25% LARGEST MOTOR	45.0	A
+ 25% LIGHTING	2.7	A
	795.4	A
+ 25% SPARE	198.9	A
TOTAL	994.25	A

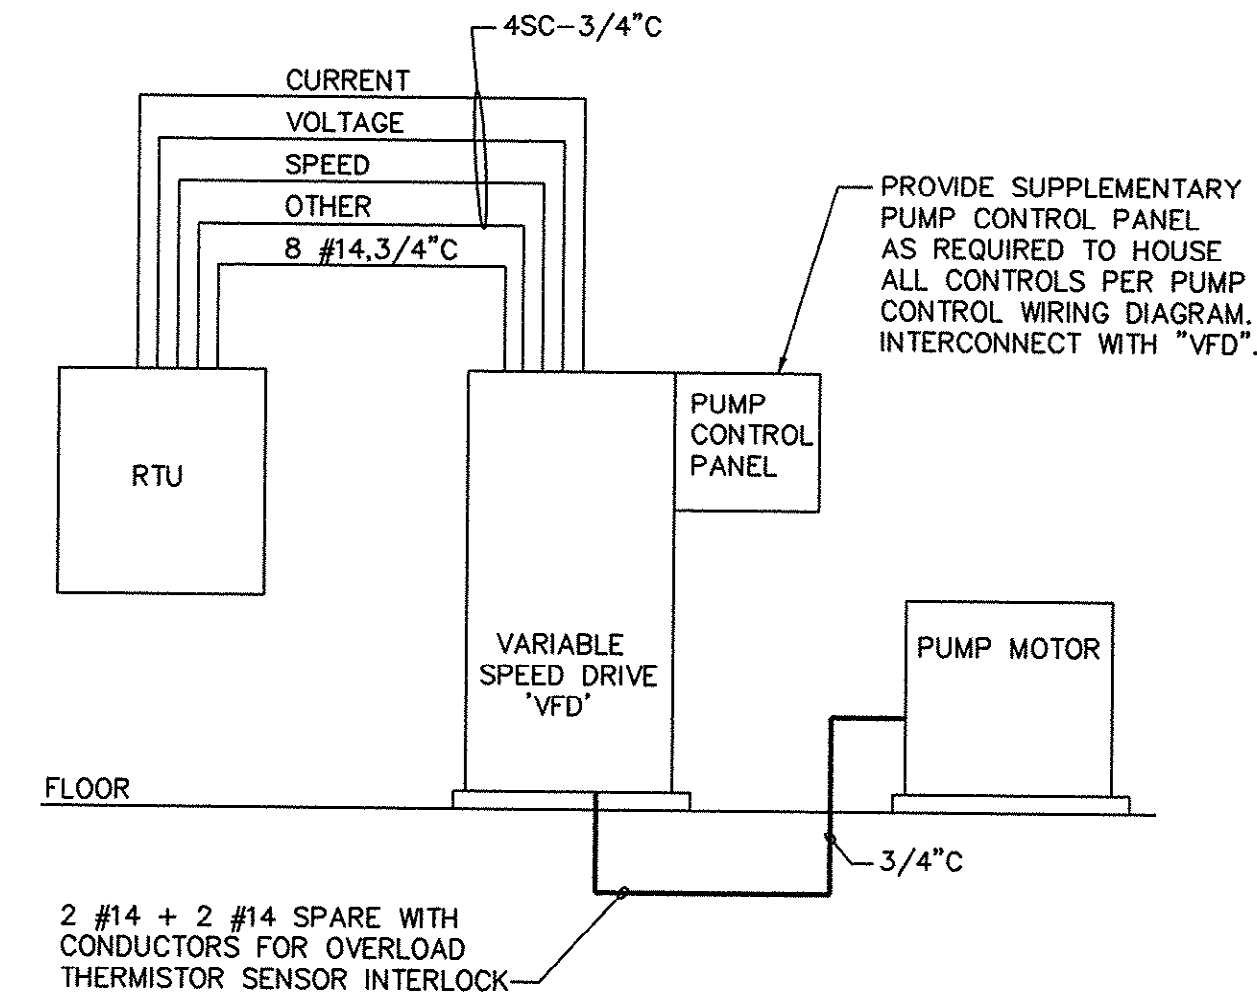

TYPICAL CONTROL WIRING RISER DIAGRAM PUMPS NO. 1, NO. 2 AND NO. 3

NOT TO SCALE

NOTE:

- CONNECT TO RTU AND TO VFD AS DIRECTED BY EQUIPMENT SUPPLIER. LEAVE 6-FOOT OF SLACK AT EACH END.

LOAD (KVA)				DESCRIPTION	WIRE SIZE	BRKR RAT'G	CKT. NO.	WIRE SIZE	BRKR RAT'G	CKT. NO.	LOAD (KVA)			
PH1	PH2										PH1	PH2		
0.7	0.7			LIGHTING	12	20/1	1	2	30/2	10	AC-1		2.3	
				LIGHTING	12	20/1	3	4		10			2.3	
0.7	0.9			RECEPTACLES	12	20/1	5	6	30/2	10	AC-2		2.3	
				RECEPTACLES	12	20/1	7	8		10			2.3	
0.2	0.2			LOUVERS	12	20/1	9	10	30/2	10	AC-3		2.3	
0.1				FAC	12	20/1	13	12		10			2.3	
	0.1			RTU	12	20/1	15	14	20/1	12	PRESSURE TRANS.	0.0		
0.0				SPARE		20/1	17	16	20/1		SPARE	0.0		
	0.0			SPARE		20/1	19	18	20/1		SPARE	0.0		
0.0				SPARE		20/1	21	20	20/1		SPARE	0.0		
	0.0			SPARE		20/1	23	22	20/1		SPARE	0.0		
0.0				SPARE		20/1	25	24	20/1		SPARE	0.0		
	0.0			SPARE		20/1	27	26	20/1		SPARE	0.0		
0.0				SPARE		20/1	29	28	20/1		SPARE	0.0		
	0.0			SO			31	30	20/1		SPARE	0.0		
0.0				SO			33	32			SO	0.0		
	0.0			SO			35	34			SO	0.0		
0.0				SO			37	36			SO	0.0		
	0.0			SO			39	38			SO	0.0		
0.0				SO			41	40			SO	0.0		
								42			SO	0.0		
TYPE: BRANCH CIRCUIT				GROSS PHASE TOTALS				CONNECTED LOAD				72.5 AMPERES		
MOUNTING: SURFACE				PH1= 8.6 KVA				LIGHTING				1.4 KVA		
SUPPLY: 240/120V, 1-PH, 3W				PH2= 8.8 KVA				HEATING				0.0 KVA		
MAINS: 150A MCB								A/C MOTORS & HEAT PUMPS				13.8 KVA		
SCIR: 10,000A								AIR HANDLING & EXH FANS				0.2 KVA		
NOTES:								RECEPTACLES				1.8 KVA		
1. WITH EQUIPMENT GROUND BUS.								ELECTRIC WATER HEATING				0.0 KVA		
								ELEVATORS				0.0 KVA		
								FOOD PROCESSING				0.0 KVA		
								PROCESS				0.0 KVA		
								MISCELLANEOUS				0.2 KVA		
								TOTAL CONNECTED LOAD				17.4 KVA		

PANEL LP

IRRIGATION BOOSTER
PUMP STATION
ONE-LINE-
POWER DIAGRAM

TIP-TOP TREE FARM
EFFLUENT LAND
APPLICATION PROJECT
GRAND STRAND WATER
AND SEWER AUTHORITY

DATE: SEPTEMBER 8, 1999

DESIGNED: DL

DRAWN: D.B.M.

CHECKED: DL

SCALE: AS SHOWN


SHEET NO.

E2

OF: 10

45-003-047/53

J:\GS9901\800\820\ELECT\E4.dwg EDITED BY: ARABON DATE: 09/29/01 TIME: 11:34 XREFS: J:\GS9901\800\825\ELECT\X-TITLE.dwg Layout: Model

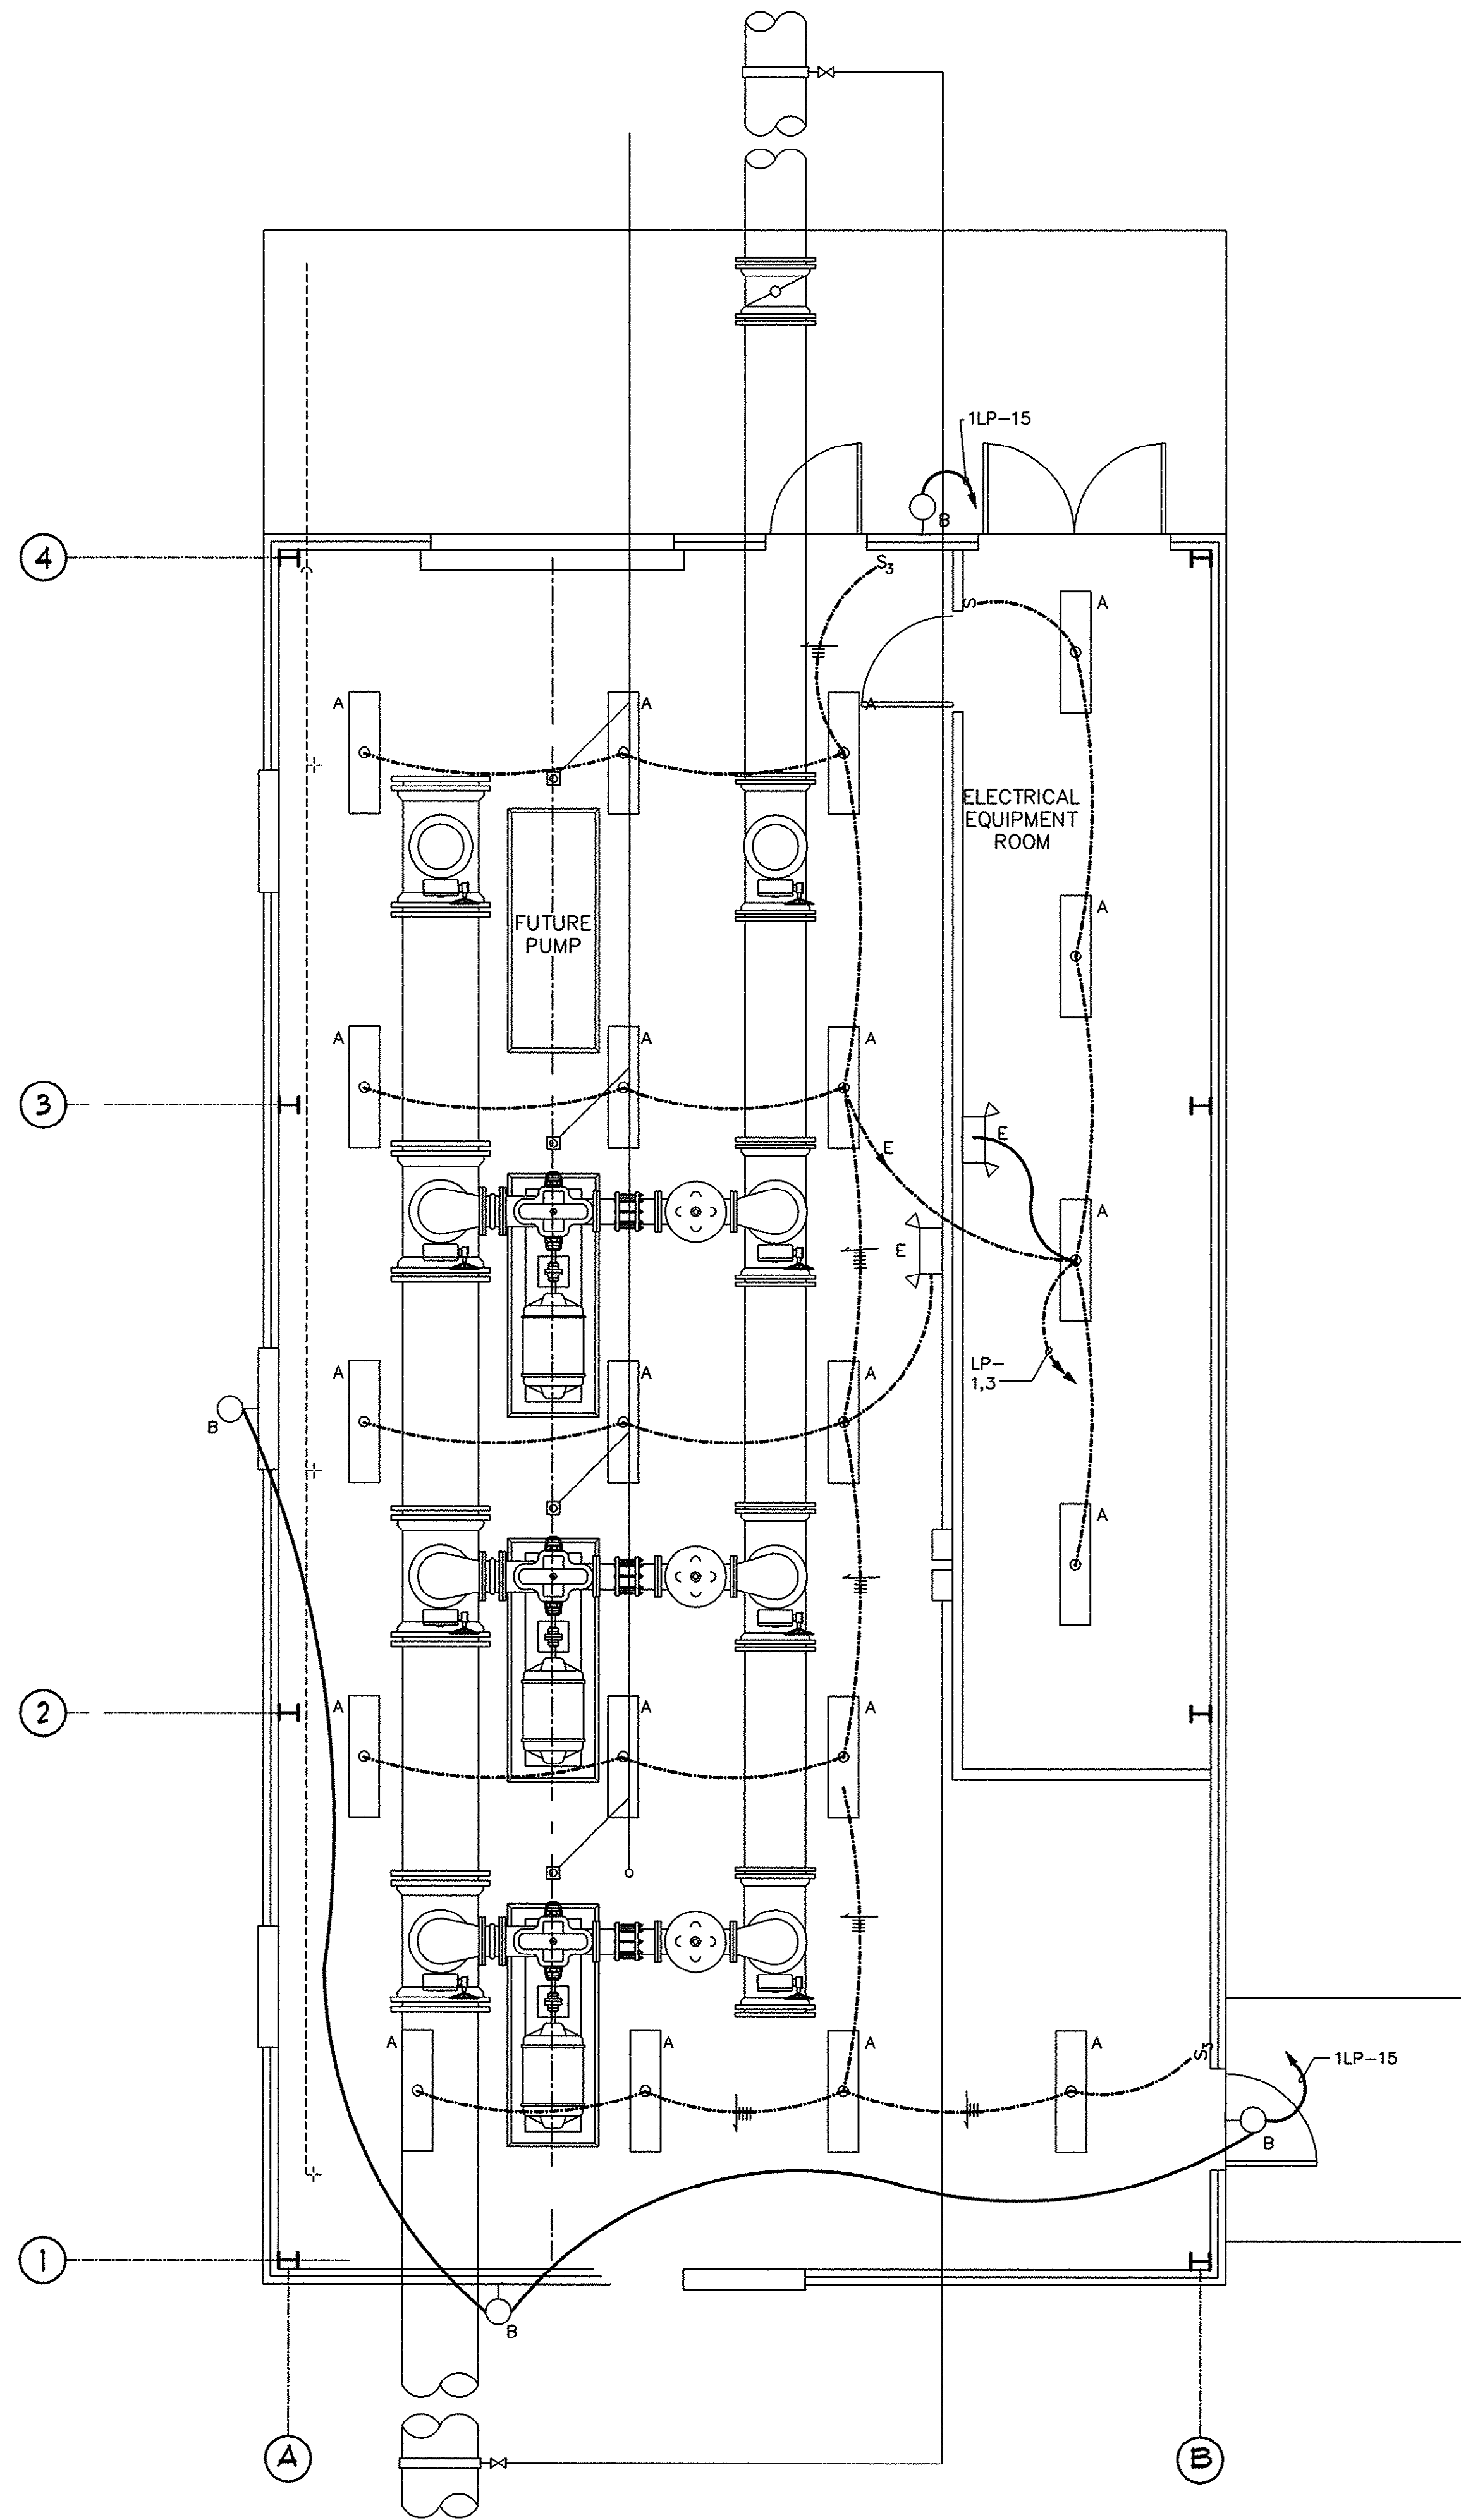


PUMP STATION - ELECTRICAL PLAN

SCALE: 1/4" = 1'-0"

THESE DRAWINGS REFLECT
AS-BUILT
CONDITIONS

REVIEWED BY:	INSPECTIONS	DATE
REVIEWED BY:	ENGINEERING	DATE


GRAND STRAND WATER AND SEWER AUTHORITY

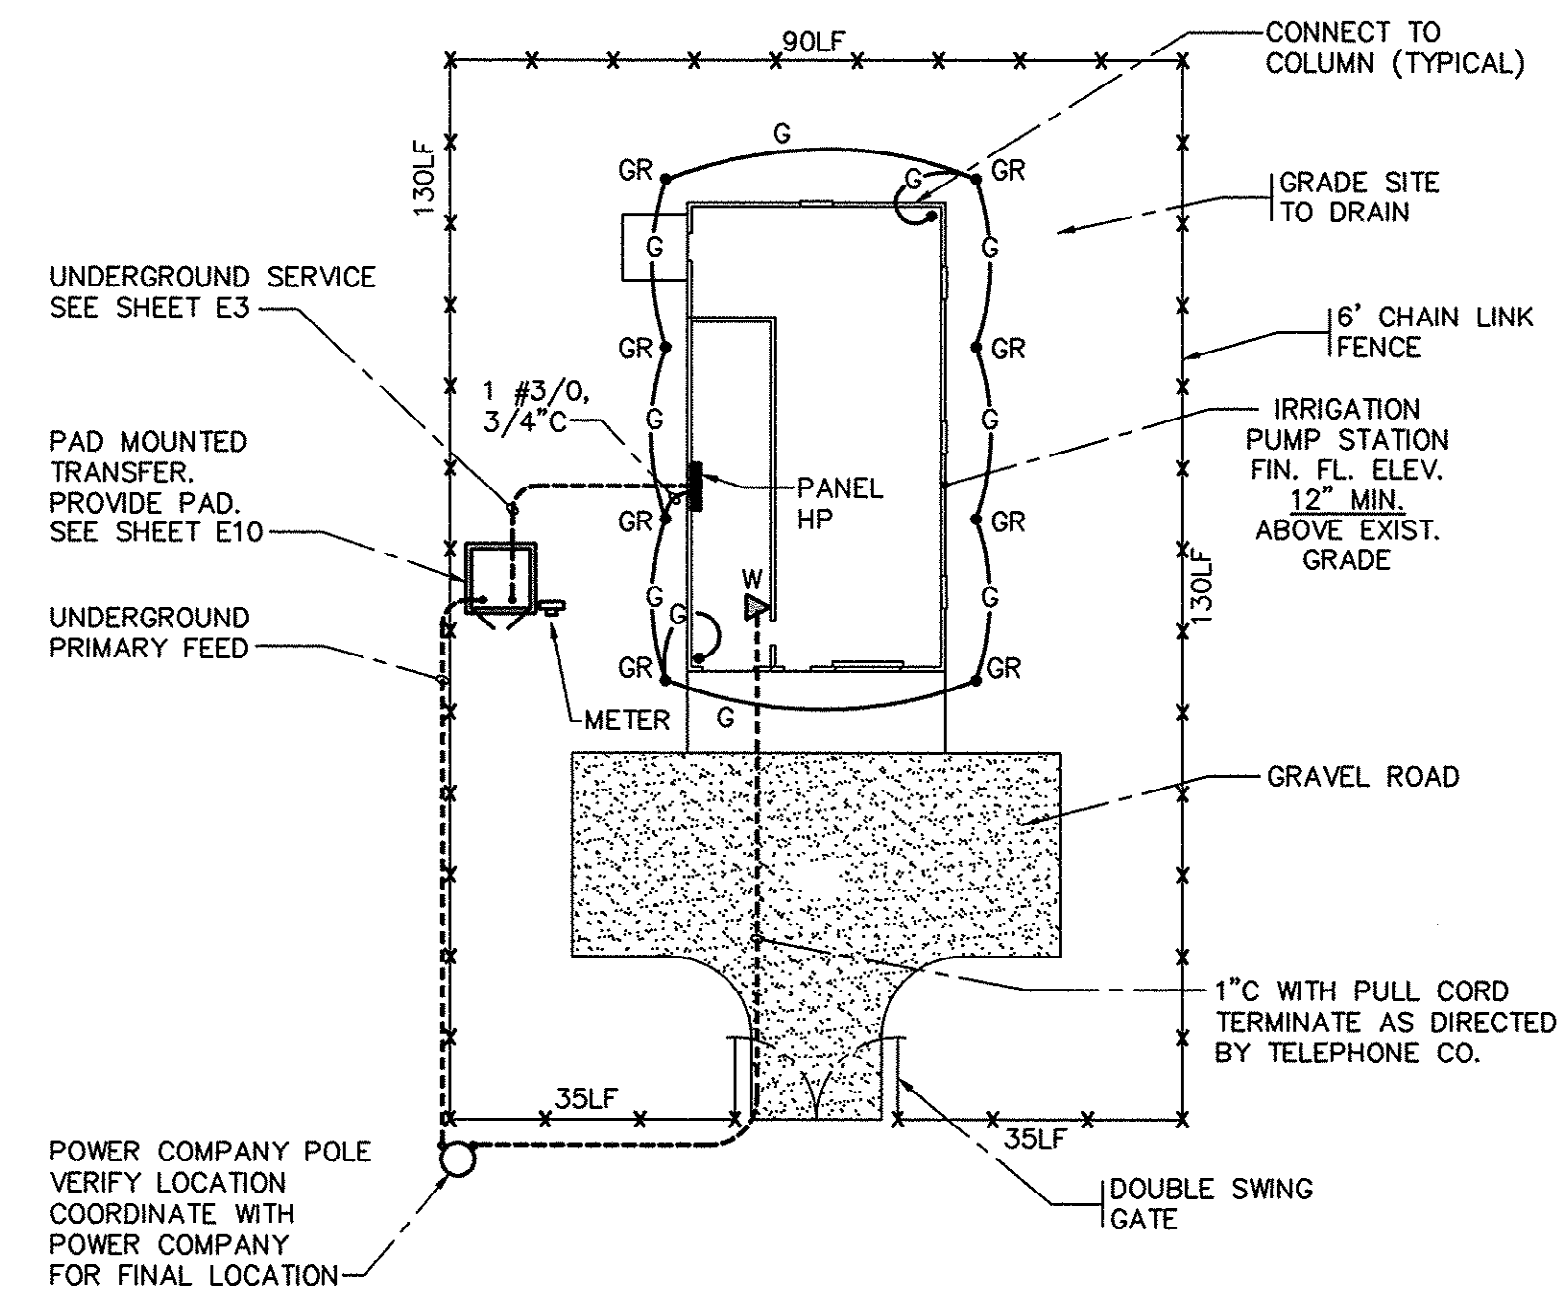

IRRIGATION PUMP STATION - SITE PLAN

N.T.S.

REVISIONS	
DATE	BY
8/27/01	CAR
DESCRIPTION	AS-BUILT
SYM.	

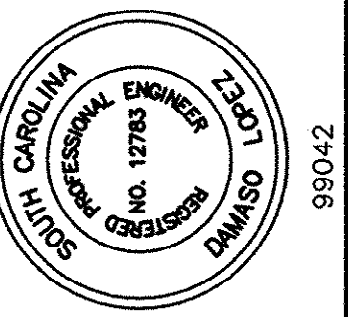

HOBBES, UPCHURCH & ASSOCIATES, P.A.
CONSULTING ENGINEERS
MYRTLE BEACH, SOUTH CAROLINA 29577



**PUMP STATION
ELECTRICAL
LIGHTING PLAN**


**TIP-TOP TREE FARM
EFFLUENT LAND
APPLICATION PROJECT
GRAND STRAND WATER
AND SEWER AUTHORITY**

DATE: SEPTEMBER 8, 1999
DESIGNED: DL
DRAWN: D.B.M.
CHECKED: DL
SCALE: AS SHOWN

SHEET NO.
E4
OF 10

45-003-041/53

J:\GS9901\800\820\ELECT\ES.dwg EDITED BY: ARABON DATE: 08/29/01 TIME: 11:36 XREFS: J:\GS9901\800\825\ELECT\X-TITLE.dwg Layout: Model

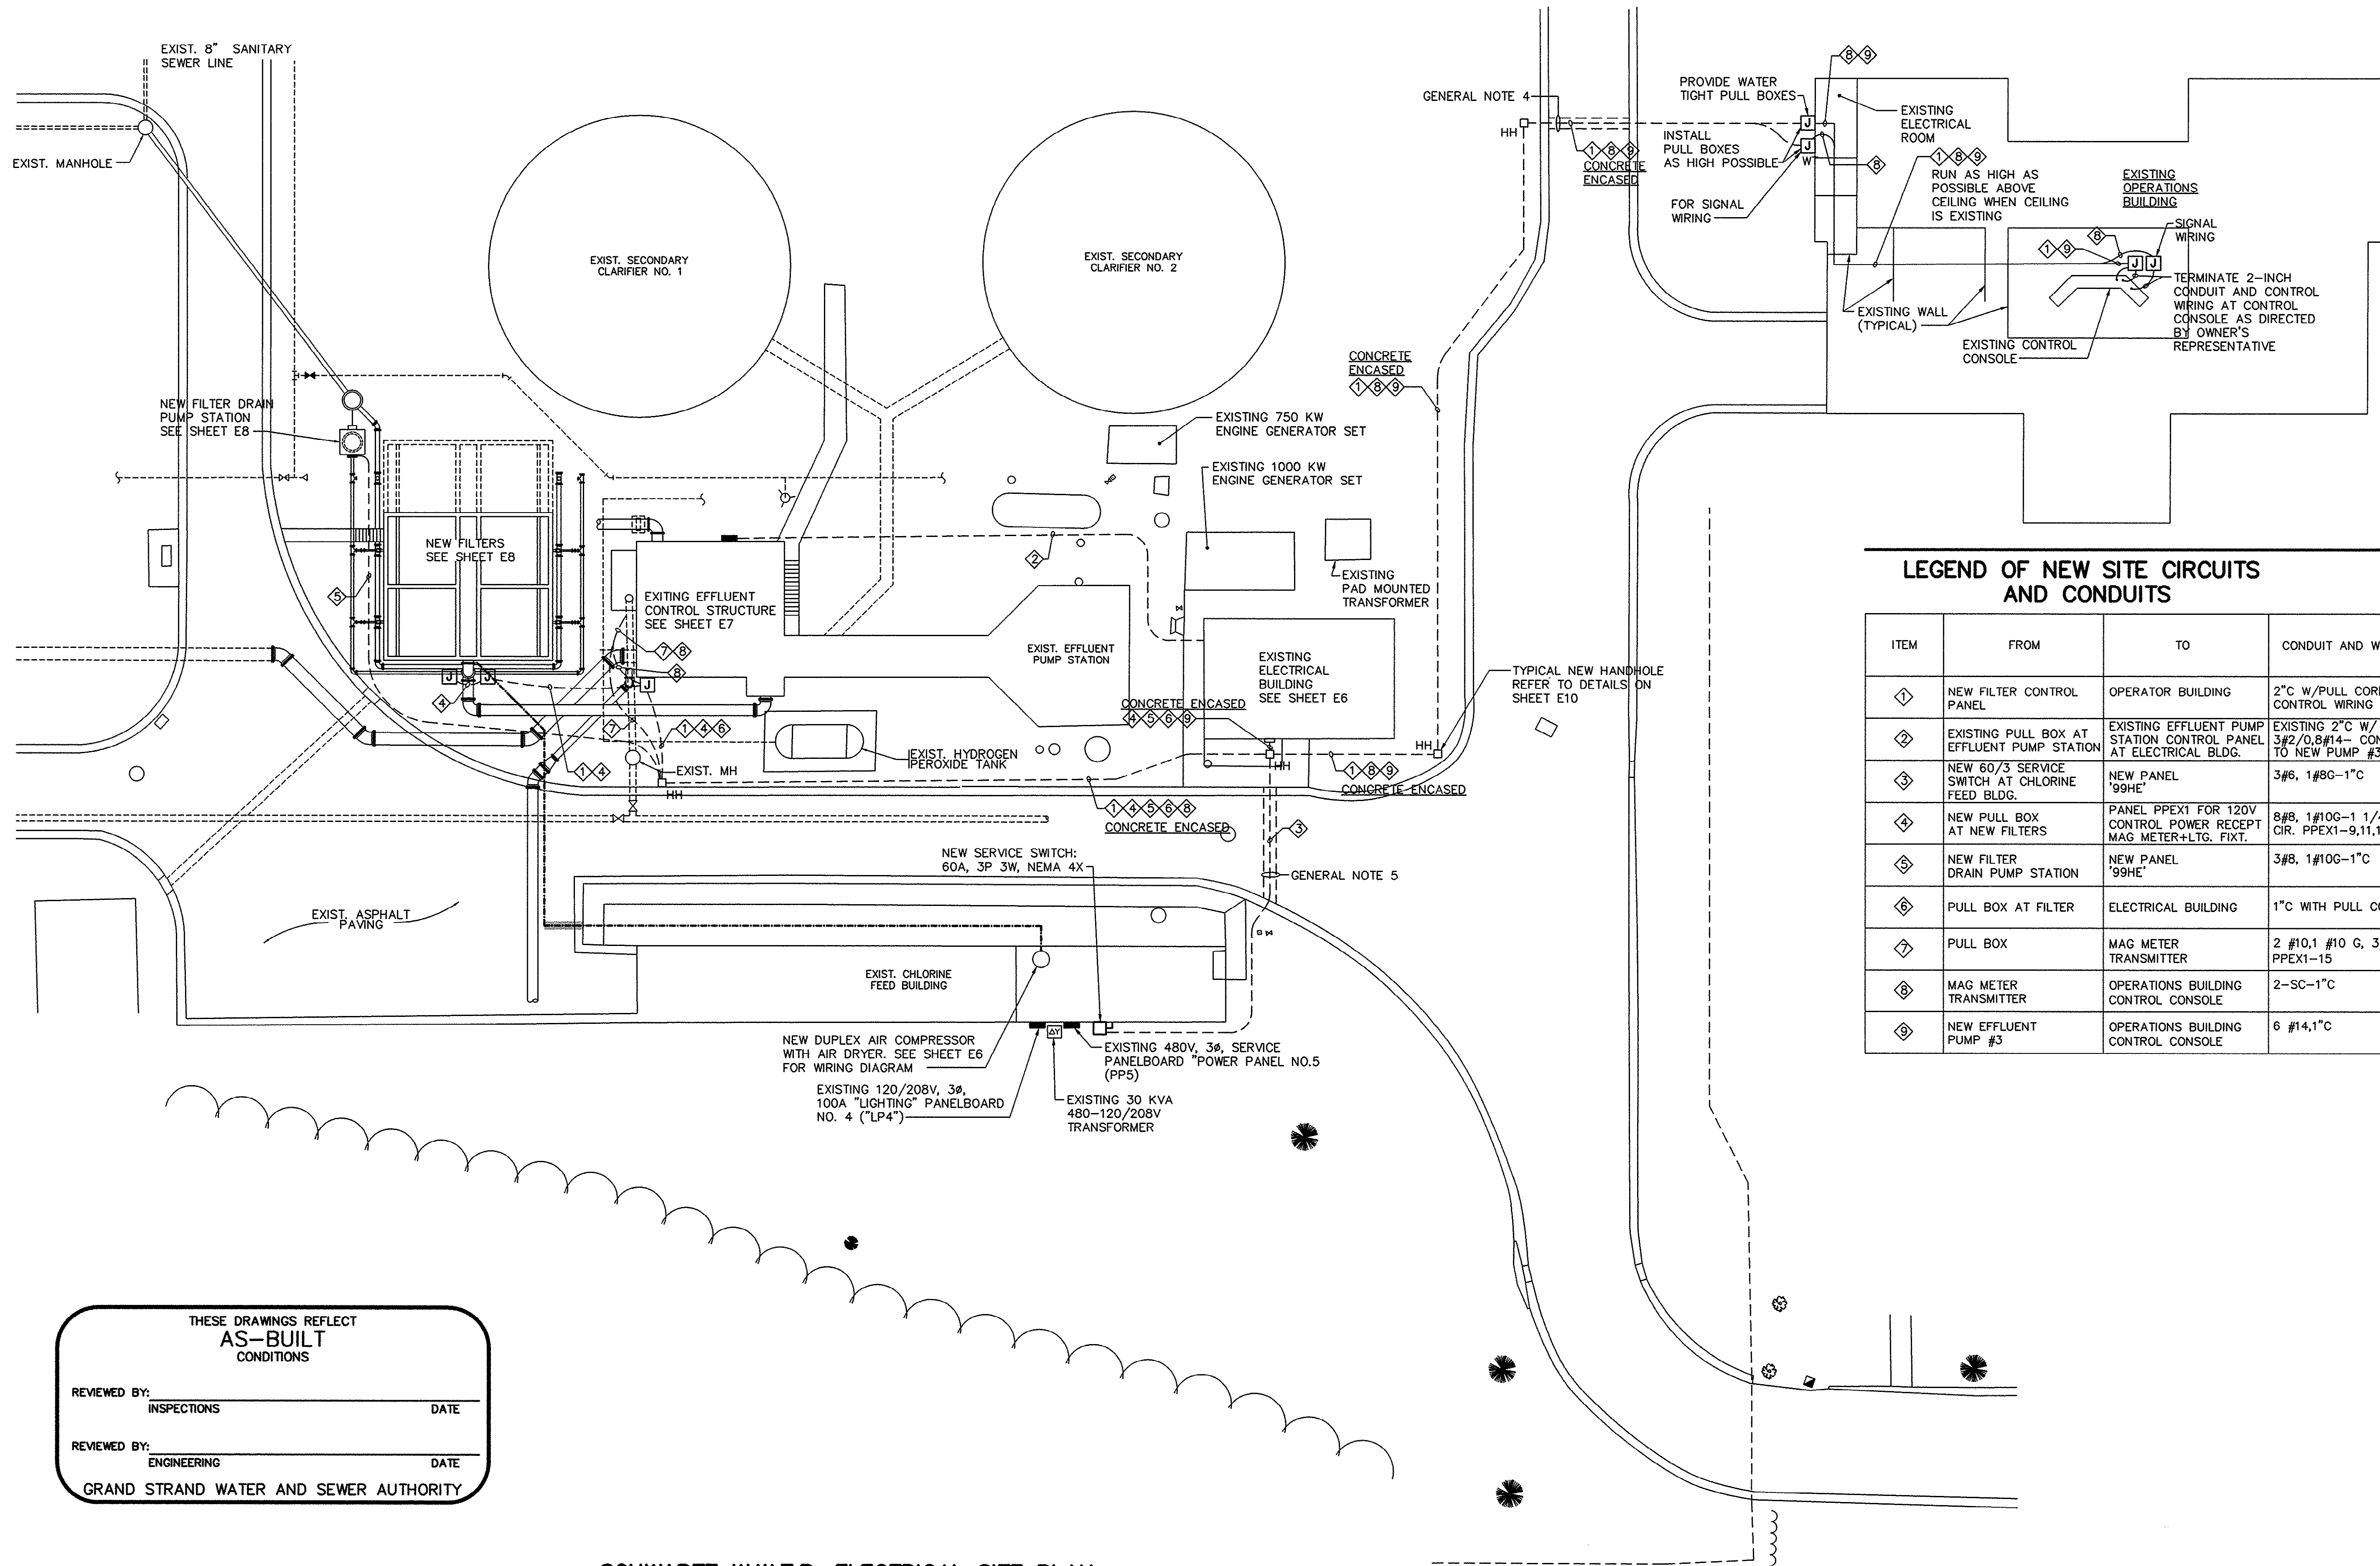

LEGEND OF NEW SITE CIRCUITS AND CONDUITS

ITEM	FROM	TO	CONDUIT AND WIRING
1	NEW FILTER CONTROL PANEL	OPERATOR BUILDING	2" C W/PULL CORD FOR CONTROL WIRING BY OTHERS.
2	EXISTING PULL BOX AT EFFLUENT PUMP STATION	EXISTING EFFLUENT PUMP STATION CONTROL PANEL AT ELECTRICAL BLDG.	EXISTING 2" C W/ NEW 3/2" Ø #14- CONNECT TO NEW PUMP #3 STARTER.
3	NEW 60/3 SERVICE SWITCH AT CHLORINE FEED BLDG.	NEW PANEL '99HE'	3#6, 1#8G-1" C
4	NEW PULL BOX AT NEW FILTERS	PANEL PPEX1 FOR 120V CONTROL POWER RECEPT MAG METER+LTG. FIXT.	8#8, 1#10G-1 1/4" C FOR CIR. PPEX1-9,11,13,15,17,19
5	NEW FILTER DRAIN PUMP STATION	NEW PANEL '99HE'	3#8, 1#10G-1" C
6	PULL BOX AT FILTER	ELECTRICAL BUILDING	1" C WITH PULL CORD-SPARE
7	PULL BOX	MAG METER TRANSMITTER	2 #10, 1 #10 G, 3/4" C PPEX1-15
8	MAG METER TRANSMITTER	OPERATIONS BUILDING CONTROL CONSOLE	2-SC-1" C
9	NEW EFFLUENT PUMP #3	OPERATIONS BUILDING CONTROL CONSOLE	6 #14, 1" C

THESE DRAWINGS REFLECT
AS-BUILT
CONDITIONS

REVIEWED BY: _____ DATE _____
INSPECTIONS

REVIEWED BY: _____ DATE _____
ENGINEERING

GRAND STRAND WATER AND SEWER AUTHORITY


SCHWARTZ W.W.T.P. ELECTRICAL SITE PLAN

SCALE: 1" = 20'-0"

GENERAL NOTES

- CONDUITS SPECIFIED ABOVE SHALL BE ENCASED IN 2-INCHES OF CONCRETE.
- CONTRACTOR SHALL SELECT A FINAL CONDUIT ROUTE IN COORDINATION WITH OWNER REPRESENTATIVE THAT BEST FITS EXISTING CONDITIONS. CONTRACTOR SHALL PAY FOR THE SERVICES OF A CONDUIT/PIPING LOCATION OUTFIT TO IDENTIFY AND WORKS EXISTING UNDERGROUND UTILITIES ALONG FINAL NEW CONDUIT ROUTE.
- CONTRACTOR SHALL WATERPROOF ALL PENETRATIONS INTO EXISTING BUILDING.
- CONDUIT IN EXISTING BUILDINGS SHALL BE RUN AS HIGH AS POSSIBLE, PARALLEL, AND PERPENDICULAR TO WALLS AND CEILING. RUN CONDUIT ABOVE CEILING IF LAY-IN CEILING EXISTS.
- BORE UNDER EXISTING ROAD AS THE PREFERRED METHOD TO CROSS UNDER ROAD SURFACES, OTHERWISE CUT, TRENCH, BACKFILL AND PATCH TO RESTORE PAVEMENT TO ORRIGINAL CONDITION.

SYMBOL	REVISIONS	DATE	BY
	DESCRIPTION	8/27/01	CAR
	AS-BUILT		

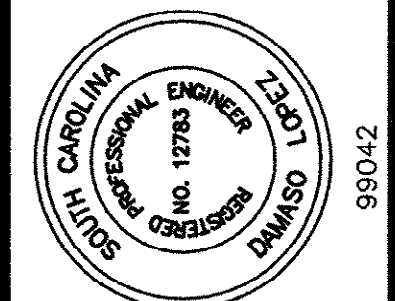

HOBBS, UPCHURCH & ASSOCIATES, P.A.
CONSULTING ENGINEERS
MYRTLE BEACH, SOUTH CAROLINA 29577



SCHWARTZ W.W.T.P.
ELECTRICAL
SITE PLAN

TIP-TOP TREE FARM
EFFLUENT LAND
APPLICATION PROJECT
GRAND STRAND WATER
AND SEWER AUTHORITY

DATE: SEPTEMBER 8, 1999
DESIGNED: DL
DRAWN: D.B.M.
CHECKED: DL
SCALE: AS SHOWN

SHEET NO.

E5

OF: 10


45-003-048/53

TYPE: BRANCH CIRCUIT	GROSS PHASE TOTALS		CONNECTED LOAD	41.9 AMPERES
MOUNTING: SURFACE	A=	11.6 KVA	LIGHTING	0.0 KVA
SUPPLY: 480V, 3-PH, 3W	B=	11.6 KVA	HEATING	0.0 KVA
MAINS: 100A MLO	C=	11.6 KVA	A/C MOTORS & HEAT PUMPS	0.0 KVA
SCIR: 42,000A			AIR HANDLING & EXH FANS	0.0 KVA
NOTES:			RECEPTACLES	0.0 KVA
1. WITH EQUIPMENT GROUND BUS.			ELECTRIC WATER HEATING	0.0 KVA
			ELEVATORS	0.0 KVA
			FOOD PROCESSING	0.0 KVA
			PROCESS	12.3 KVA
			MISCELLANEOUS	22.5 KVA
PANEL 99HE			TOTAL CONNECTED LOAD	34.8 KVA

TYPE: BRANCH CIRCUIT	GROSS PHASE TOTALS	CONNECTED LOAD	27.5 AMPERES
MOUNTING: SURFACE	A= 3.4 KVA	LIGHTING	0.2 KVA
SUPPLY: 208/120V, 3-PH, 4W	B= 3.3 KVA	HEATING	0.0 KVA
MAINS: 70A, MCB	C= 3.3 KVA	A/C MOTORS & HEAT PUMPS	0.0 KVA
SCIR: 10.000A		AIR HANDLING & EXH FANS	0.0 KVA
NOTES:		RECEPTACLES	0.4 KVA
1. WITH EQUIPMENT GROUND BUS.		ELECTRIC WATER HEATING	8.0 KVA
* INDICATES EXISTING CIRCUIT. REMOVE FROM OLD PANEL AND		ELEVATORS	0.0 KVA
CONNECT TO NEW PANEL.		FOOD PROCESSING	0.0 KVA
		PROCESS	0.0 KVA
		MISCELLANEOUS	1.4 KVA
PANEL PPEX1		TOTAL CONNECTED LOAD	9.9 KVA



J:\CS9901\800\825\ELECT\X-TITLE.dwg Layout: Model 11:43 XREFS: J:\CS9901\800\825\ELECT\X-TITLE.dwg DATE: 08/29/01 TIME: 11:43 MB J:\CS9901\800\825\ELECT\X-TITLE.dwg EDITED BY: ARABON DATE: 08/29/01

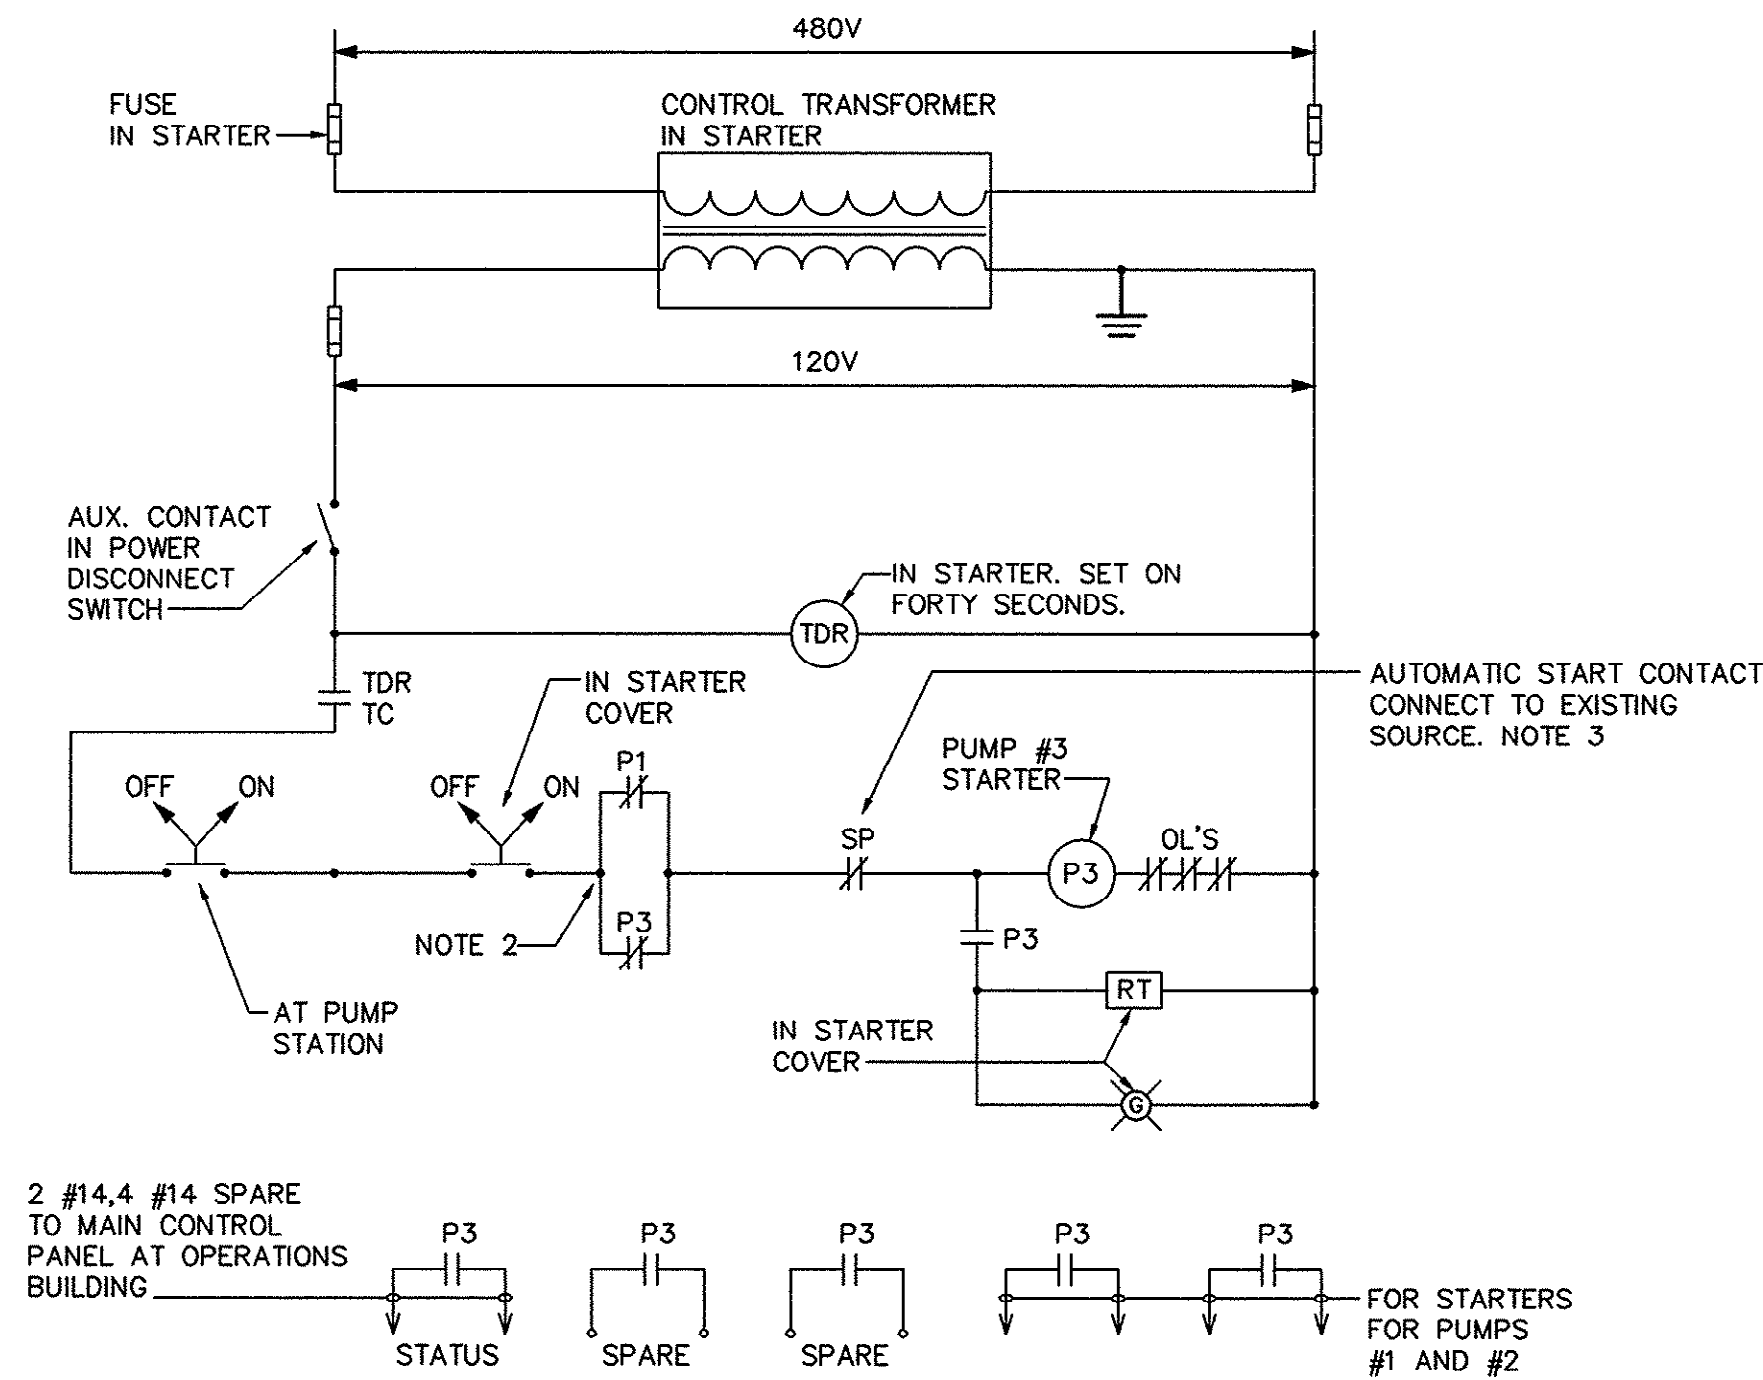


NEW EFFLUENT PUMP CONTROL WIRING DIAGRAM

NOT TO SCALE
NOTES:

1. NEW PUMP CONTROLS SHALL BE INTERLOCKED WITH EXISTING PUMP CONTROLS SO THAT AT ANY TIME NOT MORE THAN TWO 100 HP PUMPS ARE IN OPERATION AT THE SAME TIME.
2. ADD AUXILIARY RELAY AND CONTACTS TO BLOWERS #1, #2, AND #3 STARTING CIRCUITS TO ACCOMPLISH INTERLOCK WITH BLOWER #4.
3. PROVIDE AUXILIARY RELAY AND CONTACTS TO OBTAIN CONTACT FOR AUTOMATIC START/STOP.
4. PROVIDE PILOT LIGHT IN EXISTING CONSOLE AT OPERATIONS BUILDING TO INDICATE PUMP RUNNING.

CONTROL WIRING DIAGRAM LEGEND

- NORMALLY OPEN CONTACT.
- NORMALLY CLOSED CONTACT.
- TIME DELAY ON ENERGIZATION RELAY. RANGE OF 0-200 SECONDS.
- TIME DELAY RELAY CONTACT - TIMES CLOSED.
- MAINTAINED CONTACT SELECTOR SWITCH.
- RUN TIME METER.
- GREEN PILOT LIGHT.
- RED PILOT LIGHT.
- CONTACTS FROM SINGLE PHASE RELAY IN STARTER.

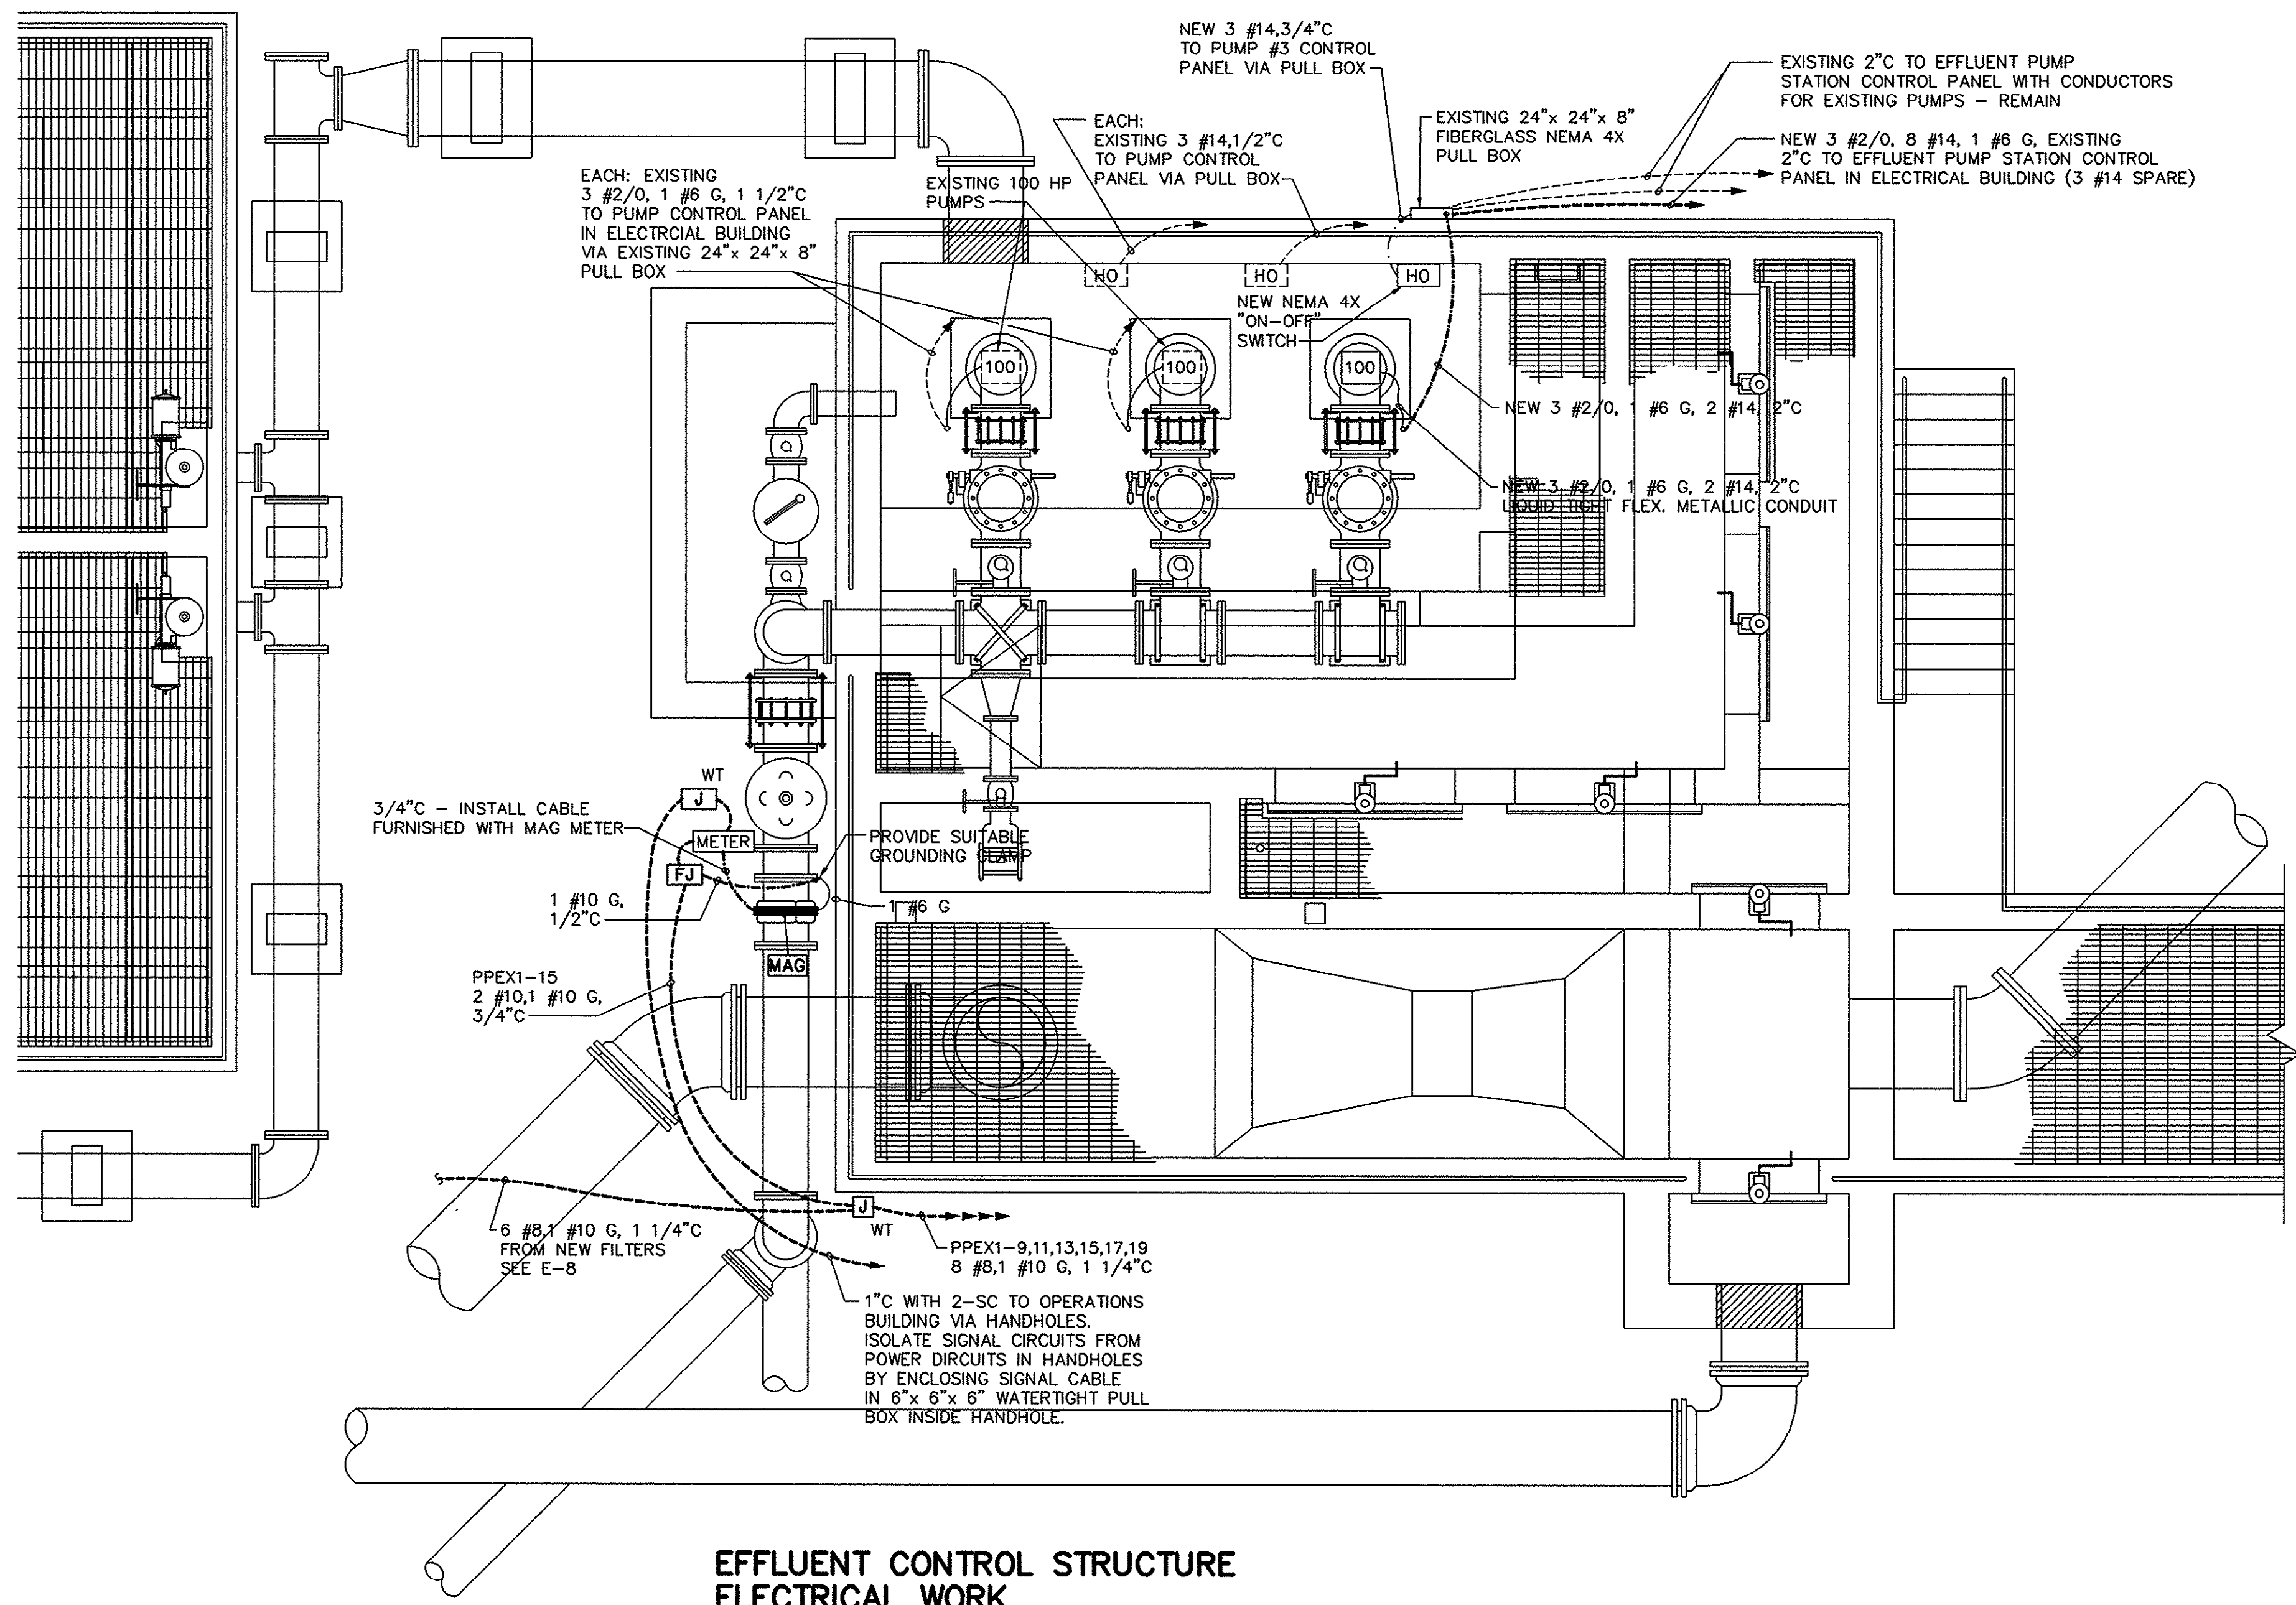

EFFLUENT CONTROL STRUCTURE ELECTRICAL WORK


SCALE: 1/4" = 1'-0"

NOTES:

1. ALL WORK SHOWN IS NEW, EXCEPT AS OTHERWISE NOTED.

THESE DRAWINGS REFLECT AS-BUILT CONDITIONS	
REVIEWED BY:	DATE
INSPECTIONS	
REVIEWED BY:	DATE
ENGINEERING	
GRAND STRAND WATER AND SEWER AUTHORITY	

SYMBOL	DESCRIPTION	DATE	BY
AS-BUILT	AS-BUILT	8/27/01	CAR

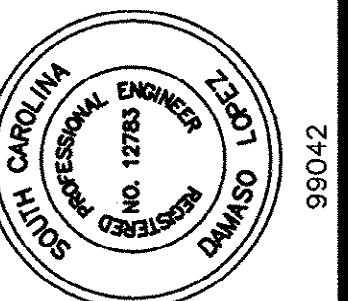

HOBBS, UPCHURCH & ASSOCIATES, P.A.
CONSULTING ENGINEERS
MYRTLE BEACH, SOUTH CAROLINA 29577



SCHWARTZ W.W.T.P.
EFFLUENT CONTROL
STRUCTURE ELECTRICAL
WORK


TIP-TOP TREE FARM
EFFLUENT LAND
APPLICATION PROJECT
GRAND STRAND WATER
AND SEWER AUTHORITY

DATE: SEPTEMBER 8, 1999
DESIGNED: DL
DRAWN: D.B.M.
CHECKED: DL
SCALE: AS SHOWN
SHEET NO. E7

45-003-001/53

J:\CS9901\800\820\ELECT\ES.dwg EDITED BY: ARISON DATE: 08/29/01 TIME: 11:56 XREFS: J:\CS9901\800\820\ELECT\Y-TITLE.dwg Layout: Model

HOBBS, UPCHURCH & ASSOC. MB

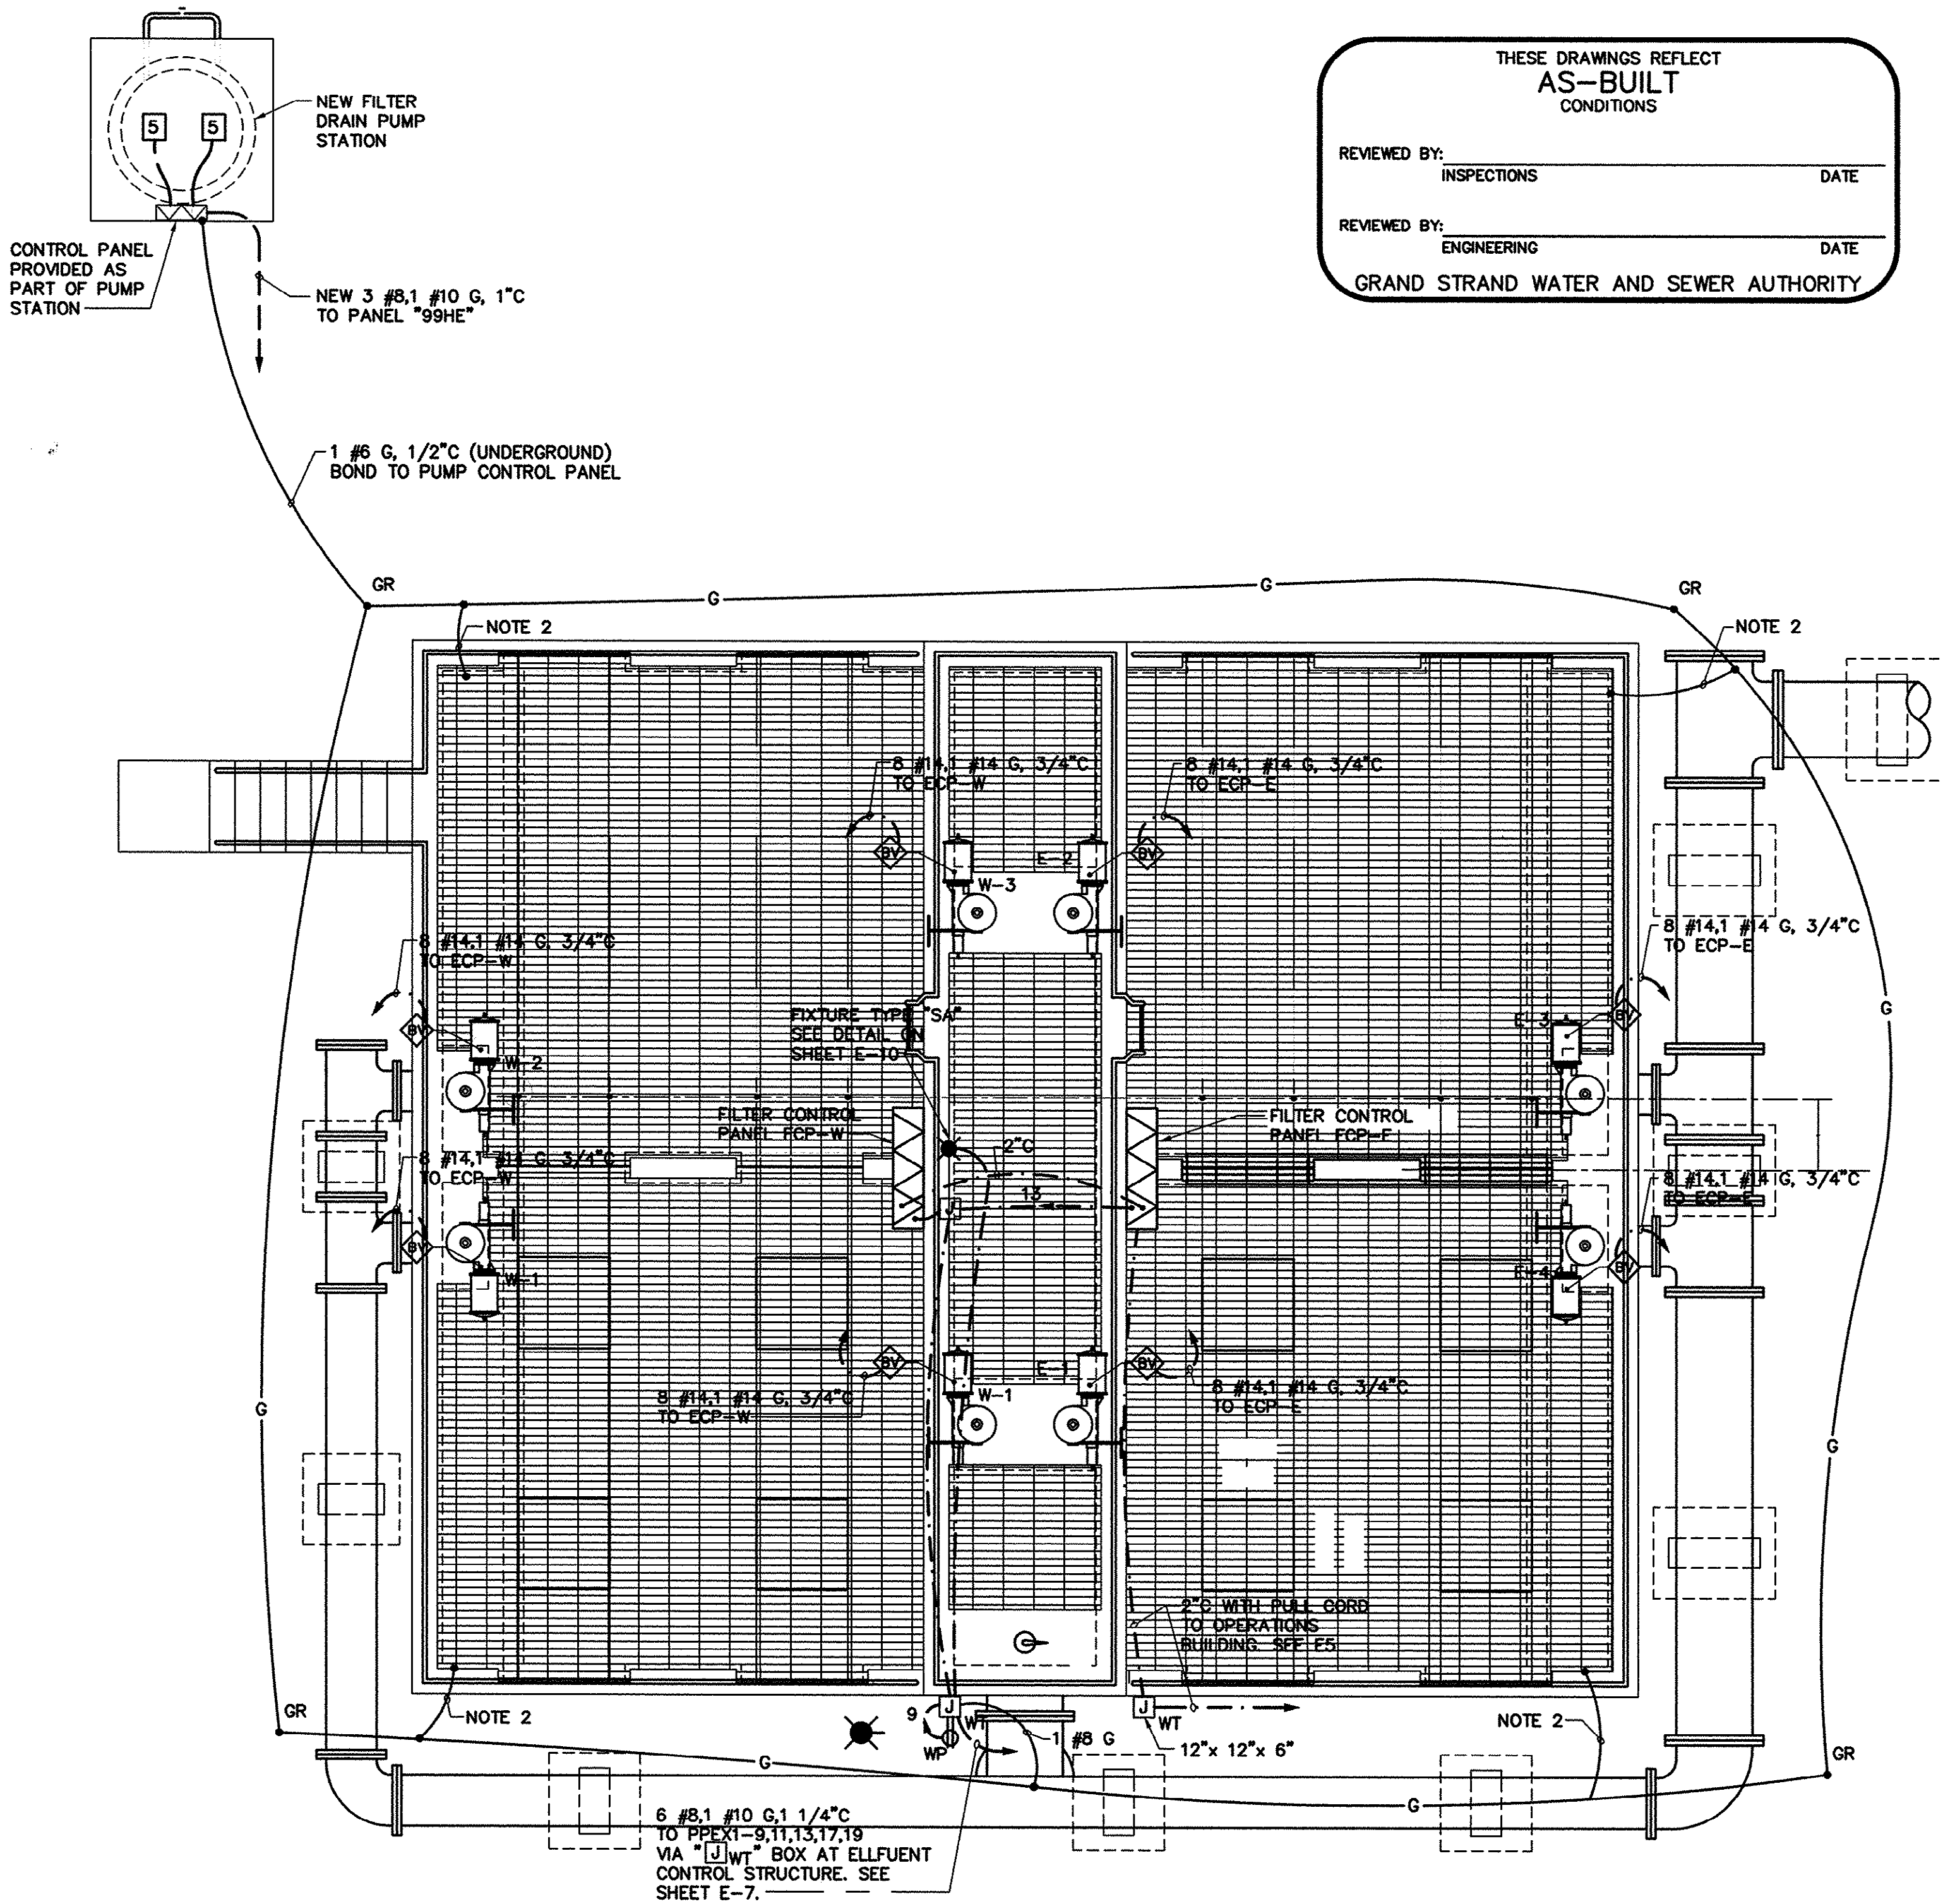

THESE DRAWINGS REFLECT
AS-BUILT
CONDITIONS

REVIEWED BY: _____ DATE _____
INSPECTIONS

REVIEWED BY: _____ DATE _____
ENGINEERING


GRAND STRAND WATER AND SEWER AUTHORITY

DEEP BED SAND FILTERS - ELECTRICAL WORK

SCALE: 1/4" = 1'-0"

- NOTES:
1. RUN CONDUIT ALONG STRUCTURAL MEMBERS OF FILTER AND UNDER GRATING. CONDUIT ABOVE GRADE SHALL BE PVC COATED RGSC.
 2. BOND STRUCTURAL METAL TO GROUND RING UTILIZING #2 AWG THWN CONDUCTOR AND SUITABLE CU/AL GROUND CONDUCTOR.

REVISIONS		DATE	BY
DESCRIPTION	AS-BUILT	8/27/01	CAR
SYM.			

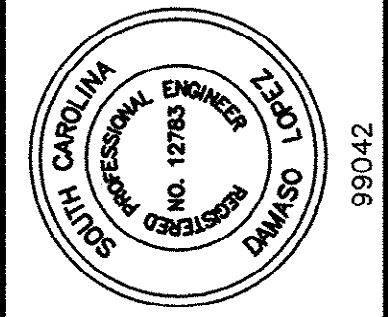

HOBBS, UPCHURCH & ASSOCIATES, P.A.
CONSULTING ENGINEERS
MYRTLE BEACH, SOUTH CAROLINA 29577

SCHWARTZ W.W.T.P.
DEEP BED SAND FILTERS
ELECTRICAL WORK


TIP-TOP TREE FARM
EFFLUENT LAND
APPLICATION PROJECT
GRAND STRAND WATER
AND SEWER AUTHORITY

DATE: SEPTEMBER 8, 1999
DESIGNED: DL
DRAWN: D.B.M.
CHECKED: DL
SCALE: AS SHOWN

SHEET NO.
E8


45-003-058/53

HOBBES, UPCHURCH & ASSOC. MB J:\GS9901\800\820\ELECT\ES.dwg EDITED BY: ARABON DATE: 08/29/01 TIME: 11:58 XREFS: J:\GS9901\800\825\ELECT\X-TITLE.dwg Layout: Model

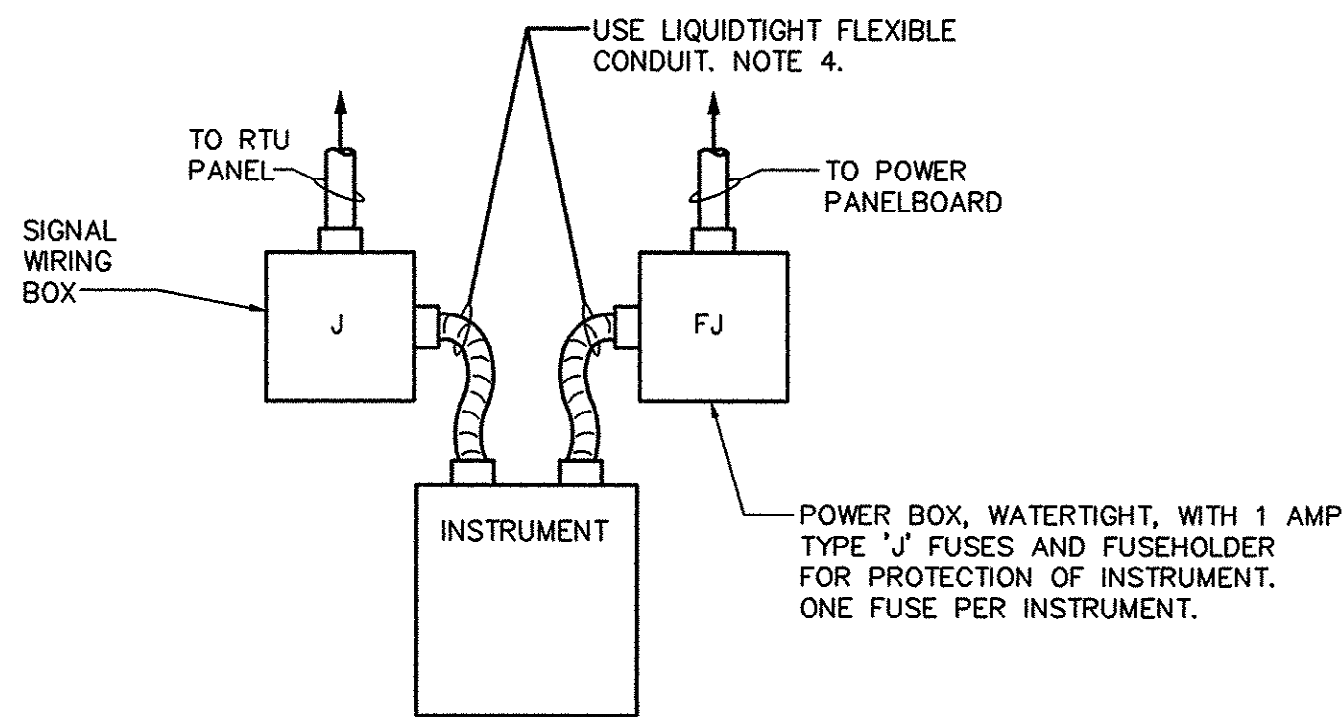


TYPICAL INSTRUMENT CONNECTION REQUIREMENTS

- NOT TO SCALE
NOTES:
1. ALL BOXES SHALL BE CAST METAL TYPE WITH HUBS.
2. ALL CONNECTIONS SHALL BE WATERTIGHT.
3. SUPPORT BOXES INDEPENDENTLY OF INSTRUMENT.
4. PRIOR TO RUNNING FINAL CONDUIT VERIFY SIZE OF CONDUIT HUBS IN INSTRUMENTATION ENCLOSURE.

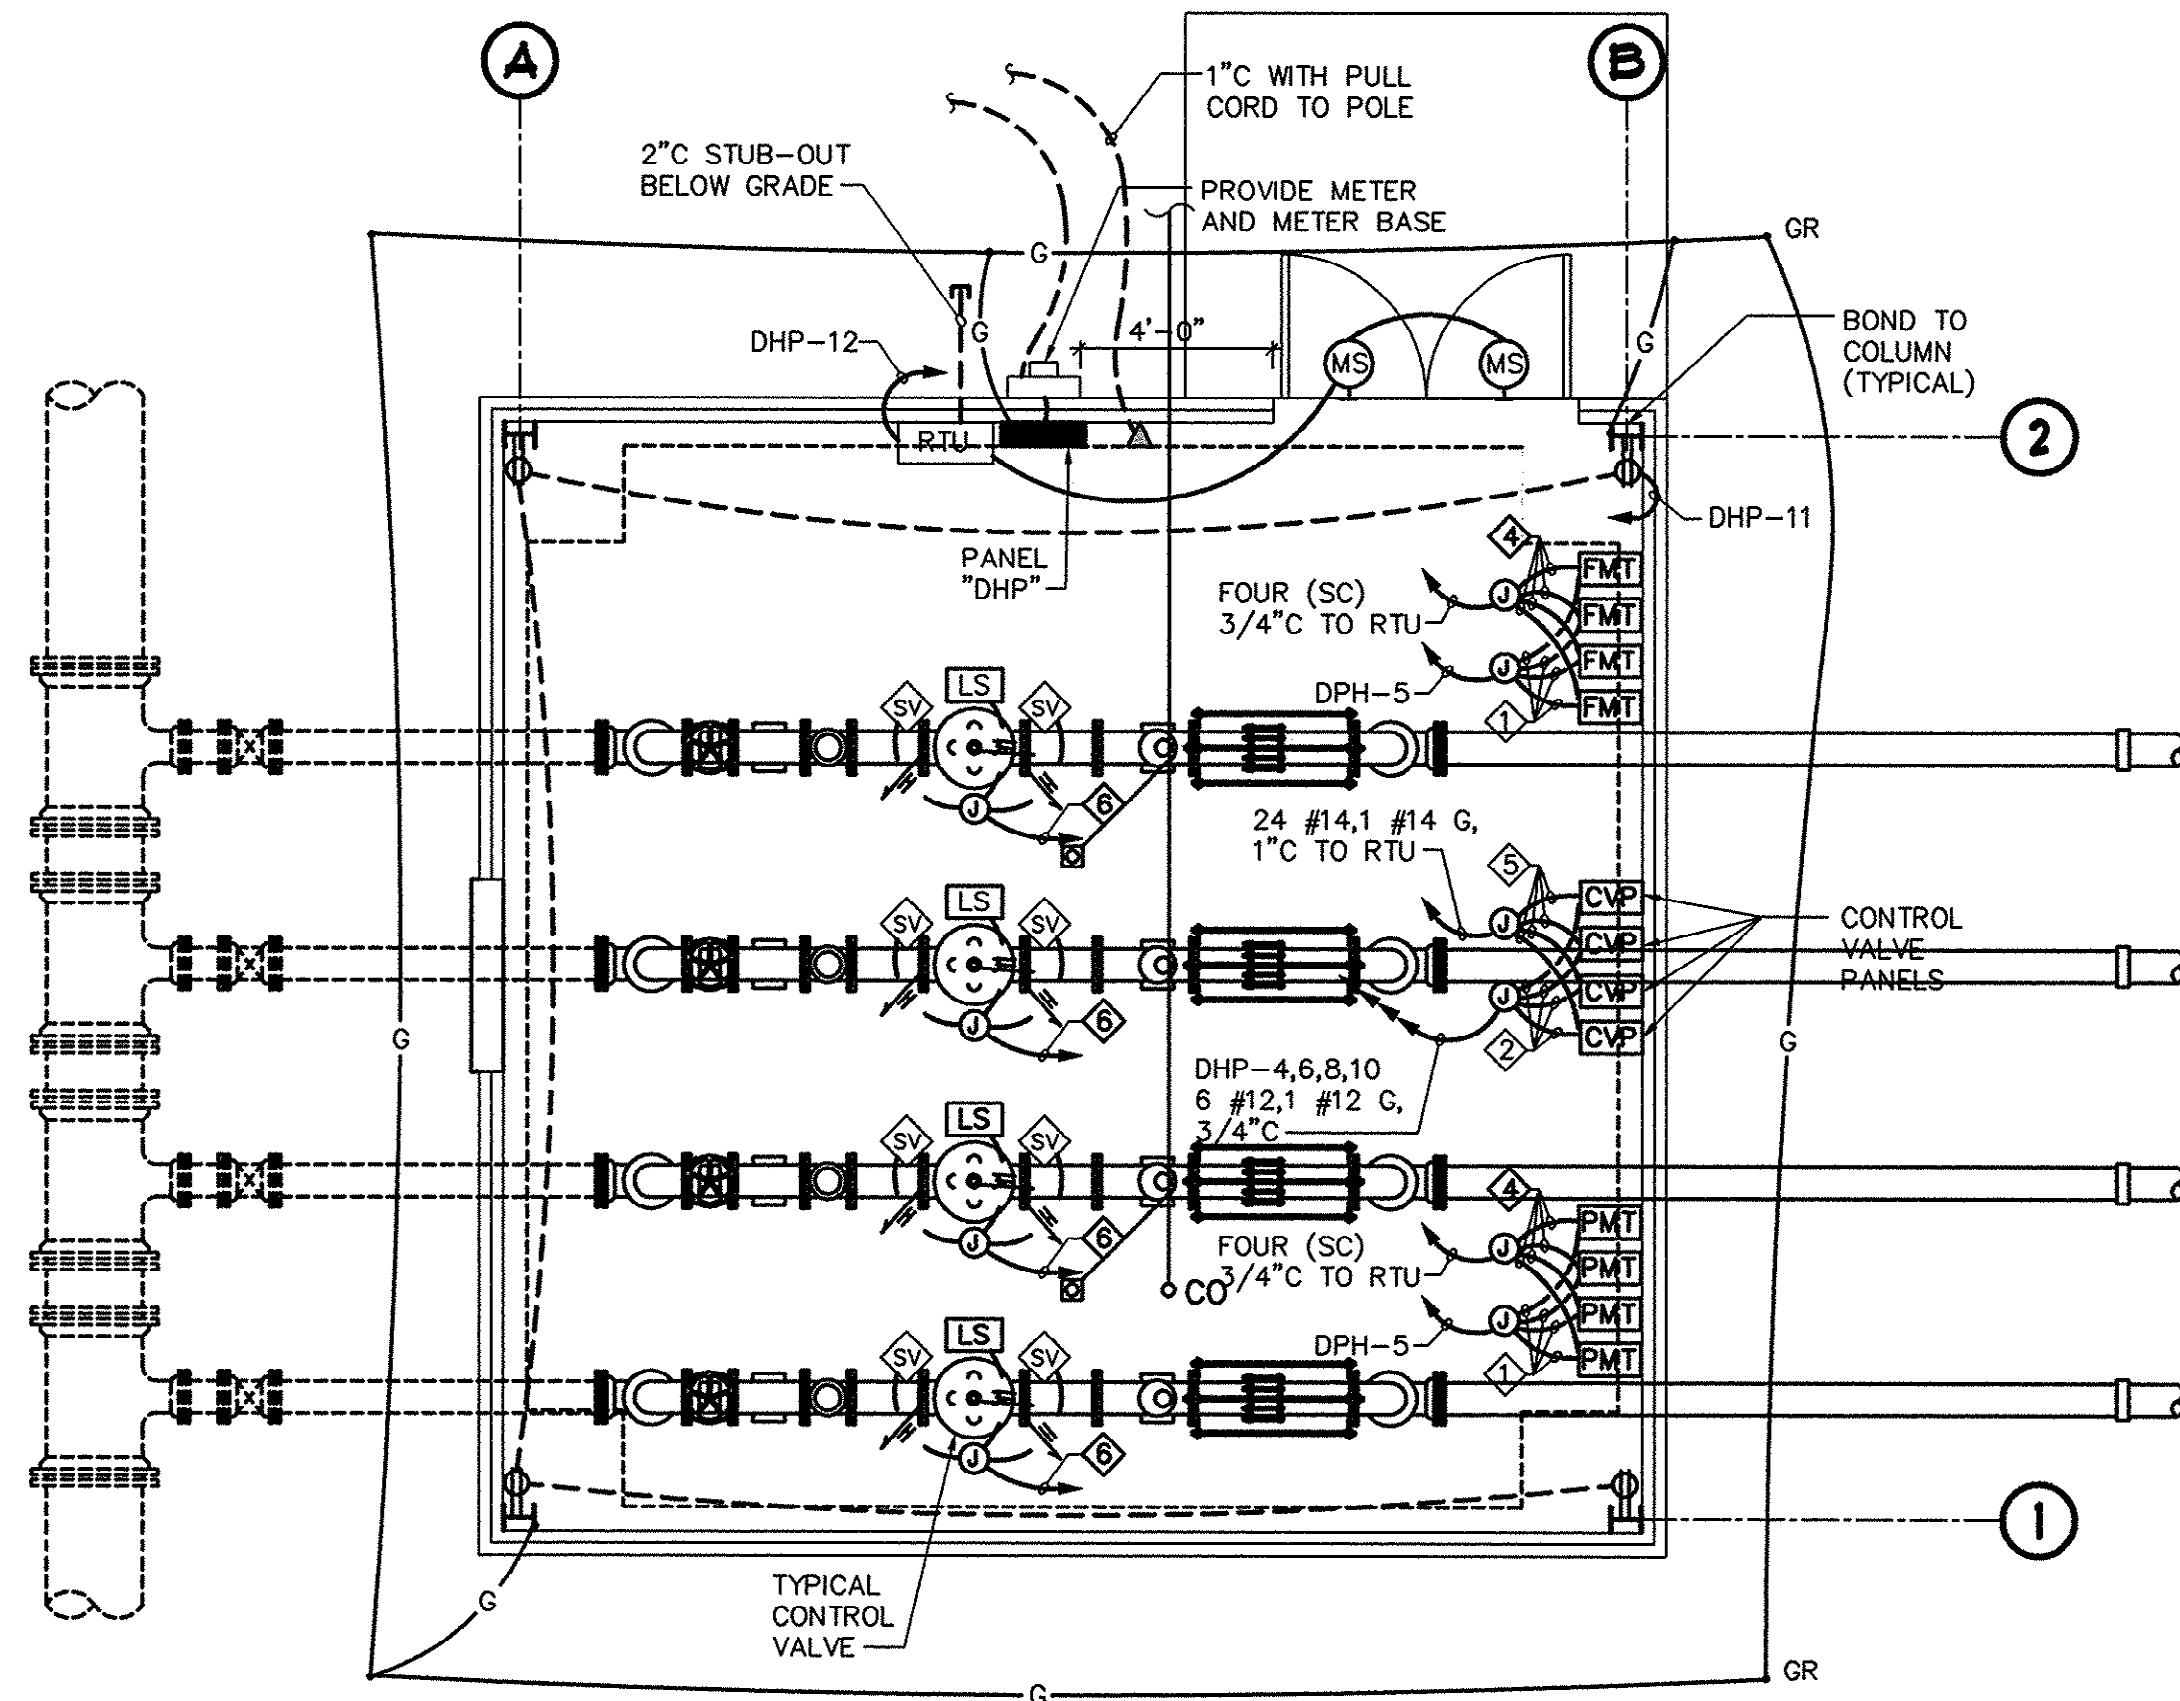

DISTRIBUTION HEATER LAYOUT BUILDING PLAN POWER AND SIGNAL PLAN


SCALE: 1/4" = 1'-0"

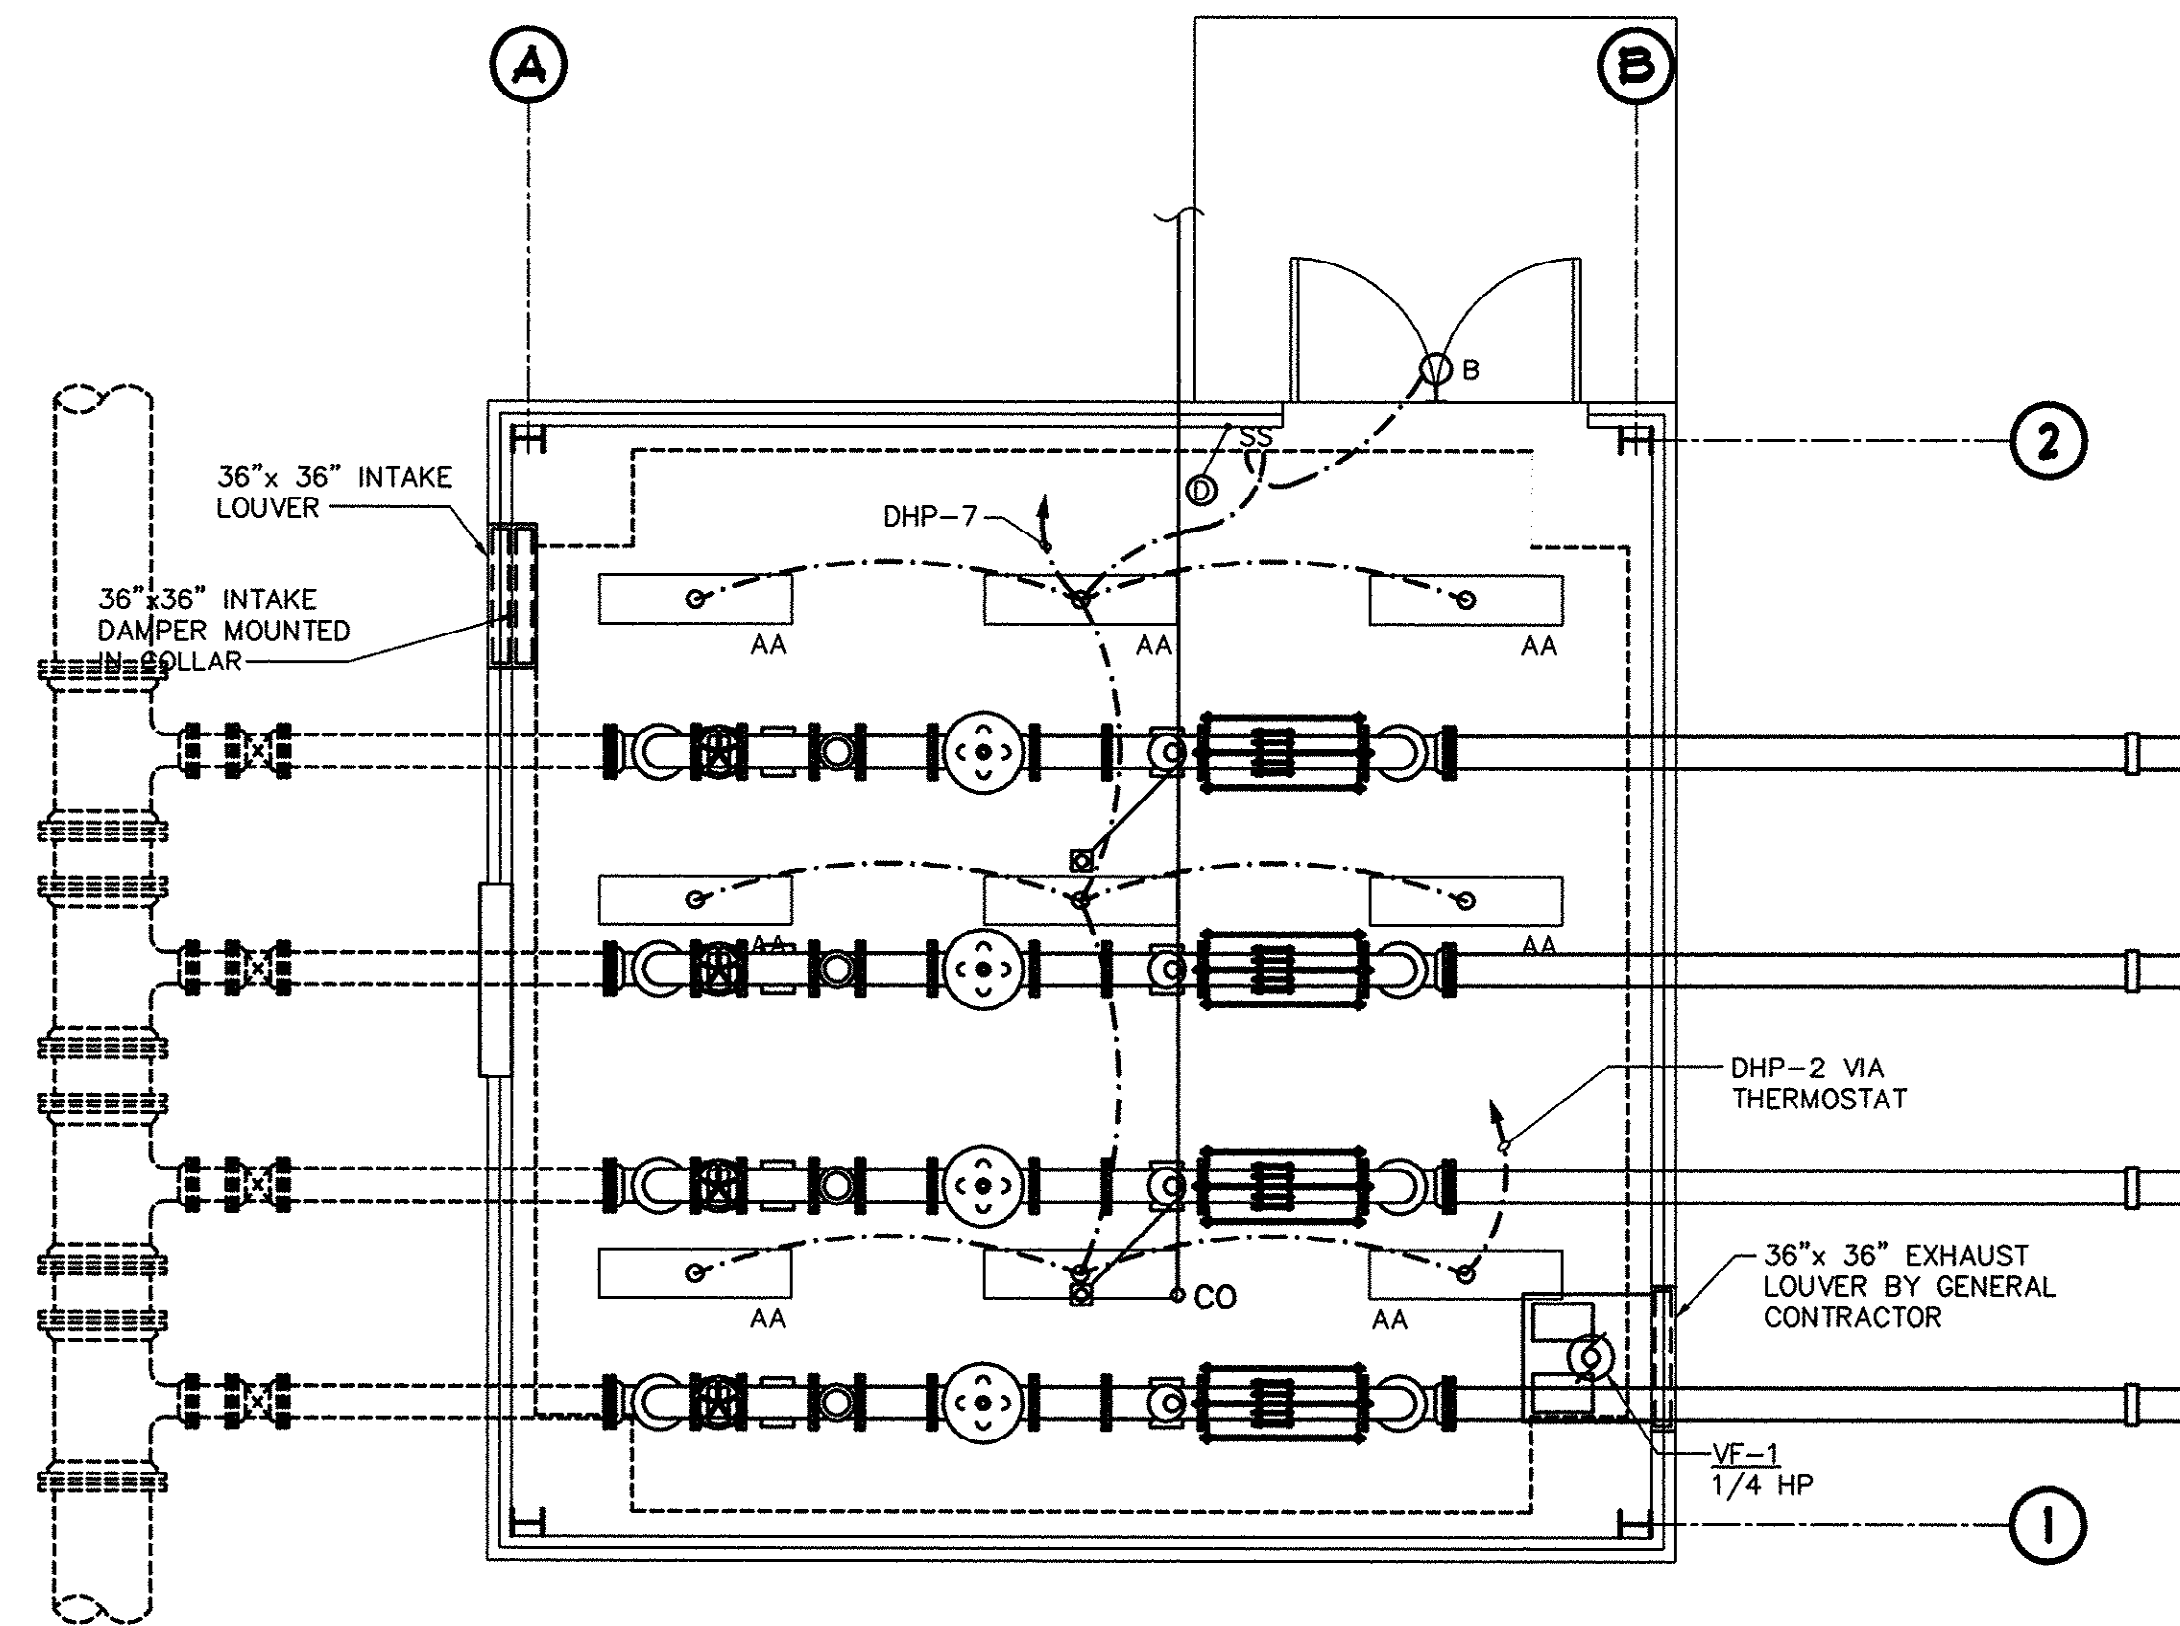

DISTRIBUTION HEATER LAYOUT BUILDING PLAN POWER AND SIGNAL PLAN

SCALE: 1/4" = 1'-0"

LOAD (KVA)			DESCRIPTION	WIRE SIZE	BKBR RATG	CKT. NO.	CKT. NO.	BKBR RATG	WIRE SIZE	DESCRIPTION	LOAD (KVA)	
PH1	PH2	PH1									PH2	
0.0	0.0		LIGHTNING ARRESTER	8	30/2	1	2	15/1	-	VF-1 - 1/4 HP	0.0	0.0
0.1	1.1		PRESS. TRANSMITTER	12	15/1	5	4	15/1	-	C.V. PANEL #1	0.2	0.2
0.1	0.8		LIGHTING	12	20/1	7	6	15/1	-	C.V. PANEL #2	0.2	0.2
0.0	0.0		FLOW METER	12	20/1	9	10	15/1	-	C.V. PANEL #4	0.2	0.2
0.0	0.0		RECEPTACLE	12	20/1	11	12	15/1	-	RTU	0.0	0.0
0.0	0.0		SPARE	-	20/1	13	14	20/1	-	SPARE	0.0	0.0
0.0	0.0		SPARE	-	20/1	15	16	20/1	-	SPARE	0.0	0.0
0.0	0.0		SPARE	-	20/1	17	18	20/1	-	SPARE	0.0	0.0
0.0	0.0		SPARE	-	20/1	19	20	20/1	-	SPARE	0.0	0.0
0.0	0.0		SPARE	-	20/1	21	22	20/1	-	SPARE	0.0	0.0
0.0	0.0		SPARE	-	20/1	23	24	20/1	-	SPARE	0.0	0.0
0.0	0.0		SPARE	-	20/1	25	26	20/1	-	SPARE	0.0	0.0
0.0	0.0		SPARE	-	20/1	27	28	20/1	-	SPARE	0.0	0.0
0.0	0.0		SPARE	-	20/1	29	30	20/1	-	SPARE	0.0	0.0
				-		31	32	-	-			
				-		33	34	-	-			
				-		35	36	-	-			
				-		37	38	-	-			
				-		39	40	-	-			
				-		41	42	-	-			
TYPE: BRANCH CIRCUIT												
MOUNTING: SURFACE												
SUPPLY: 120/240V, 1-PH, 3W												
MAINS: 100A MCB												
SCIR: 10,000A												
NOTES:												
1. PROVIDE EQUIPMENT GROUND BUS.												
2. SUITABLE FOR USE AS SERVICE ENTRANCE.												

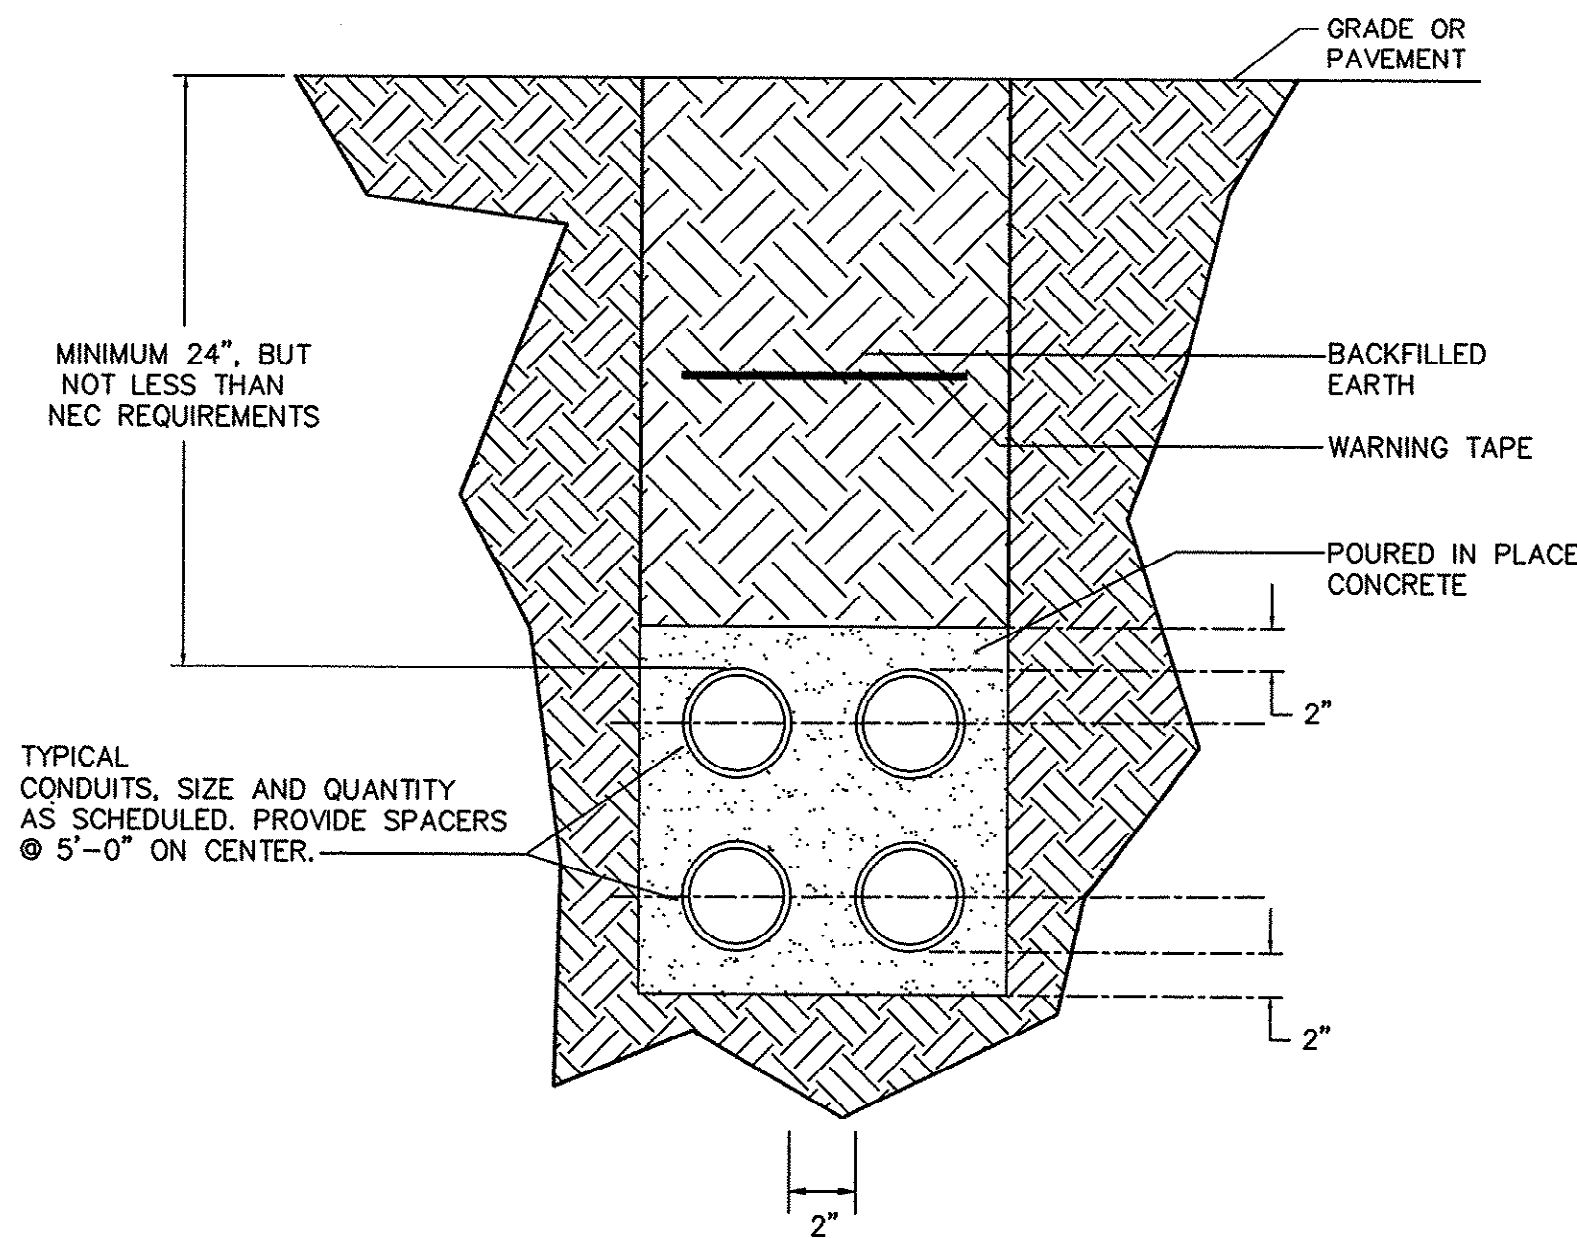

TYPICAL SECTION THROUGH MAJOR CONDUIT RUN

NOT TO SCALE

NOTES:


1. CONCRETE ENCASUREMENT IS ONLY REQUIRED AS MARKED ON SITE PLAN SHEET E5, FOR MAIN CONDUIT RUNS.

THESE DRAWINGS REFLECT
AS-BUILT
CONDITIONS


REVIEWED BY: _____ DATE _____
INSPECTIONS

REVIEWED BY: _____ DATE _____
ENGINEERING

GRAND STRAND WATER AND SEWER AUTHORITY

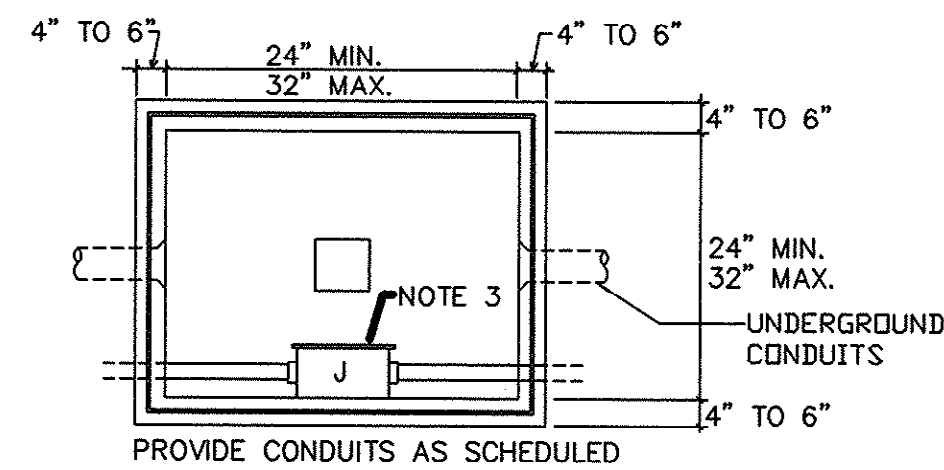

PLAN - (COVER REMOVED)

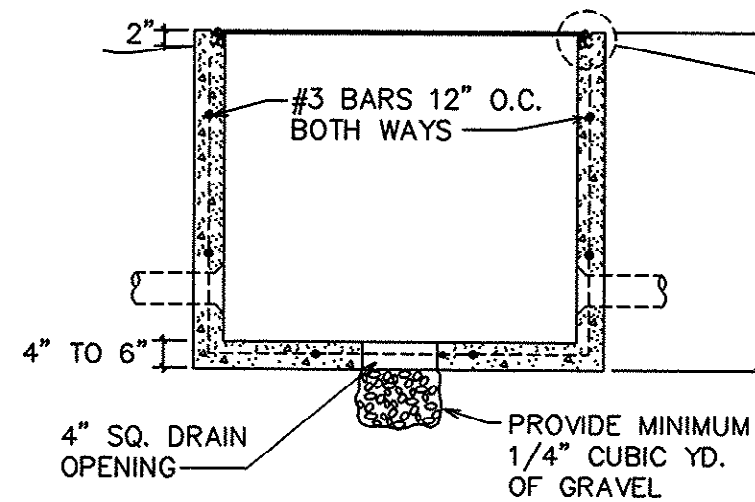


SECTION

TYPICAL HANDHOLE "HH" DETAILS

NOT TO SCALE

NOTES:

1. PRECAST CONCRETE HANDHOLES ARE ACCEPTABLE PROVIDED THAT THEY ARE BUILT IN ACCORDANCE WITH SPECIFICATIONS AND REQUIREMENTS SHOWN IN THIS DETAIL.
2. EXACT DIMENSIONS OF HANDHOLES SHALL BE AS REQUIRED TO MEET N.E.C. REQUIREMENTS FOR STRAIGHT OR ANGLE CABLE PULLS, AS APPLICABLE.
3. PROVIDE 6"x 6"x 6" WATERTIGHT NEMA 4X PULL BOX FOR SIGNAL CIRCUITS (SC" CABLES).

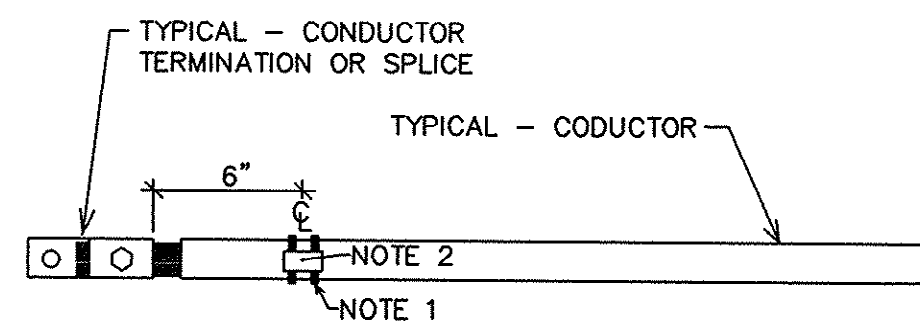


DETAIL OF IDENTIFICATION OF CONDUCTORS

NOT TO SCALE


NOTES:

1. SELF LOCKING T & B NYLON TY-RAP TIE PLACED ON CONDUCTOR AT A LOCATION LEGIBLE FROM THE OPENING OF THE ENCLOSURE.
2. MARK IDENTIFICATION USING T & B #WT163M-3 RED PERMANENT MARKING PEN.

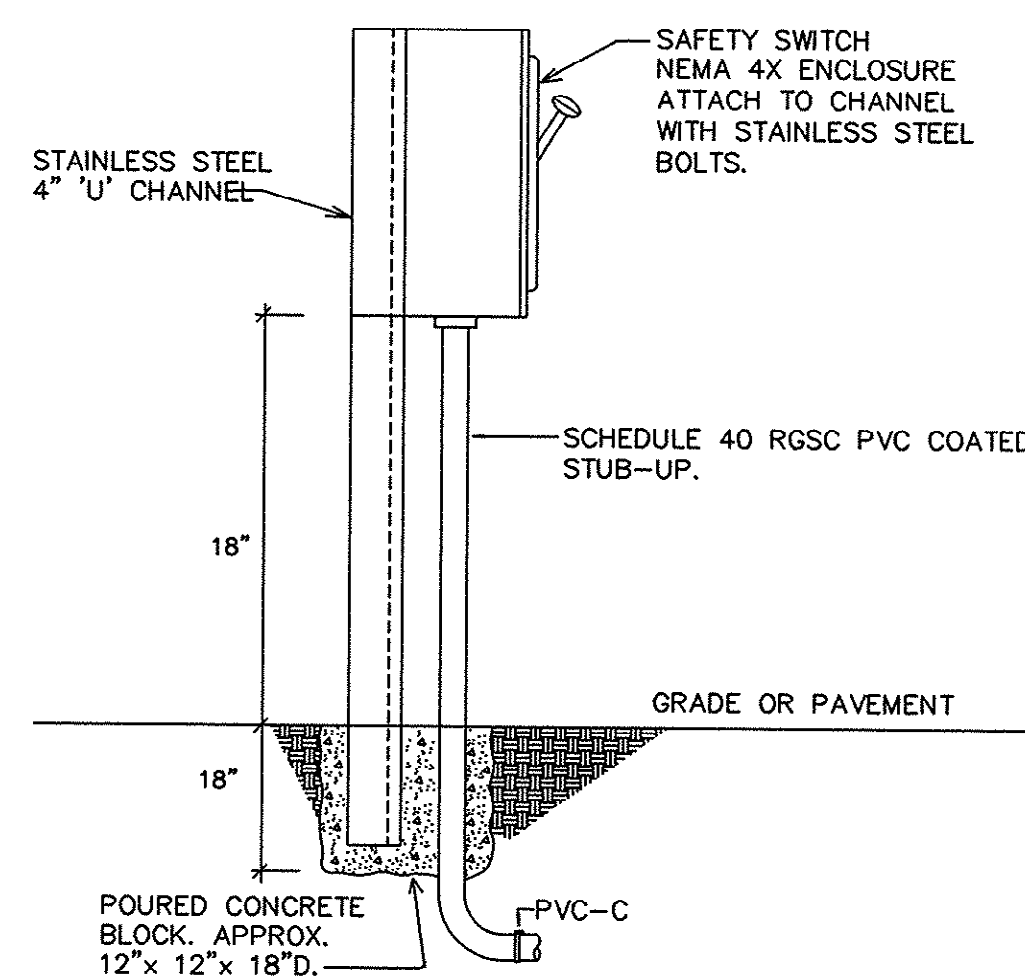


TYPICAL FIELD DISCONNECT SUPPORT


NOT TO SCALE

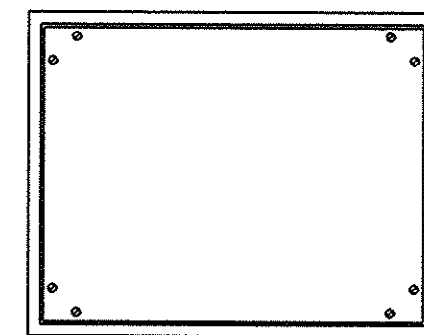

COVER PLATE

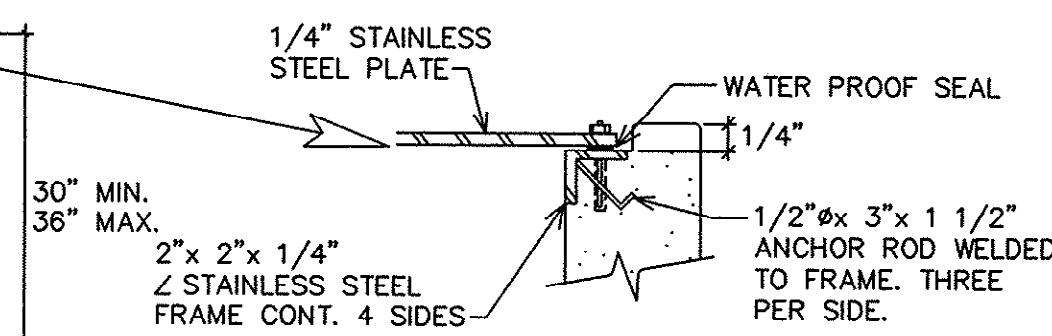

COVER DETAIL


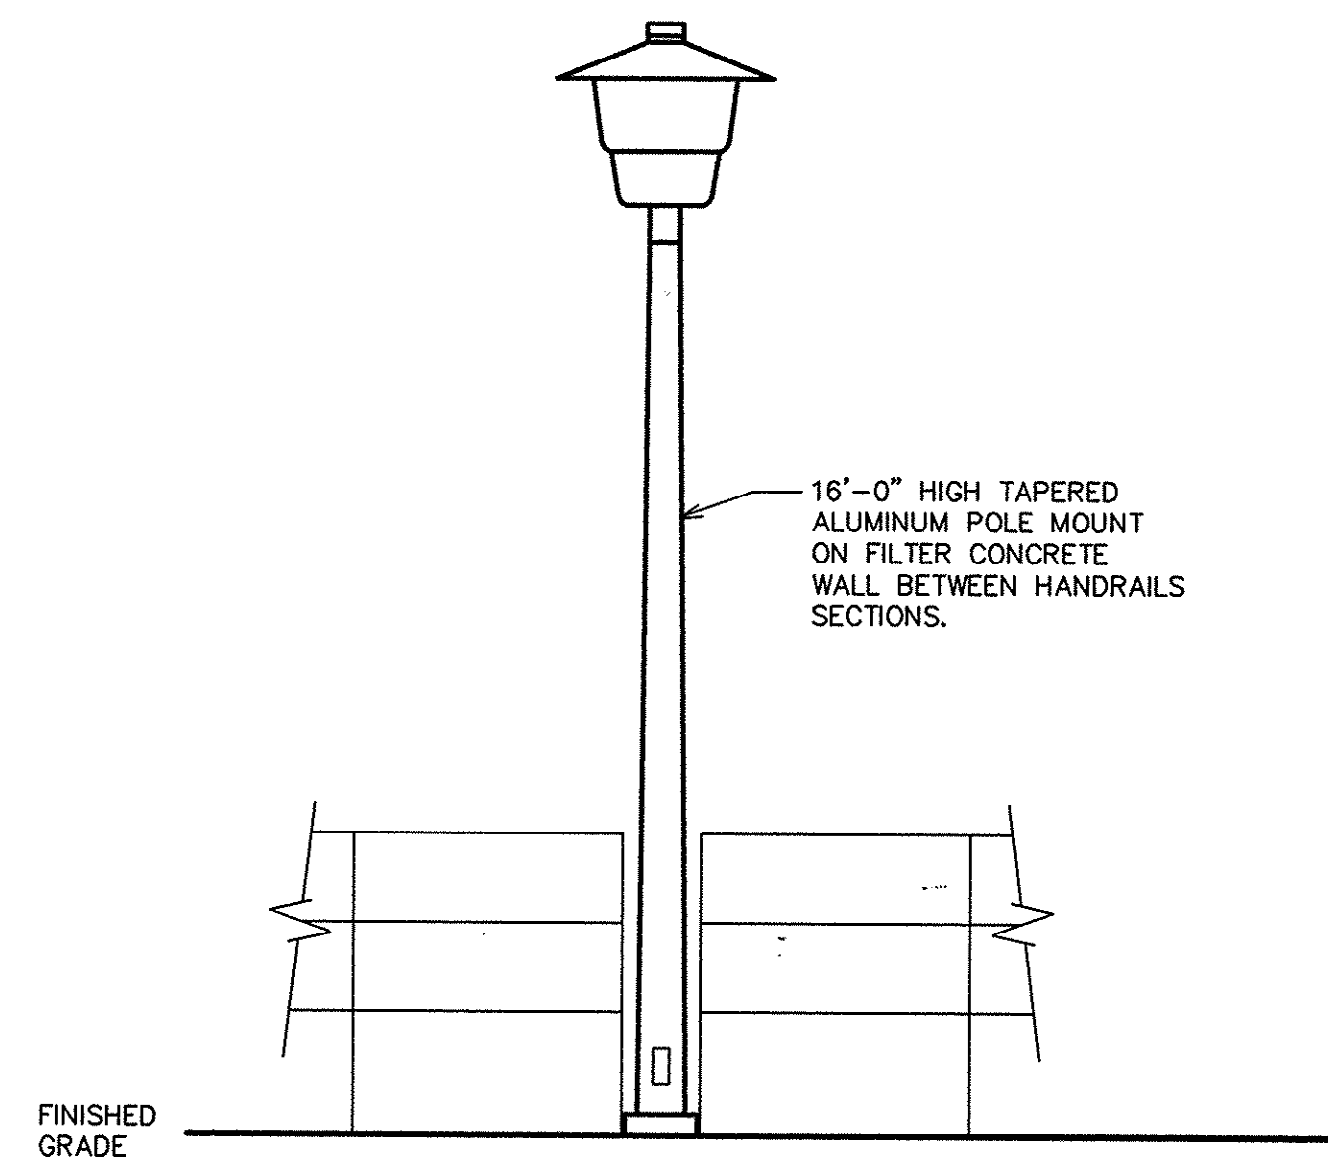


TYPE 'SA' FIXTURE DETAIL

NOT TO SCALE

NOTES:

1. INSTALL FIXTURE ON CONCRETE WALL. COORDINATE WITH GENERAL CONTRACTOR FOR CASTING ANCHOR BOLTS INTO THE CONCRETE WALL.

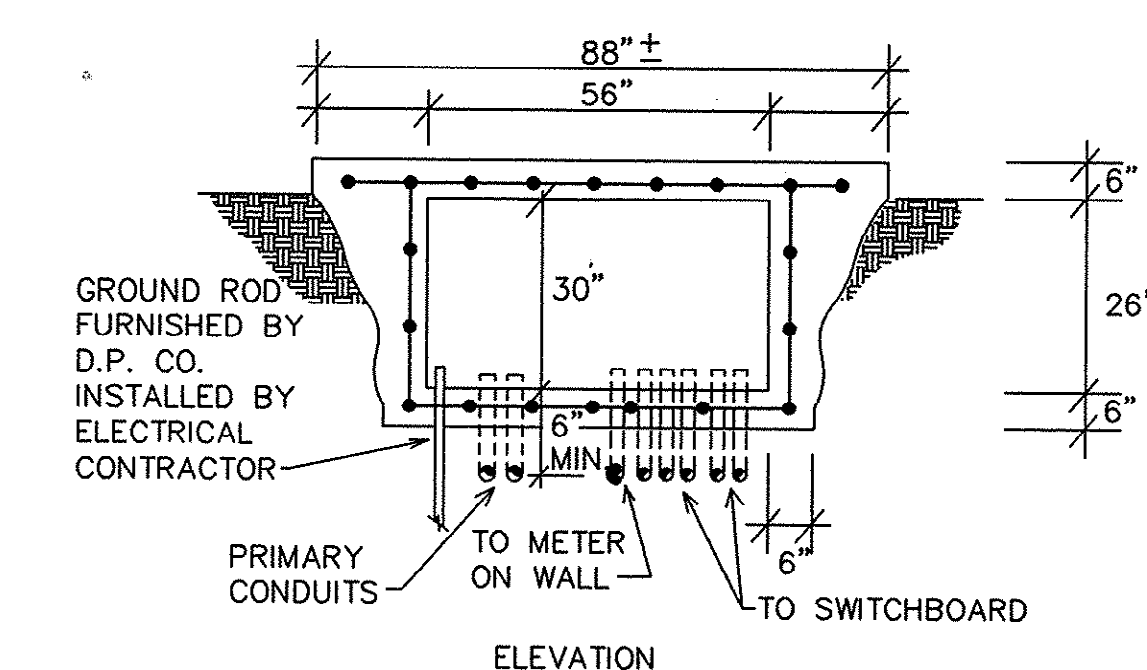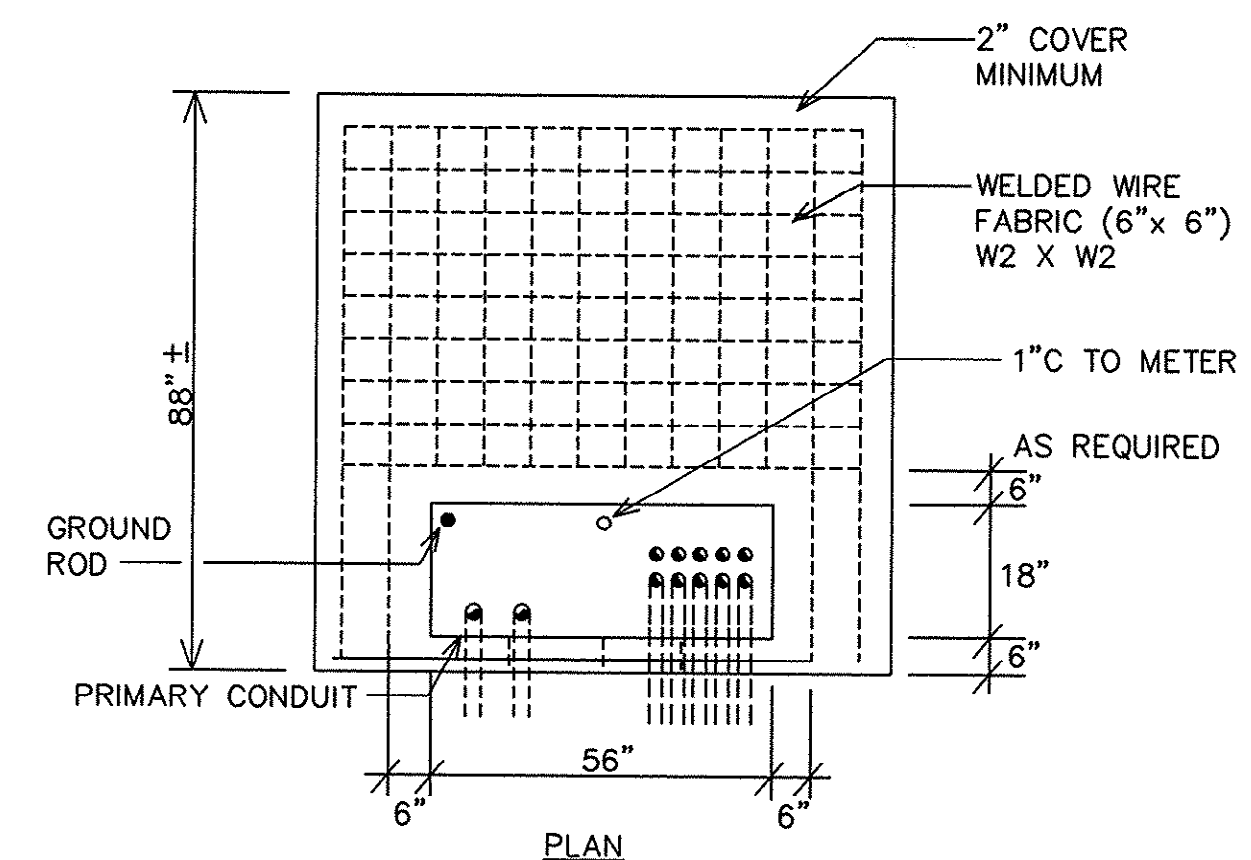

NOTES:


1. CONCRETE TO BE 3,000 LBS. GRADE.
2. ALL DIMENSIONS ARE APPROXIMATE. CONTRACTOR SHALL ADJUST DIMENSIONS TO FIT TRANSFORMER ORDERED.
3. COORDINATE WITH POWER CO. FOR EXACT DIMENSIONS AND PIT CONFIGURATION.

PAD MOUNTED TRANSFORMER

CONCRETE PAD

NOT TO SCALE

REVISIONS	DATE	BY
DESCRIPTION	8/27/01	CAR
AS-BUILT		

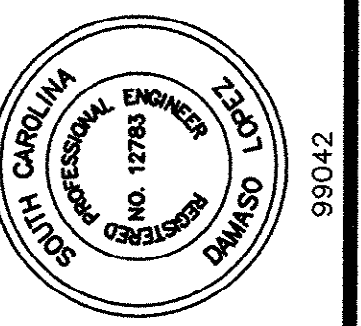

HOBBS, UPCHURCH & ASSOCIATES, P.A.
CONSULTING ENGINEERS
MYRTLE BEACH, SOUTH CAROLINA 29577



**MISCELLANEOUS
DETAILS**

**TIP-TOP TREE FARM
EFFLUENT LAND
APPLICATION PROJECT
GRAND STRAND WATER
AND SEWER AUTHORITY**

DATE: SEPTEMBER 8, 1999
DESIGNED: DL
DRAWN: D.B.M.
CHECKED: DL
SCALE: AS SHOWN
SHEET NO. E10

45-003-052/53